

NOTES



- WHB - 300 TRAPPED WASTE
- SHR - 400 TRAPPED WASTE WITH TOP RODDING ACCESS
- BATH - 400 TRAPPED WASTE
- WC - 1000 SOIL PIPE
- WM - 400 TRAPPED STANDPIPE
- SINK - 400 TRAPPED WASTE
- DW - 400 TRAPPED STANDPIPE
- CYL - 400 TRAPPED STANDPIPE
- BOILER - 300 HEPVO DRY TRAPPED STANDPIPE

LEGEND

- PIPEWORK AT HIGH LEVEL
- PIPEWORK AT LOW LEVEL
- BELOW GROUND DRAINAGE

- AAV - AIR ADMITTANCE VALVE
- CYL - CYLINDER
- DW - DISHWASHER
- FA - FROM ABOVE
- FCU - FAN COIL UNIT
- FG - FLOOR GULLY
- G - PLANTROOM GULLY
- H/L - HIGH LEVEL
- L/L - LOW LEVEL
- PG - CAR PARK GULLY
- RE - RODDING EYE
- RWO - RAIN WATER OUTLET
- RWP - RAIN WATER PIPE
- SHR - SHOWER
- SS - STUB STACK
- SVP - SOIL VENT PIPE
- T/A - TO ABOVE
- T/B - TO BELOW
- VP - VENT PIPE
- WC - WATER CLOSET
- WHB - WASH HAND BASIN
- WM - WASHING MACHINE
- WP - WASTE PIPE

ALL PIPEWORK TO BE DB20 AND ACOUSTICALLY INSULATED

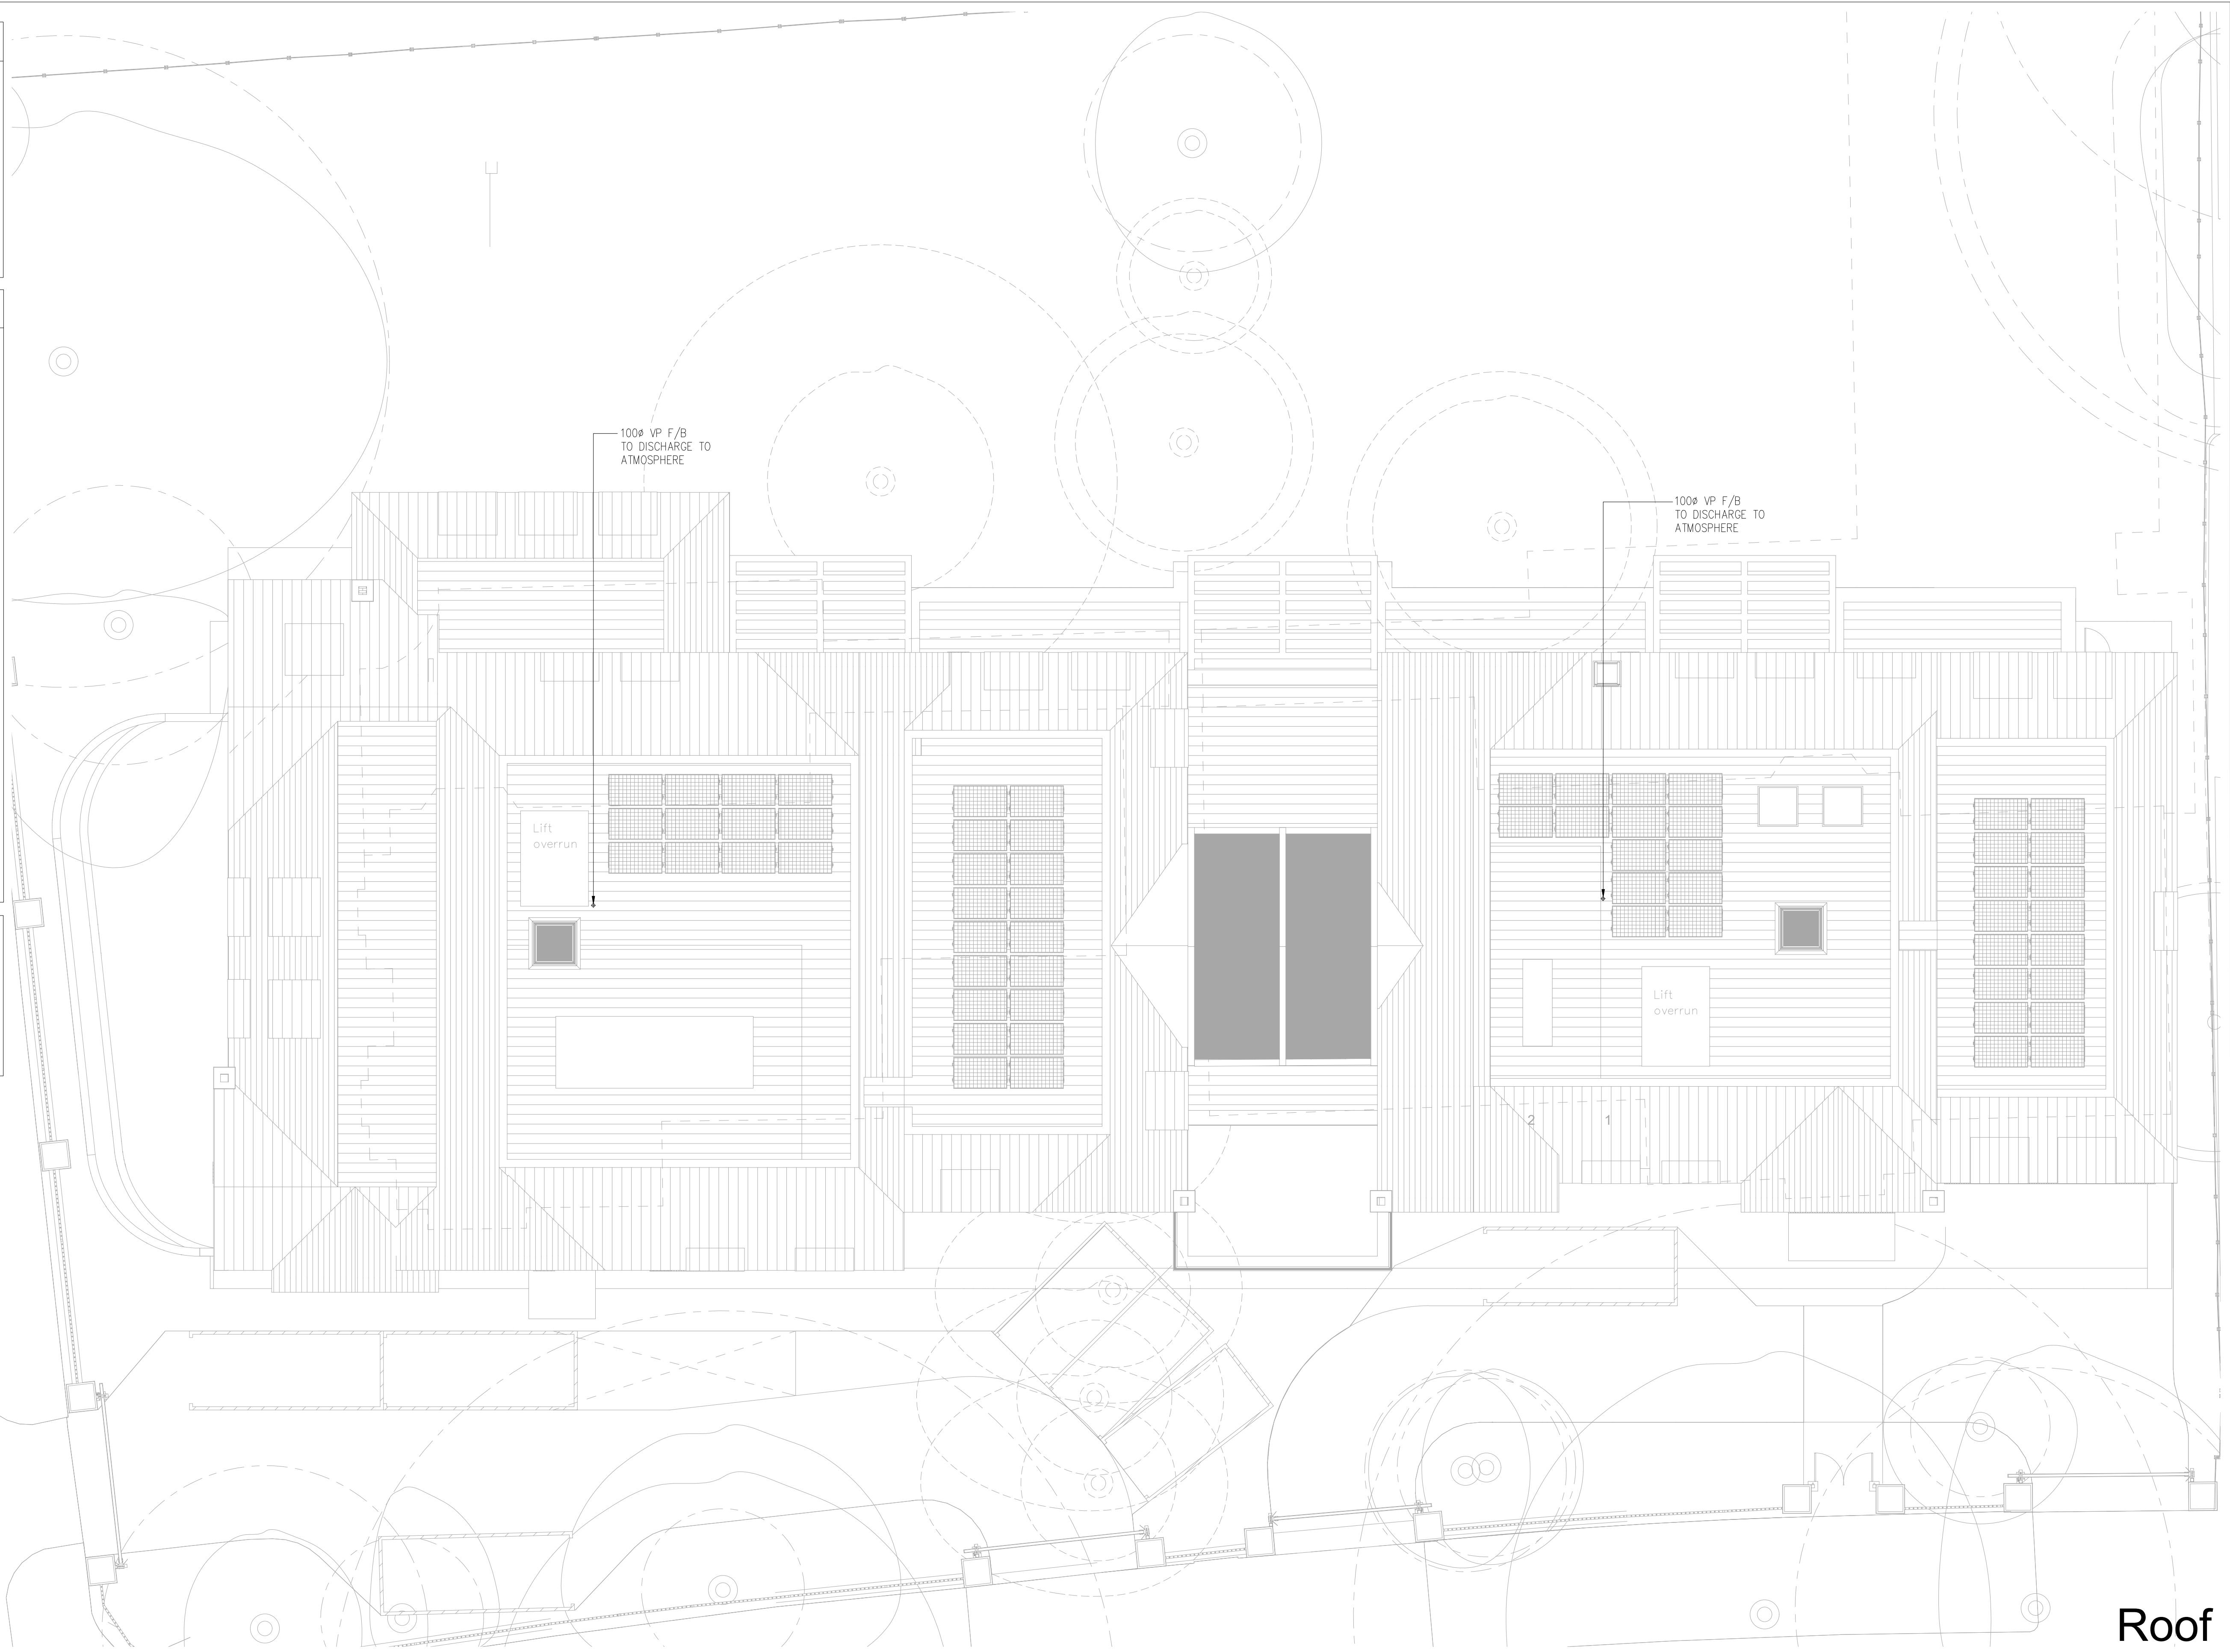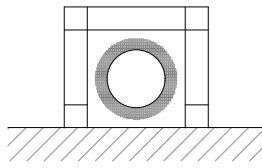

Roof


Note: ALL DIMENSIONS TO BE VERIFIED ON SITE BEFORE SETTING OUT OR MAKING ANY SHOP DRAWINGS. THIS DRAWING IS TO BE READ IN CONJUNCTION WITH THE CONSULTANT ENGINEER'S SPECIFICATION.

Microfilm Scale

3 inches

75 mm

ref./date	REVISIONS
p 30.06.21	PRELIMINARY ISSUE FOR COMMENT
P1 07.09.22	PRELIMINARY ISSUE FOR COMMENT, GA's UPDATED

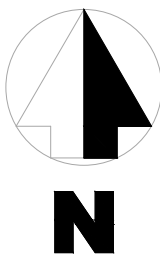

Description

ROOF PLAN
PUBLIC HEALTH SERVICES
ABOVE GROUND DRAINAGE


Architect

WOLF ARCHITECTS
16 Lambton Place
Notting Hill
London, W11 2SH
Tel: 0207 229 3125

Project

44-46 HAMPSTEAD LANE
HIGHGATE
LONDON
N6 4LL

Scale	1:100@A1	Drawn	IC
Date	June 2021	Checked	
Project No.	6678	Services	PH
Dwg No.	106	Rev.	P1

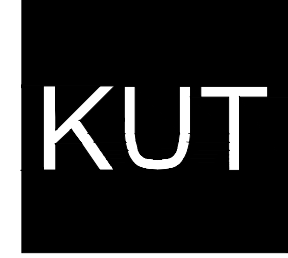

KUT LLP
Suite 303
Ability House
121 Brooker Road
Waltham Abbey
Essex EN9 1JH
Tel: +44(0)20 8348 5171
Email: tkp@kut.co.uk
Web: www.kut.co.uk