


The Copyright of this drawing remains with Fulkers Bailey Russell and is not to be reproduced without written approval. Dimensions are not to be scaled from this drawing. The Contractor is to check all dimensions on site and report any discrepancies to the Contract Administrator. This drawing is to be read in conjunction with all other standard documentation.

Key

Existing plasterboard ceilings to be made good and redecorated

 New MF plasterboard areas . Moisture resistant plasterboard to wet area ie bathrooms and wcs.

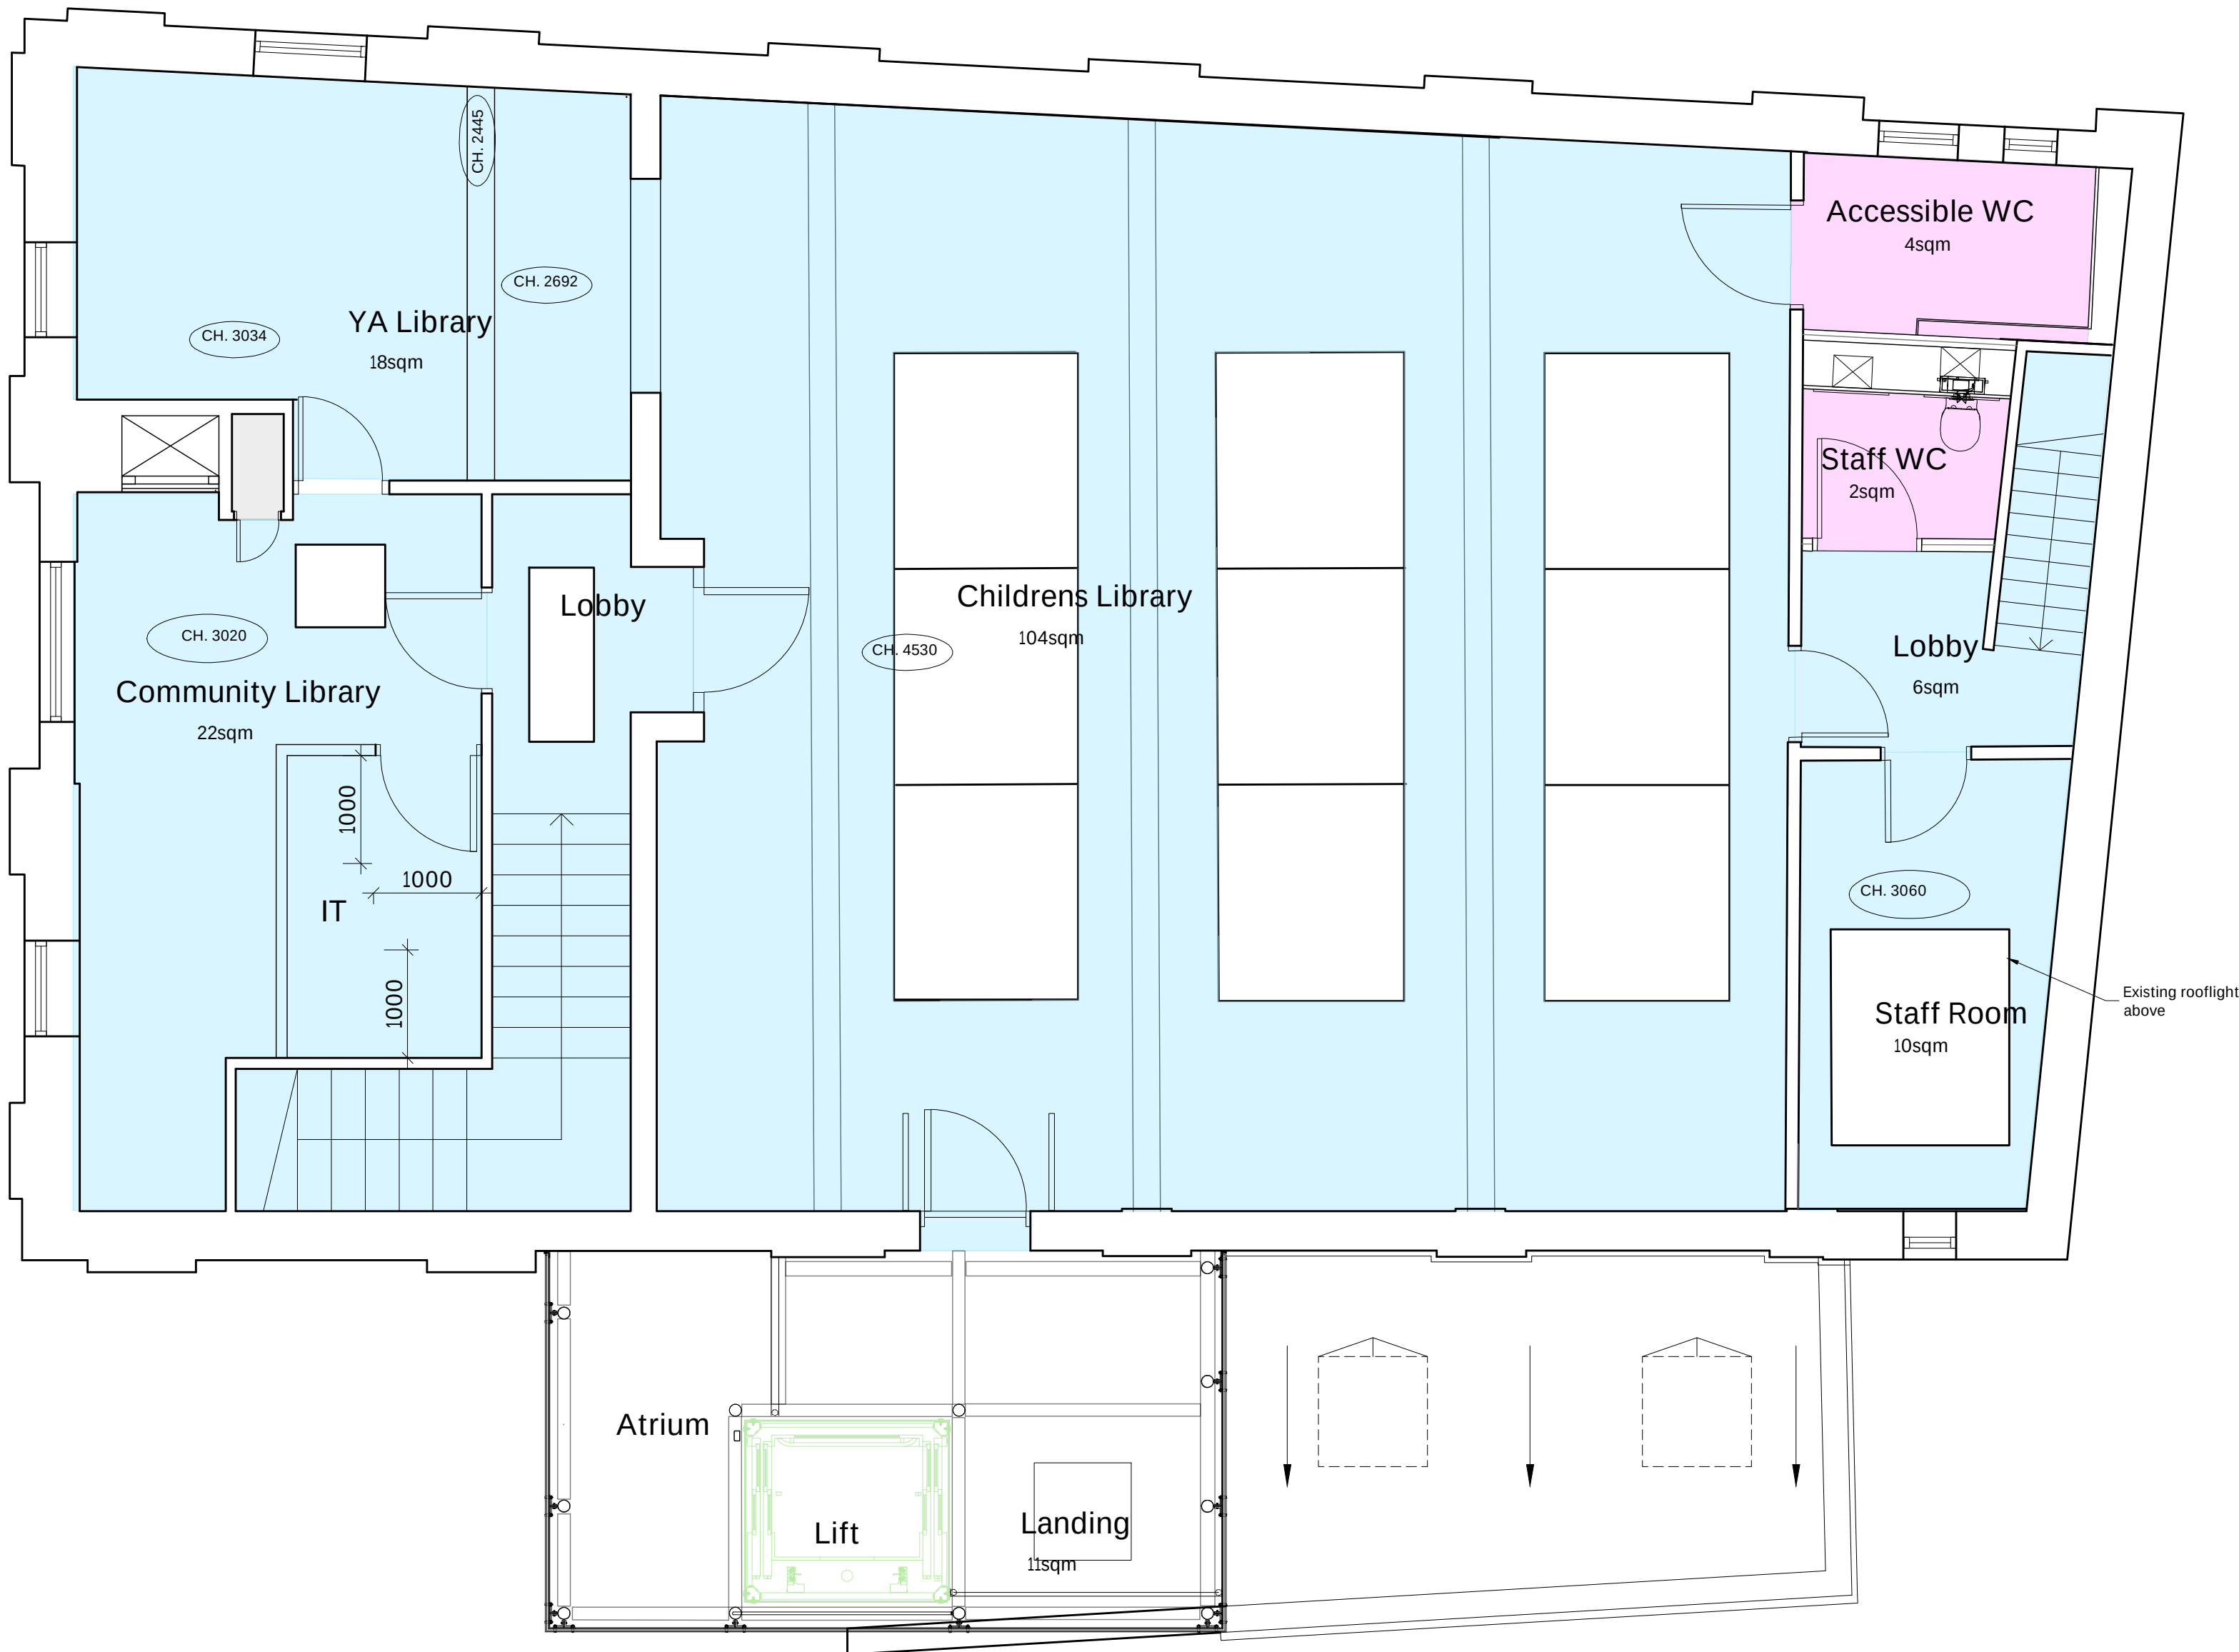

First Floor

RCP

1:50

P02	Issued for Tender	14/10/22	SP
P01	Issued for Tender	30/09/22	SP
rev.	description	date	chkd.

client :

London Borough of Haringey

project : Library Enhancement Works
Muswell Hill Library
Queen's Av, Muswell Hill. London. N10 3PF

drawing title :

First Floor
Reflected Ceiling Plan
As Proposed

FulkersBaileyRussell

london | brighton | bristol | leeds | reading | manchester
info@fulkers.co.uk // www.fulkers.co.uk // 020 3735 5792

drawn: GD	chkd : AK	date: Aug 2022
-----------	-----------	----------------

proj no : 21.3453	scale: 1:50@A1
-------------------	-------------------

identifizier :
3453-FBR-A1-FF-DR-A-223

status:	rev no:
D2 (Tender)	P02