 


SITE LOCATION



Reproduced by permission of Ordnance Survey on behalf of the Controller of Her Majesty's Stationery Office
All rights reserved. © Crown Copyright licence no. 100022432


SITE AREA PLAN



SITE PHOTOGRAPH




SITE LOCATION

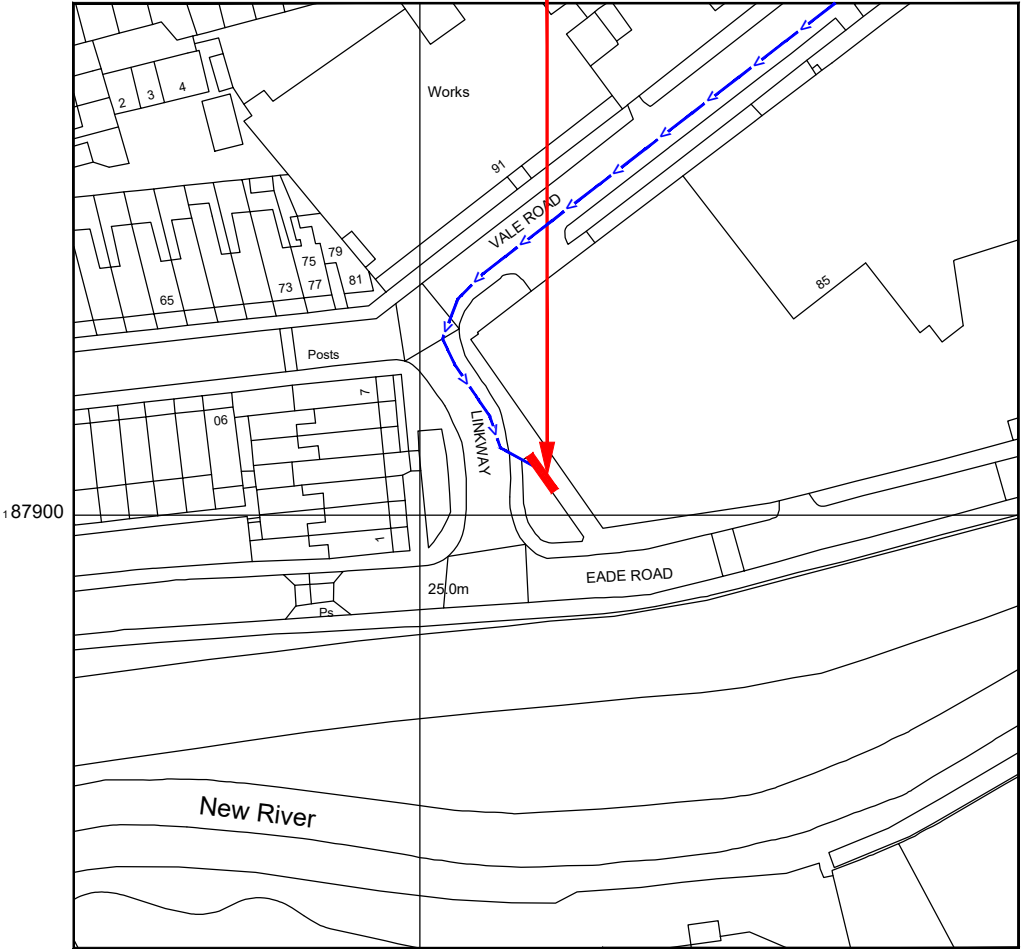

Reproduced by permission of Ordnance Survey on behalf
of the Controller of Her Majesty's Stationery Office
All rights reserved. © Crown Copyright licence no. 100022432

NGR E: 532324 N: 187907

 SITE LOCATION PLAN



GOOGLE MAPS QR CODE

GOOGLE MAPS - <https://goo.gl/maps/hHWrUtpXHiD3WtV6>

GOOGLE STREETVIEW - <https://goo.gl/maps/GiZd26TCp1iqf2BB7>

NOTES:

1. ALL DIMENSIONS IN MM UNLESS OTHERWISE NOTED.

DIRECTIONS TO SITE:
Head south-east. Merge onto N Circular Rd./A406. Keep left to stay on N Circular Rd./A406. Take the A1000 exit towards N Finchley/Barnet/East Finchley. Turn left onto High Rd/A1000. Turn left onto Creighton Ave. At the roundabout, take the 3rd exit onto Coppetts Rd. At the roundabout, take the 3rd exit onto Coppetts Rd. Turn left onto Kings Ave. Turn left onto Queens Ave/A504. At the roundabout, take the 3rd exit onto Muswell Hill/A504. Turn right onto Wightman Rd/B138. Turn left onto Beresford Rd. Turn right onto Green Lanes/A105. Turn left onto St Ann's Rd/B152. At the roundabout, take the 2nd exit onto Hermitage Rd. Turn left onto Vale Rd. Turn left onto Linkway. Follow Linkway and site location is on the left hand side.

Site Provider's
Property Boundary:
Access Route To Site:



Master:	MBNL / EE / H3G:	Project:	Purpose of Issue:	Issue:
M001	H3G	H3G DENSIFICATION STREETWORKS	Planning	A
Date:	03/10/2022	Revision / Upgrade Description:		
Drawn:	CDN	First Issue - Site nomination dated: TBC		
Checked:	J. Glover			
Approved:	J. Glover			



Hutchison 3G UK Limited
Green Park, 450 Longwater Avenue
Reading, RG30 3UR
Tel: 01628 765 000
Fax: 01628 765 001

H3G Base Station Information line:
0845 6043000
Available 8am-8pm Monday to Friday

Design Consultant & Principal Contractor:



Unit E, Madison Place, Northampton Road,
Manchester, M40 5AG
Tel: 0161 785 4500 Fax: 0161 785 4501
Web: www.clarke-telecom.com

Site Name:
LINKWAY STREETWORKS

Site ID:
HGY25540

Address:
LINKWAY,
HARRINGAY WAREHOUSE DISTRICT,
LONDON BOROUGH OF HARINGEY,
GREATER LONDON,
ENGLAND,
N4 1QF


Title:
002 SITE LOCATION PLAN

Project:
H3G DENSIFICATION STREETWORKS

Purpose of Issue:
PLANNING


EE Cell ID:	MBNL Cell ID:	3UK Cell ID:
-	-	HGY25540

Master Drawing No:	Issue:
HGY25540_B35_GA_A	A

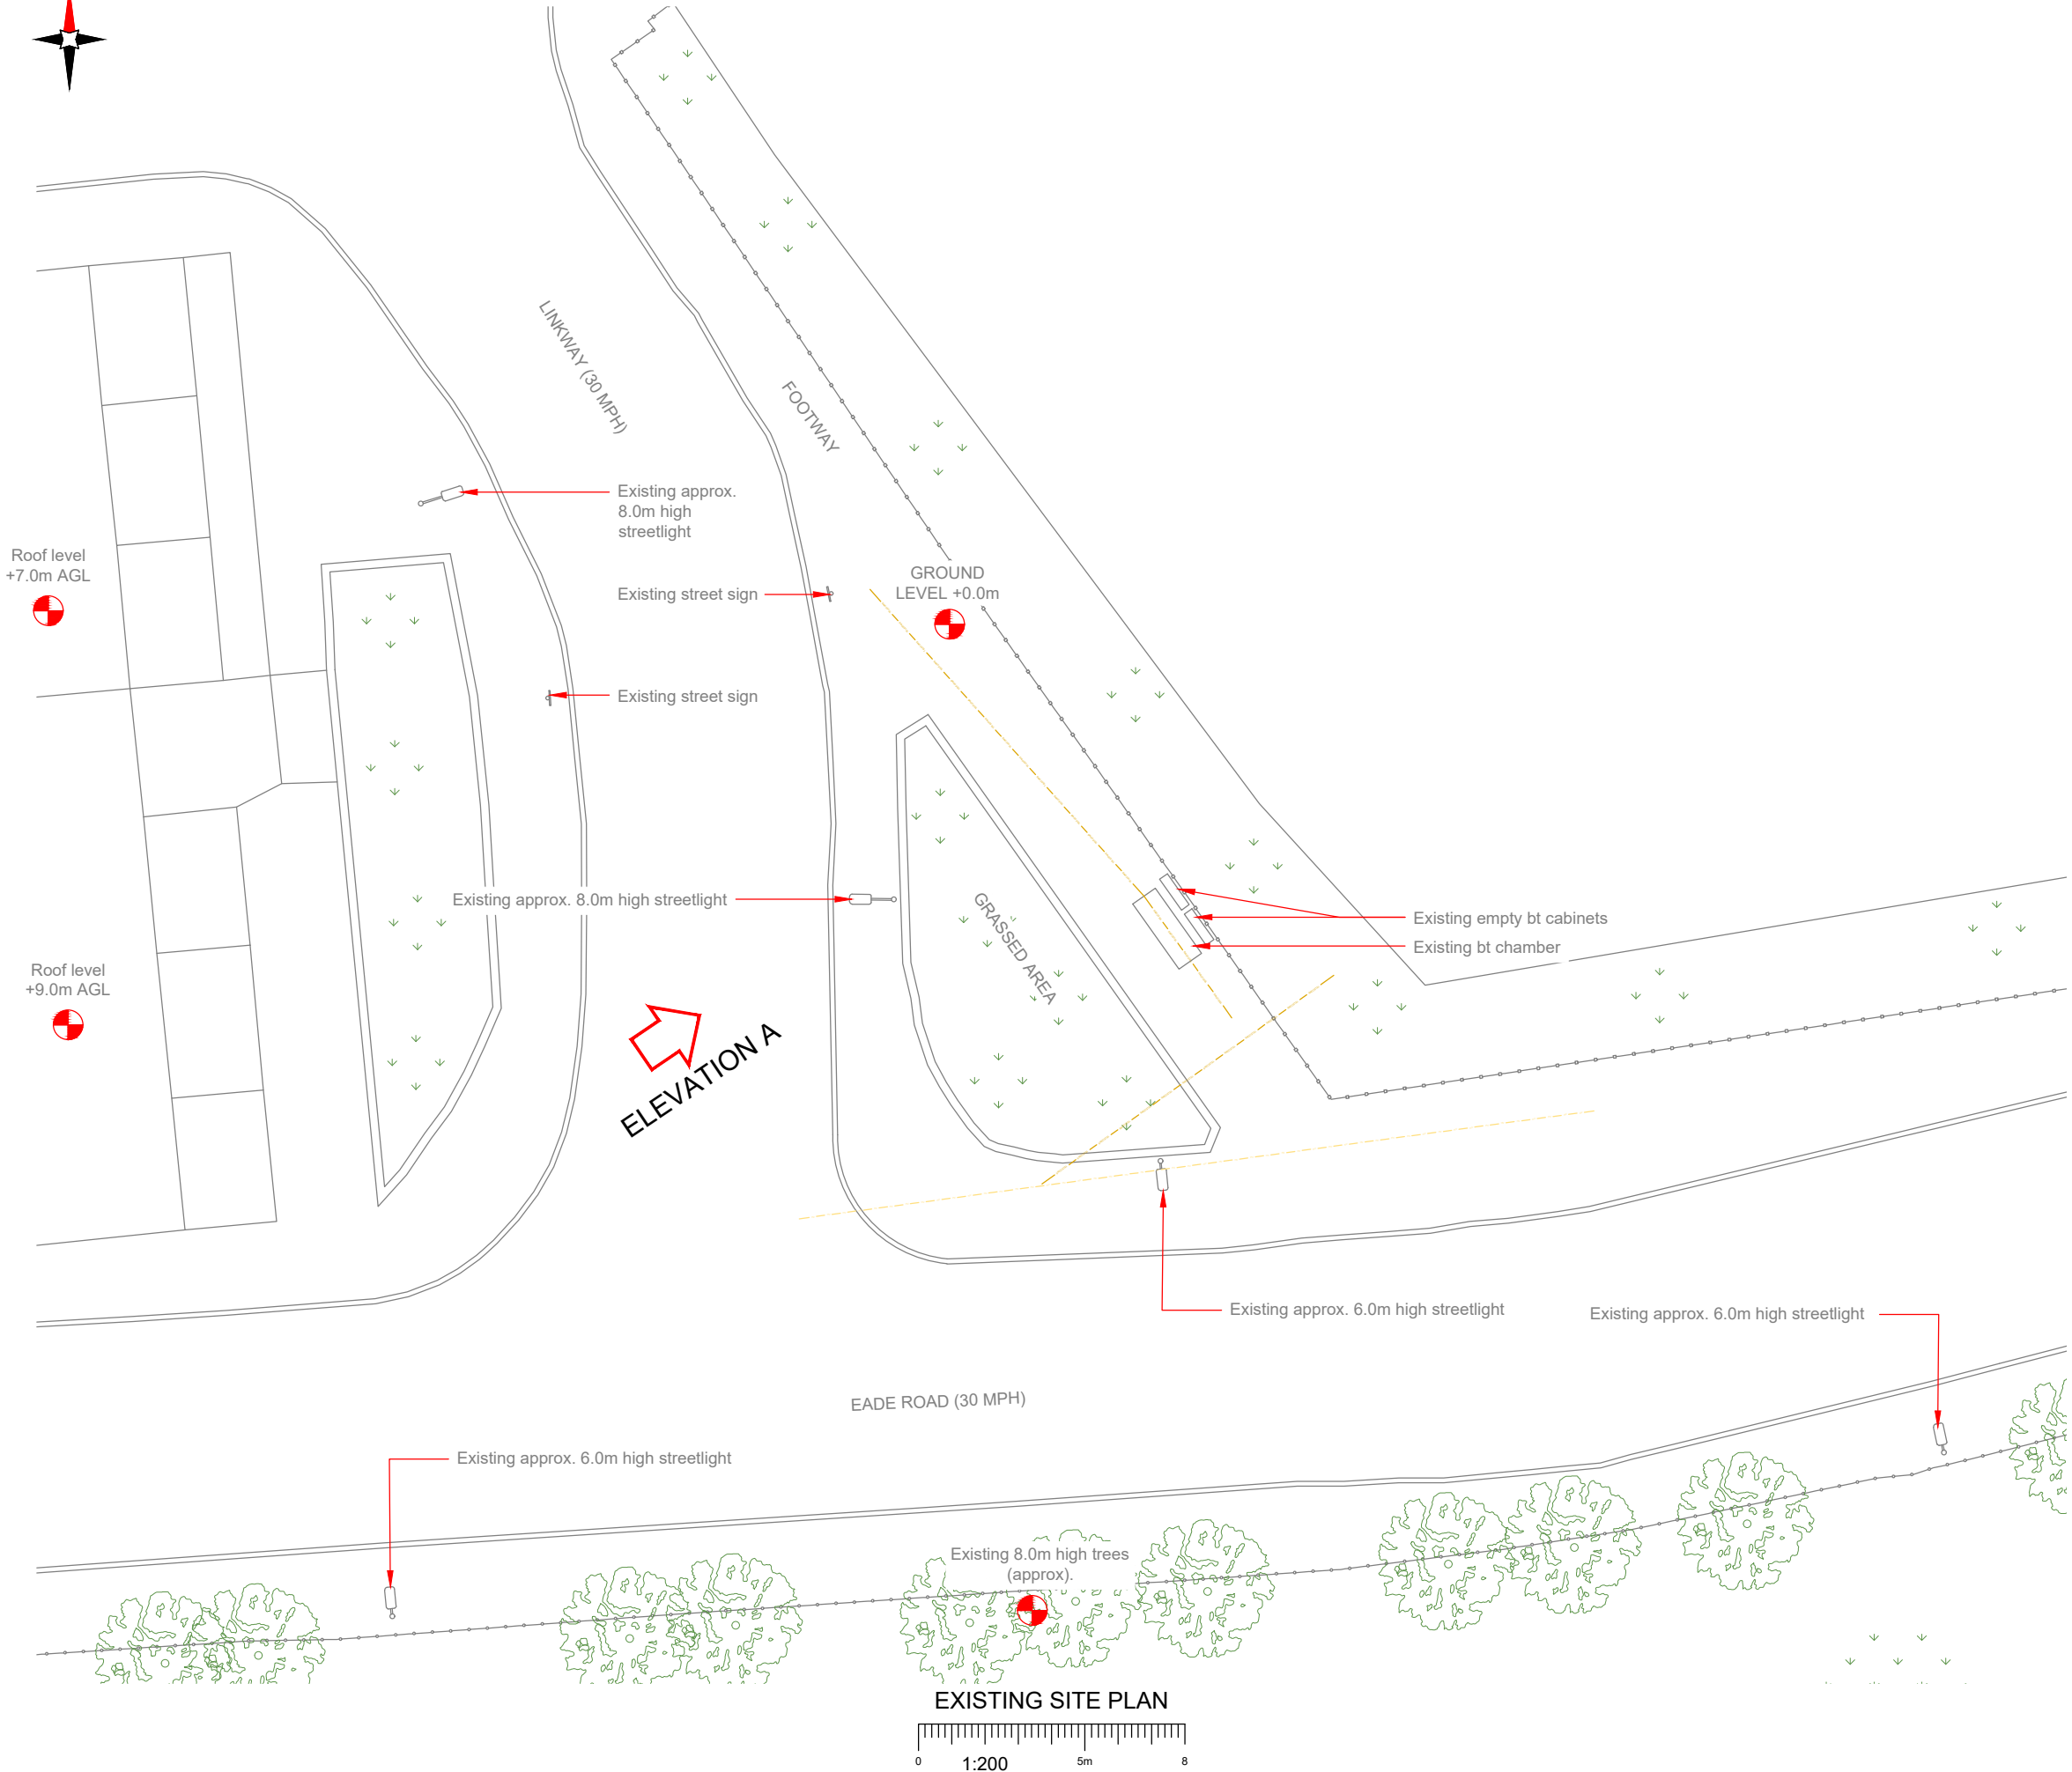

NOTES:

1. ALL DIMENSIONS IN MM UNLESS OTHERWISE NOTED.

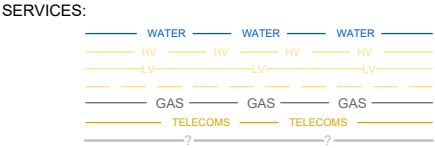

NOTES:

Radar Scan and Stats to be reviewed prior to any build works commencing

Master:	MBNL / EE / H3G:	Project:	Purpose of Issue:	Issue:
M001	H3G	H3G DENSIFICATION STREETWORKS	Planning	A
Date:	03/10/2022	Revision / Upgrade Description:		
Drawn:	CDN	First Issue - Site nomination dated: TBC		
Checked:	J. Glover			
Approved:	J. Glover			



Hutchison 3G UK Limited
Green Park, 450 Longwater Avenue
Reading, RG30 3UR
Tel: 01628 765 000
Fax: 01628 765 001

H3G Base Station Information line:
0845 6043000
Available 8am-8pm Monday to Friday

Design Consultant & Principal Contractor:


Unit E, Madison Place, Northampton Road,
Manchester, M40 5AG
Tel: 0161 785 4500 Fax: 0161 785 4501
Web: www.clarke-telecom.com

Site Name:	LINKWAY STREETWORKS		
Site ID:	HGY25540		
Address:	LINKWAY, HARRINGAY WAREHOUSE DISTRICT, LONDON BOROUGH OF HARINGEY, GREATER LONDON, ENGLAND, N4 1QF		
Title:	100 EXISTING SITE PLAN		
Project:	H3G DENSIFICATION STREETWORKS		
Purpose of Issue:	PLANNING		
EE Cell ID:	MBNL Cell ID:	3UK Cell ID:	
-	-	HGY25540	
Master Drawing No:			Issue:
HGY25540_B35_GA_A			A

100mm

50mm

10mm

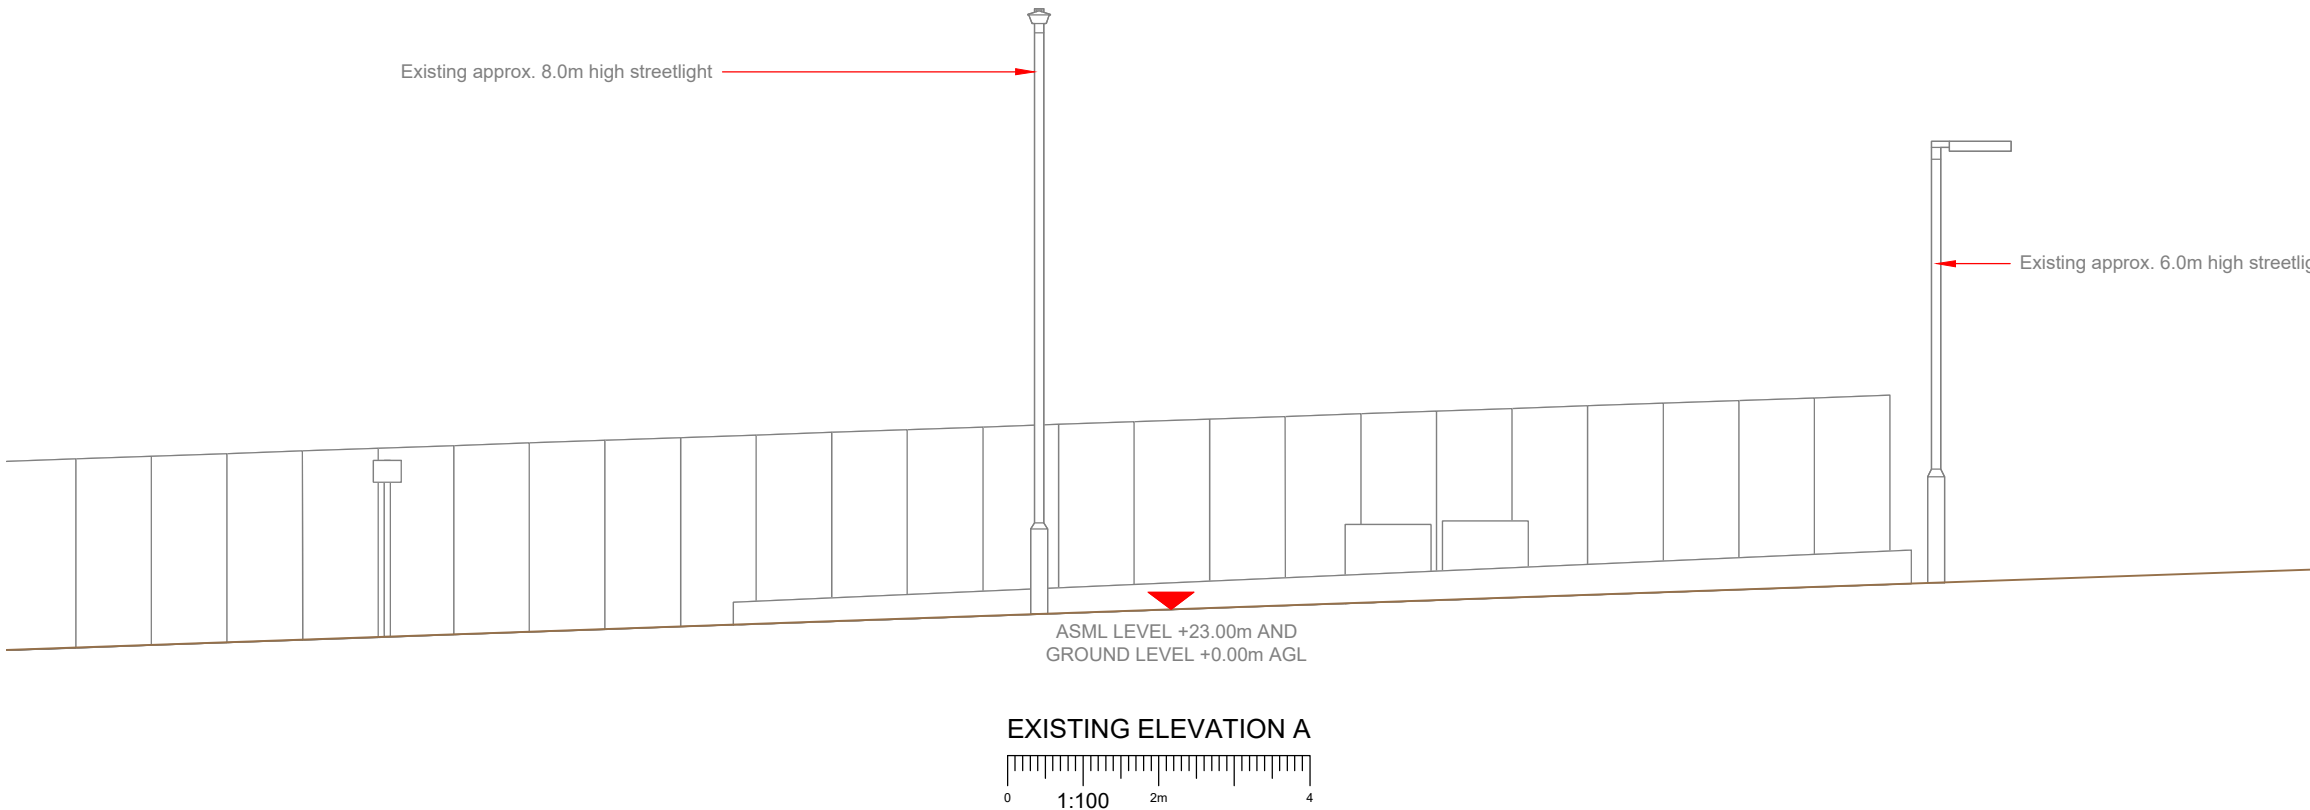

- NOTES:
1. ALL DIMENSIONS IN MM UNLESS OTHERWISE NOTED.

Master:	MBNL / EE / H3G:	Project:	Purpose of Issue:	Issue:
M001	H3G	H3G DENSIFICATION STREETWORKS	Planning	A
Date:	03/10/2022	Revision / Upgrade Description:		
Drawn:	CDN	First Issue - Site nomination dated: TBC		
Checked:	J. Glover			
Approved:	J. Glover			



Hutchison 3G UK Limited
Green Park, 450 Longwater Avenue
Reading, RG30 3UR
Tel: 01628 765 000
Fax: 01628 765 001


H3G Base Station Information line:
0845 6043000
Available 8am-8pm Monday to Friday

Design Consultant & Principal Contractor:

CLARKE telecom

Unit E, Madison Place, Northampton Road,
Manchester, M40 5AG
Tel: 0161 785 4500 Fax: 0161 785 4501
Web: www.clarke-telecom.com

Site Name:	LINKWAY STREETWORKS		
Site ID:	HGY25540		
Address:	LINKWAY, HARRINGAY WAREHOUSE DISTRICT, LONDON BOROUGH OF HARINGEY, GREATER LONDON, ENGLAND, N4 1QF		
Title:	150 EXISTING SITE ELEVATION		
Project:	H3G DENSIFICATION STREETWORKS		
Purpose of Issue:	PLANNING		
EE Cell ID:	MBNL Cell ID:	3UK Cell ID:	
-	-	HGY25540	
Master Drawing No:			Issue:
HGY25540_B35_GA_A			A

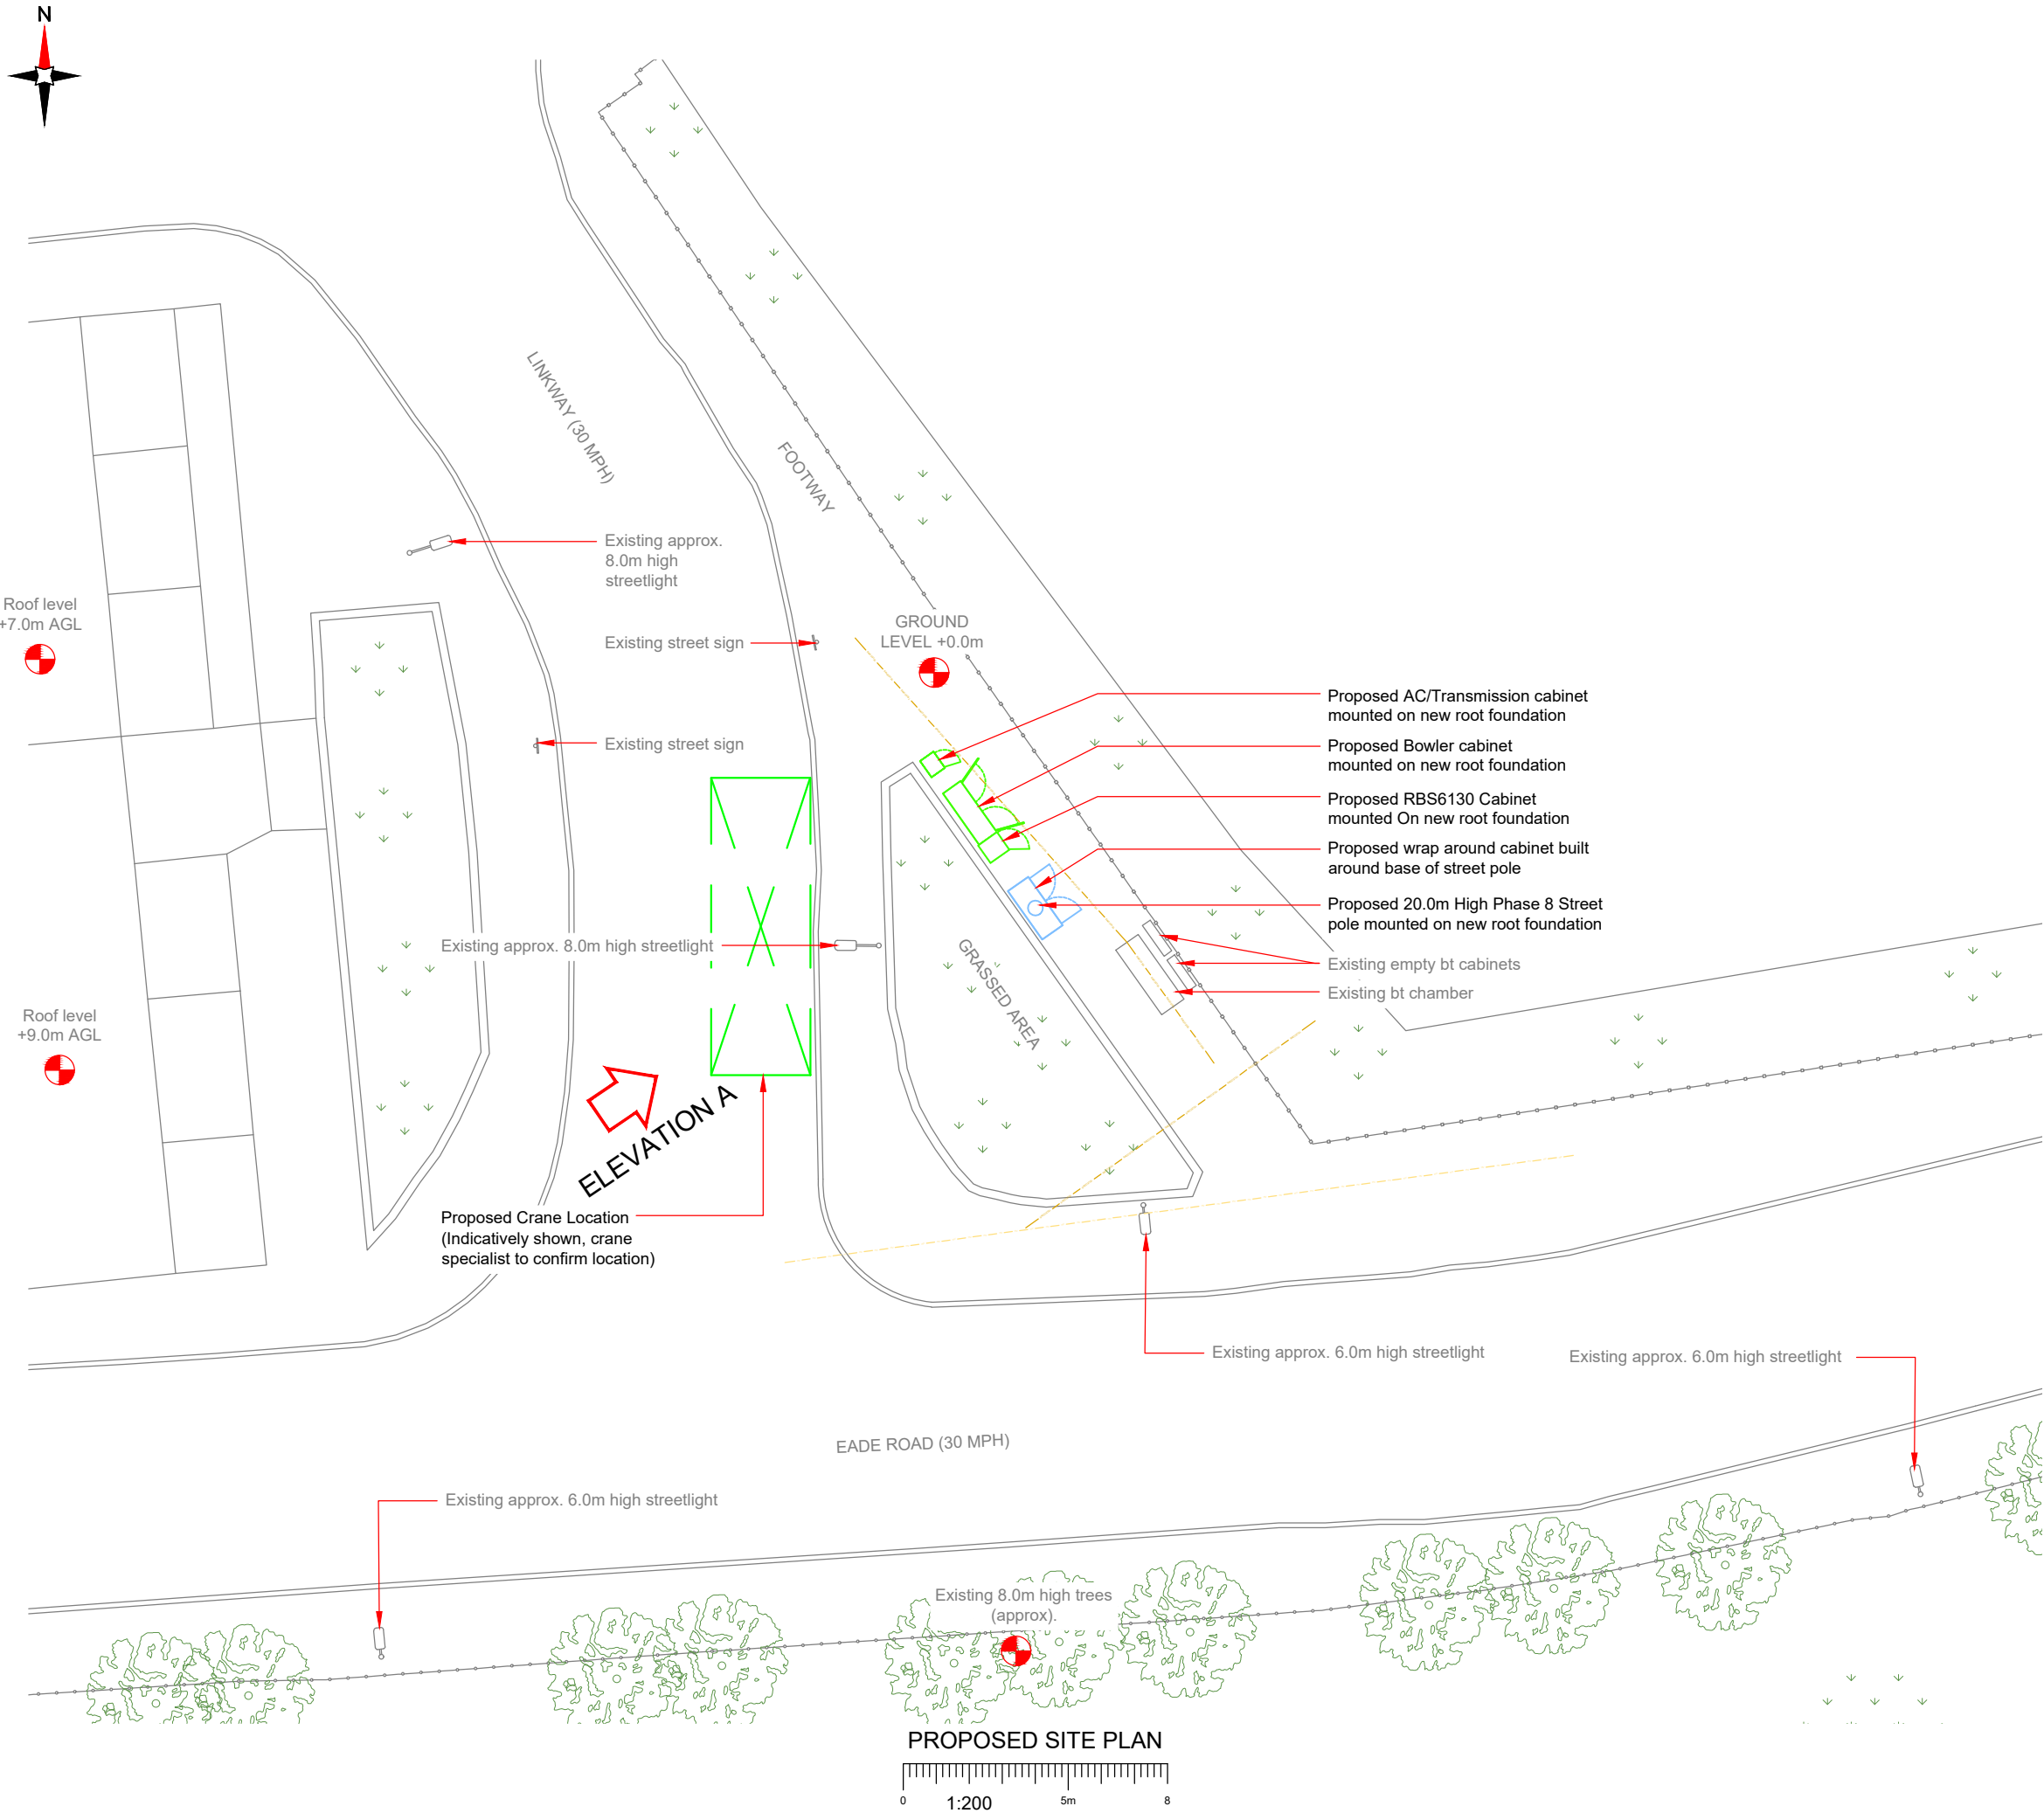

NOTES:

1. ALL DIMENSIONS IN MM UNLESS OTHERWISE NOTED.

SERVICES:

WATER

WATER

WATER

WATER

HV

HV

HV

HV

LV

LV

LV

LV

GAS

GAS

GAS

GAS

TELECOMS

TELECOMS

TELECOMS

TELECOMS

?

?

?

?

CRANE OR CHERRY PICKER LOCATION:

NOTES:

Radar Scan and Stats to be reviewed prior to any build works commencing

Master:	MBNL / EE / H3G:	Project:	Purpose of Issue:	Issue:
M001	H3G	H3G DENSIFICATION STREETWORKS	Planning	A
Date:	03/10/2022	Revision / Upgrade Description:		
Drawn:	CDN	First Issue - Site nomination dated: TBC		
Checked:	J. Glover			
Approved:	J. Glover			

Hutchison 3G UK Limited
Green Park, 450 Longwater Avenue
Reading, RG30 3UR
Tel: 01628 765 000
Fax: 01628 765 001

H3G Base Station Information line:
0845 6043000
Available 8am-8pm Monday to Friday

Design Consultant & Principal Contractor:

Unit E, Madison Place, Northampton Road,
Manchester, M40 5AG
Tel: 0161 785 4500 Fax: 0161 785 4501
Web: www.clarke-telecom.com

Site Name:

LINKWAY STREETWORKS

Site ID:

HGY25540

Address:

LINKWAY,
HARRINGAY WAREHOUSE DISTRICT,
LONDON BOROUGH OF HARINGEY,
GREATER LONDON,
ENGLAND,
N4 1QF

Title:

210 PROPOSED SITE PLAN

Project:

H3G DENSIFICATION STREETWORKS

Purpose of Issue:

PLANNING

EE Cell ID:	MBNL Cell ID:	3UK Cell ID:
-	-	HGY25540

Master Drawing No:

HGY25540_B35_GA_A


Issue:

A

100mm

50mm

10mm

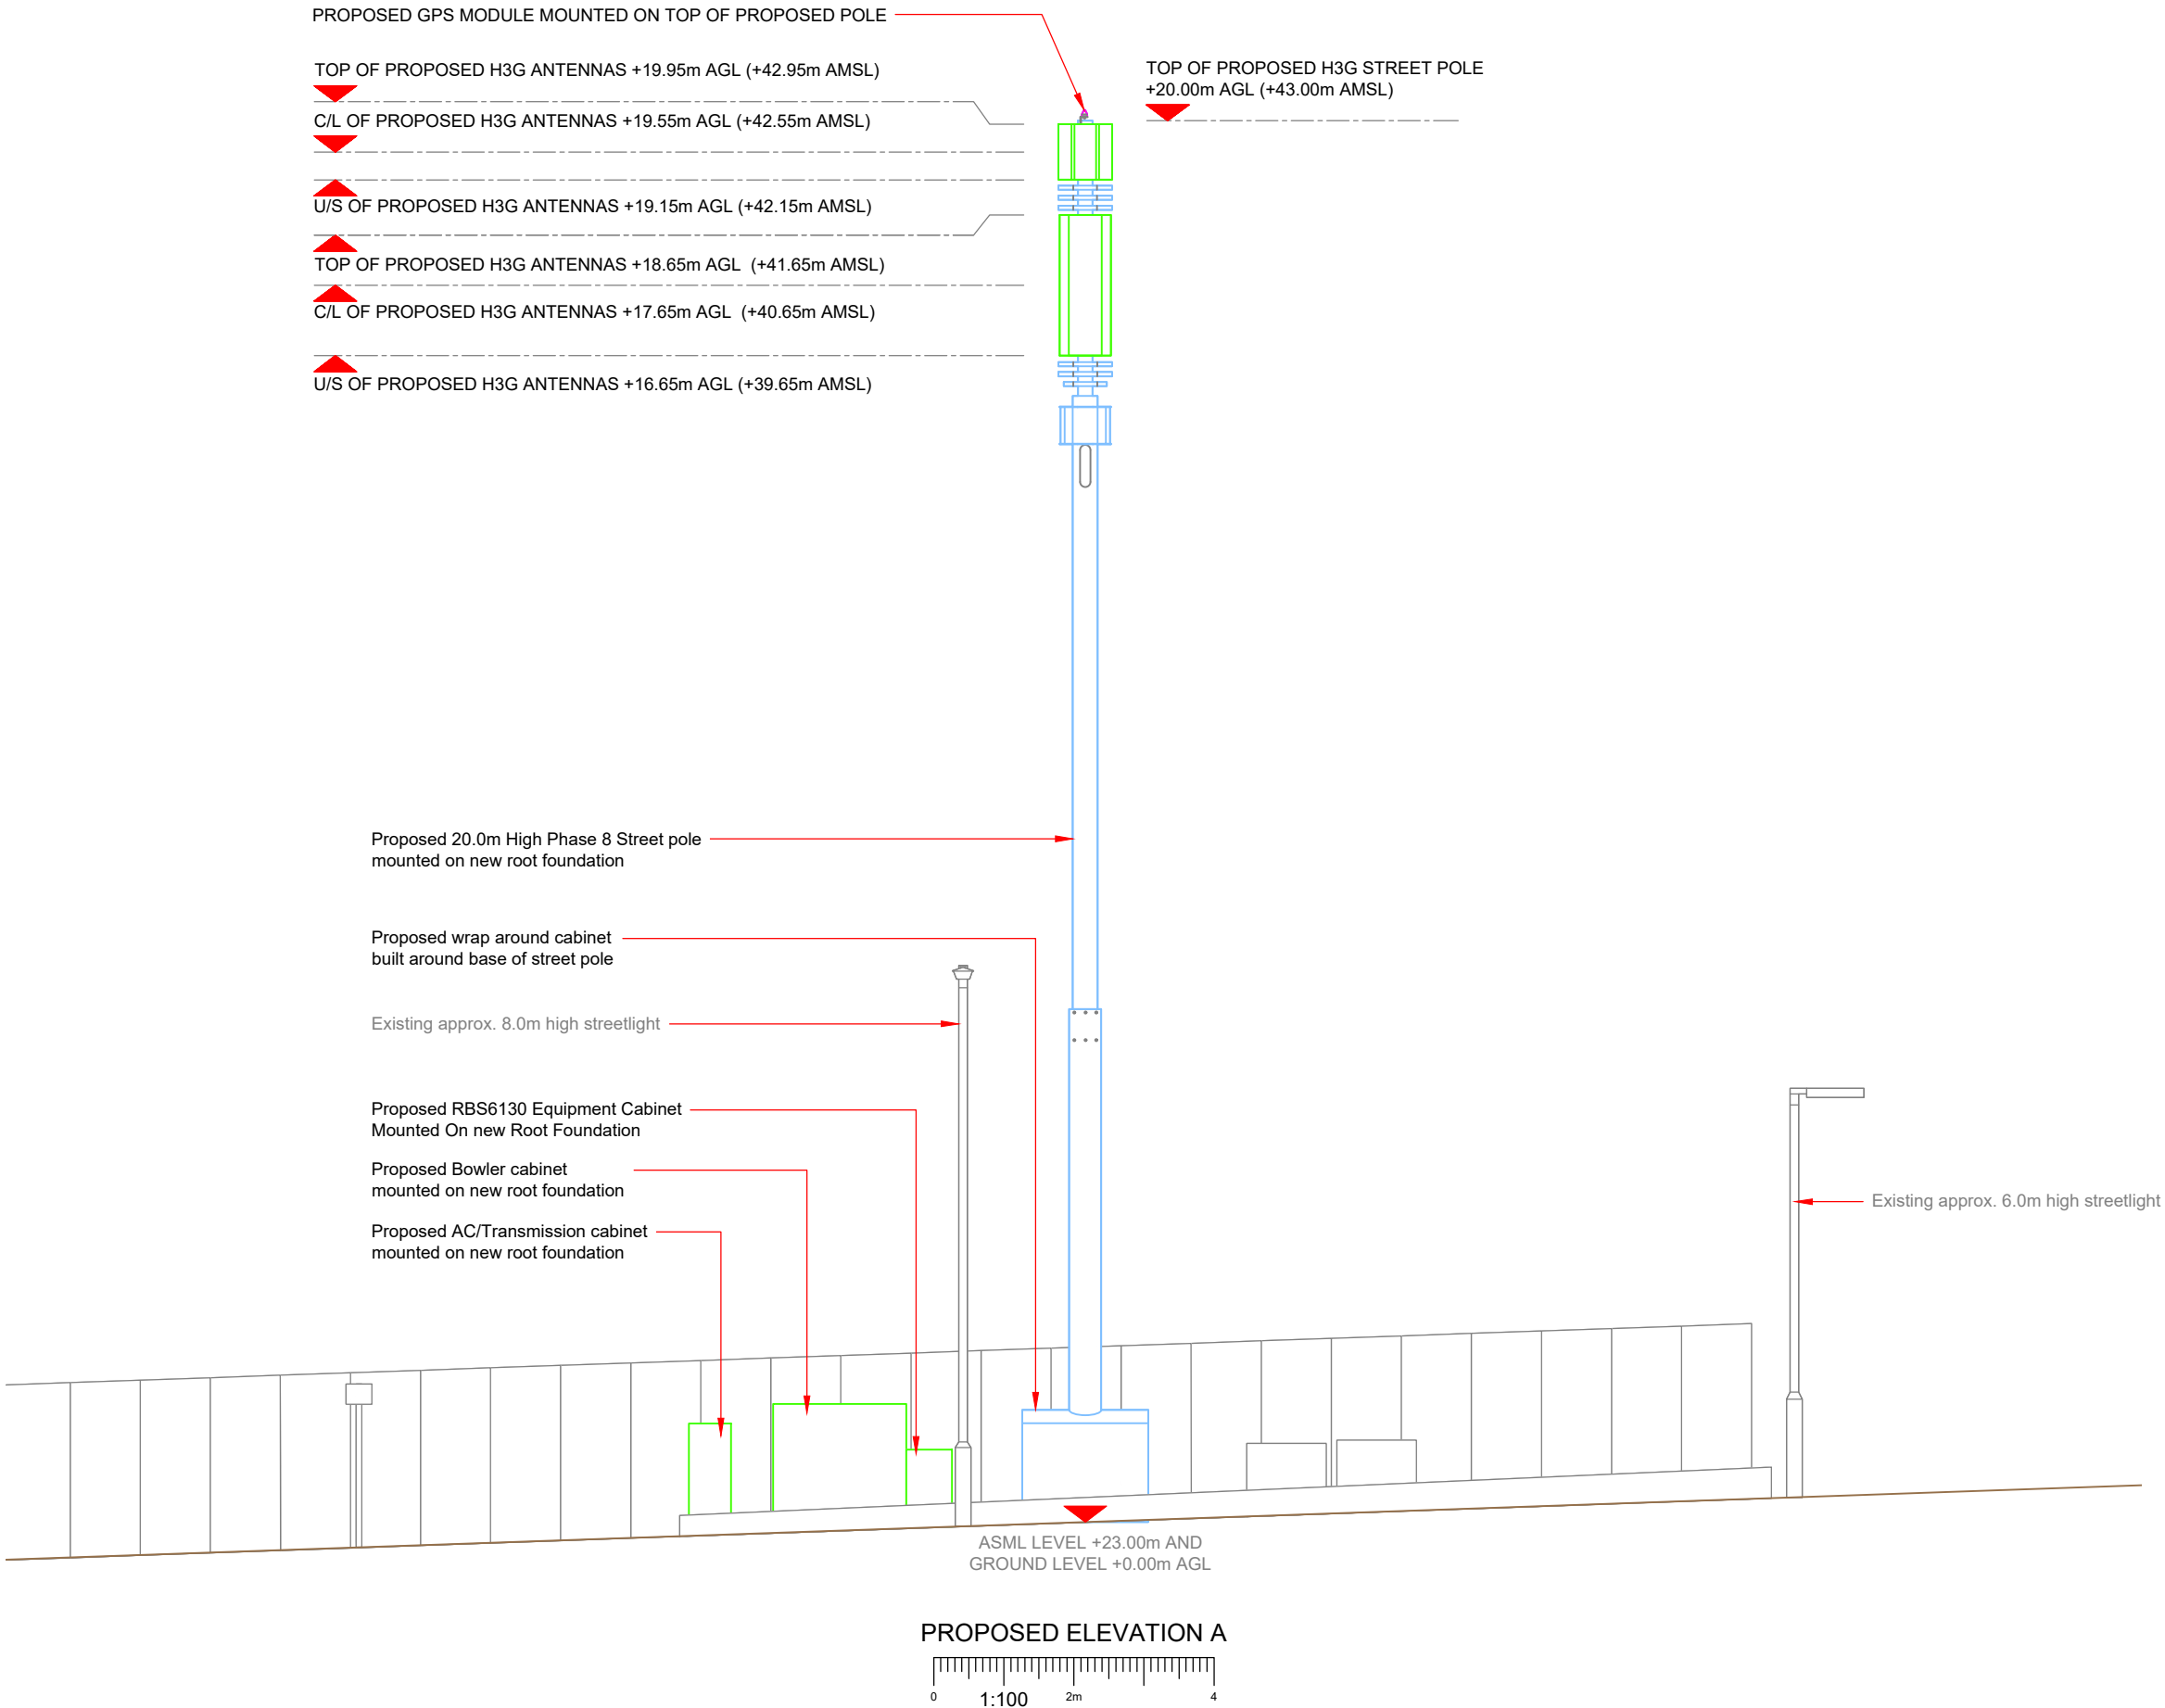

NOTES:
1. ALL DIMENSIONS IN MM UNLESS OTHERWISE NOTED.

Master:	MBNL / EE / H3G:	Project:	Purpose of Issue:	Issue:
M001	H3G	H3G DENSIFICATION STREETWORKS	Planning	A
Date:	03/10/2022	Revision / Upgrade Description:		
Drawn:	CDN	First Issue - Site nomination dated: TBC		
Checked:	J. Glover			
Approved:	J. Glover			



Hutchison 3G UK Limited
Green Park, 450 Longwater Avenue
Reading, RG30 3UR
Tel: 01628 765 000
Fax: 01628 765 001

H3G Base Station Information line:
0845 6043000
Available 8am-8pm Monday to Friday

Design Consultant & Principal Contractor:


Unit E, Madison Place, Northampton Road,
Manchester, M40 5AG
Tel: 0161 785 4500 Fax: 0161 785 4501
Web: www.clarke-telecom.com

Site Name:		
LINKWAY STREETWORKS		
Site ID:		
HGY25540		
Address:		
LINKWAY, HARRINGAY WAREHOUSE DISTRICT, LONDON BOROUGH OF HARINGEY, GREATER LONDON, ENGLAND, N4 1QF		
Title:		
260 PROPOSED ELEVATION		
Project:		
H3G DENSIFICATION STREETWORKS		
Purpose of Issue:		
PLANNING		
EE Cell ID:	MBNL Cell ID:	3UK Cell ID:
-	-	HGY25540
Master Drawing No:		Issue:
HGY25540_B35_GA_A		A