



The Copyright of this drawing remains with Fulkers Bailey Russell and is not to be reproduced without written approval. Dimensions are not to be scaled from this drawing. The Contractor is to check all dimensions on site and report any discrepancies to the Contract Administrator. This drawing is to be read in conjunction with all other standard documentation.

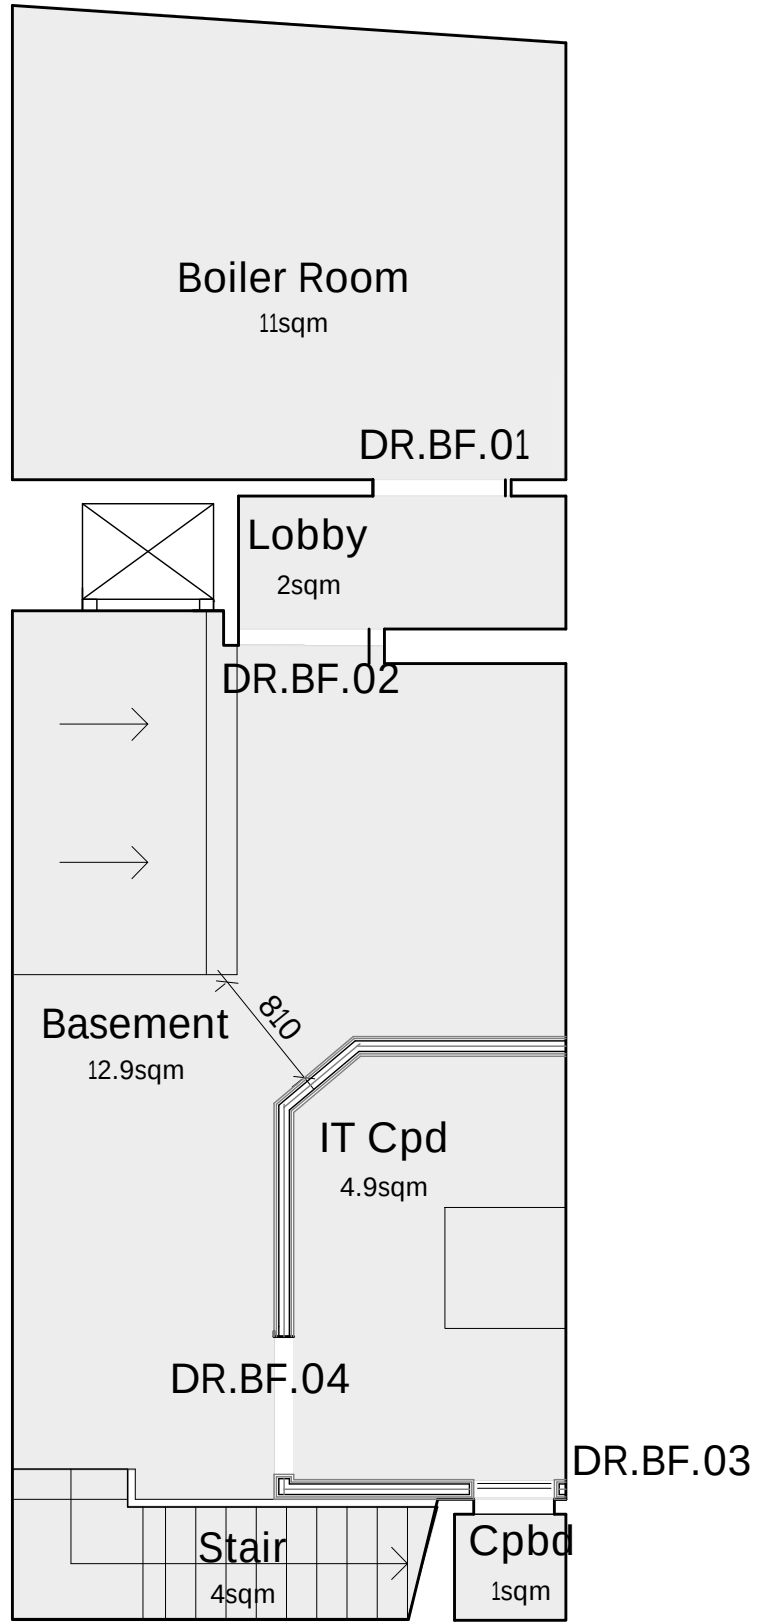

Basement level
Reflected Ceiling Plan
1:50

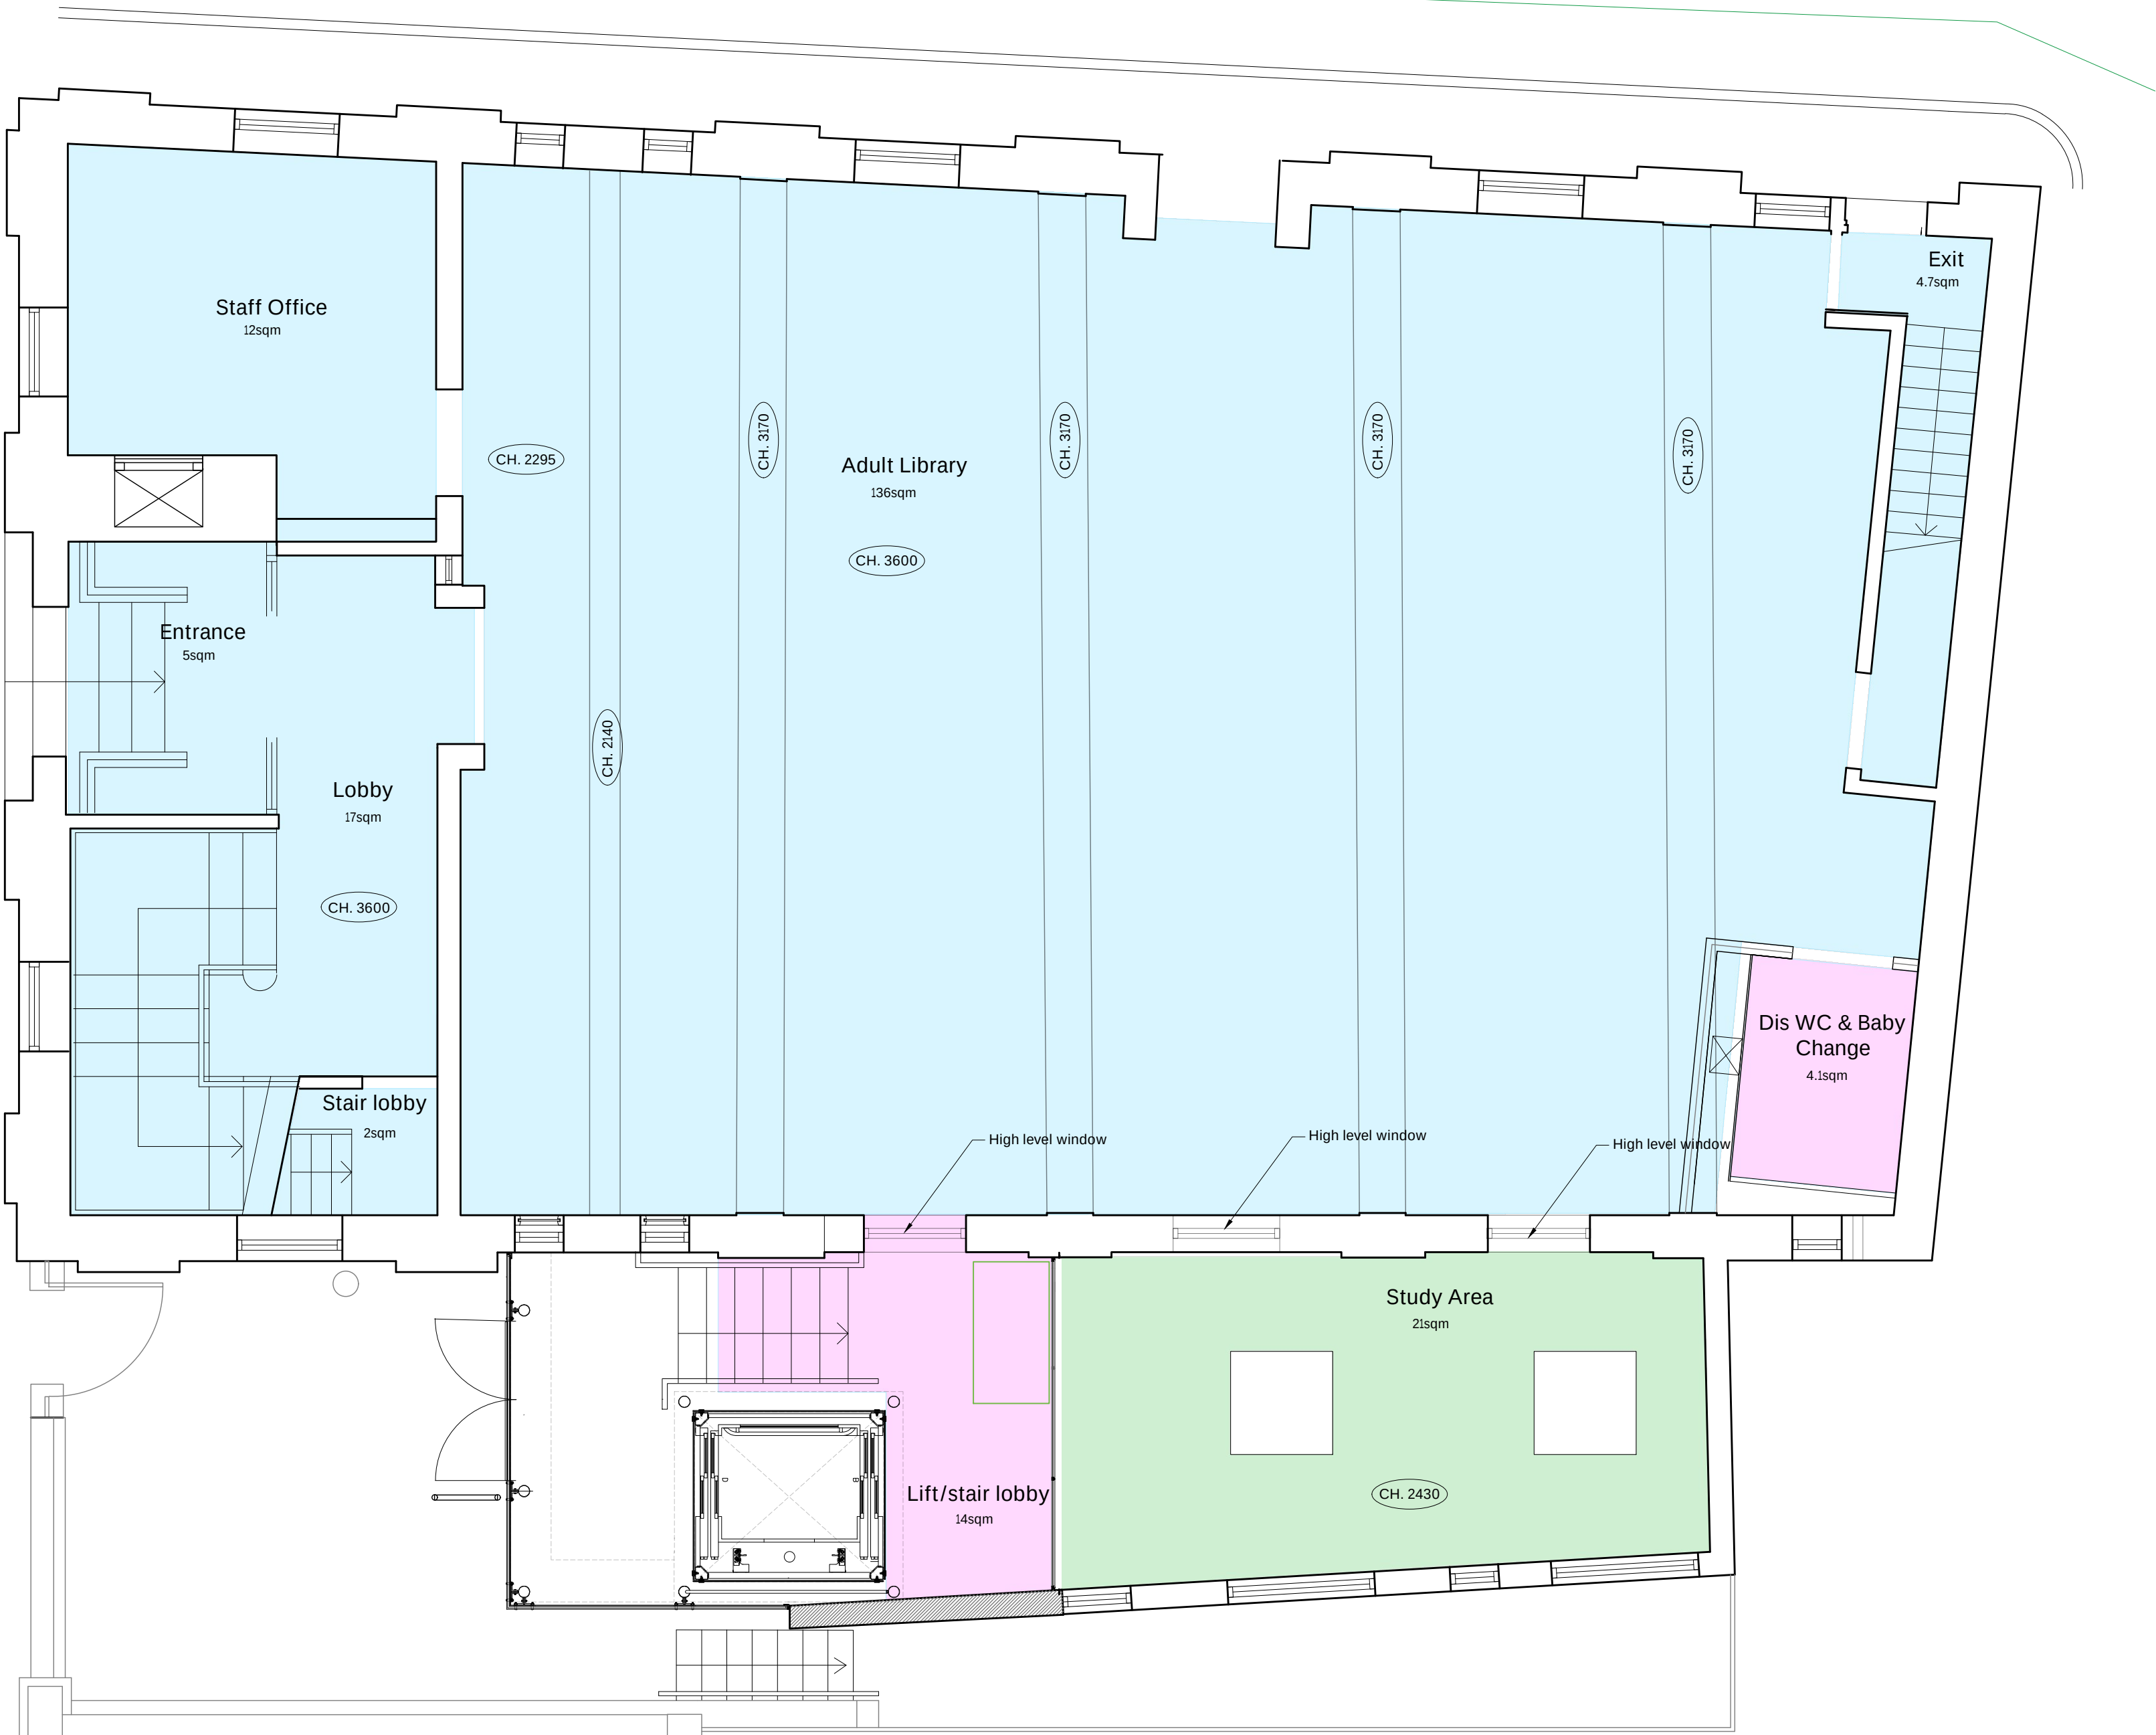

Ground Floor
Reflected Ceiling Plan
1:50

- Key
- Existing plasterboard ceilings to be made good and redecorated
 - New MF plasterboard areas. Moisture resistant plasterboard to wet area ie bathrooms and wcs. To NBS clause K10/220
 - New plasterboard ceiling to clause K10/245
 - Existing Basement ceiling to be made good and redecorated

P03	IT Cupboard to basement and high level windows added to Ground Floor	09/11/22	SP
P02	Issued for Tender	14/10/22	SP
P01	Issued for Tender	30/09/22	SP
rev.	description	date	chkd.

client :
London Borough of Haringey

project :
**Library Enhancement Works
Muswell Hill Library
Queen's Av, Muswell Hill. London. N10 3PF**

drawing title :

**Bsement and Ground Floor
Reflected Ceiling Plans
As Proposed**

FulkersBaileyRussell
london | brighton | bristol | leeds | reading | manchester
info@fulkers.co.uk // www.fulkers.co.uk // 020 3735 5792

drawn: GD	chkd : AK	date: Aug 2022
proj no : 21.3453		scale: 1:50@A1
identifier : 3453-FBR-A1-GF-DR-A-222		
status: D2 (Tender)		rev no: P03