


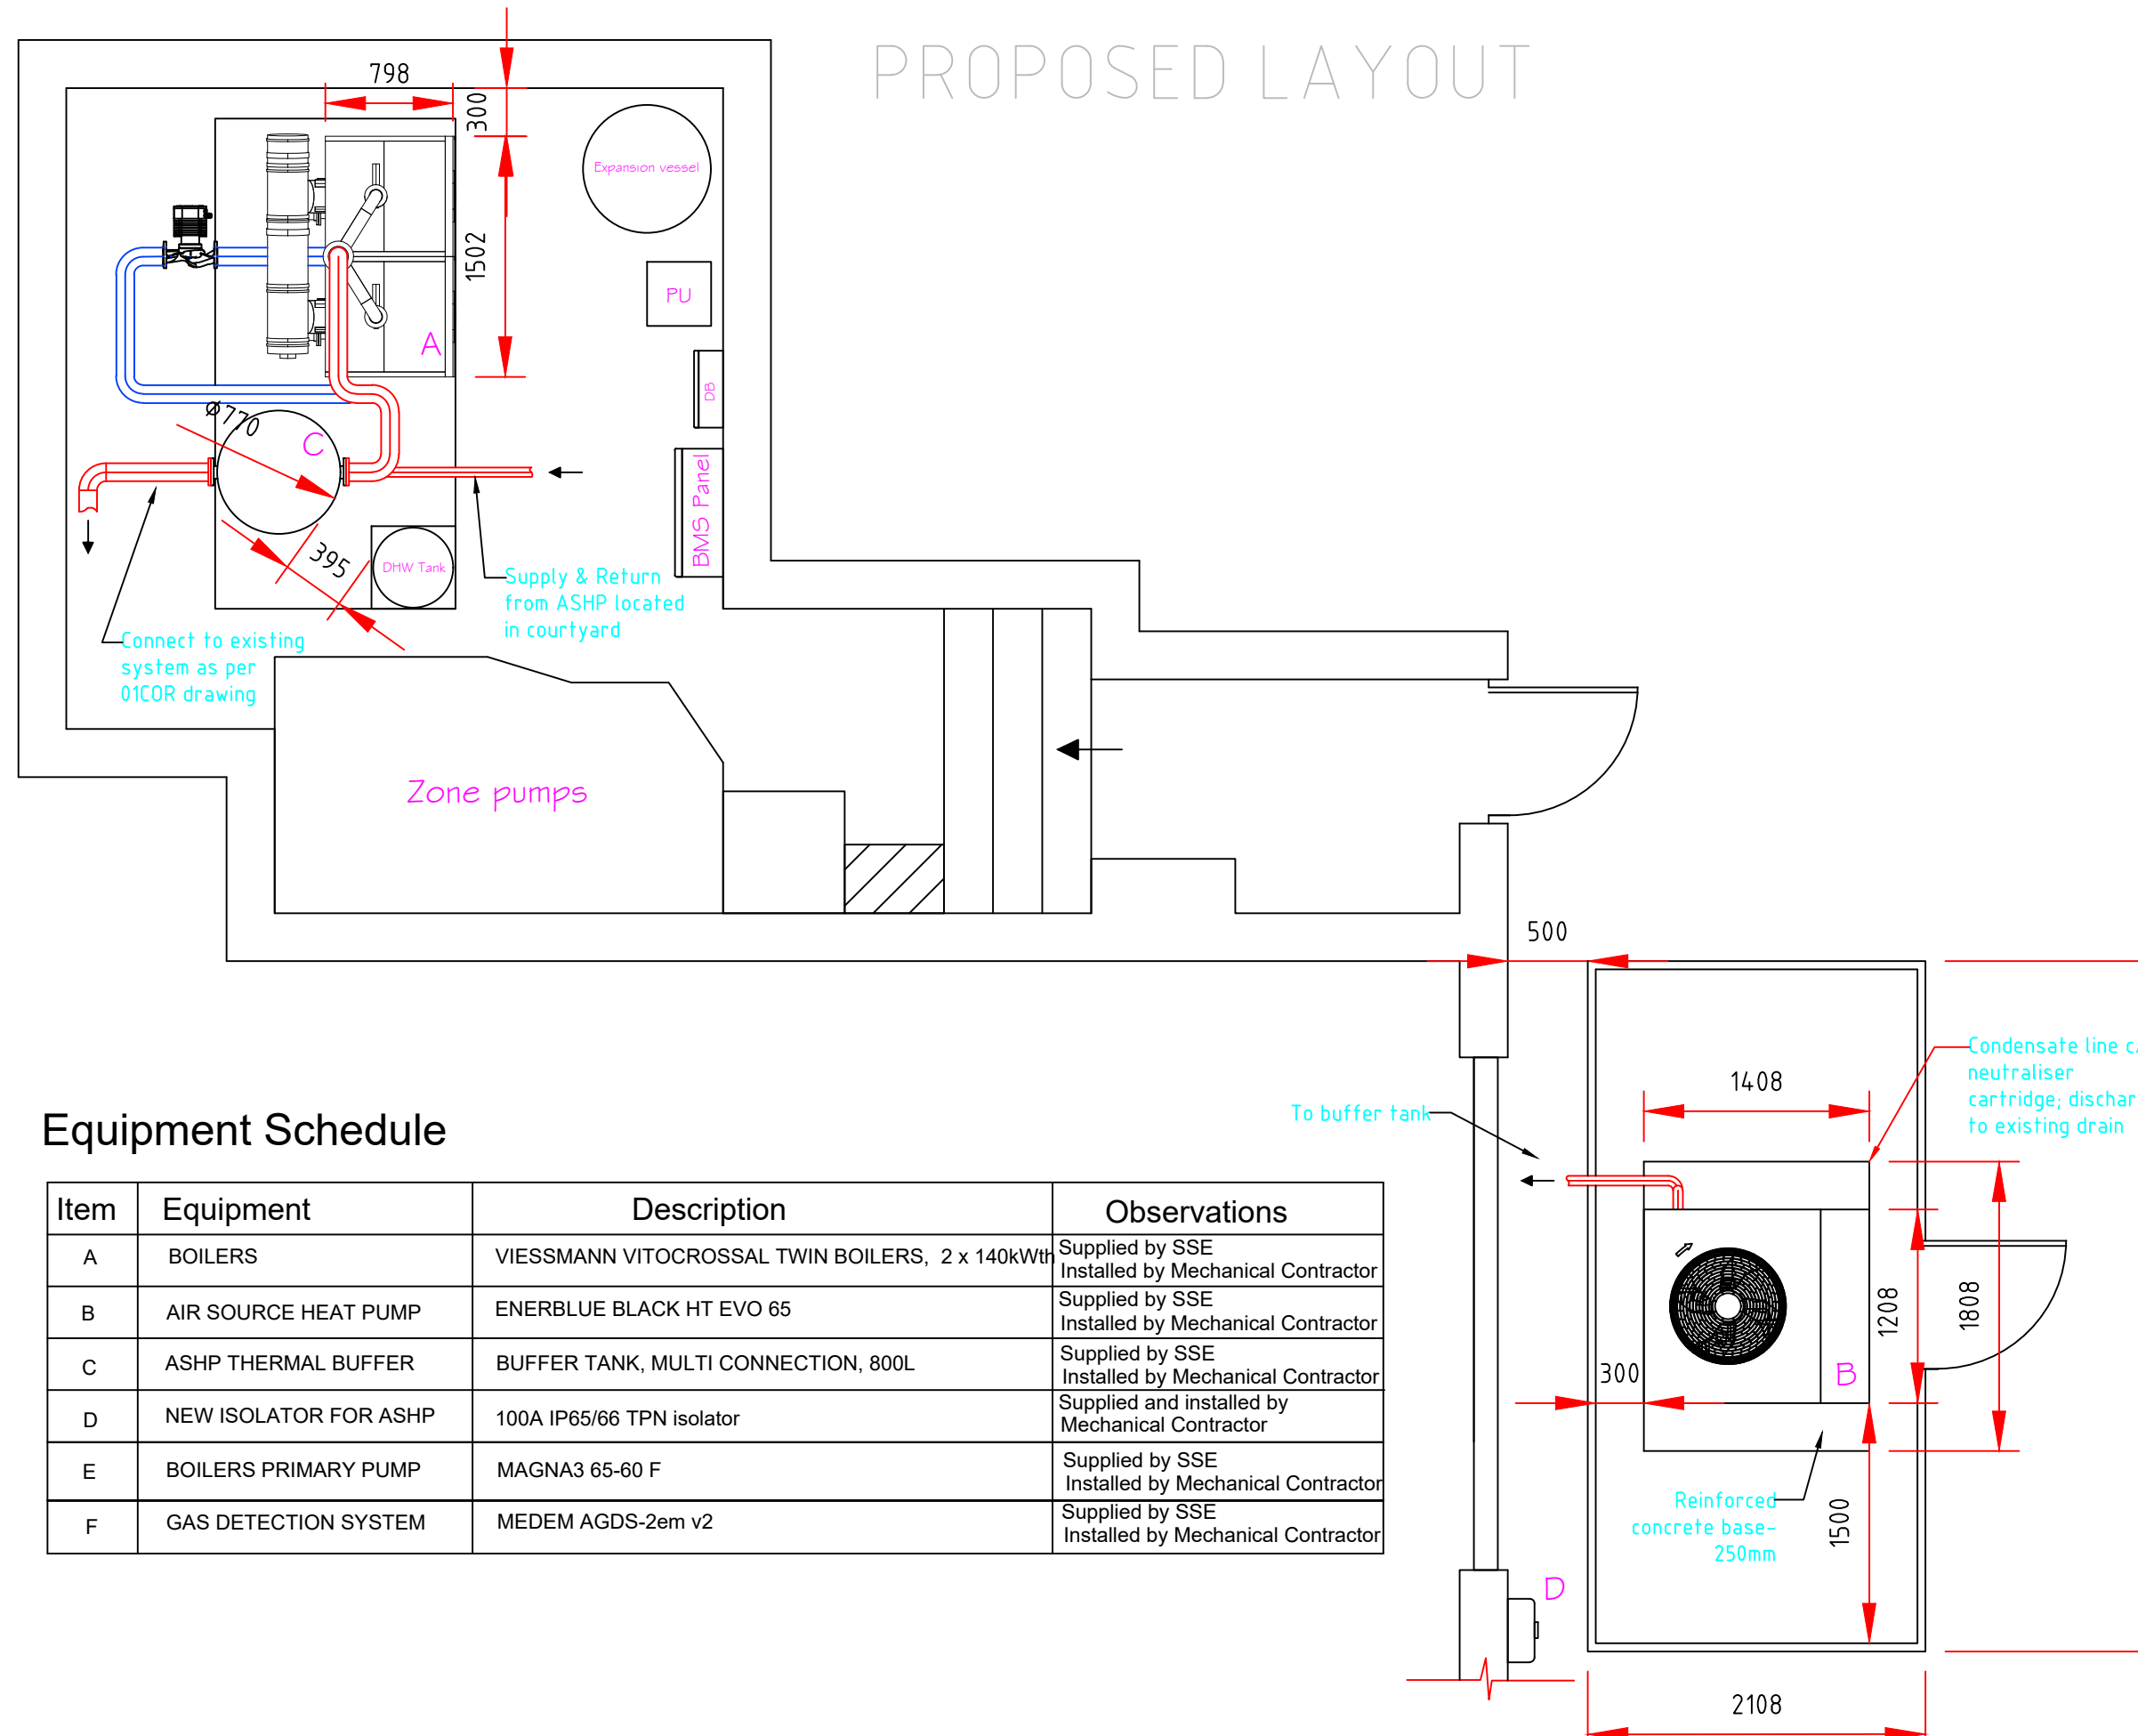

- NOTES
1. THIS DRAWING IS TO BE READ IN CONJUNCTION WITH THE SCOPE OF REQUIREMENTS. THE WORKS ARE TO BE UNDERTAKEN IN STAGES AS DETAILED IN THE SCOPE OF REQUIREMENTS.
 2. ALL PROPOSED CARBON STEEL PIPEWORK SHALL BE SCREWED OR FLANGED AND NO WELDING SHALL BE UNDERTAKEN INTERNALLY ON SITE.
 3. CONDENSATE PIPEWORK FROM FLUE TO BE TAKEN TO NEUTRALIZER AND FURTHER TO EXTERNAL RAINWATER PIPE.
 4. ISOLATION VALVES TO BE INSTALLED AT SERVICES AS INDICATED ON THE DRAWING 001
 5. PIPEWORK THERMAL INSULATION TO BE FINISHED WITH WHITE PVC PREFORMED JACKETS UNLESS SPECIFIED OTHERWISE.
 6. ALL ISOLATION VALVES TO BE BALL VALVES AND FULL PORT.
 7. BEFORE COMMENCING WORK CONTRACTOR WILL MAKE SURE EXISTING SITE FIRE ALARM SYSTEM IS FULLY FUNCTIONAL. ON COMPLETION THERMAL CUTS OUTS WILL BE REPLACED AND RECOMMISSIONED BY FIRE ALARM PROVIDER.
 8. CONTRACTOR PROGRAMME TO BE FULLY DETAILED AND ALL DISRUPTION OF SERVICES TO BE AGREED WITH HARRIS FEDERATION.
 9. GAS SUBCONTRACTOR TO SUPPLY AS BUILT GAS SCHEMATIC DRAWING.

REV No.	DATE	REV DESCRIPTION	DRN	CHK	REV	APR
sse Enterprise Energy Solutions						
SSE Enterprise Bramah House 65-71 Bermondsey St London SE1 3XF						
PROJECT HARRIS FEDERATION PSDS3 DECARBONISATION PROJECT						
CLIENT HARRIS FEDERATION						
CLIENT DRAWING No. N/A						
DRAWING TITLE HPA CORELAINE PARK GENERAL LAYOUT - PROPOSED						
PROJECT STATUS PUBLISHED DOCUMENTATION			SUITABILITY CODE D1			
SCALE AND PAPERSIZE 1:50 @ A3						
DRAWN BY: JC			DATE: 27 FEB 2022			
CHECKED BY: TO			DATE: 27 FEB 2022			
REVIEWED BY: BM			DATE: 02 MAR 2022			
APPROVED BY: BM			DATE: 02 MAR 2022			
DRAWING NUMBER 004COR			REVISION 0			