


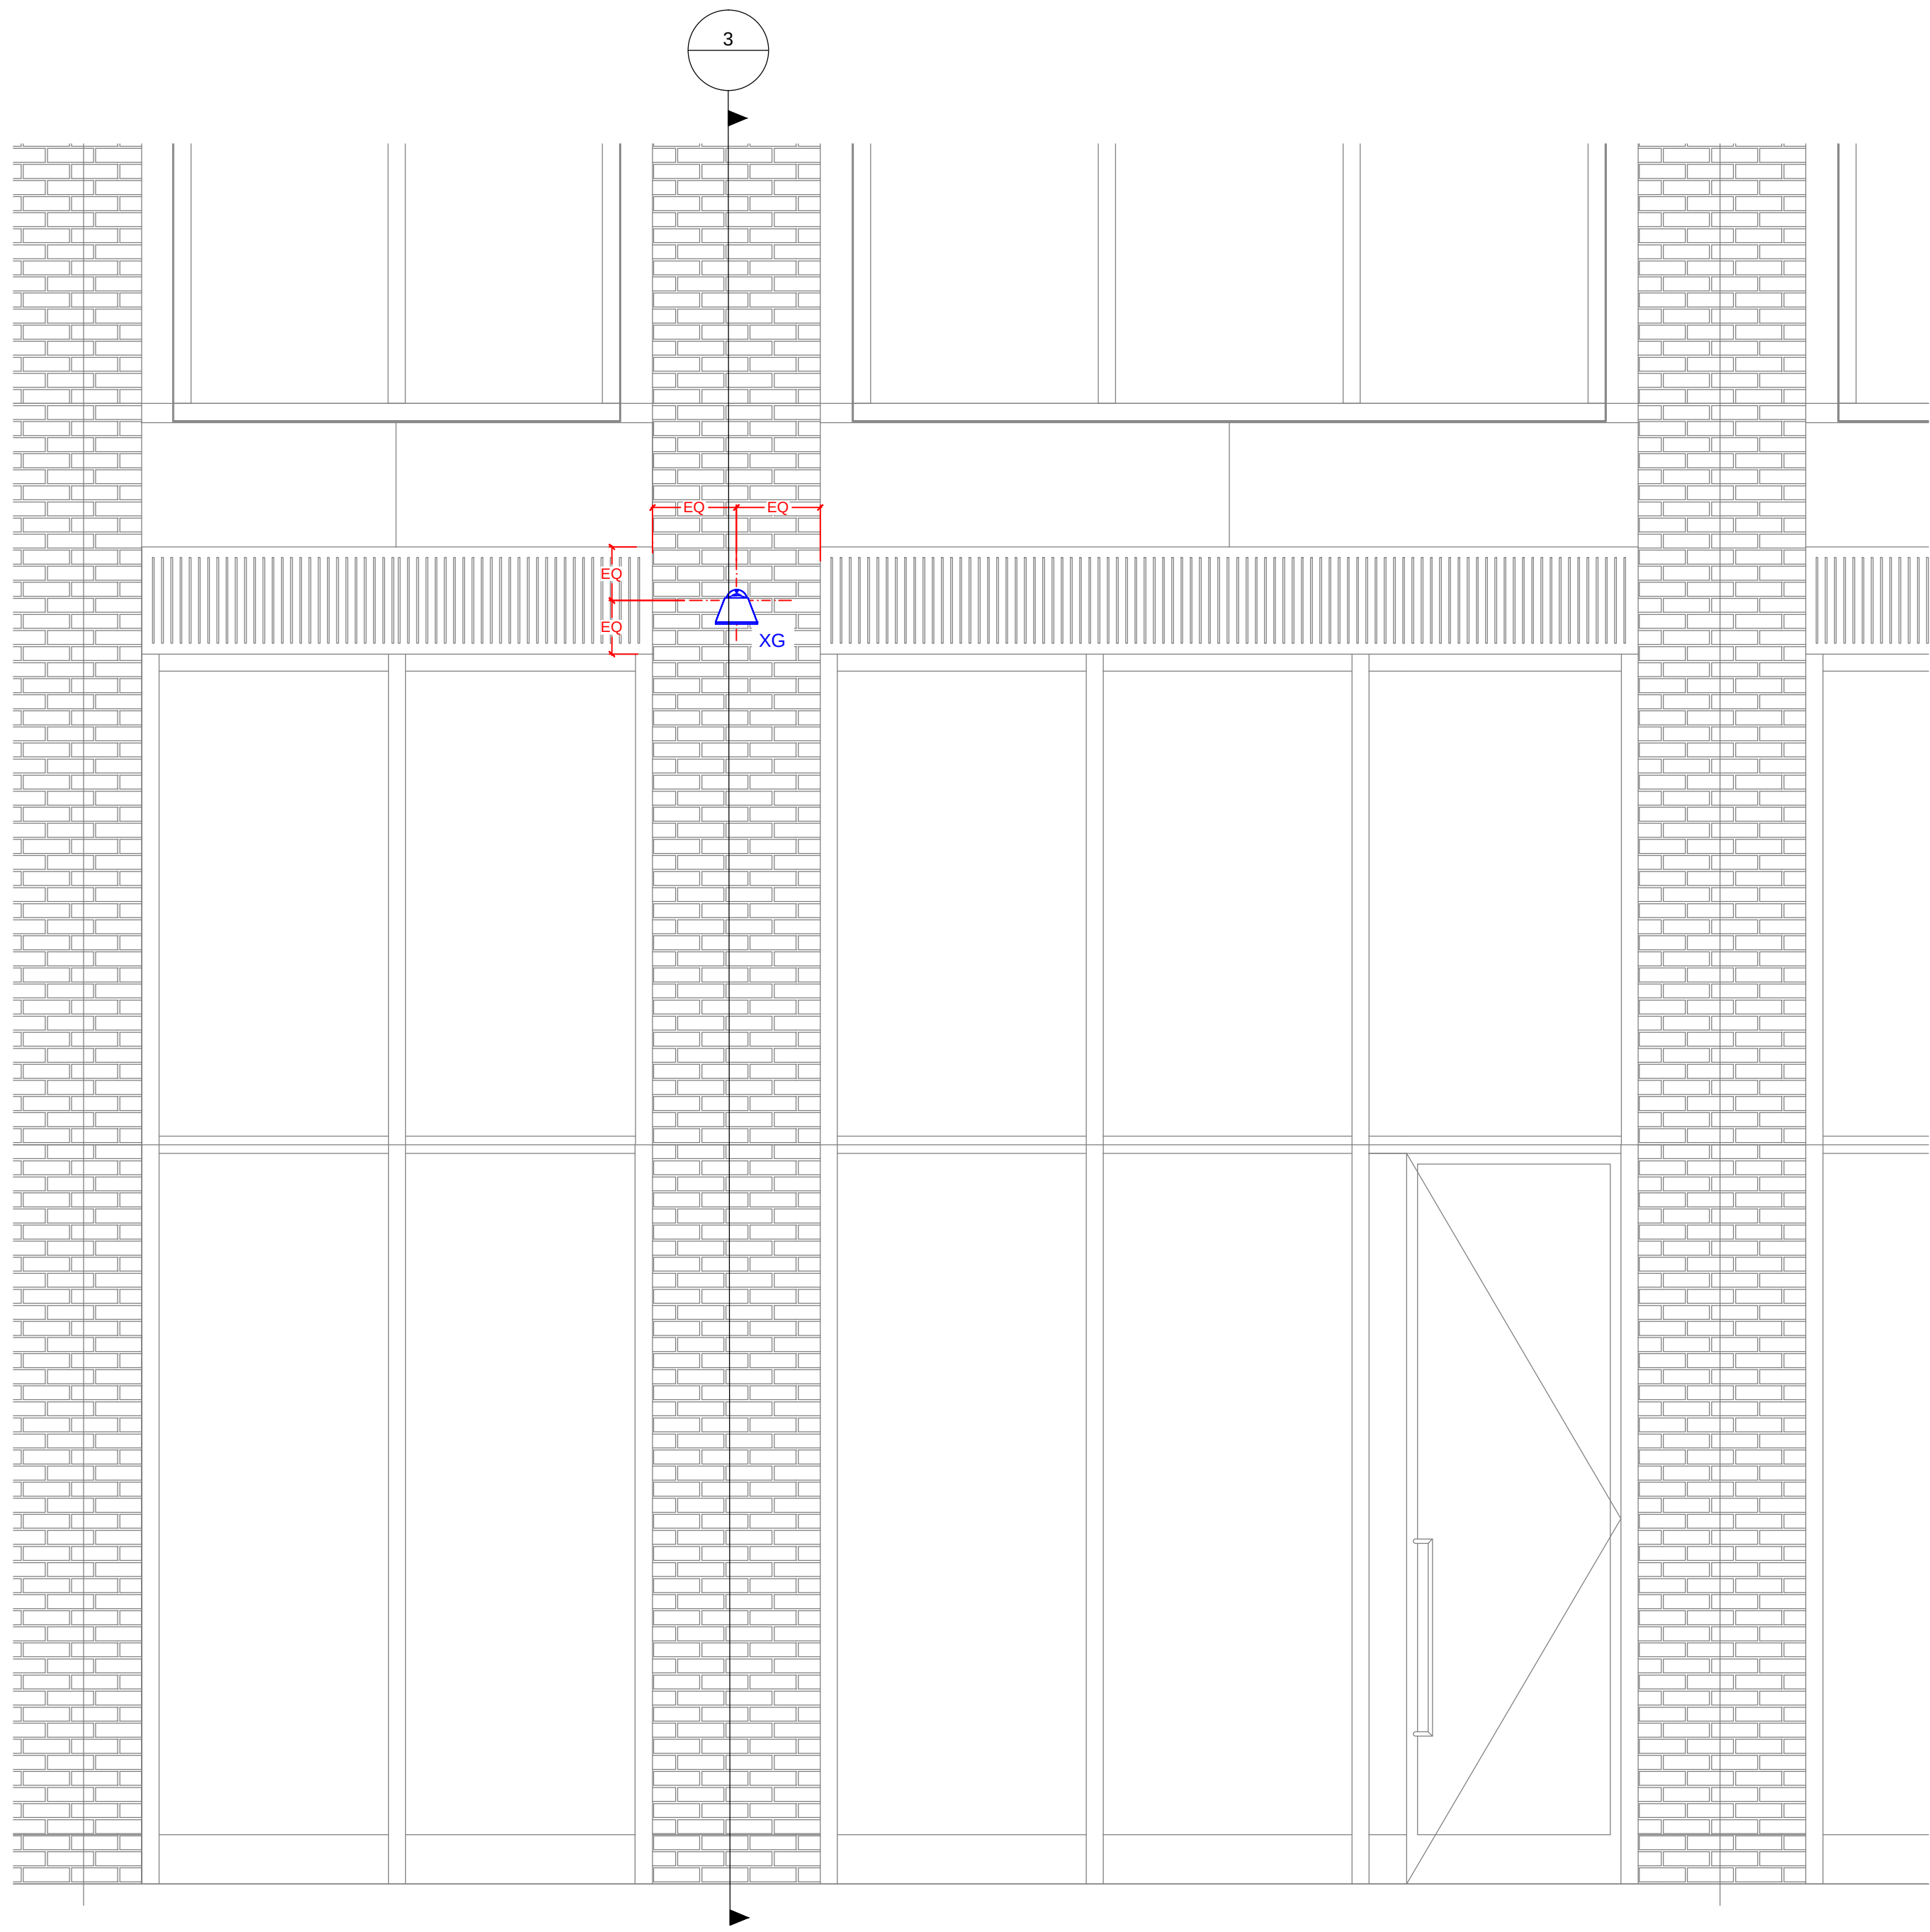


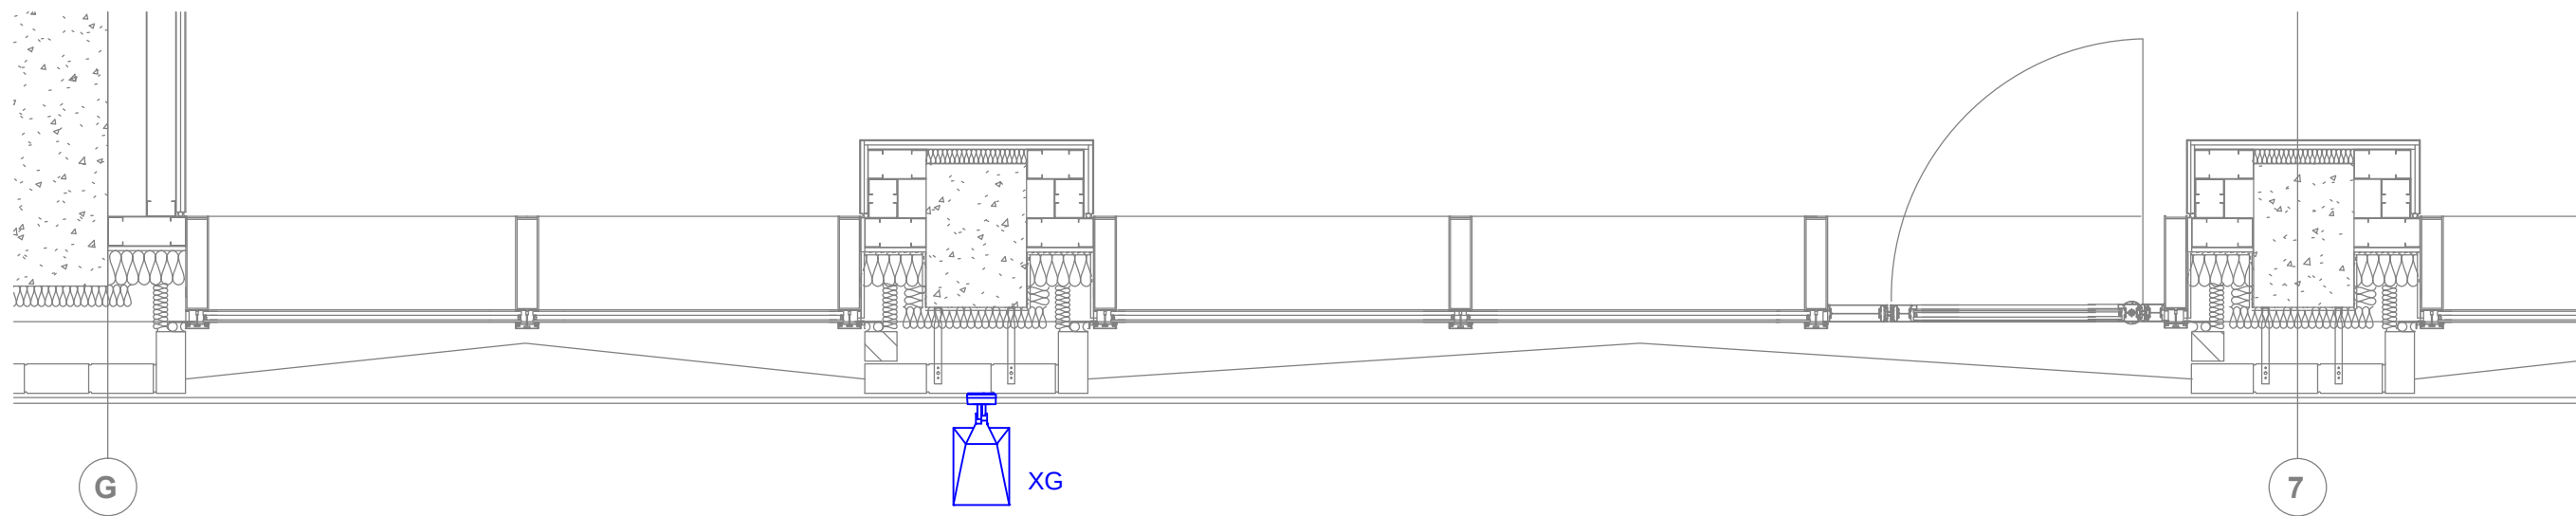


2 Elevation
1:25

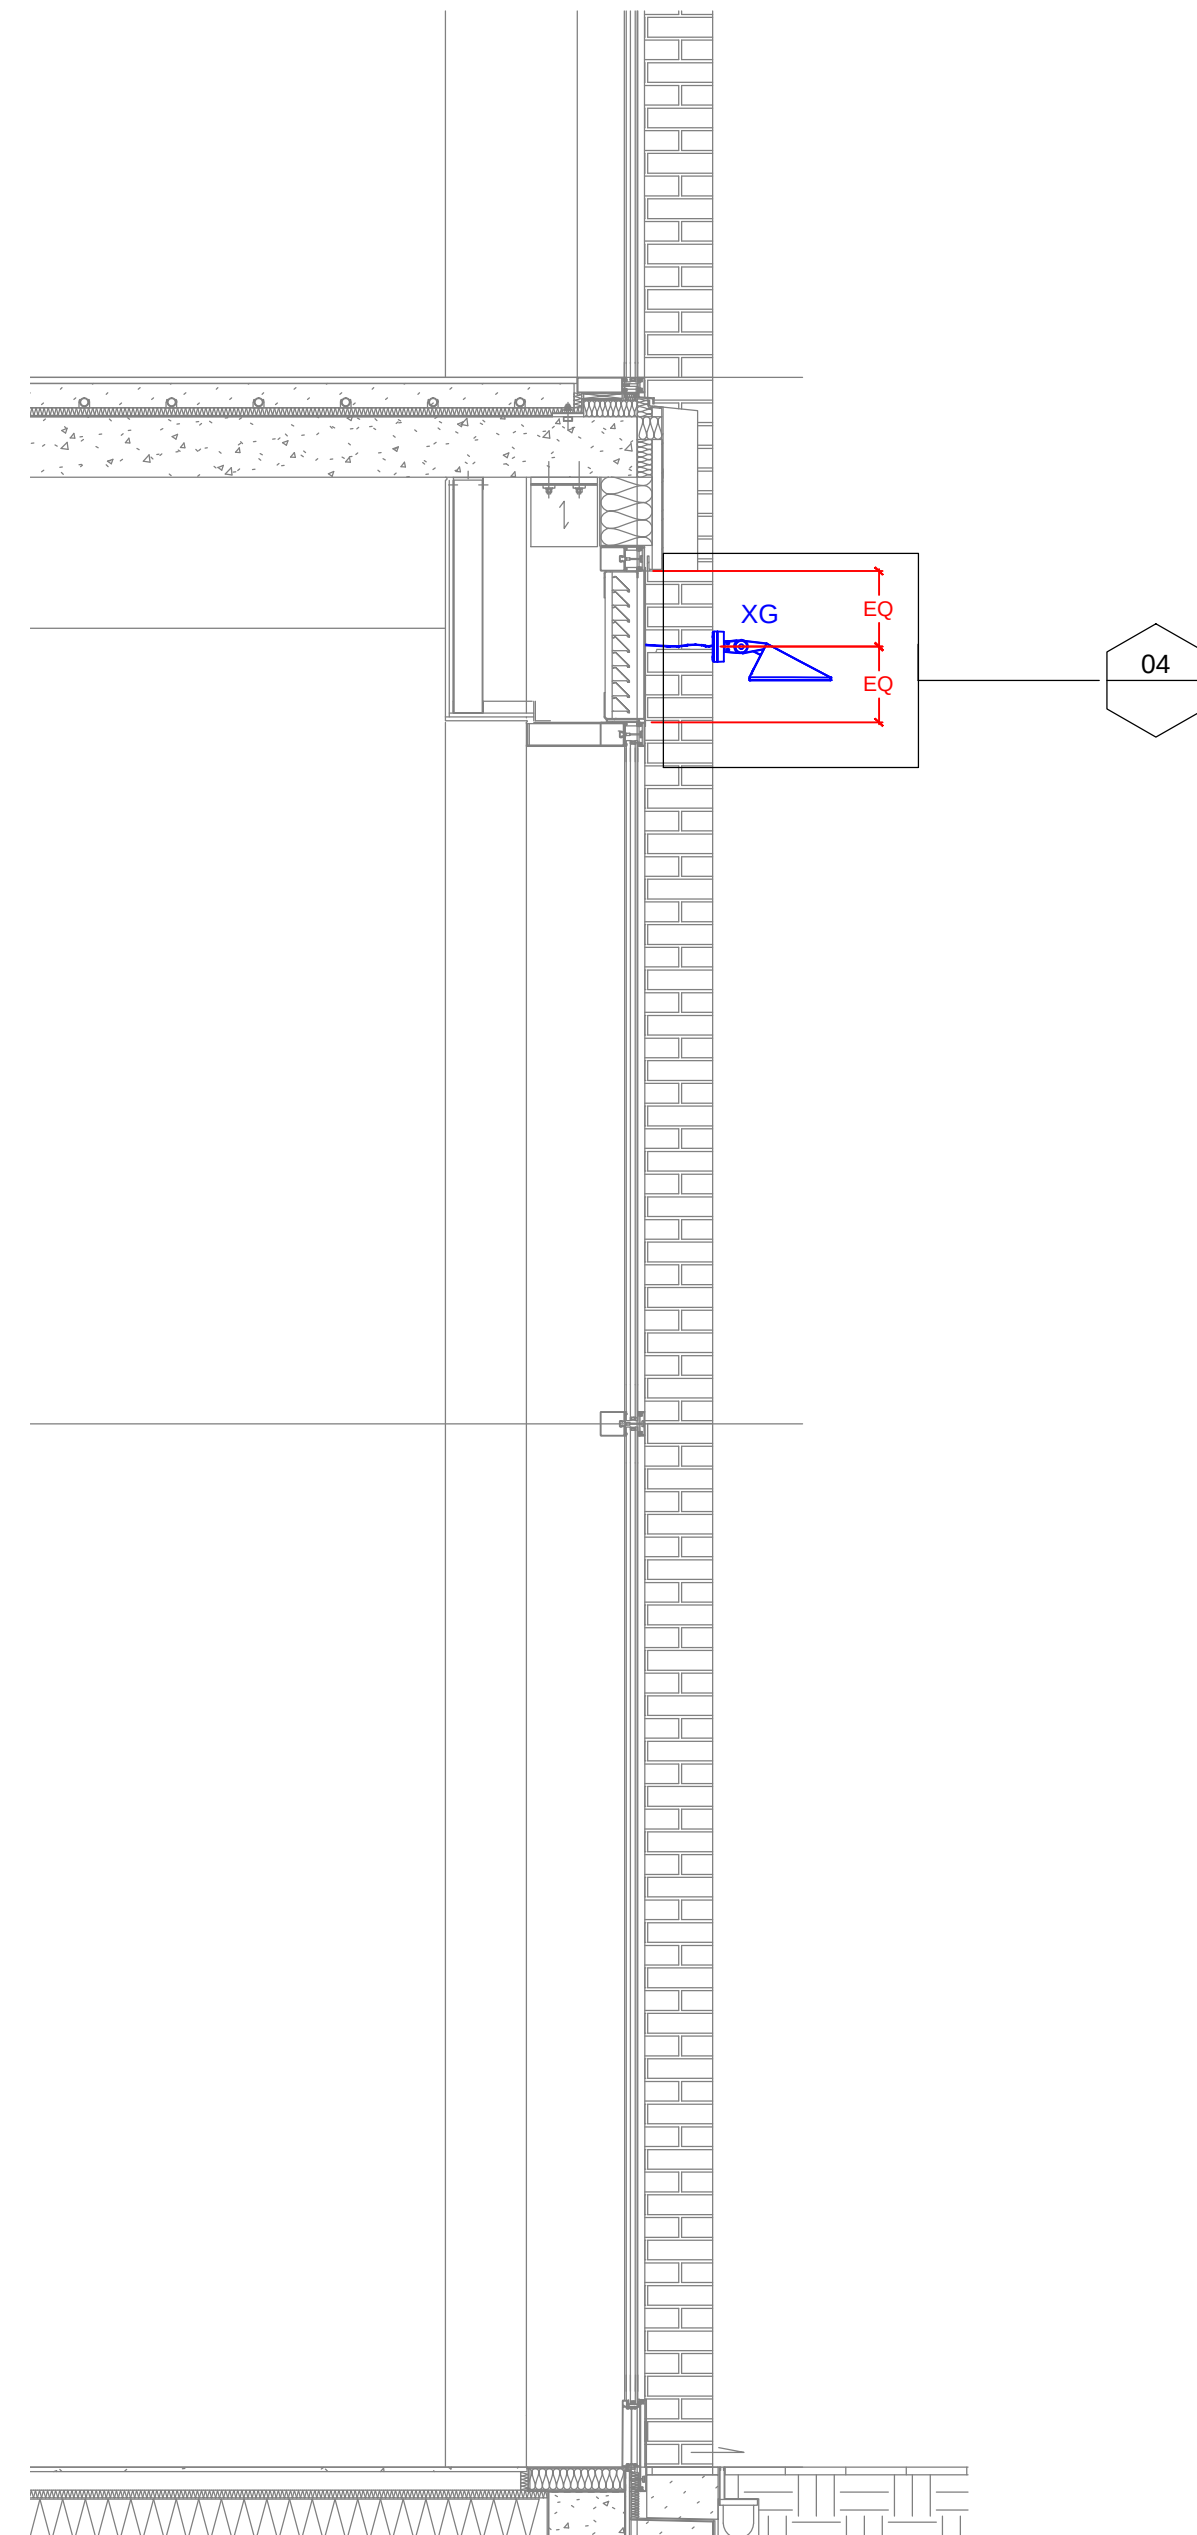

1 Partial Reflected Ceiling Plan - Mezzanine
1:25

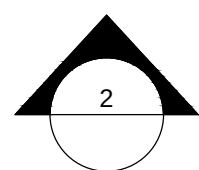

3 Section
1:25

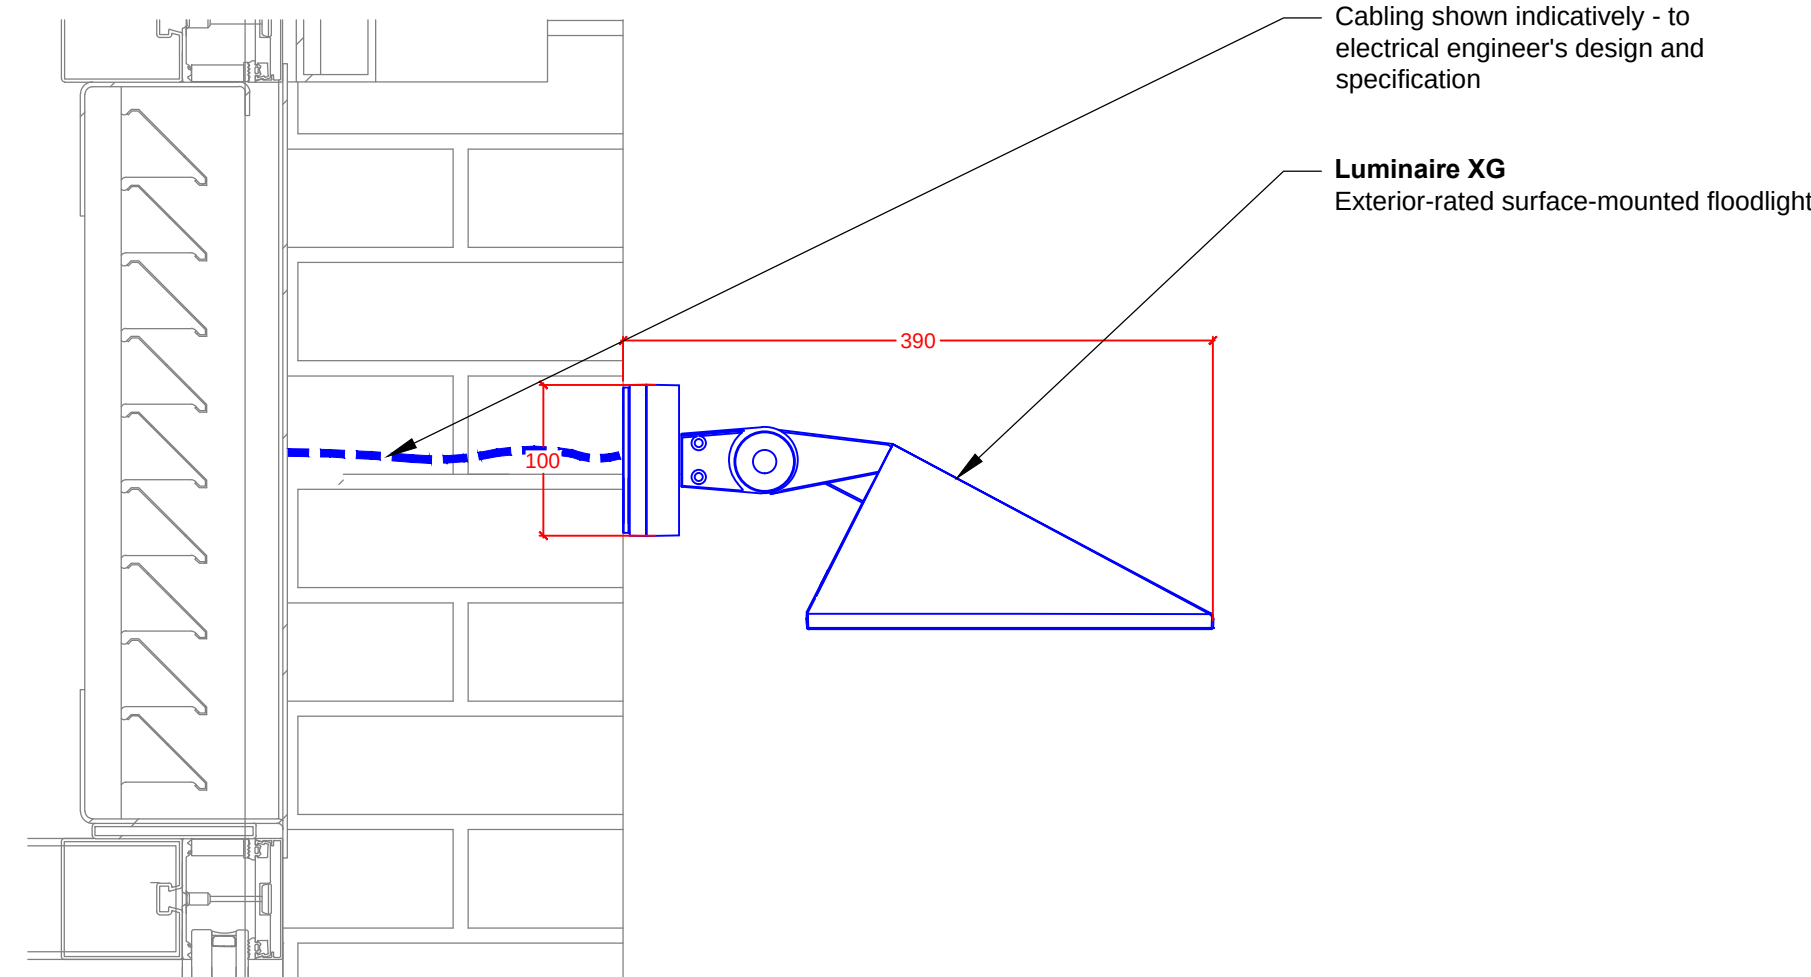

4 Detail
1:5

NOTES:
All cabling, containment and other electrical infrastructure to electrical engineer's detail and specification.
Luminaires to be installed in accordance with manufacturer's installation instructions and in dry conditions.

Notes:
Do not scale off this drawing.
All drawings to be read in conjunction with all other relevant documents, including drawings and specifications.
All works to be carried out in accordance with such Standards, Building and IEE regulations, mandatory and statutory regulations and codes of practice as are deemed to apply in the relevant country or state.
Refer to *Speirs+Major Lighting Designer's Risk Assessment* for associated risks under the construction (Design and Management) Regulations (where applicable).

Symbol Notes (where used):
Symbols indicate positions of luminaires and other equipment.
The alphanumeric reference beside each symbol refers to luminaire type - see relevant *Speirs+Major Lighting Equipment Specification*.
The numeric code beside each symbol refers to a logical control channel reference (NOT the same as a physical wiring circuit). For details of logical channels see relevant *Speirs+Major Control Channel Schedule*. For details of wiring circuits, etc, see relevant engineers' drawings.

Copyright:
© Speirs + Major LLP, date as below. Under UK law, all rights described in Chapter 4 of the Copyrights, Designs and Patents Act 1988 have been generally asserted.

IMPORTANT:
THIS DRAWING IS NOT TO BE ISSUED FOR TENDER OR CONSTRUCTION. IF THIS DRAWING IS ISSUED TO CONTRACTORS, IT IS FOR INFORMATION ONLY - ARCHITECTS' AND ENGINEERS' DRAWINGS MUST BE USED AS THE BASIS FOR TENDER AND CONSTRUCTION.

00 02/11/18 AG IR Stage 3 - Design Development Issue

Rev.	Date	By	Chkd	Revision Notes
------	------	----	------	----------------

Project:
Ashley Road East, Tottenham Hale
London, UK

Drawing:
Lighting Detail
Building-mounted streetlighting

Drawing Number:
TH-ARE-01-001-J-11163B-63-604

Rev.
00

Scale: 1:25, 1:5 **ISO:** A1

SPEIRS+MAJOR
London: +44(0)20 7067 4700 Email: info@speirsandmajor.com
www.speirsandmajor.com