
 


SITE LOCATION

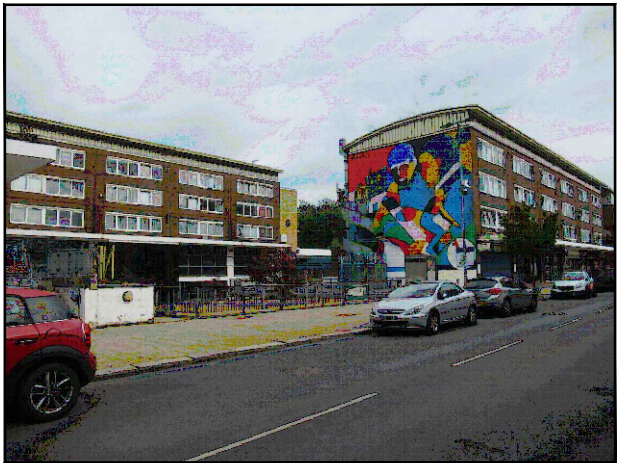

Reproduced by permission of Ordnance Survey on behalf of the Controller of Her Majesty's Stationery Office
All rights reserved. © Crown Copyright licence no. 100022432


SITE AREA PLAN



SITE PHOTOGRAPH




SITE LOCATION

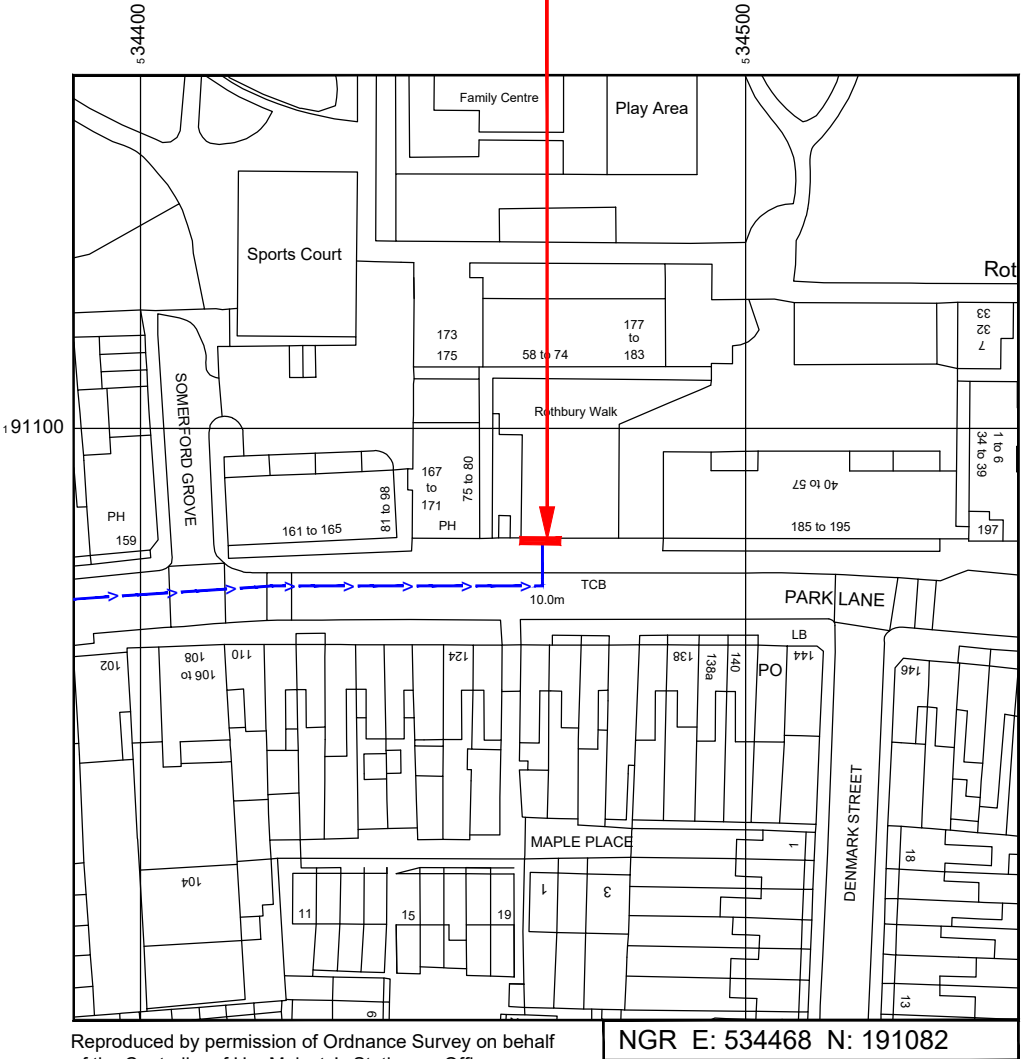

Reproduced by permission of Ordnance Survey on behalf of the Controller of Her Majesty's Stationery Office
All rights reserved. © Crown Copyright licence no. 100022432

 SITE LOCATION PLAN



GOOGLE MAPS QR CODE

GOOGLE MAPS - <https://goo.gl/maps/UTk3xjRBJRrJu1Eh9>

GOOGLE STREETVIEW - <https://goo.gl/maps/62bDP32G2dUTS4fVA>

NOTES:

1. ALL DIMENSIONS IN MM UNLESS OTHERWISE NOTED.

DIRECTIONS TO SITE:
Head west on M25. At junction 25, take the A10 exit to London N/London C/Enfield/Hertford. At Waltham Cross Interchange, take the 1st exit onto Great Cambridge Rd/A10. Continue straight to stay on Great Cambridge Rd/A10. At the roundabout, take the 2nd exit and stay on Great Cambridge Rd/A10. At the roundabout, take the 1st exit onto Lordship Ln/A10. At the roundabout, take the 1st exit onto Lordship Ln/A109. Continue straight onto Lansdowne Rd. Turn left onto St Paul's Rd. Turn right onto Park Ln. Follow Park Ln and site location is on the left hand side.

Site Provider's
Property Boundary:



Access Route To Site:



Master	MBNL / EE / H3G	Project	Purpose of Issue	Issue
M001	H3G	H3G DENSIFICATION STREETWORKS	Planning	A
Date:	24/10/2022	Revision / Upgrade Description:		
Drawn:	CDN	First Issue - Site nomination dated: TBC		
Checked:	J. Glover			
Approved:	J. Glover			



Hutchison 3G UK Limited
Green Park, 450 Longwater Avenue
Reading, RG30 3UR
Tel: 01628 765 000
Fax: 01628 765 001

H3G Base Station Information line:
0845 6043000
Available 8am-8pm Monday to Friday

Design Consultant & Principal Contractor:



Unit E, Madison Place, Northampton Road,
Manchester, M40 5AG
Tel: 0161 785 4500 Fax: 0161 785 4501
Web: www.clarke-telecom.com

Site Name:
PARK LANE STREETWORKS

Site ID:
HGY23676

Address:
**PARK LANE,
TOTTENHAM,
LONDON BOROUGH OF HARINGEY,
GREATER LONDON,
ENGLAND,
N17 0JP**


Title:
002 SITE LOCATION PLAN

Project:
H3G DENSIFICATION STREETWORKS

Purpose of Issue:
PLANNING


MBNL Cell ID: HGY191	3UK Cell ID: N1239
--------------------------------	------------------------------

Master Drawing No: HGY23676_B35_GA_A	Issue: A
--	--------------------

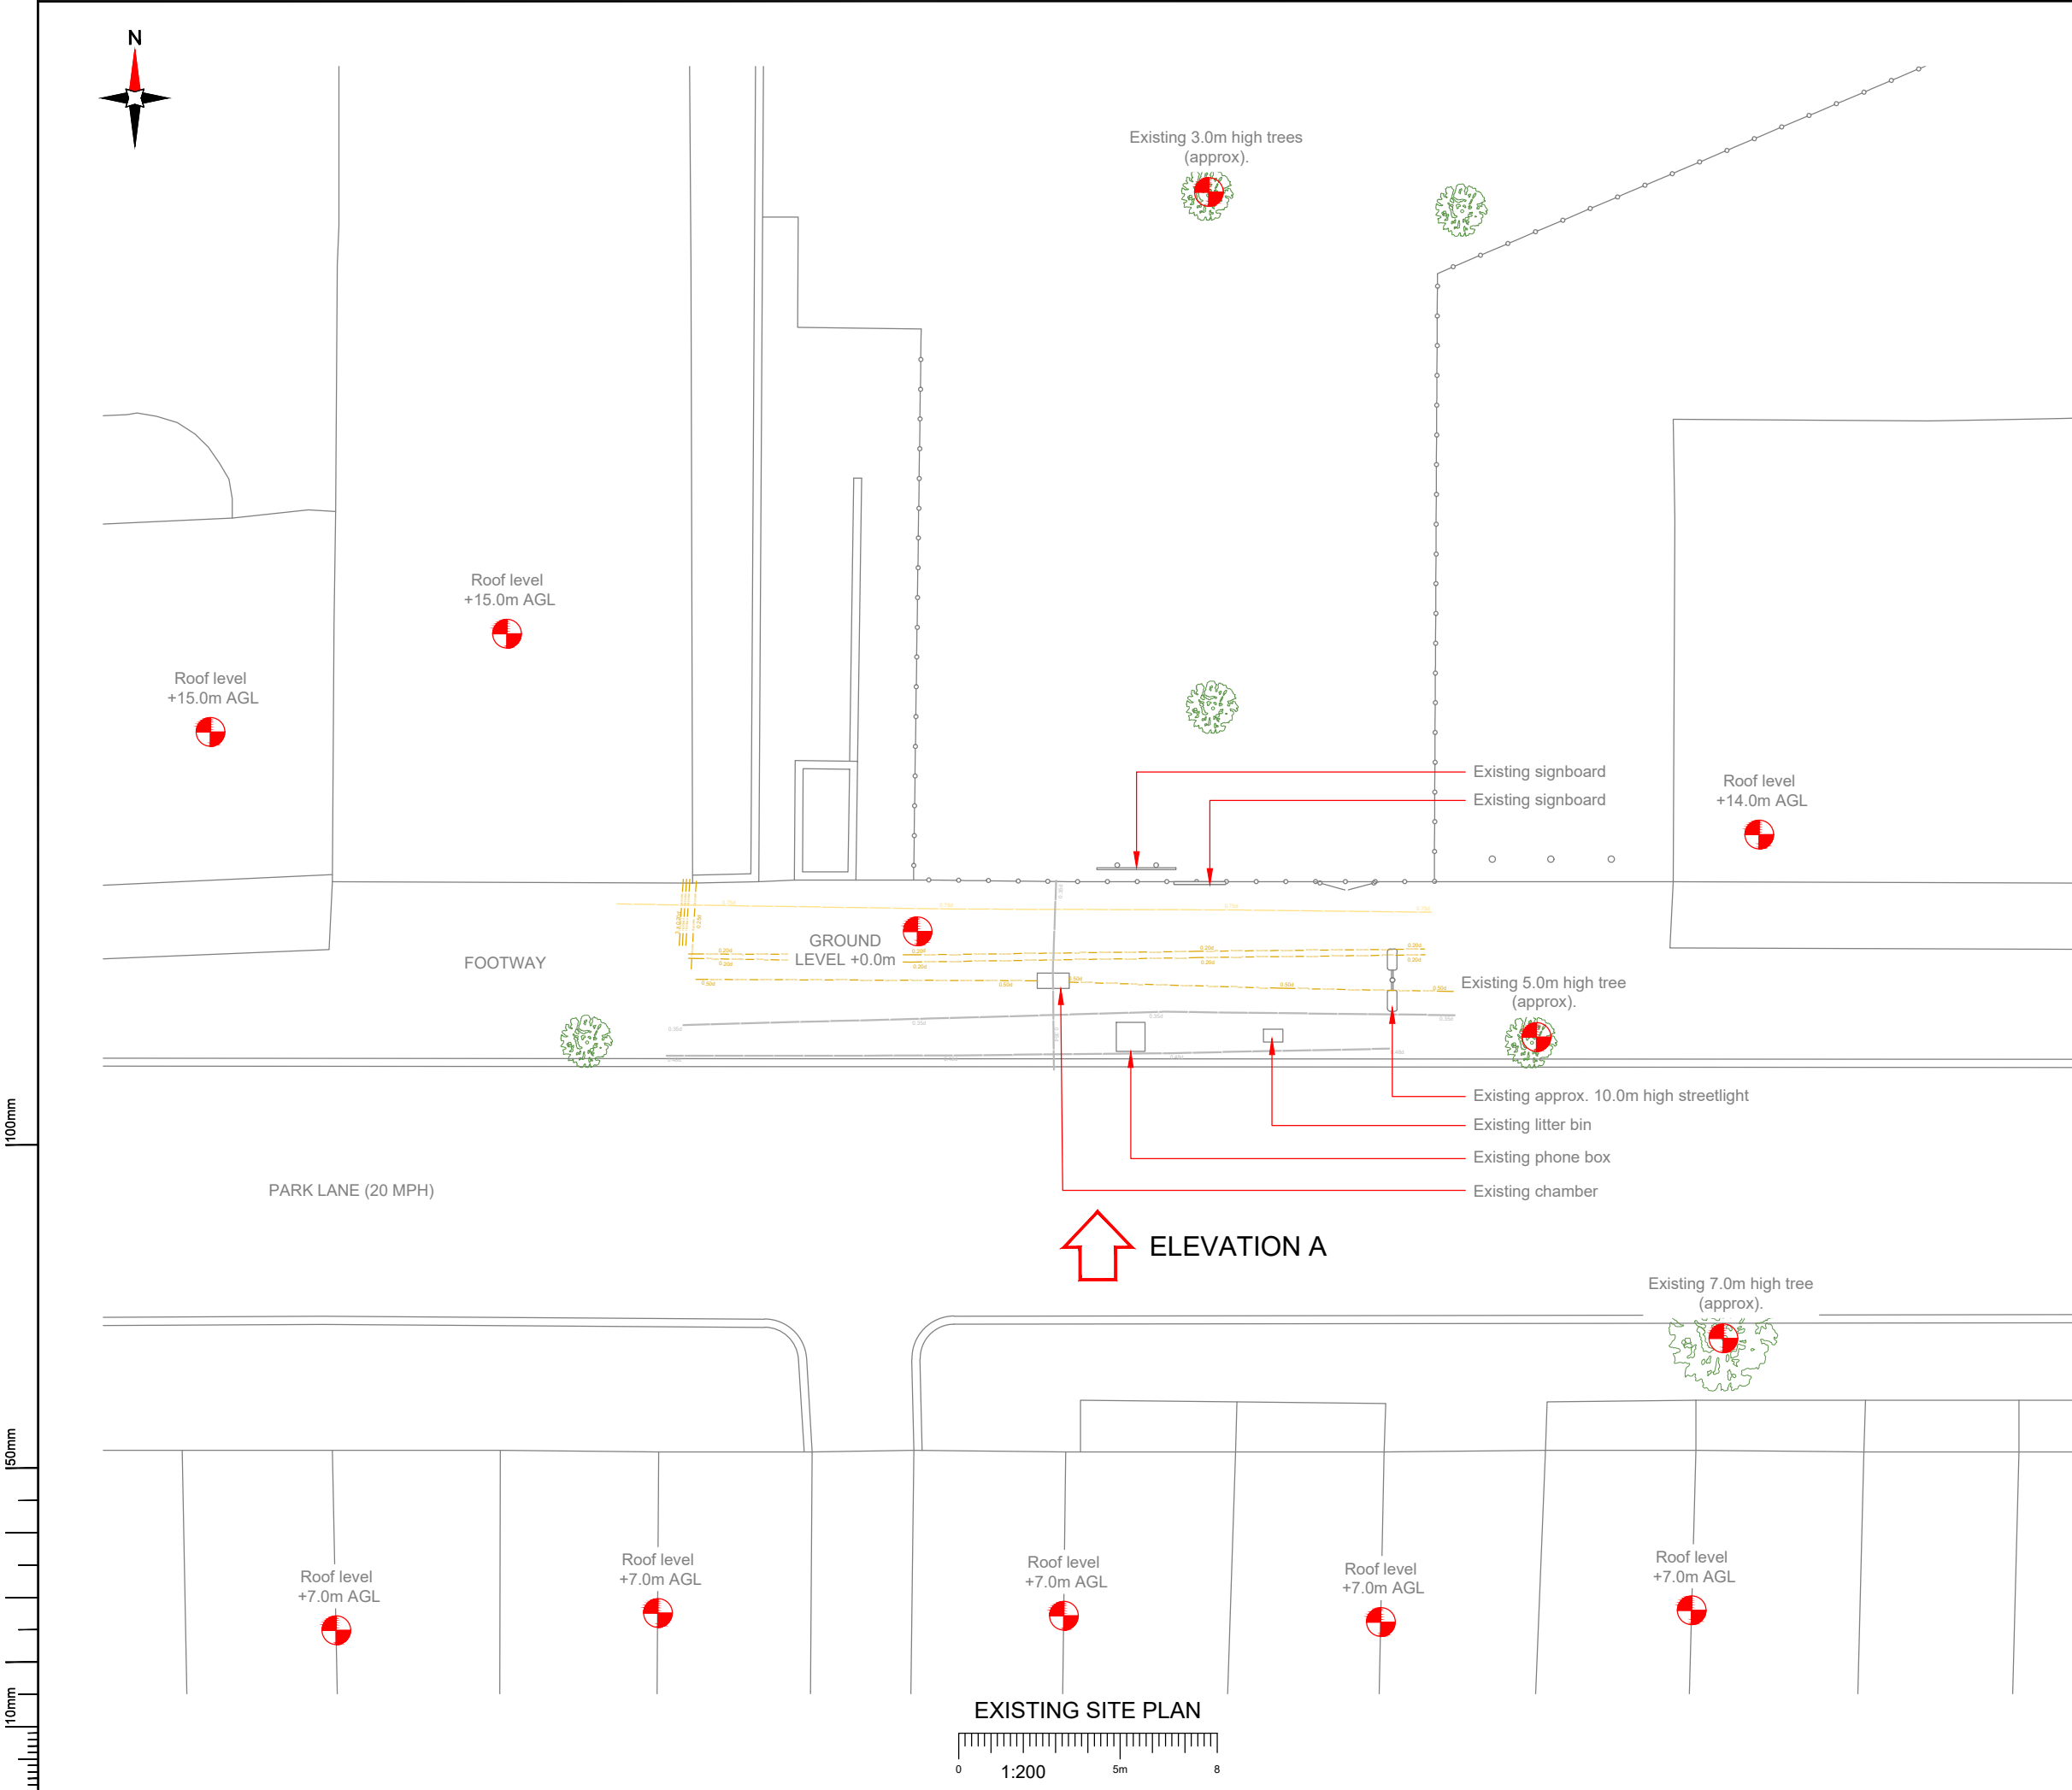

NOTES:

1. ALL DIMENSIONS IN MM UNLESS OTHERWISE NOTED.

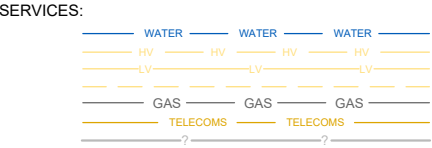

NOTES:

Radar Scan and Stats to be reviewed prior to any build works commencing

Master:	MBNL / EE / H3G:	Project:	Purpose of Issue:	Issue:
M001	H3G	H3G DENSIFICATION STREETWORKS	Planning	A
Date:	24/10/2022	Revision / Upgrade Description:		
Drawn:	CDN	First Issue - Site nomination dated: TBC		
Checked:	J. Glover			
Approved:	J. Glover			




Hutchison 3G UK Limited
Green Park, 450 Longwater Avenue
Reading, RG30 3UR
Tel: 01628 765 000
Fax: 01628 765 001

H3G Base Station Information line:
0845 6043000
Available 8am-8pm Monday to Friday

Design Consultant & Principal Contractor:

Unit E, Madison Place, Northampton Road,
Manchester, M40 5AG
Tel: 0161 785 4500 Fax: 0161 785 4501
Web: www.clarke-telecom.com

Site Name:		PARK LANE STREETWORKS	
Site ID:		HGY23676	
Address:		PARK LANE, TOTTENHAM, LONDON BOROUGH OF HARINGEY, GREATER LONDON, ENGLAND, N17 0JP	
Title:		100 EXISTING SITE PLAN	
Project:		H3G DENSIFICATION STREETWORKS	
Purpose of Issue:		PLANNING	
MBNL Cell ID: HGY191		3UK Cell ID: N1239	
Master Drawing No: HGY23676_B35_GA_A		Issue: A	

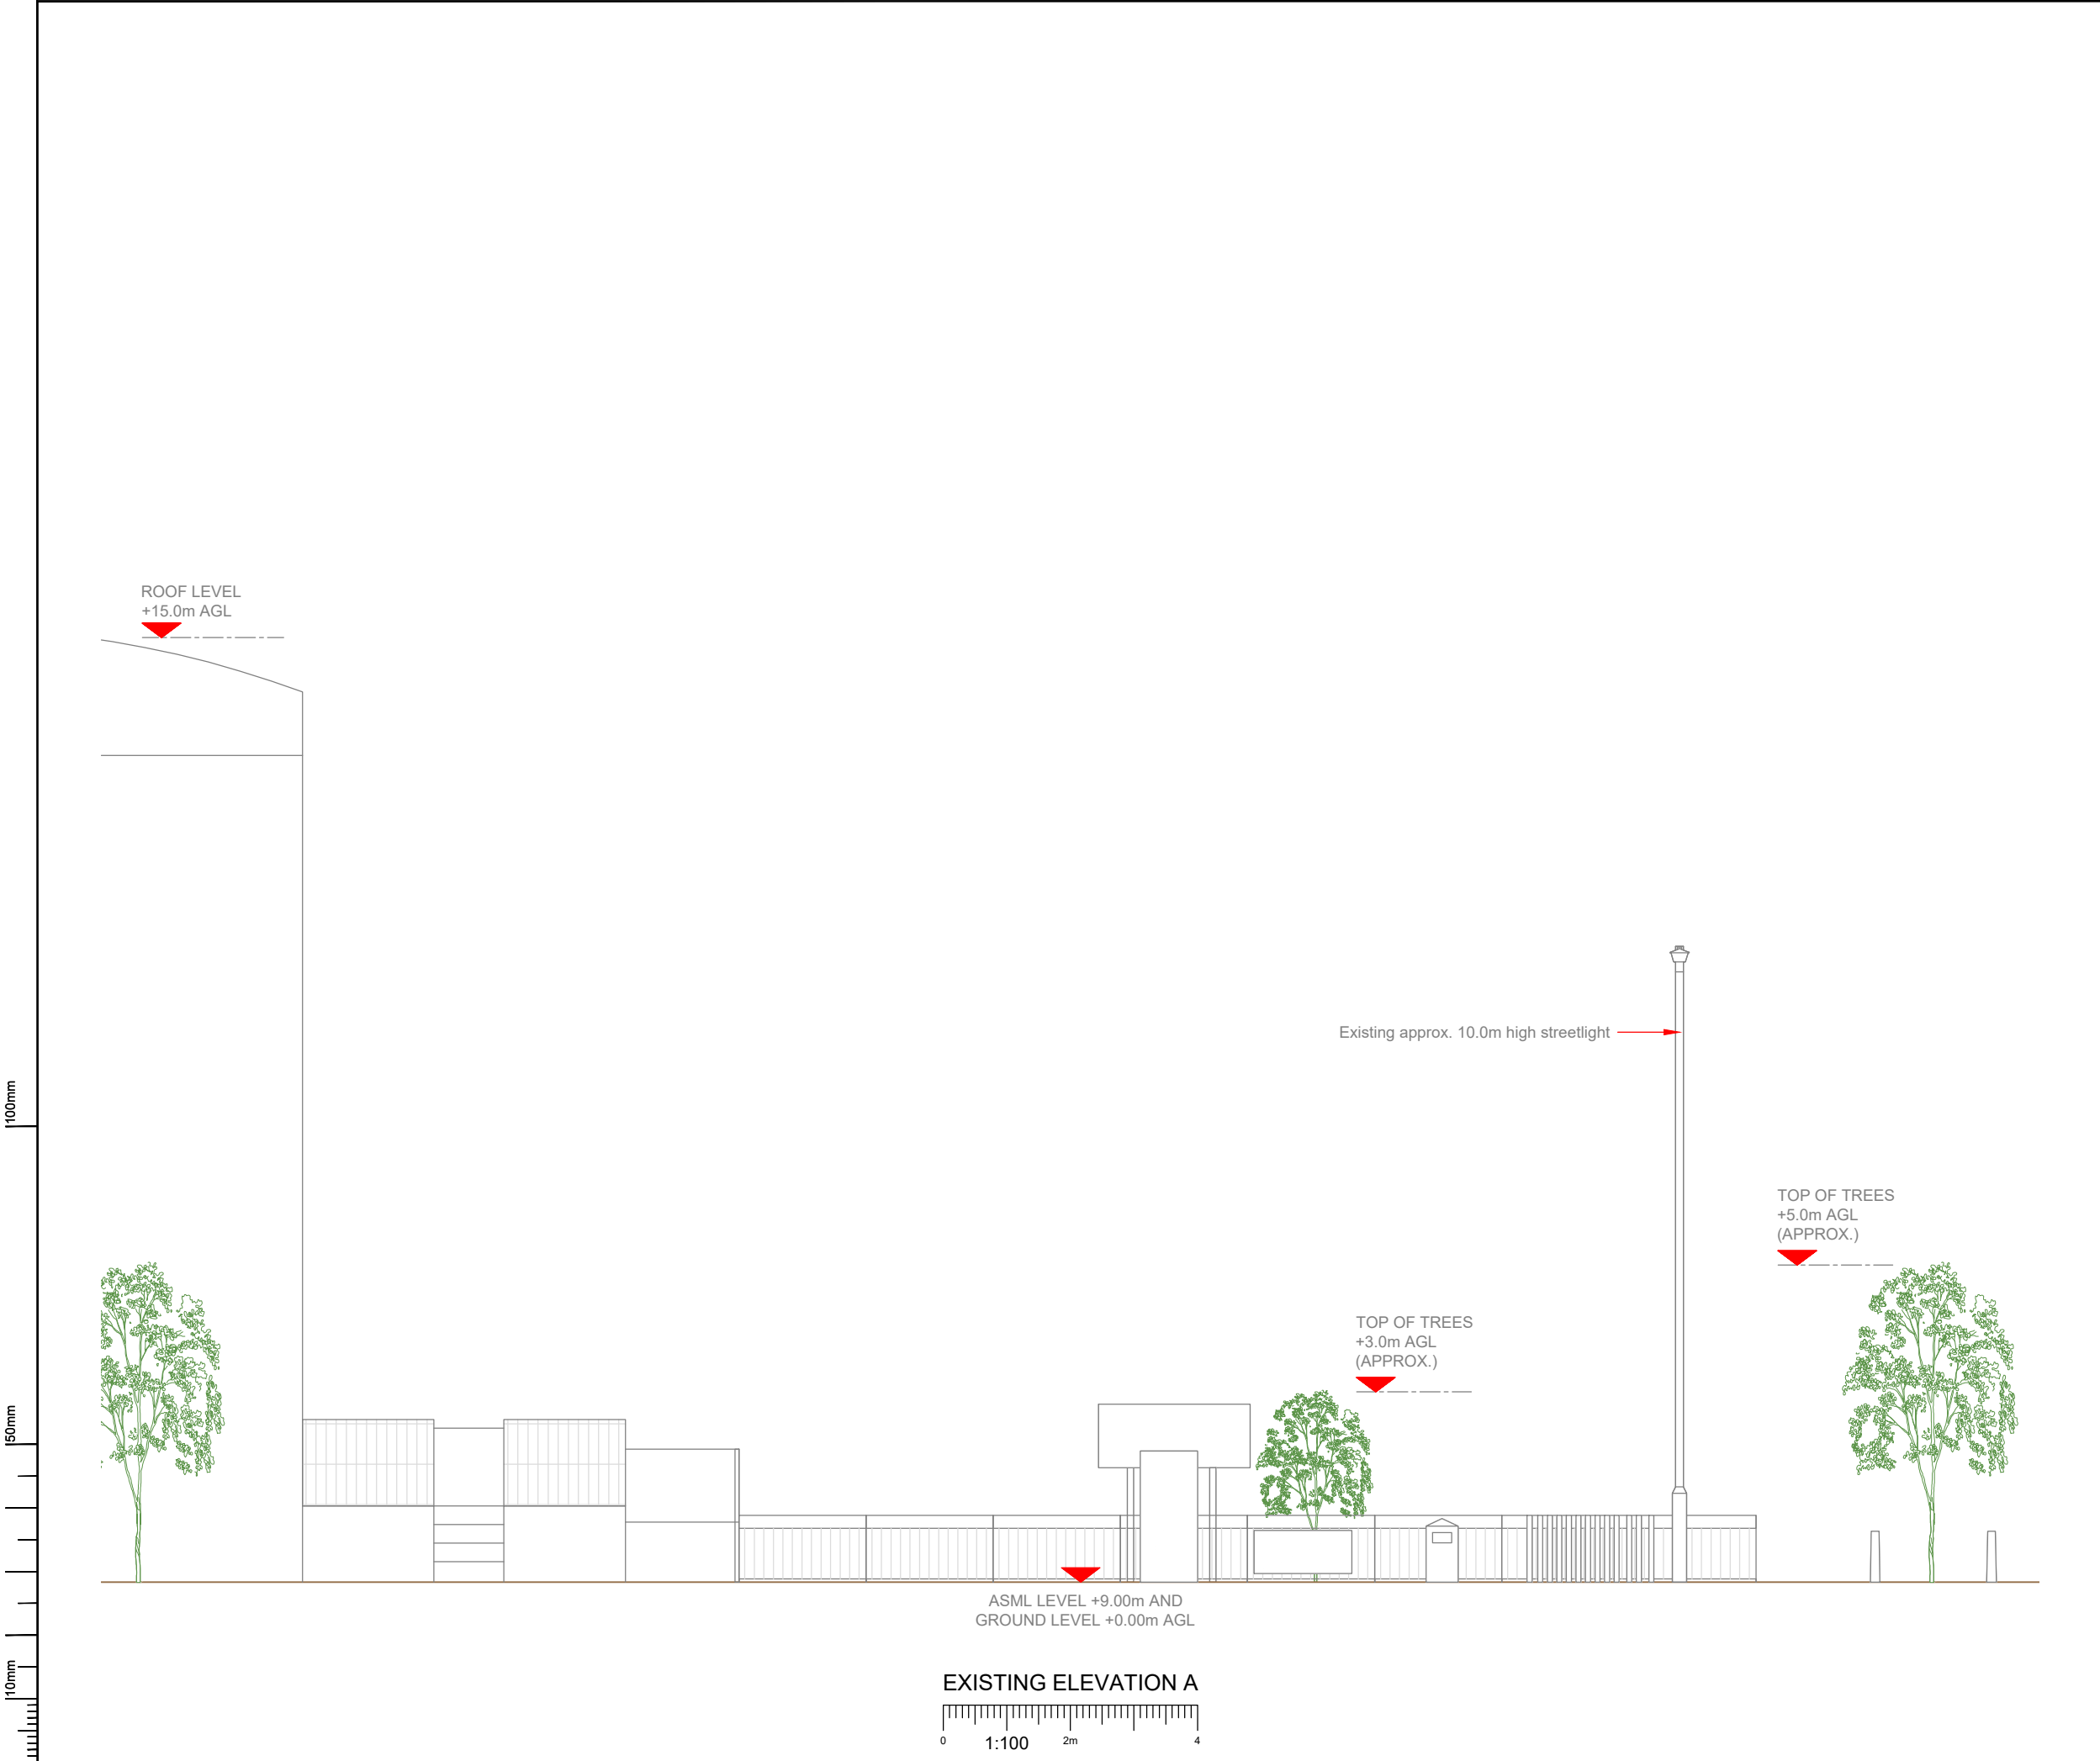

NOTES:

1. ALL DIMENSIONS IN MM UNLESS OTHERWISE NOTED.

Master:	MBNL / EE / H3G:	Project:	Purpose of Issue:	Issue:
M001	H3G	H3G DENSIFICATION STREETWORKS	Planning	A
Date:	24/10/2022	Revision / Upgrade Description:		
Drawn:	CDN	First Issue - Site nomination dated: TBC		
Checked:	J. Glover			
Approved:	J. Glover			



Hutchison 3G UK Limited
Green Park, 450 Longwater Avenue
Reading, RG30 3UR
Tel: 01628 765 000
Fax: 01628 765 001

H3G Base Station Information line:
0845 6043000
Available 8am-8pm Monday to Friday

Design Consultant & Principal Contractor:



Unit E, Madison Place, Northampton Road,
Manchester, M40 5AG
Tel: 0161 785 4500 Fax: 0161 785 4501
Web: www.clarke-telecom.com

Site Name:
PARK LANE STREETWORKS

Site ID:
HGY23676

Address:
PARK LANE,
TOTTENHAM,
LONDON BOROUGH OF HARINGEY,
GREATER LONDON,
ENGLAND,
N17 0JP

Title:
150 EXISTING SITE ELEVATION

Project:
H3G DENSIFICATION STREETWORKS

Purpose of Issue:
PLANNING

MBNL Cell ID: HGY191	3UK Cell ID: N1239
-------------------------	-----------------------

Master Drawing No: HGY23676_B35_GA_A	Issue: A
---	-------------



NOTES:
Radar Scan and Stats to be reviewed prior to any
build works commencing


Design Consultant & Principal Contractor:


Unit E, Madison Place, Northampton Road,
Manchester, M40 5AG
Tel: 0161 785 4500 Fax: 0161 785 4501
Web: www.clarke-telecom.com

Address: PARK LANE,
TOTTENHAM,
LONDON BOROUGH OF HARINGEY,
GREATER LONDON,
ENGLAND,
N17 0JP

Master Drawing No:	HGY23676_B35_GA_A	Issue:	A
--------------------	-------------------	--------	---

100mm
50mm
10mm

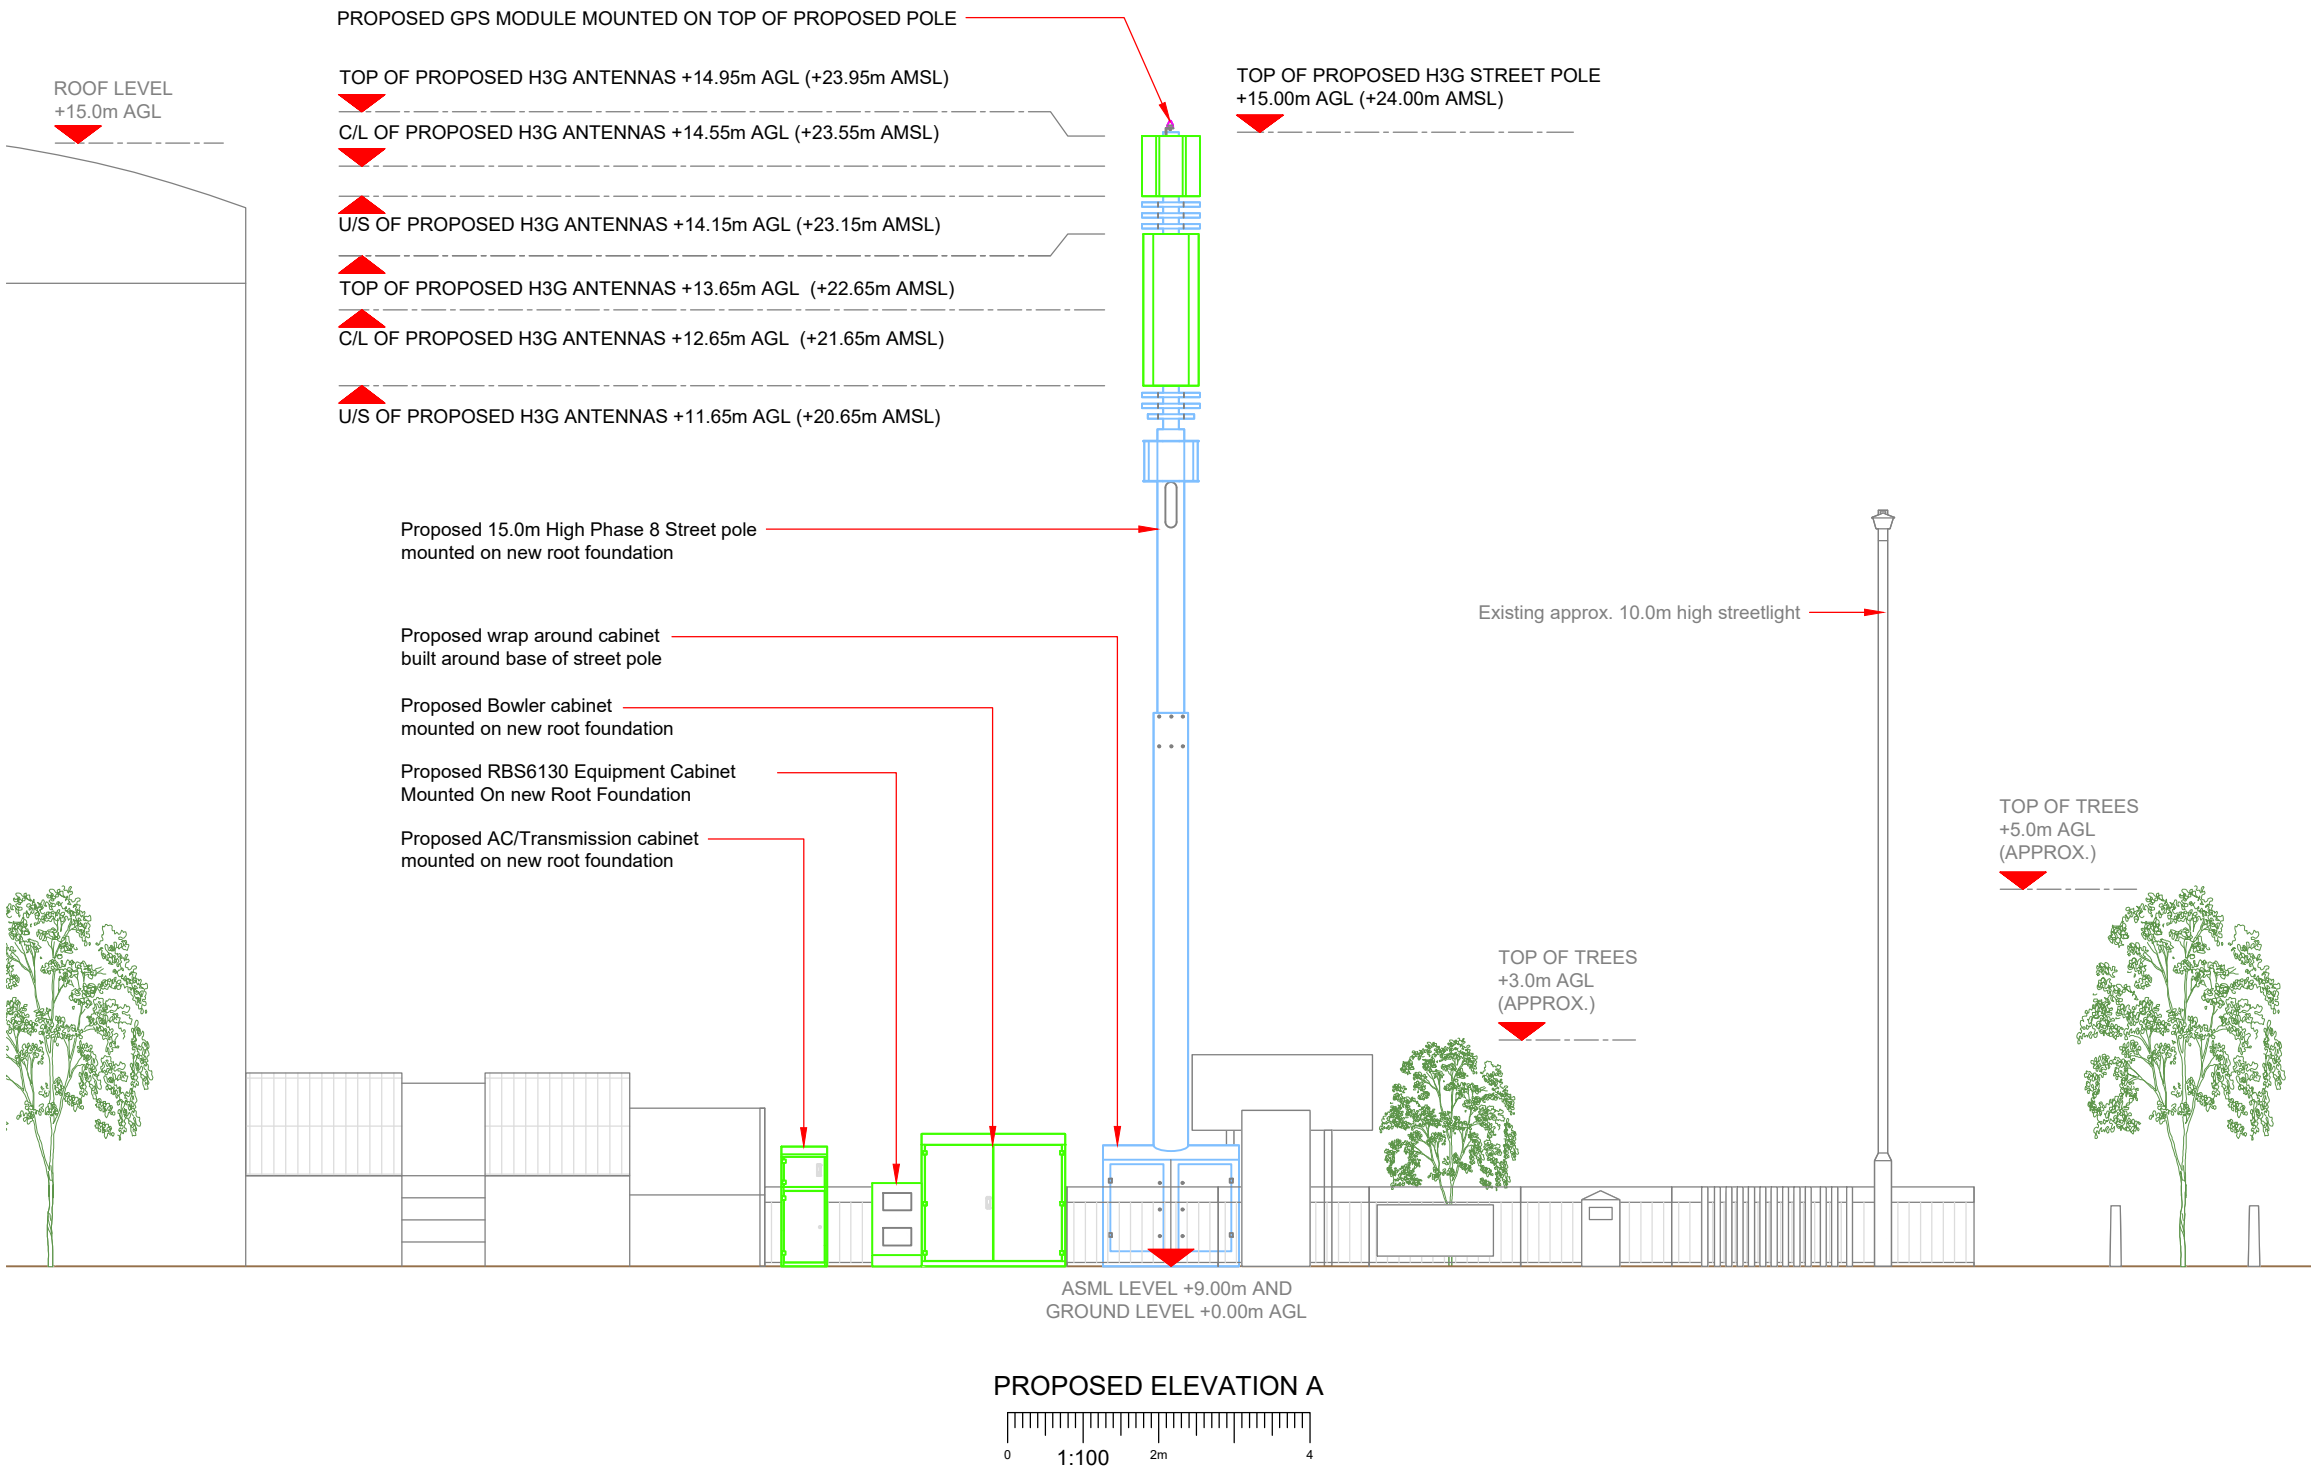

NOTES:

1. ALL DIMENSIONS IN MM UNLESS OTHERWISE NOTED.

Master:	MBNL / EE / H3G:	Project:	Purpose of Issue:	Issue:
M001	H3G	H3G DENSIFICATION STREETWORKS	Planning	A
Date:	24/10/2022	Revision / Upgrade Description:		
Drawn:	CDN	First Issue - Site nomination dated: TBC		
Checked:	J. Glover			
Approved:	J. Glover			



Hutchison 3G UK Limited
Green Park, 450 Longwater Avenue
Reading, RG30 3UR
Tel: 01628 765 000
Fax: 01628 765 001

H3G Base Station Information line:
0845 6043000
Available 8am-8pm Monday to Friday

Design Consultant & Principal Contractor:


Unit E, Madison Place, Northampton Road,
Manchester, M40 5AG
Tel: 0161 785 4500 Fax: 0161 785 4501
Web: www.clarke-telecom.com

Site Name:
PARK LANE STREETWORKS

Site ID:
HGY23676

Address:
PARK LANE,
TOTTENHAM,
LONDON BOROUGH OF HARINGEY,
GREATER LONDON,
ENGLAND,
N17 0JP

Title:
260 PROPOSED ELEVATION

Project:
H3G DENSIFICATION STREETWORKS

Purpose of Issue:
PLANNING

MBNL Cell ID:	3UK Cell ID:
HGY191	N1239

Master Drawing No:	Issue:
HGY23676_B35_GA_A	A