


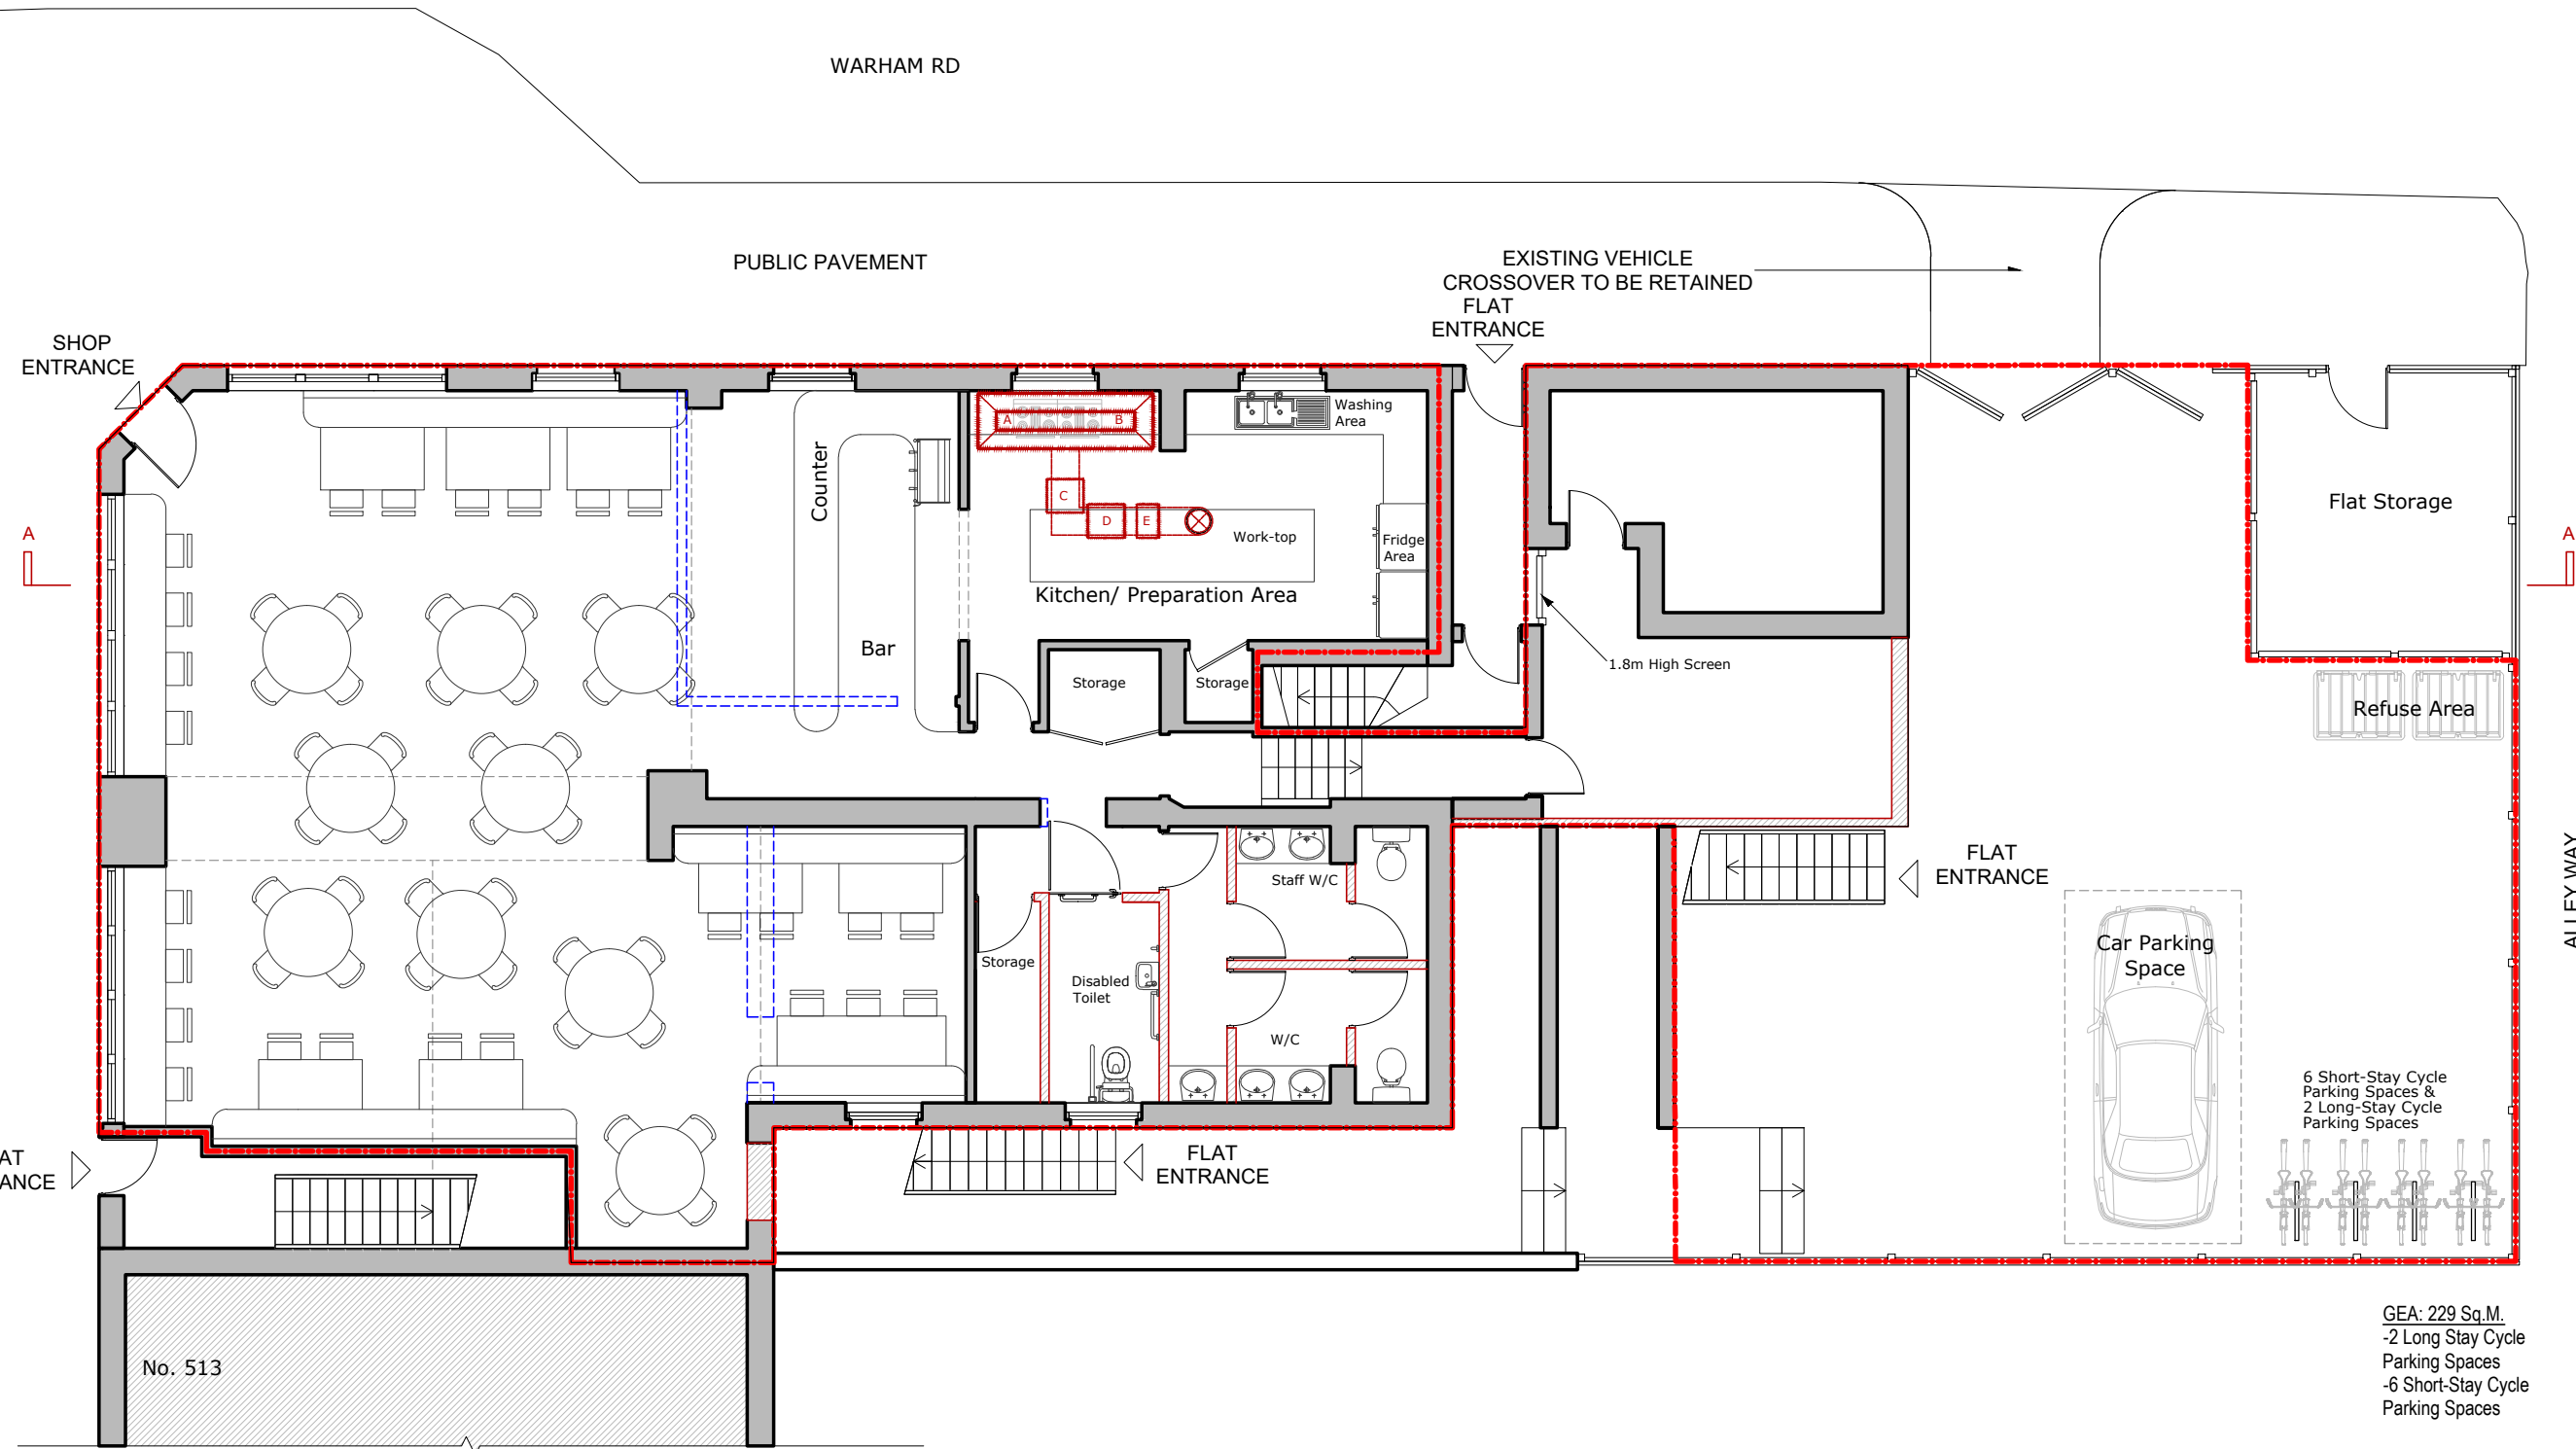

GEA: 229 Sq.M.
-2 Long Stay Cycle
Parking Spaces
-6 Short-Stay Cycle
Parking Spaces

SCHEMATIC DIAGRAM OF A KITCHEN VENTILATION SYSTEM LEGEND

- A. COOKING AREA
B. CANOPY
GFBE JASUN BAFFLE GREASE FILTERS CODE:GFBEx-1818
SIZE:445X445X45MM
RATED AIRFLOW M3HR:1089 FILTERS TO BE INSTALLED AT
ANGLE OF NOT LESS THAN 45° AT FROM HORIZONTAL
C. ACTIVATED CARBON FILTERS
WIRE MESH SUPPORTED PLEATED
SYNTHETIC MEDIA (EU4)
PREFILTER MUST BE REPLACED EVERY
2-4 WEEKS
D. FAN/ MOTOR UNIT
MODEL NO.: GBW500.1.1
HELIOS CENTRIFUGAL FAN
E. SOUND ATTENUATORS

PLEASE NOTE
1. All dimensions to be verified on site.
2. All dimensions are in millimeters.
3. No work shall commence until all approvals
and agreements have been obtained.
These include, Planning, Building
Regulations, Water and party Wall.
4. The Copyright of this drawing belong to
Adv Planning Limited T/A Advance Architecture.



Drawn By T.Y
Checked By K.K

PROJECT
STATUS

PLANNING
EXISTING GROUND
FLOOR PLAN

PROJECT

509-511 GREEN
LANES, HORNSEY,
LONDON, N4 1AN

SHEET
JOB No.

PLAN
22.040

DRAWING
NUMBER
DATE

P104

REV
R1