
 


SITE LOCATION

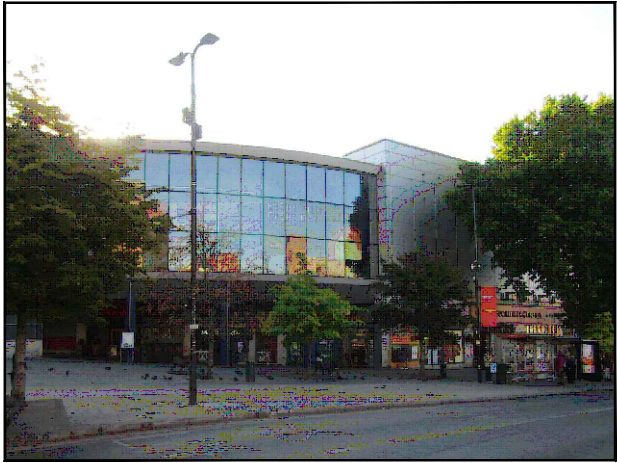

Reproduced by permission of Ordnance Survey on behalf of the Controller of Her Majesty's Stationery Office
All rights reserved. © Crown Copyright licence no. 100022432


SITE AREA PLAN



SITE PHOTOGRAPH


N

SITE LOCATION

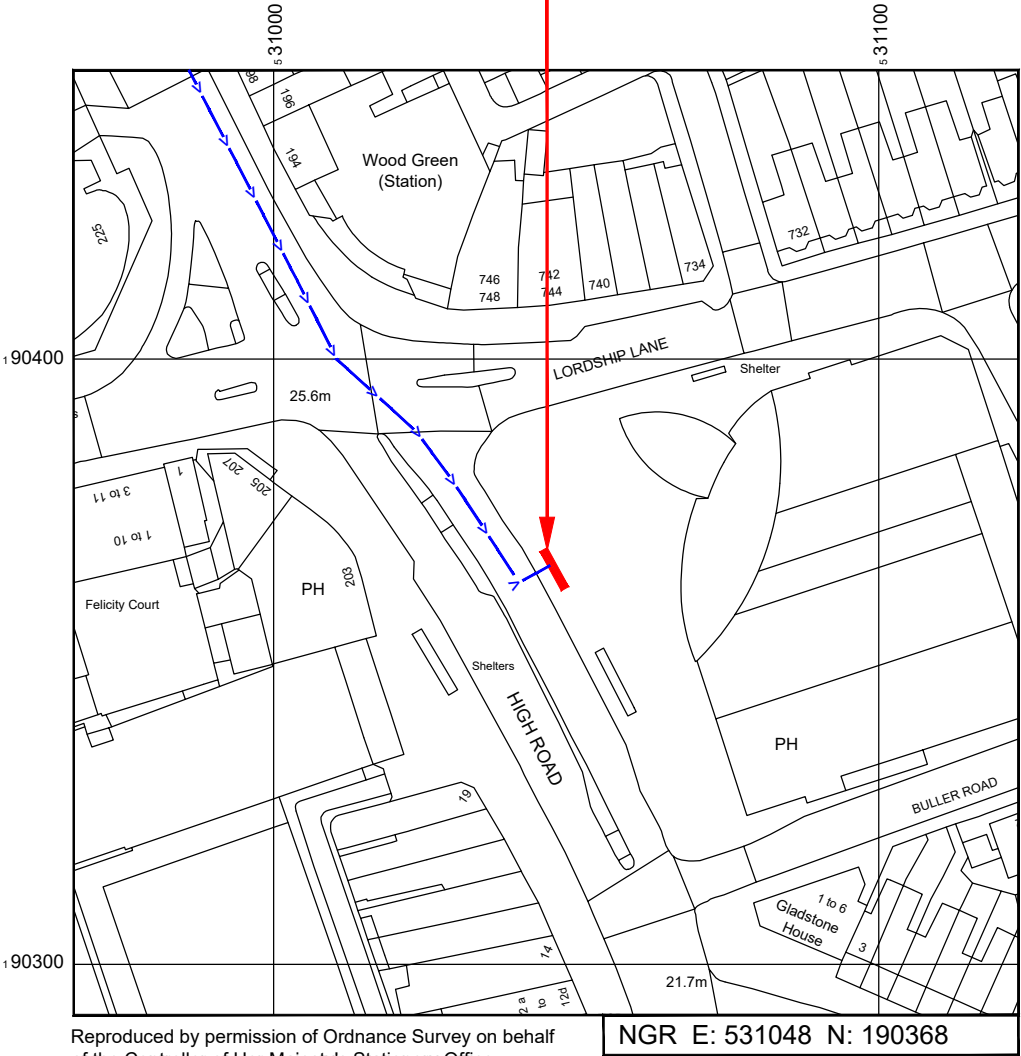

Reproduced by permission of Ordnance Survey on behalf of the Controller of Her Majesty's Stationery Office
All rights reserved. © Crown Copyright licence no. 100022432

 SITE LOCATION PLAN



GOOGLE MAPS QR CODE

GOOGLE MAPS - <https://goo.gl/maps/uqKW3twHoCMNV9Kk6>

GOOGLE STREETVIEW - <https://goo.gl/maps/mDebKoaAbiHY9edk6>

NOTES:

1. ALL DIMENSIONS IN MM UNLESS OTHERWISE NOTED.

DIRECTIONS TO SITE:
Head south-east on M1. Keep left. Merge onto N Circular Rd./A406. Keep left to stay on N Circular Rd./A406. Keep right to continue towards Bounds Green Rd/A109. Slight right onto Bounds Green Rd/A109. Turn right onto High Rd/A105. Follow High Road and site location is on the left hand side.

Site Provider's
Property Boundary:



Access Route To Site:



Master	MBNL / EE / H3G	Project	Purpose of Issue	Issue
M001	H3G	H3G DENSIFICATION STREETWORKS	Planning	A
Date:	07/11/2022	Revision / Upgrade Description:		
Drawn:	CDN	First Issue - Site nomination dated: TBC		
Checked:	J. Glover			
Approved:	J. Glover			



Hutchison 3G UK Limited
Green Park, 450 Longwater Avenue
Reading, RG30 3UR
Tel: 01628 765 000
Fax: 01628 765 001

H3G Base Station Information line:
0845 6043000
Available 8am-8pm Monday to Friday

Design Consultant & Principal Contractor:



Unit E, Madison Place, Northampton Road,
Manchester, M40 5AG
Tel: 0161 785 4500 Fax: 0161 785 4501
Web: www.clarke-telecom.com

Site Name:
HIGH ROAD STREETWORKS

Site ID:
HGY23662

Address:
HIGH ROAD
HOLLYWOOD GREEN
HORNSEY PARK
LONDON
ENGLAND
N22 6EJ

Title:
002 SITE LOCATION PLAN

Project:
H3G DENSIFICATION STREETWORKS

Purpose of Issue:
PLANNING

MBNL Cell ID: HGY188	3UK Cell ID: N1237
-------------------------	-----------------------

Master Drawing No: HGY23662_B35_GA_A	Issue: A
---	-------------



Existing approx. 8.0m high streetlight

ELEVATION A

Existing approx. 8.0m high streetlight

Existing bus stop shelter

EXISTING SITE PLAN



NOTES:

1. ALL DIMENSIONS IN MM UNLESS OTHERWISE NOTED.

SERVICES:

WATER

WATER

WATER

WATER

HV

HV

HV

HV

LV

LV

LV

LV

GAS

GAS

GAS

GAS

TELECOMS

TELECOMS

TELECOMS

TELECOMS

?

?

?

?

NOTES:
Radar Scan and Stats to be reviewed prior to any build works commencing

Master:	MBNL / EE / H3G:	Project:	Purpose of Issue:	Issue:
M001	H3G	H3G DENSIFICATION STREETWORKS	Planning	A
Date:	07/11/2022	Revision / Upgrade Description:		
Drawn:	CDN	First Issue - Site nomination dated: TBC		
Checked:	J. Glover			
Approved:	J. Glover			



Hutchison 3G UK Limited
Green Park, 450 Longwater Avenue
Reading, RG30 3UR
Tel: 01628 765 000
Fax: 01628 765 001

H3G Base Station Information line:
0845 6043000
Available 8am-8pm Monday to Friday

Design Consultant & Principal Contractor:

CLARKE
telecom


Unit E, Madison Place, Northampton Road,
Manchester, M40 5AG
Tel: 0161 785 4500 Fax: 0161 785 4501
Web: www.clarke-telecom.com

Site Name:	HIGH ROAD STREETWORKS		
Site ID:	HGY23662		
Address:	HIGH ROAD HOLLYWOOD GREEN HORNSEY PARK LONDON ENGLAND N22 6EJ		
Title:	100 EXISTING SITE PLAN		
Project:	H3G DENSIFICATION STREETWORKS		
Purpose of Issue:	PLANNING		
MBNL Cell ID:	HGY188	3UK Cell ID:	N1237
Master Drawing No:	HGY23662_B35_GA_A		Issue: A


100mm

50mm

10mm

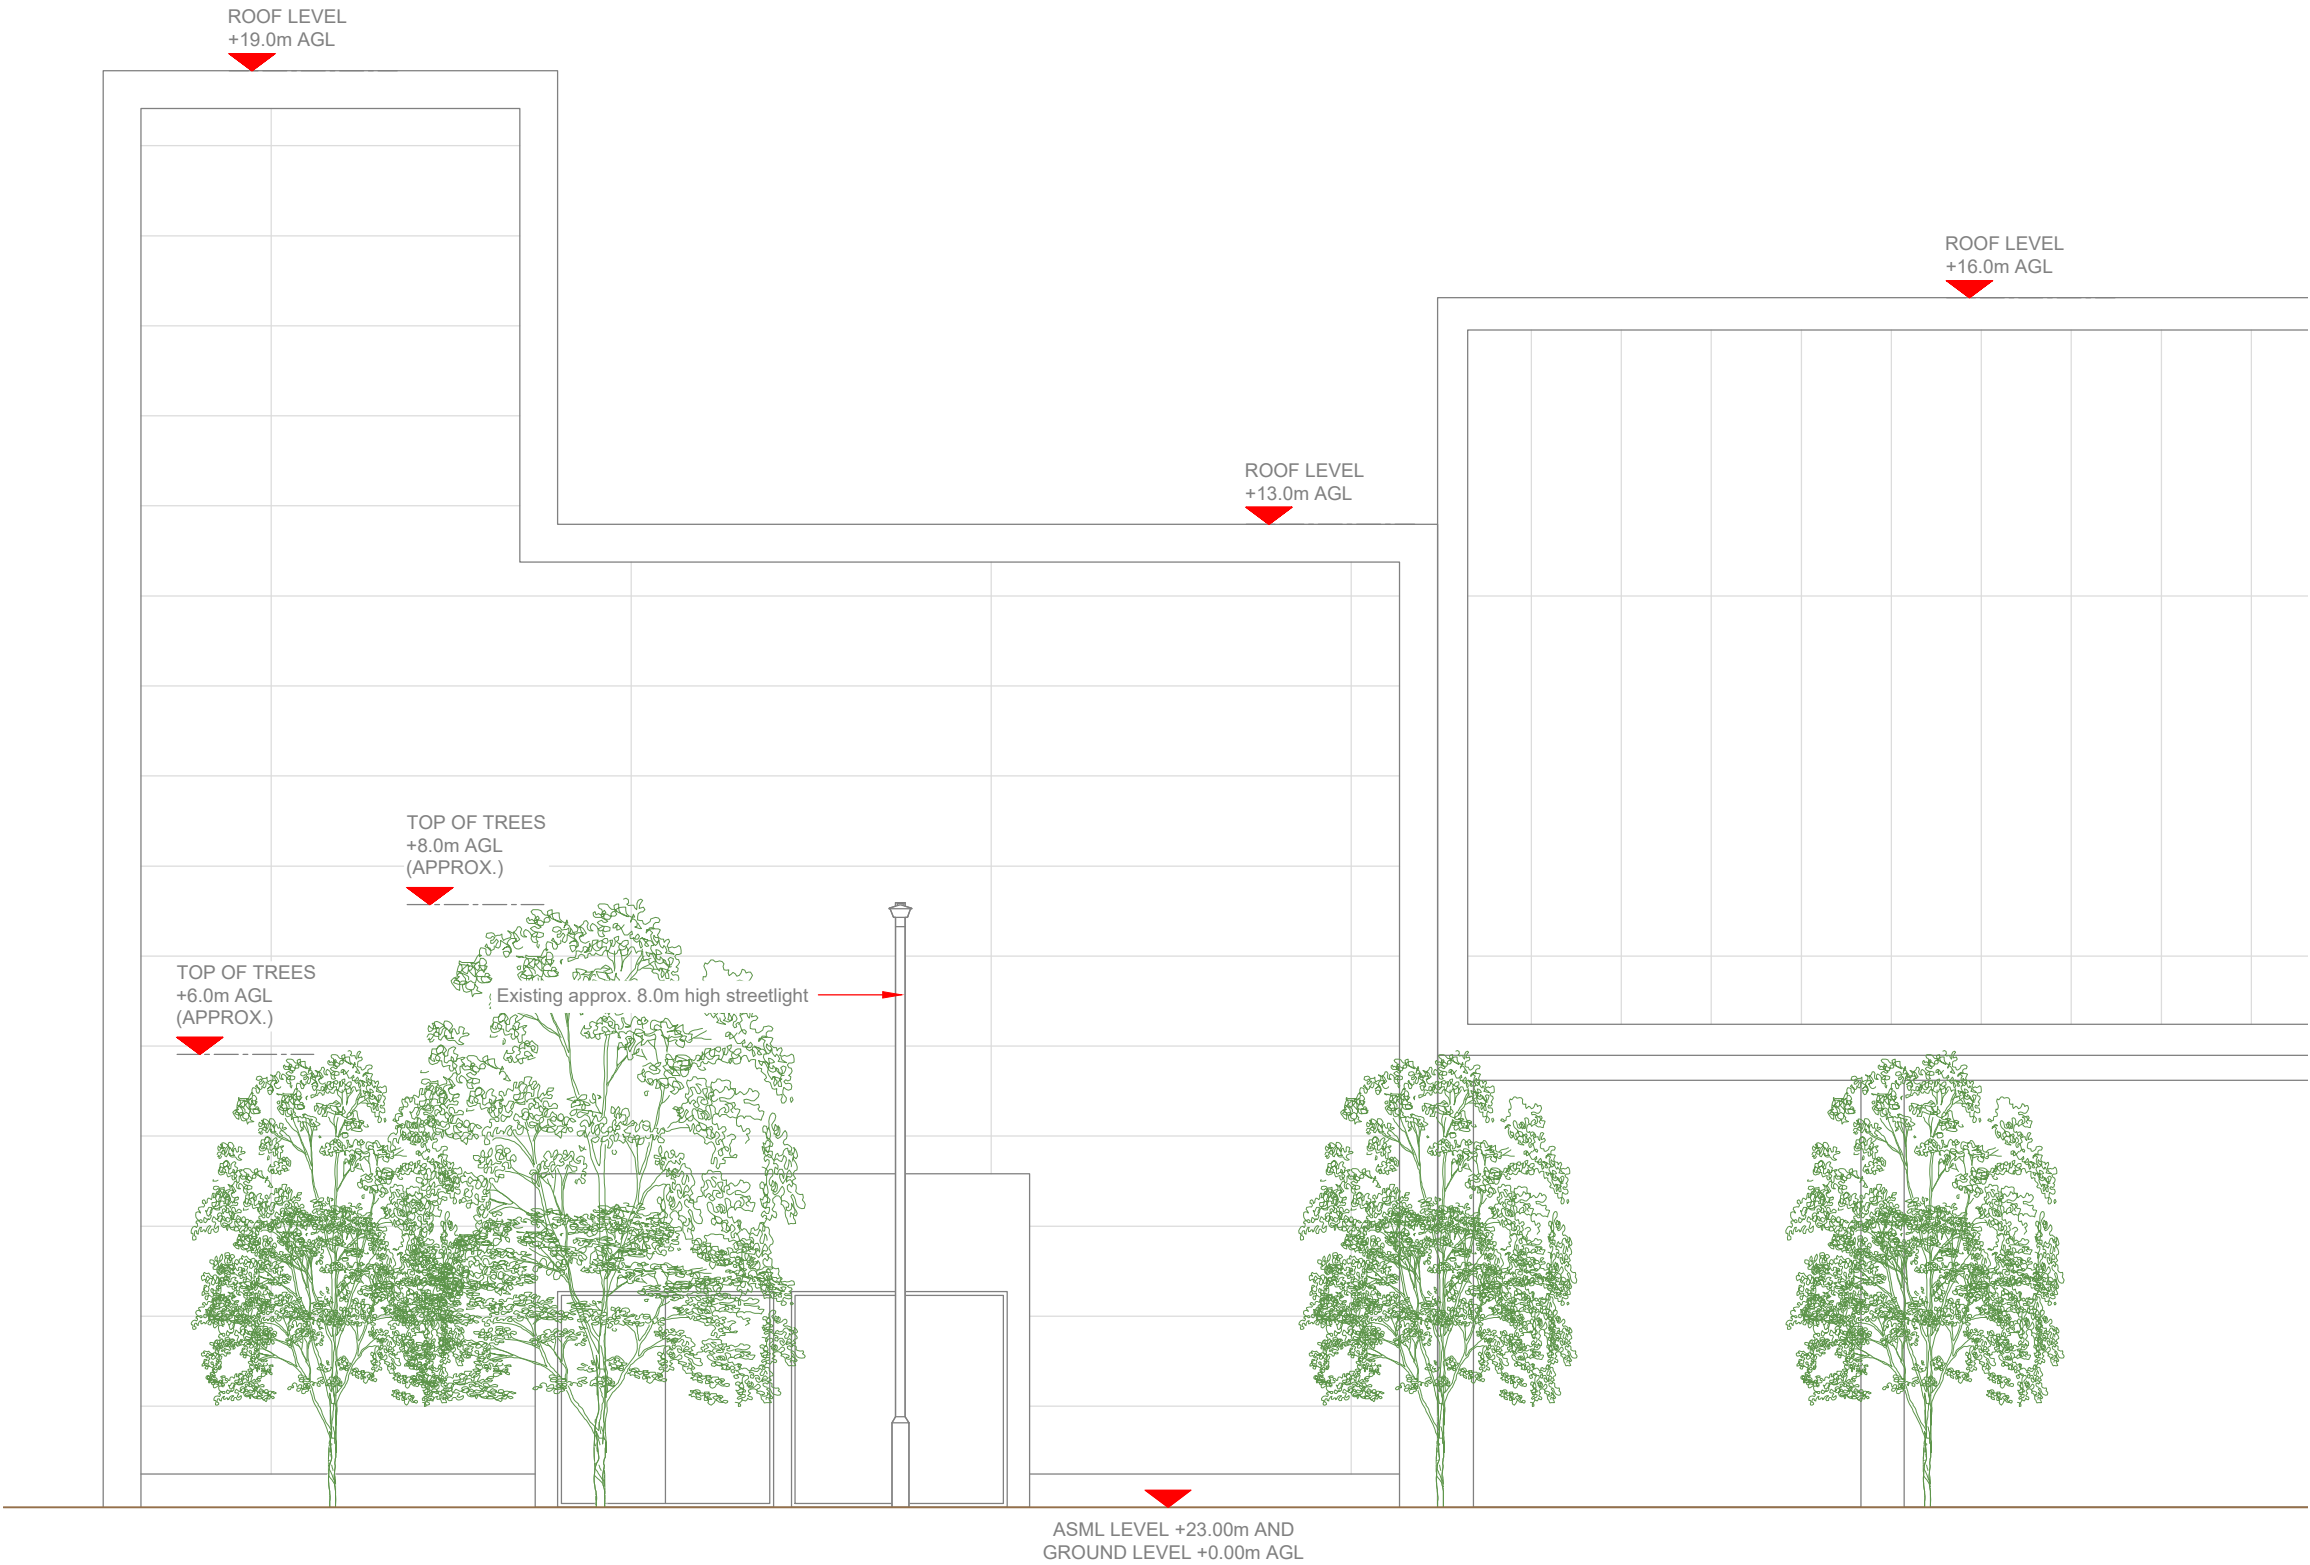

EXISTING ELEVATION A

 

- NOTES:
- ALL DIMENSIONS IN MM UNLESS OTHERWISE NOTED.

Master:	MBNL / EE / H3G:	Project:	Purpose of Issue:	Issue:
M001	H3G	H3G DENSIFICATION STREETWORKS	Planning	A
Date:	07/11/2022	Revision / Upgrade Description:		
Drawn:	CDN	First Issue - Site nomination dated: TBC		
Checked:	J. Glover			
Approved:	J. Glover			



Hutchison 3G UK Limited
Green Park, 450 Longwater Avenue
Reading, RG30 3UR
Tel: 01628 765 000
Fax: 01628 765 001

H3G Base Station Information line:
0845 6043000
Available 8am-8pm Monday to Friday

Design Consultant & Principal Contractor:



Unit E, Madison Place, Northampton Road,
Manchester, M40 5AG
Tel: 0161 785 4500 Fax: 0161 785 4501
Web: www.clarke-telecom.com

Site Name:
HIGH ROAD STREETWORKS

Site ID:
HGY23662

Address:
HIGH ROAD
HOLLYWOOD GREEN
HORNSEY PARK
LONDON
ENGLAND
N22 6EJ


Title:
150 EXISTING SITE ELEVATION

Project:
H3G DENSIFICATION STREETWORKS


Purpose of Issue:
PLANNING

MBNL Cell ID: HGY188	3UK Cell ID: N1237
-------------------------	-----------------------

Master Drawing No: HGY23662_B35_GA_A	Issue: A
---	-------------

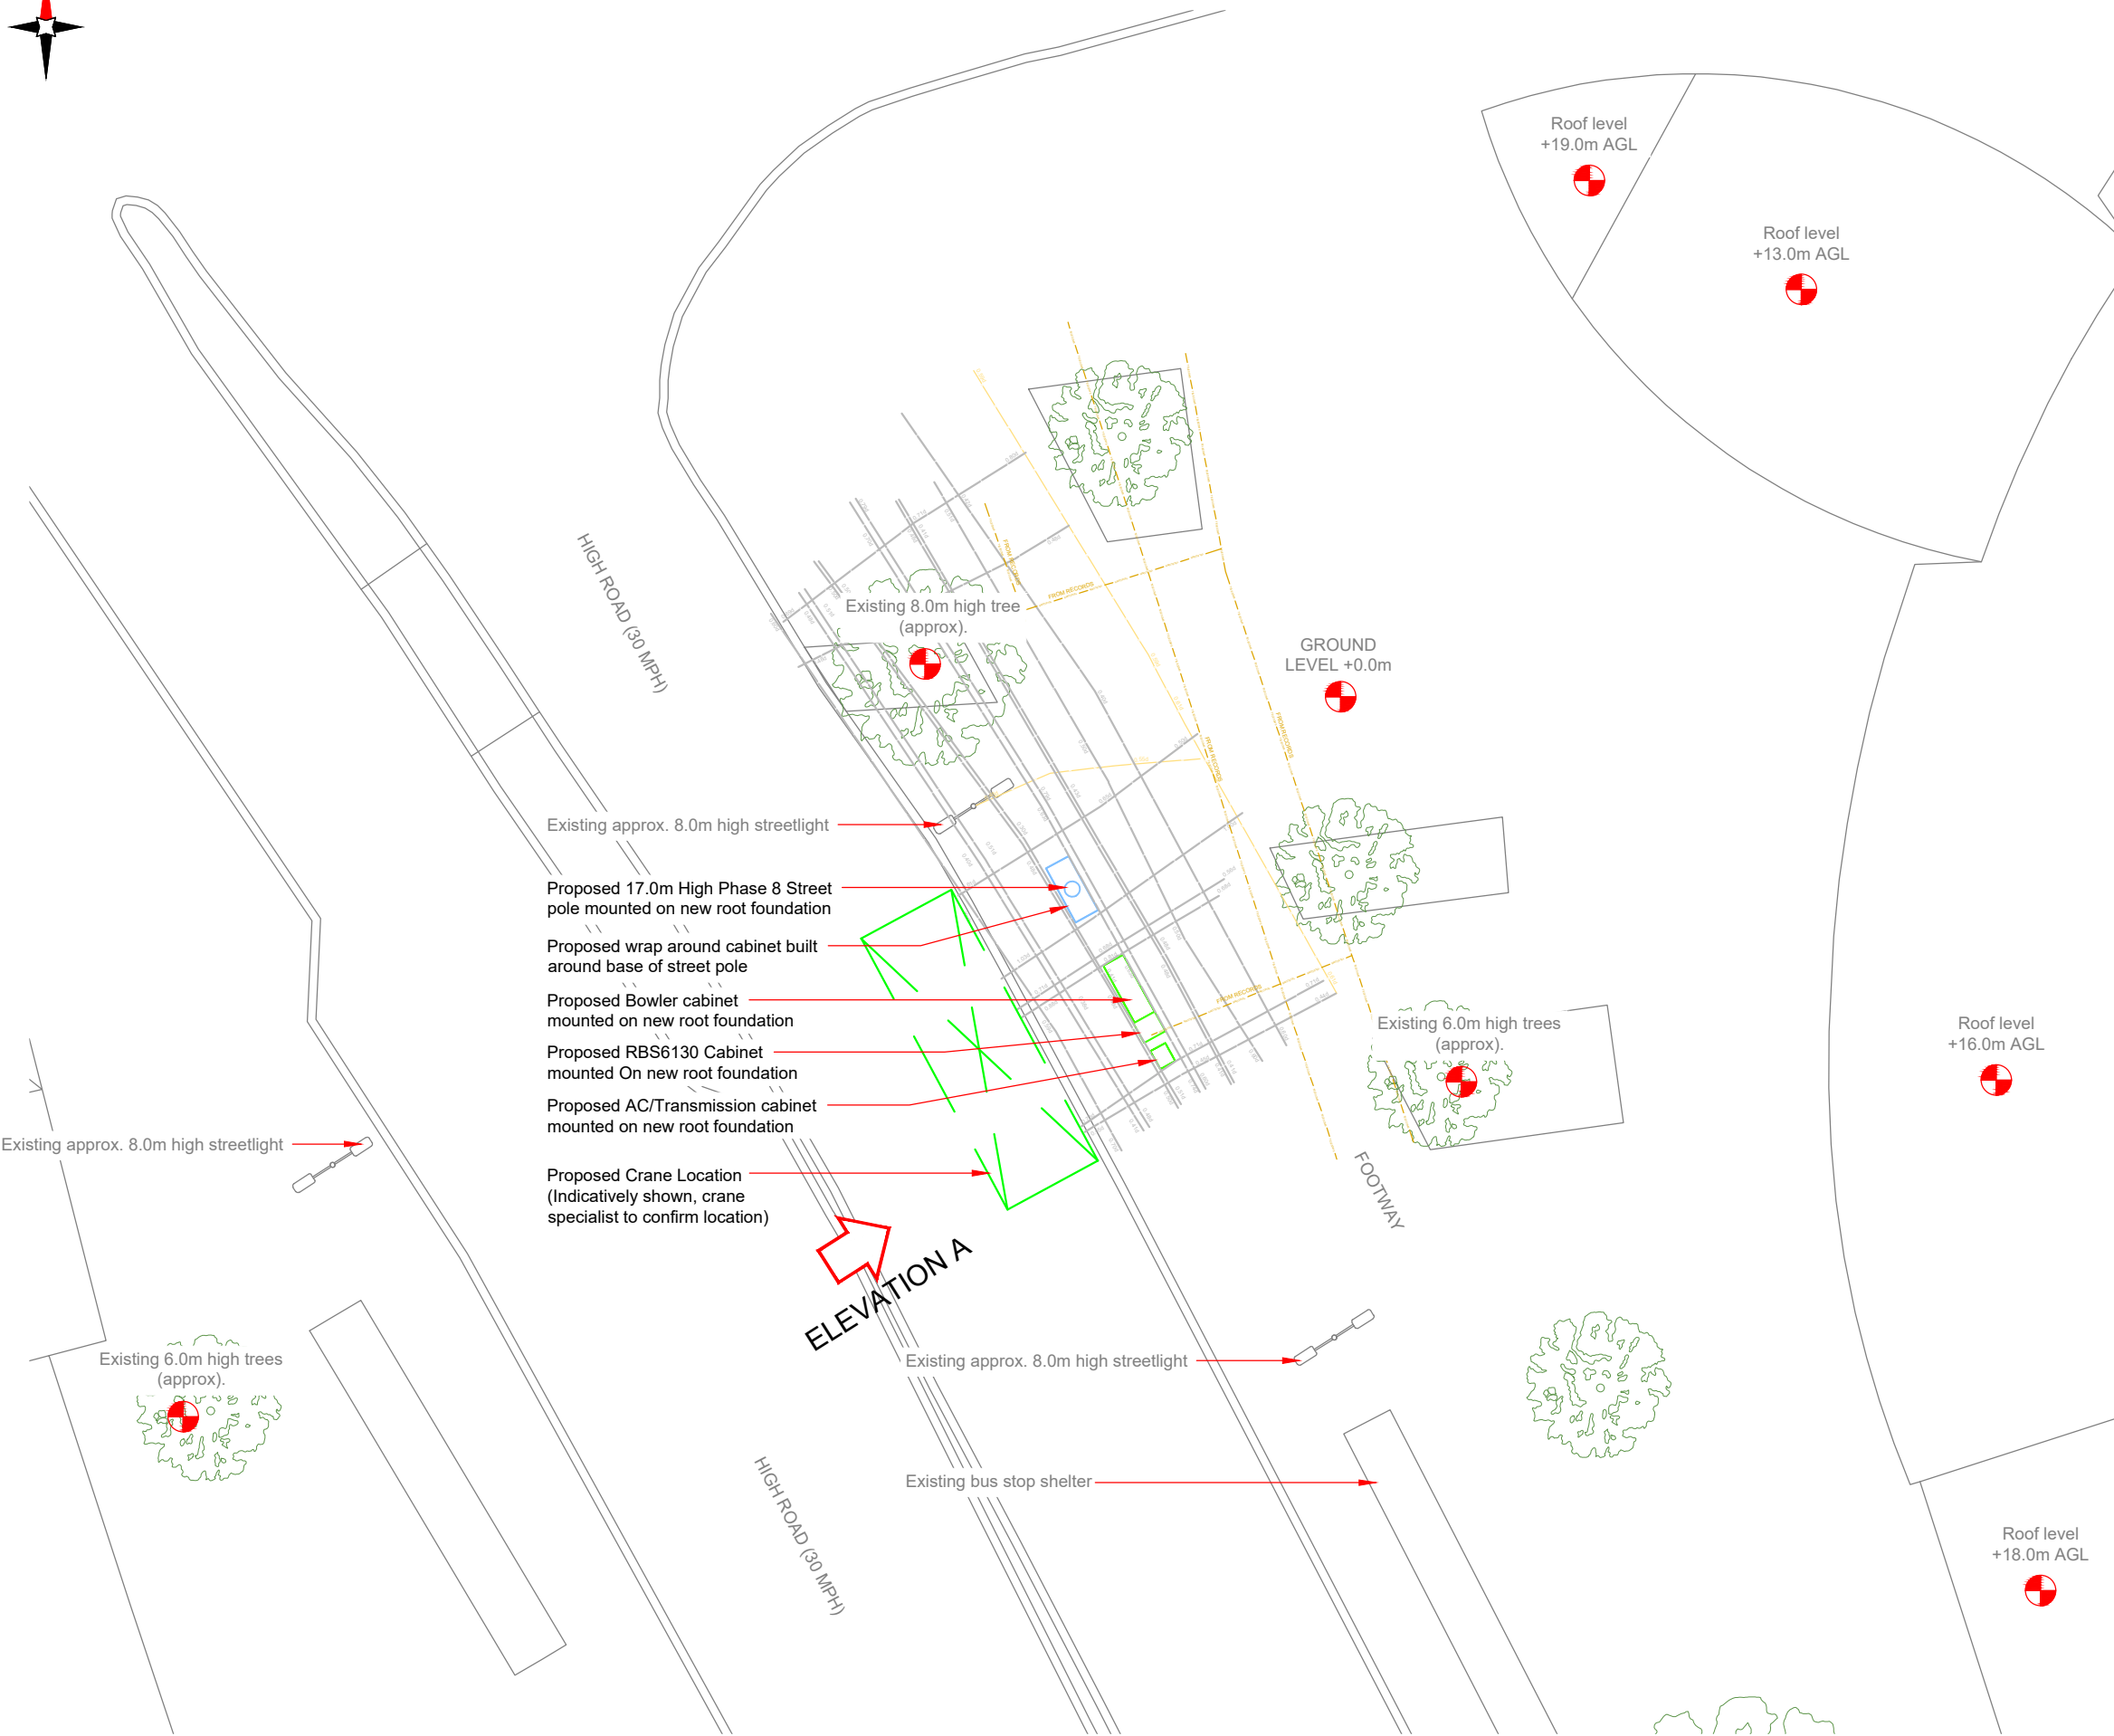


PROPOSED SITE PLAN

 


NOTES:

1. ALL DIMENSIONS IN MM UNLESS OTHERWISE NOTED.

 SERVICES:



CRANE OR CHERRY PICKER LOCATION:

 

NOTES:

Radar Scan and Stats to be reviewed prior to any build works commencing

Master:	MBNL / EE / H3G:	Project:	Purpose of Issue:	Issue:
M001	H3G	H3G DENSIFICATION STREETWORKS	Planning	A
Date:	07/11/2022	Revision / Upgrade Description:		
Drawn:	CDN	First Issue - Site nomination dated: TBC		
Checked:	J. Glover			
Approved:	J. Glover			



Hutchison 3G UK Limited
Green Park, 450 Longwater Avenue
Reading, RG30 3UR
Tel: 01628 765 000
Fax: 01628 765 001

H3G Base Station Information line:
0845 6043000
Available 8am-8pm Monday to Friday

Design Consultant & Principal Contractor:



Unit E, Madison Place, Northampton Road,
Manchester, M40 5AG
Tel: 0161 785 4500 Fax: 0161 785 4501
Web: www.clarke-telecom.com

Site Name:
HIGH ROAD STREETWORKS

Site ID:
HGY23662

Address:
HIGH ROAD
HOLLYWOOD GREEN
HORNSEY PARK
LONDON
ENGLAND
N22 6EJ



Title:
210 PROPOSED SITE PLAN

Project:
H3G DENSIFICATION STREETWORKS

Purpose of Issue:
PLANNING

MBNL Cell ID: HGY188	3UK Cell ID: N1237
-------------------------	-----------------------

Master Drawing No: HGY23662_B35_GA_A	Issue: A
---	-------------

 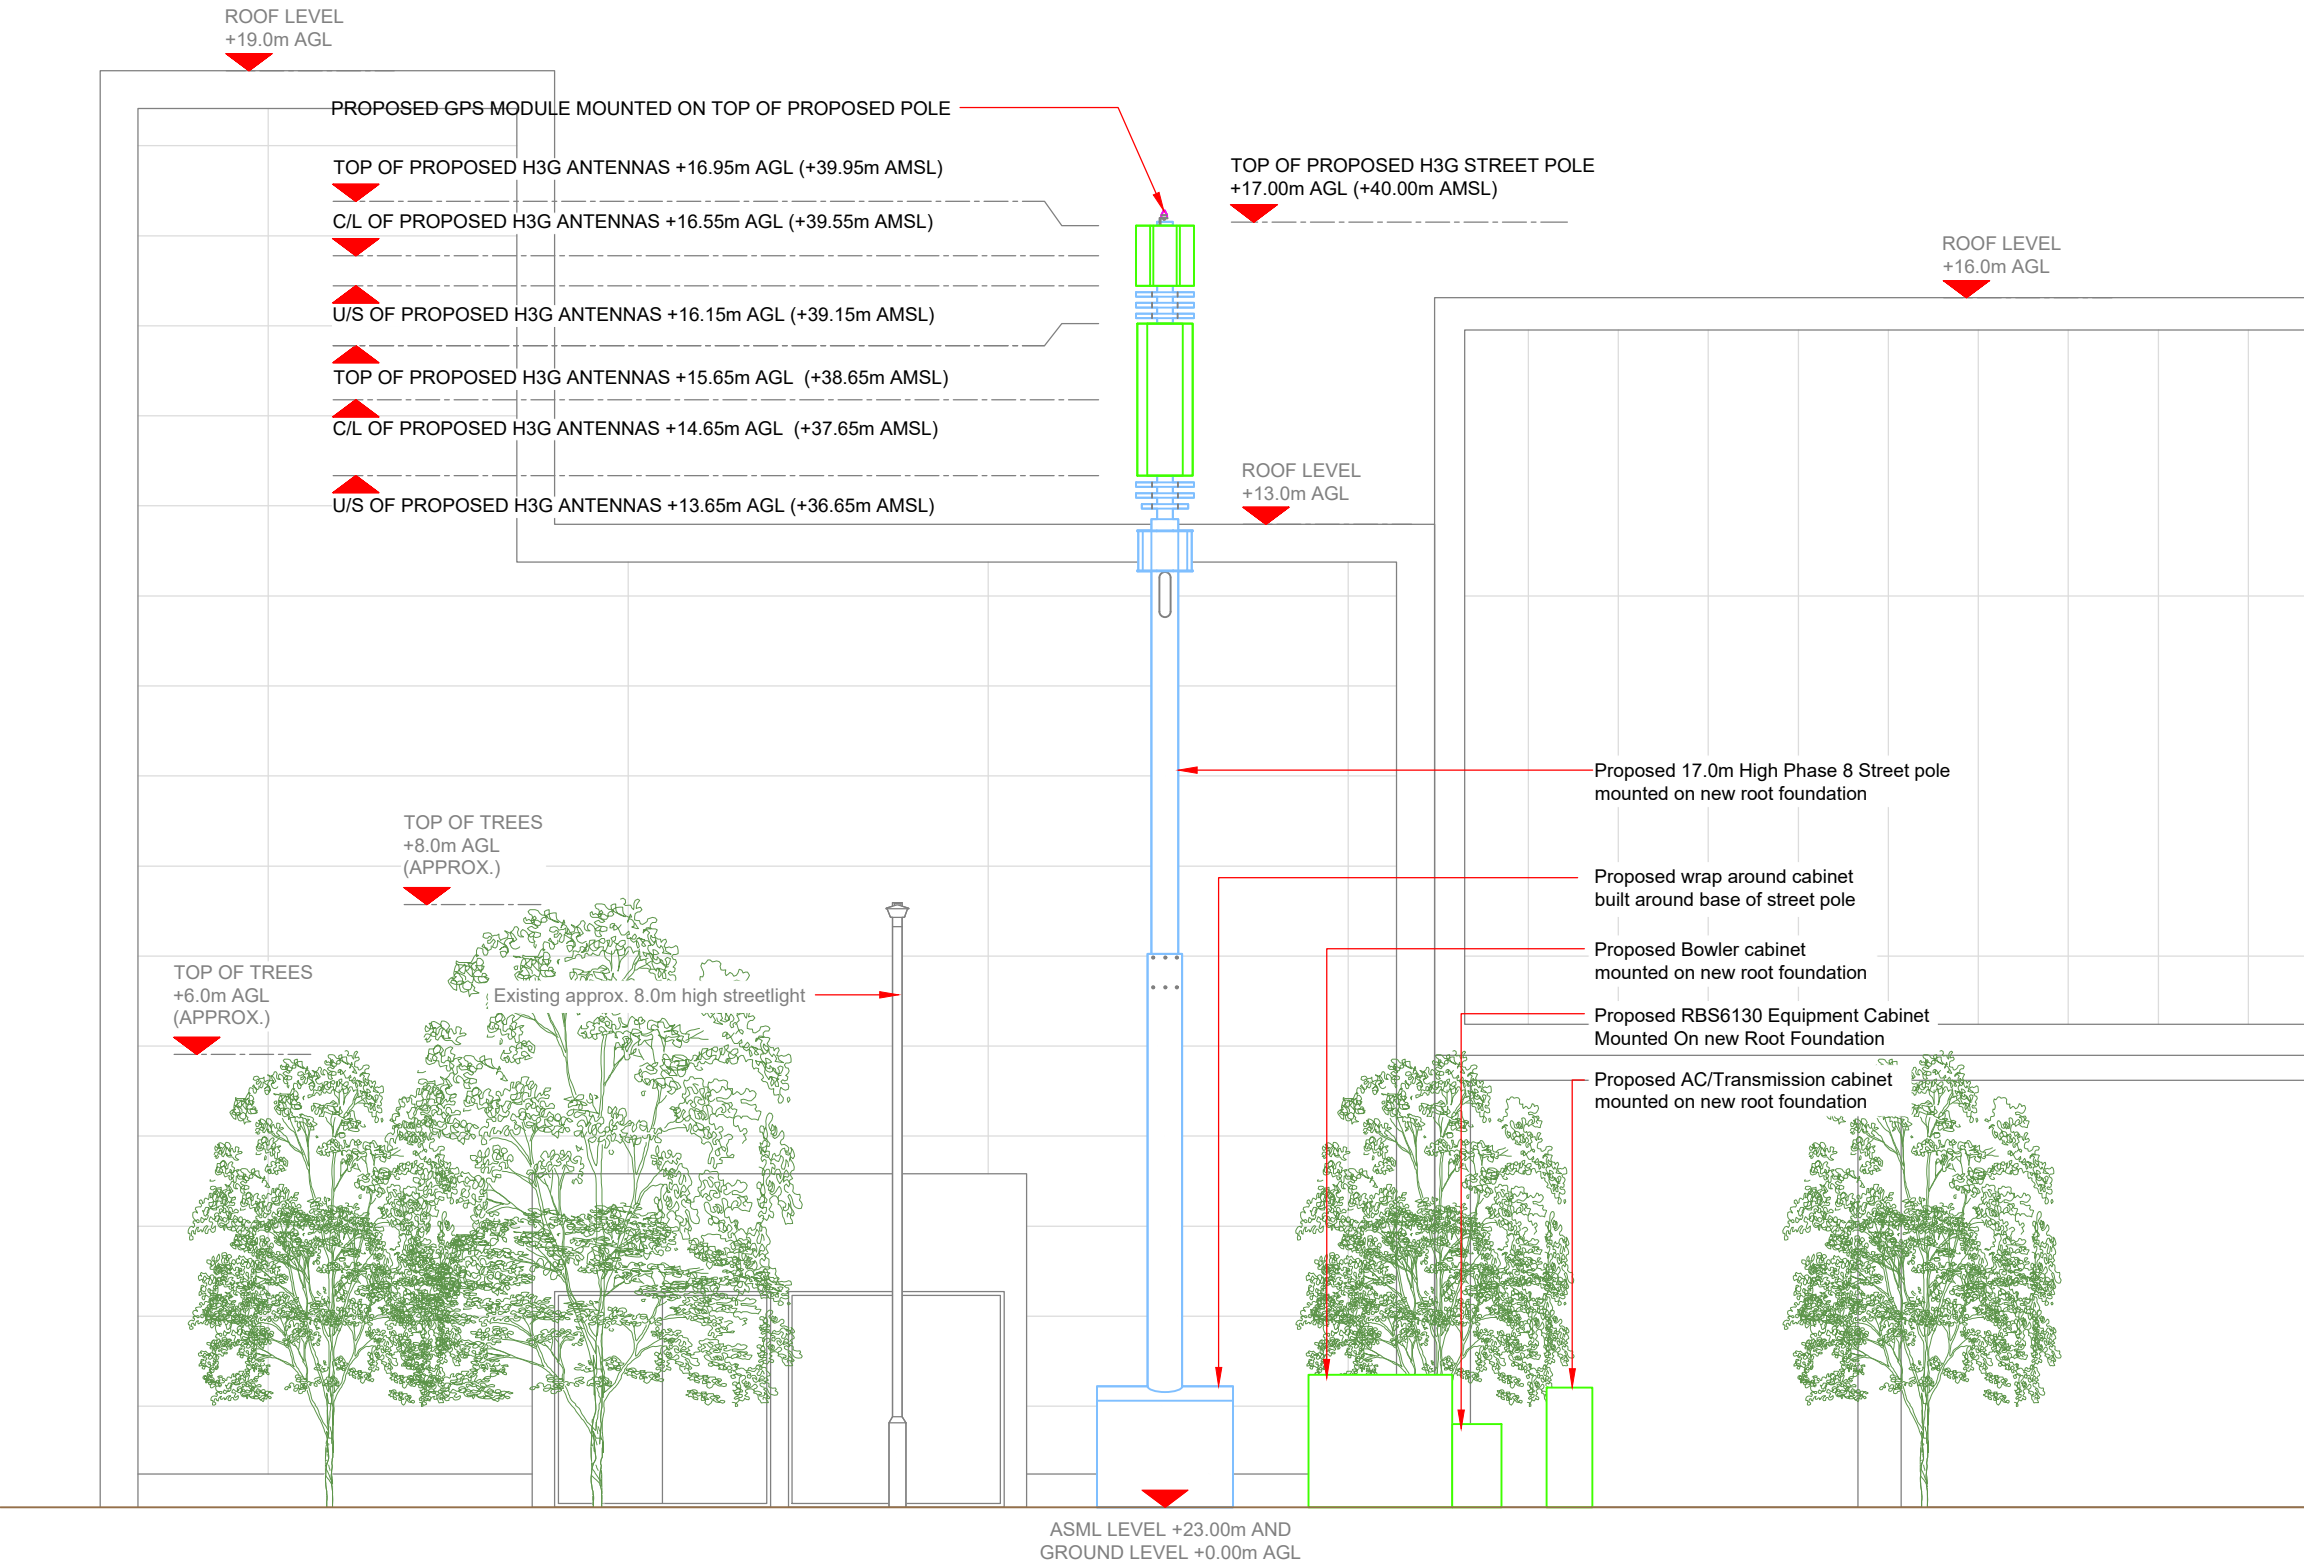

- NOTES:
1. ALL DIMENSIONS IN MM UNLESS OTHERWISE NOTED.

Master:	MBNL / EE / H3G:	Project:	Purpose of Issue:	Issue:
M001	H3G	H3G DENSIFICATION STREETWORKS	Planning	A
Date:	07/11/2022	Revision / Upgrade Description:		
Drawn:	CDN	First Issue - Site nomination dated: TBC		
Checked:	J. Glover			
Approved:	J. Glover			



Hutchison 3G UK Limited
Green Park, 450 Longwater Avenue
Reading, RG30 3UR
Tel: 01628 765 000
Fax: 01628 765 001

H3G Base Station Information line:
0845 6043000
Available 8am-8pm Monday to Friday

Design Consultant & Principal Contractor:

CLARKE telecom

Unit E, Madison Place, Northampton Road,
Manchester, M40 5AG
Tel: 0161 785 4500 Fax: 0161 785 4501
Web: www.clarke-telecom.com

Site Name:	HIGH ROAD STREETWORKS		
Site ID:	HGY23662		
Address:	HIGH ROAD HOLLYWOOD GREEN HORNSEY PARK LONDON ENGLAND N22 6EJ		
Title:	260 PROPOSED ELEVATION		
Project:	H3G DENSIFICATION STREETWORKS		
Purpose of Issue:	PLANNING		
MBNL Cell ID: HGY188		3UK Cell ID: N1237	
Master Drawing No: HGY23662_B35_GA_A			Issue: A