
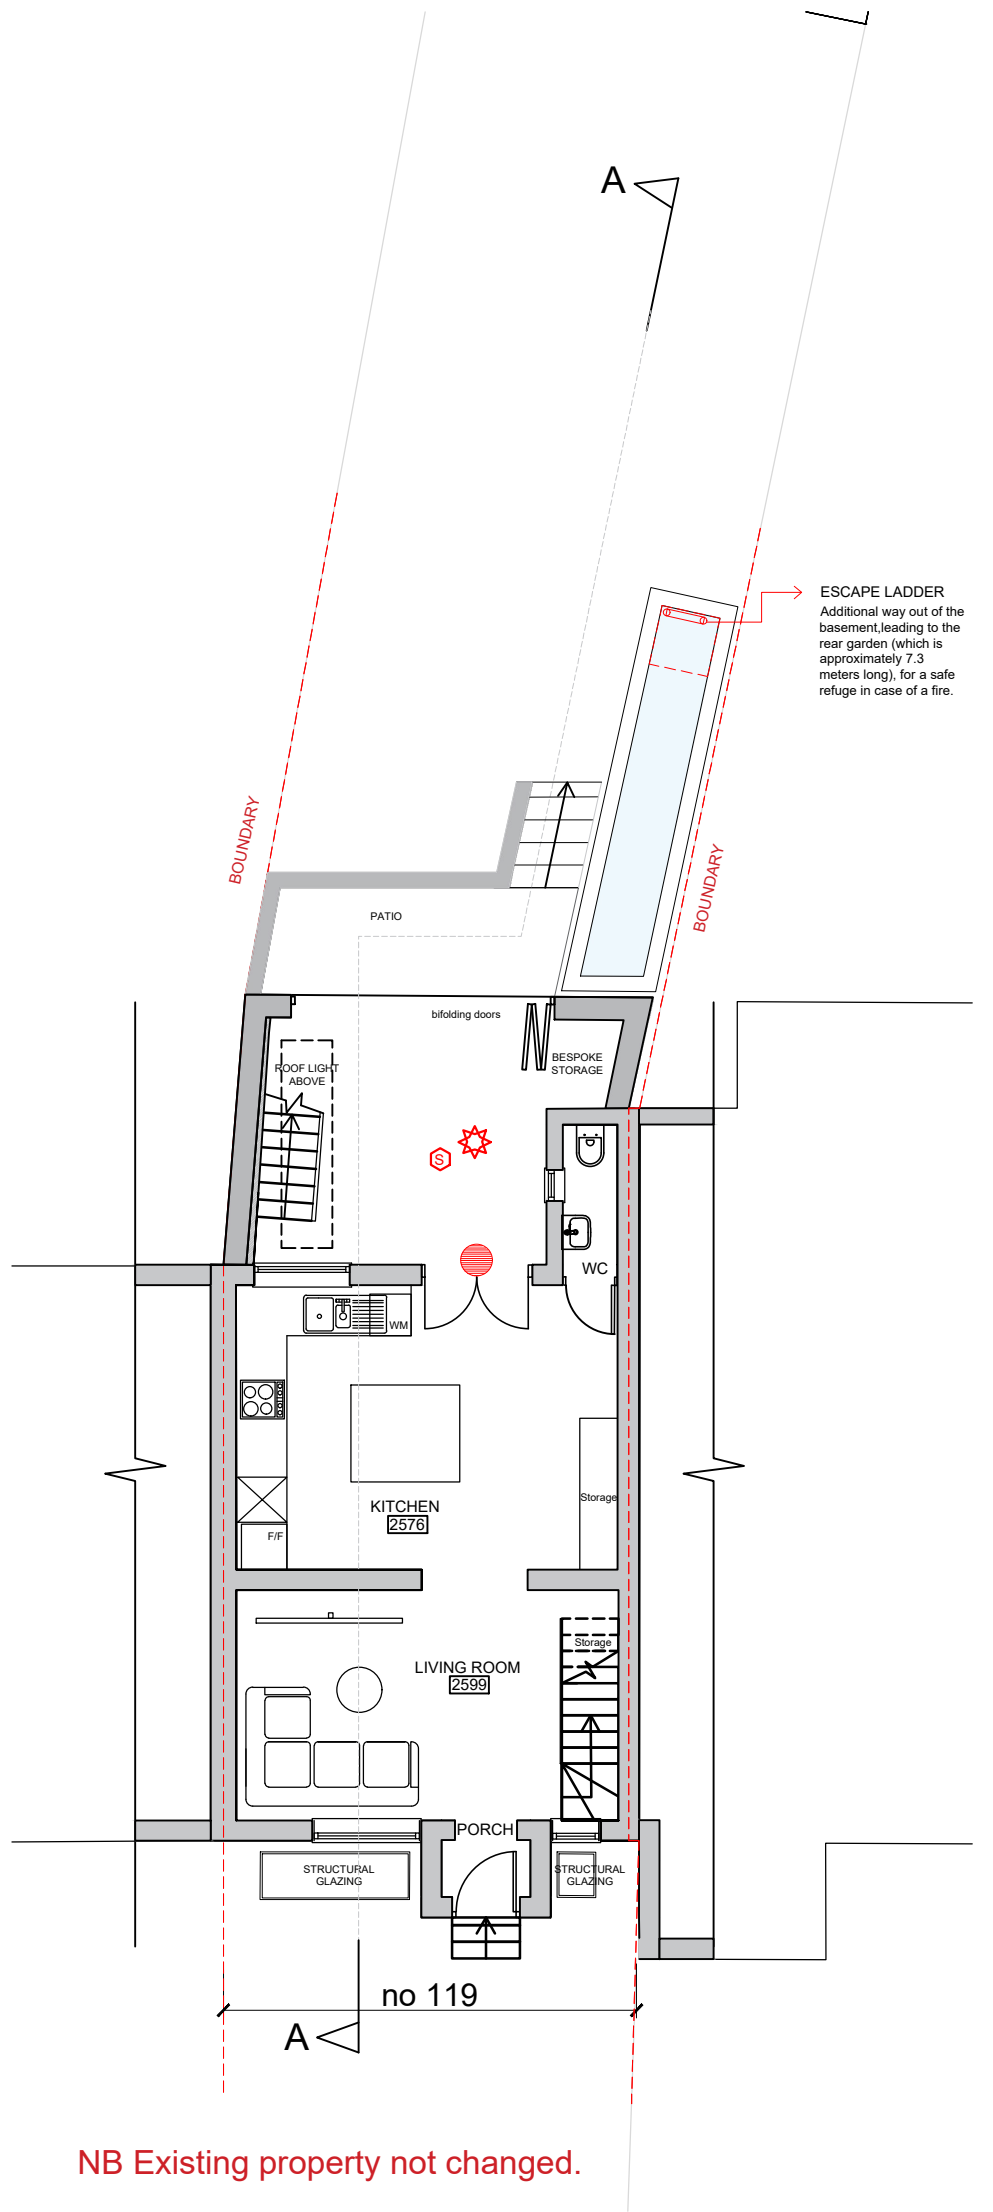


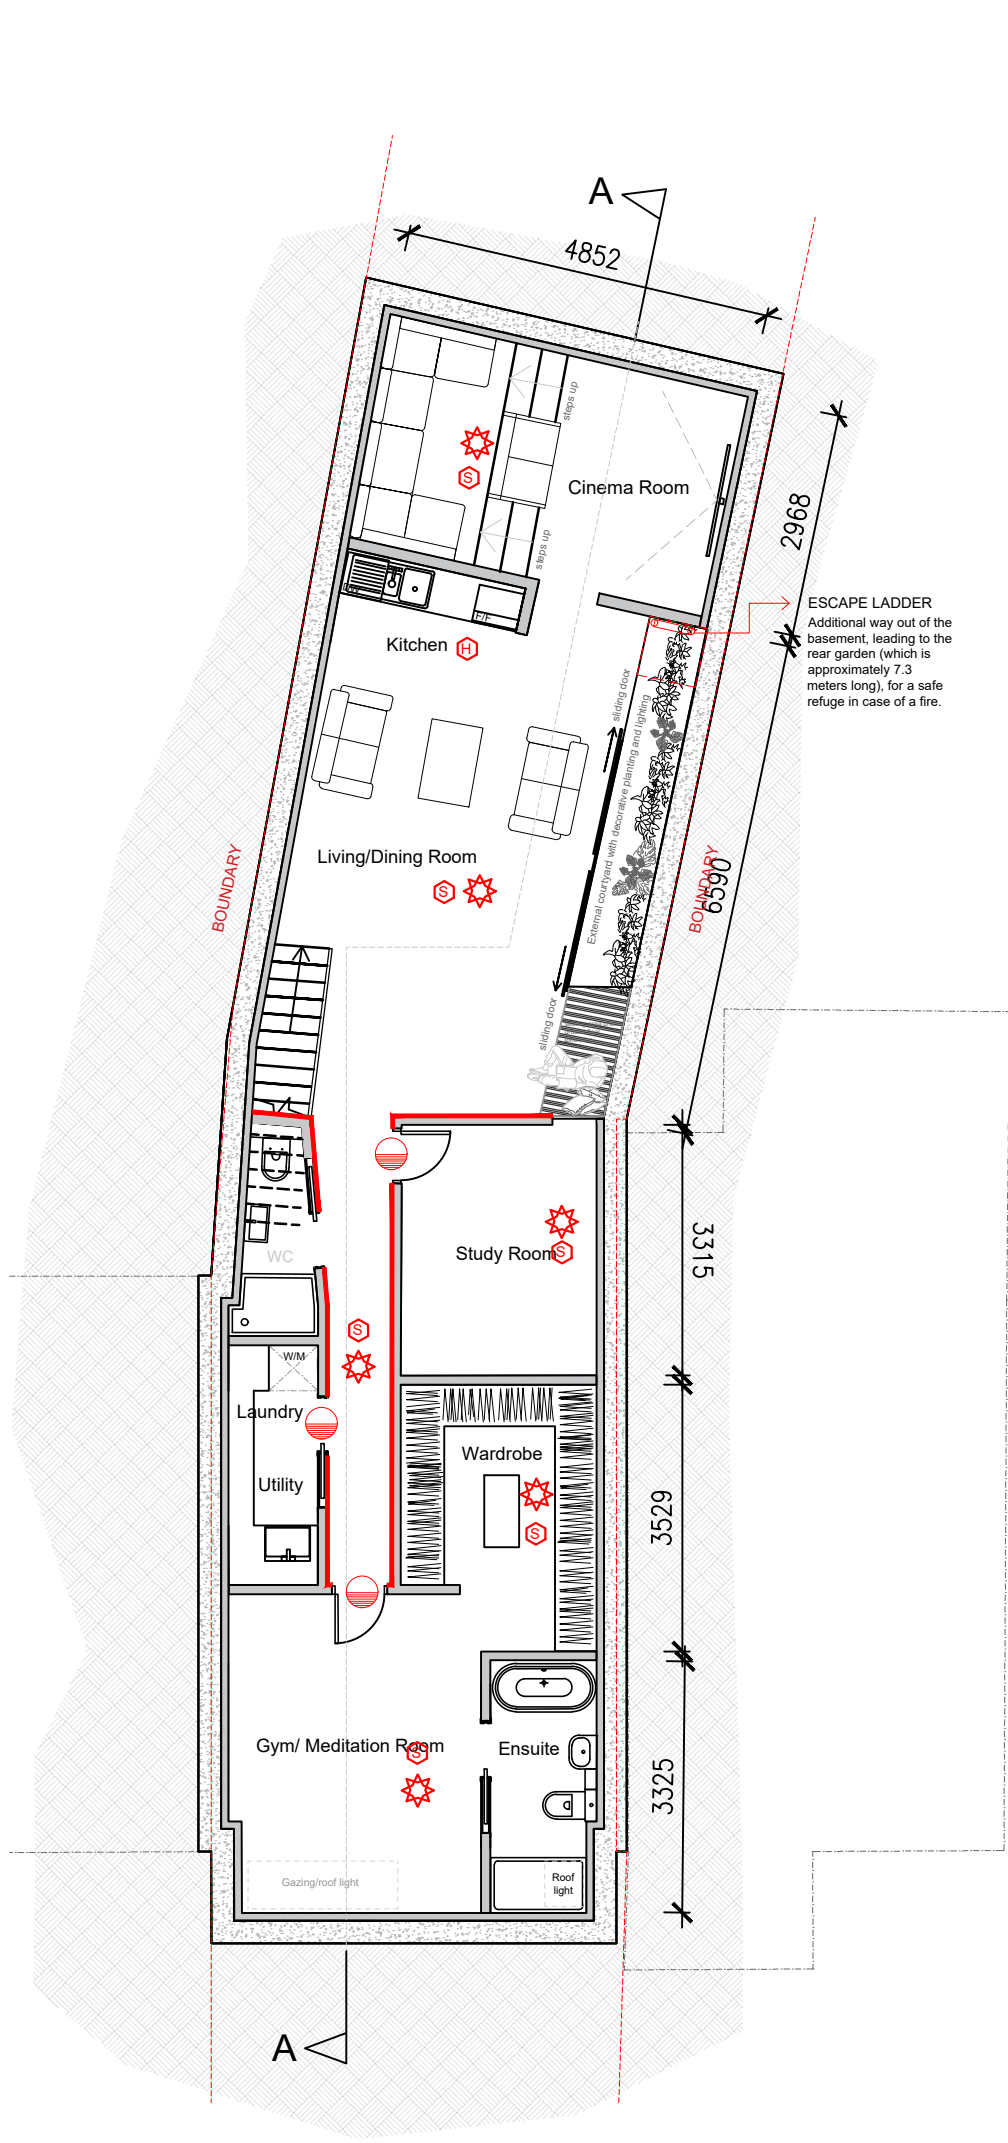

NB Existing property not changed.

01 PROPOSED BASEMENT SCALE: 1:100

02 PROPOSED GROUND FLOOR PLAN SCALE: 1:100

- KEY
- EMERGENCY EGRESS
 - FIRE ALARM BREAK GLASS
 - INTERLINKED THROUGHOUT FLAT ONLY
 - SMOKE DETECTOR WITH SOUNDER, FINAL POSITIONS TO BE COORDINATED WITH LIGHTING DESIGN
 - HEAT DETECTOR WITH SOUNDER, FINAL POSITIONS TO BE COORDINATED WITH LIGHTING DESIGN
 - INTERLINKED THROUGHOUT THE ENTIRE BUILDING
 - SMOKE DETECTOR WITH SOUNDER, FINAL POSITIONS TO BE COORDINATED WITH LIGHTING DESIGN
 - ALL SMOKE DETECTORS INTERLINK WITH AOV
 - 60 MIN FIRE RATED DOOR
 - 30 MIN FIRE RATED DOOR
 - 30 min FIRE COMPARTMENT
 - 60 min FIRE COMPARTMENT

- FIRE EXIT SIGN SEMI RIGID SELF ADHESIVE PVC SIGN GLOW IN THE DARK SIGNS TO COMPLY WITH BS 5499-1:2002
- FIRE EXIT SIGN CEILING MOUNTED ILLUMINATED FIRE ESCAPE SIGN. SIGNS TO COMPLY WITH BS 5499-1:2002
- CEILING LIGHT POSITIONS WITH EMERGENCY BACKUP IN ACCORDANCE WITH BS 5266-1:2005.
- EXTERNAL SECURITY LIGHT POSITIONS WITH EMERGENCY BACKUP IN ACCORDANCE WITH BS 5266-1:2005.
- FIRE BLANKET
- CAVITY BARRIERS AND FIRE-STOPS
- AUTOMATIC SELF-CLOSING
- ESCAPE EXIT
- FIRE CONTROL PANEL
- EMERGENCY LIGHT
- MIST SPRINKLER SYSTEM TO SPECIALIST DESIGN
- SVP + RWP WITH FIRE COLLORS AT ALL LEVELS

REVISION	DATE	COMMENTS	AUTHOR / CHECKED
■ NORTH STUDIO 116A HIGH STREET EDGEWARE HA8 7EL			
■ SOUTH STUDIO MATRIX STUDIOS 91 PETERBOROUGH ROAD LONDON SW8 3BU			
■ design@dsquared.co.uk ■ www.dsquared.co.uk ■ 020 8732 5620			
DS SQUARED architects			
TITLE 119 COPPETTS ROAD			
DETAIL FIRE STRATEGY PLANS			
DATE NOV 2022	SCALE 1:100	PAPER SIZE A3	AUTHOR / CHECKED ID/KL
DRAWING No. 22041S 06.01	REVISION -	STATUS PLANNING	
CONTRACTORS MUST CHECK ALL DIMENSIONS ON SITE. ONLY DIMENSIONS ARE TO BE WORKED FROM. DISCREPANCIES MUST BE REPORTED TO THE ARCHITECT BEFORE PROCEEDING. THIS DRAWING IS NOT TO BE USED FOR CONSTRUCTION.			
SCALE mm	0.5	2.5	5 7.5