


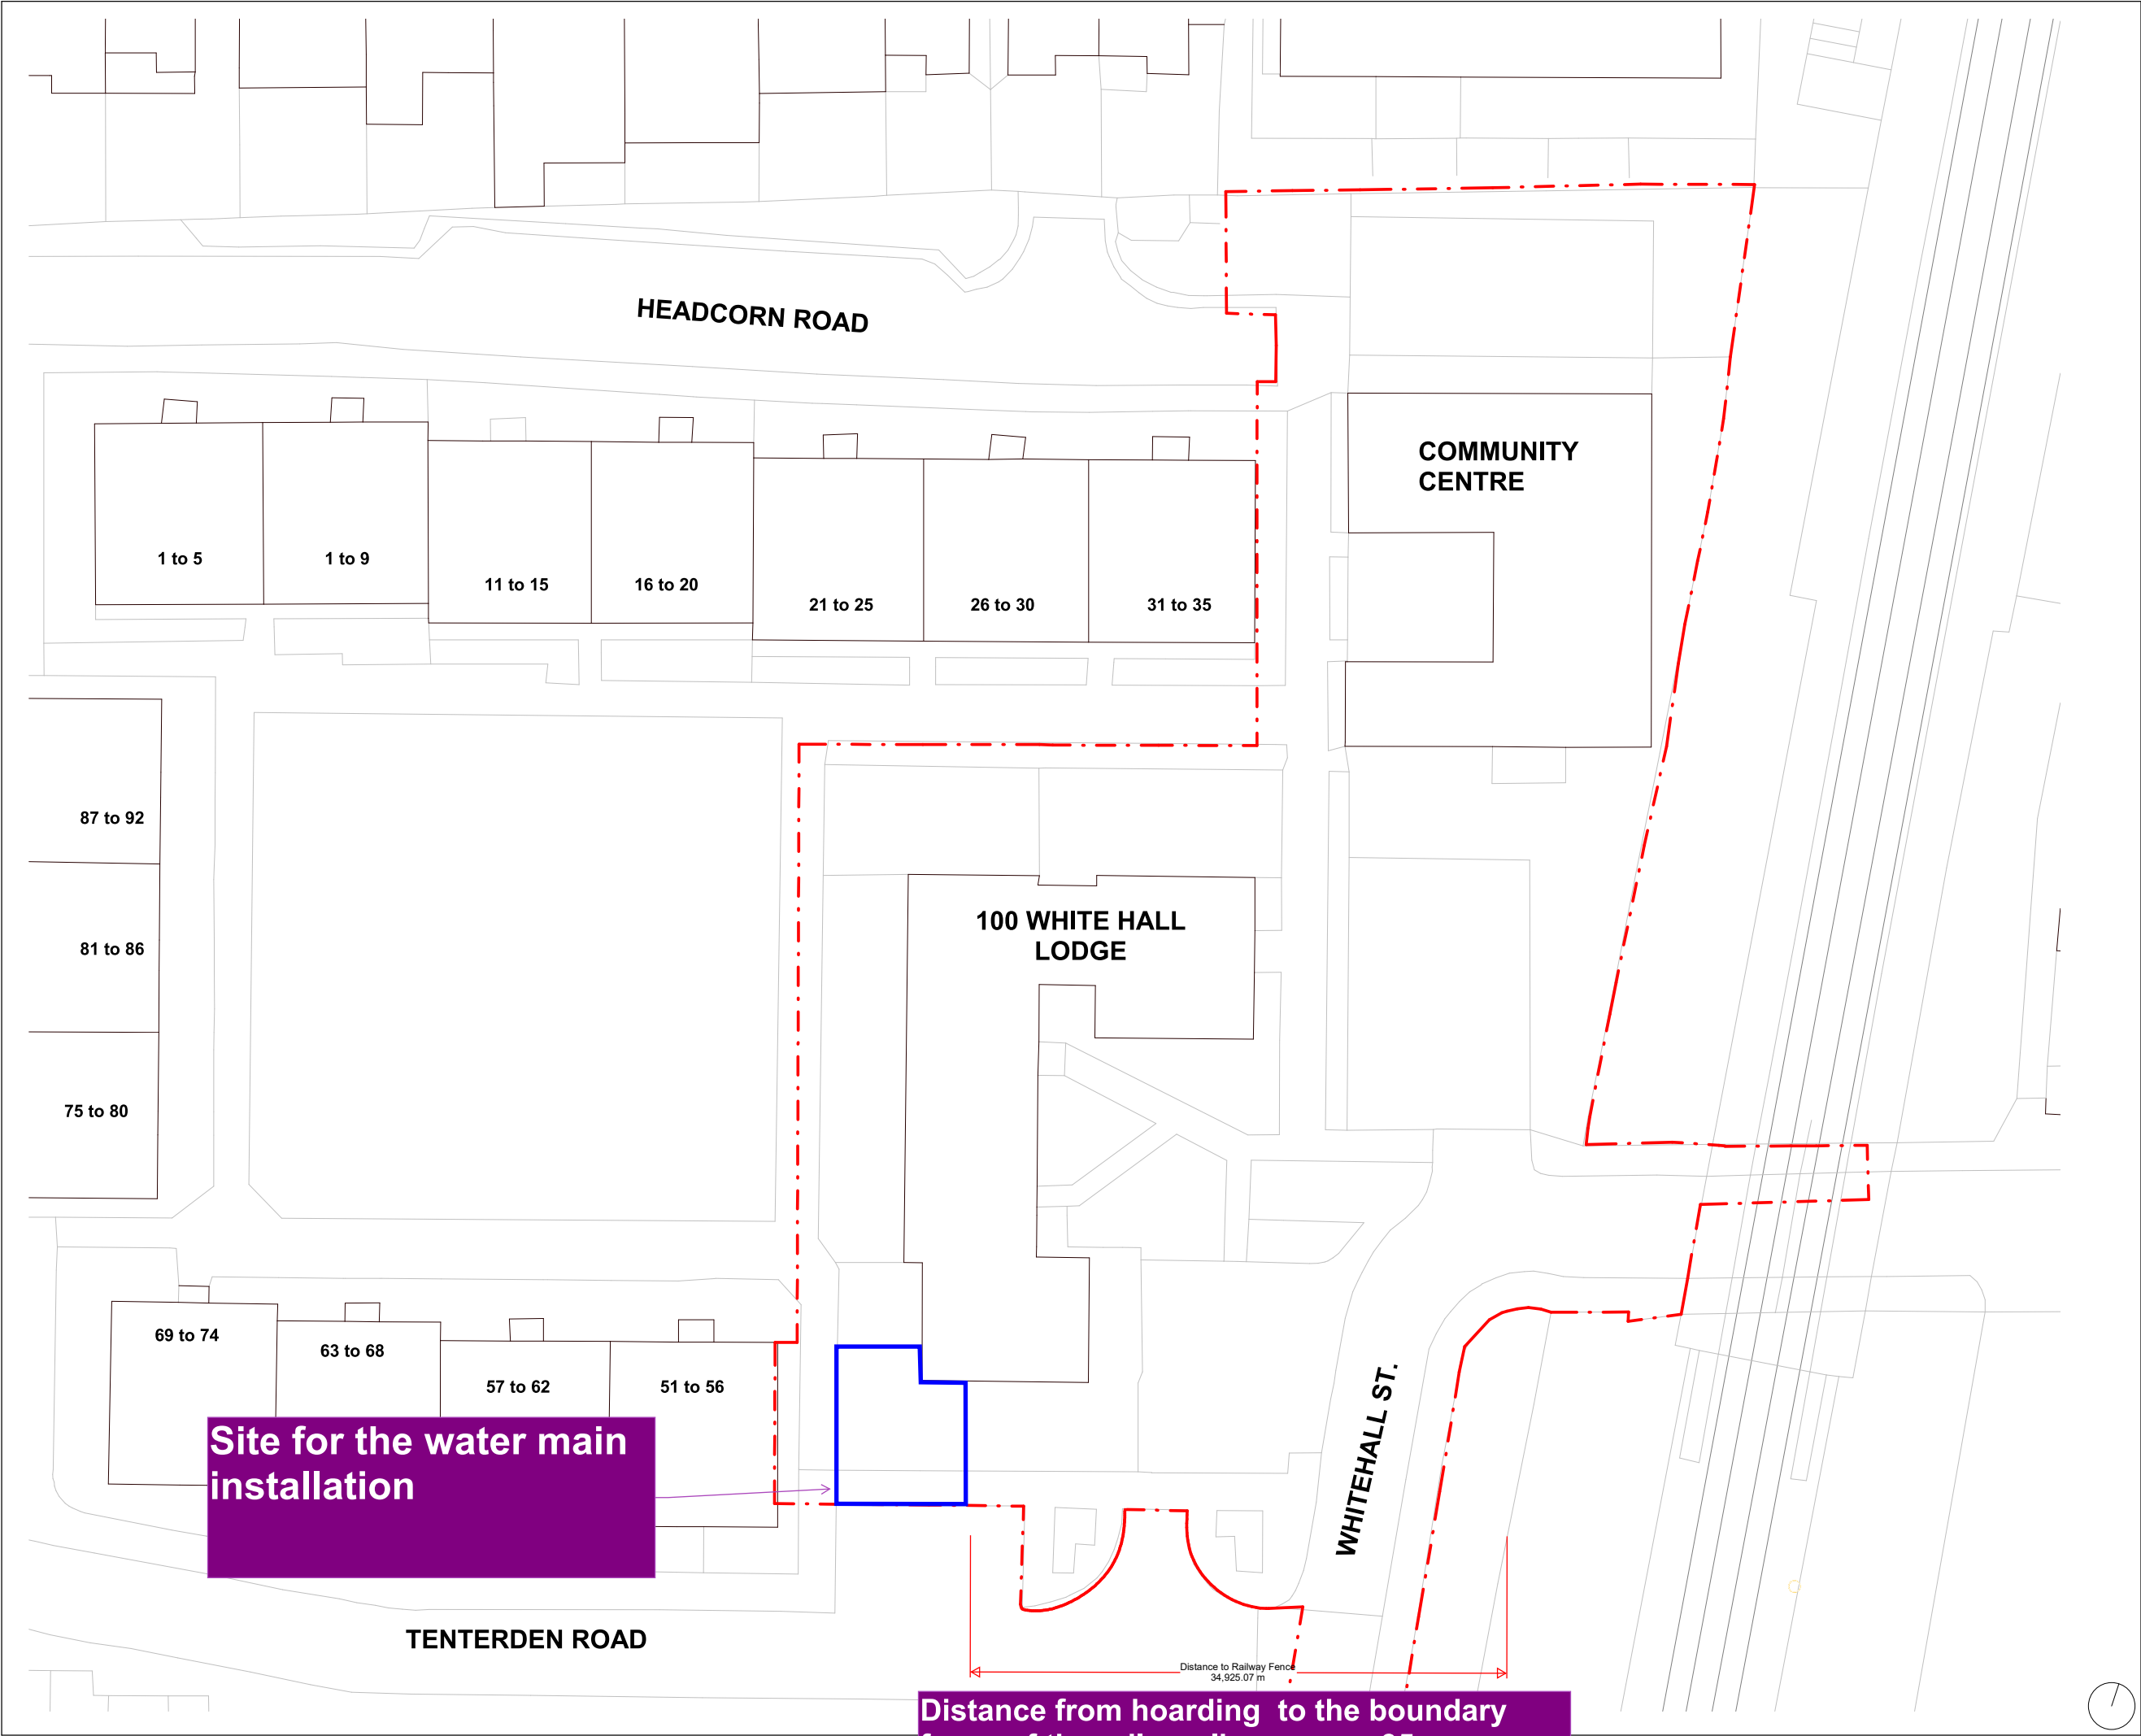

NOTES

Do not scale from this drawing. To be read in conjunction with all relevant Architects', Services and Structural Engineer' information. Architect to be immediately notified of discrepancies.

DISCLAIMER:

THIS DRAWING IS COPYRIGHT OF PTE ARCHITECTS. REPRODUCTION AND ELECTRONIC DISSEMINATION MAY RESULT IN DISTORTION AND RESIZING OF DRAWING CONTENT.

PTE TAKES NO RESPONSIBILITY FOR MEASUREMENTS OR SCALING TAKEN FROM ANY OTHER DRAWING THAN THE ORIGINAL HARDCOPY ISSUED BY PTE AND NO RELIANCE MAY BE PLACED ON SUCH DIMENSIONS.

THIS DRAWING MUST BE READ IN CONJUNCTION WITH ALL OTHER RELEVANT DRAWINGS AND SPECIFICATIONS FROM THE ARCHITECT AND OTHER CONSULTANTS.

INDICATIVE STRUCTURE, TO BE CONFIRMED BY SE

--- Detailed Planning Application Boundary

Metres 0 2 4 1:200 10 m

— Location of Water Main Installation

P4	Planning Submission - Third Draft	11.10.2021	AT
P3	Planning Submission - Second Draft	23.09.2021	AT
P2	Draft Planning Submission	01.09.2021	AT
P1	Draft Planning Deliverables	24.08.2021	AT

REV	DESCRIPTION	DATE	BY
KEY PLAN			

LEAD DESIGNER

Pollard Thomas Edwards
Diespeker Wharf
38 Graham Street
London N1 8JX
T +44 (0)20 7336 7777
forename.surname@ptea.co.uk

PROJECT

HIGH ROAD WEST - PLOT A

Whitehall Mews

DRAWING TITLE

Plot A - Site Plan - Existing

SCALE AT A1 1 : 200	DATE: 11.10.2021	JOB NUMBER: 21-011	
SCALE AT A3 N/A	DRAWN BY: NPW	CHECKED BY: AT	APPROVED BY: AT
DRAWING NUMBER HRWPA-PTE-XX-ZZ-D-A-000002			REV P4
STATUS CODE: S3	STATUS DESCRIPTION: Planning Submission - Third Draft		

