


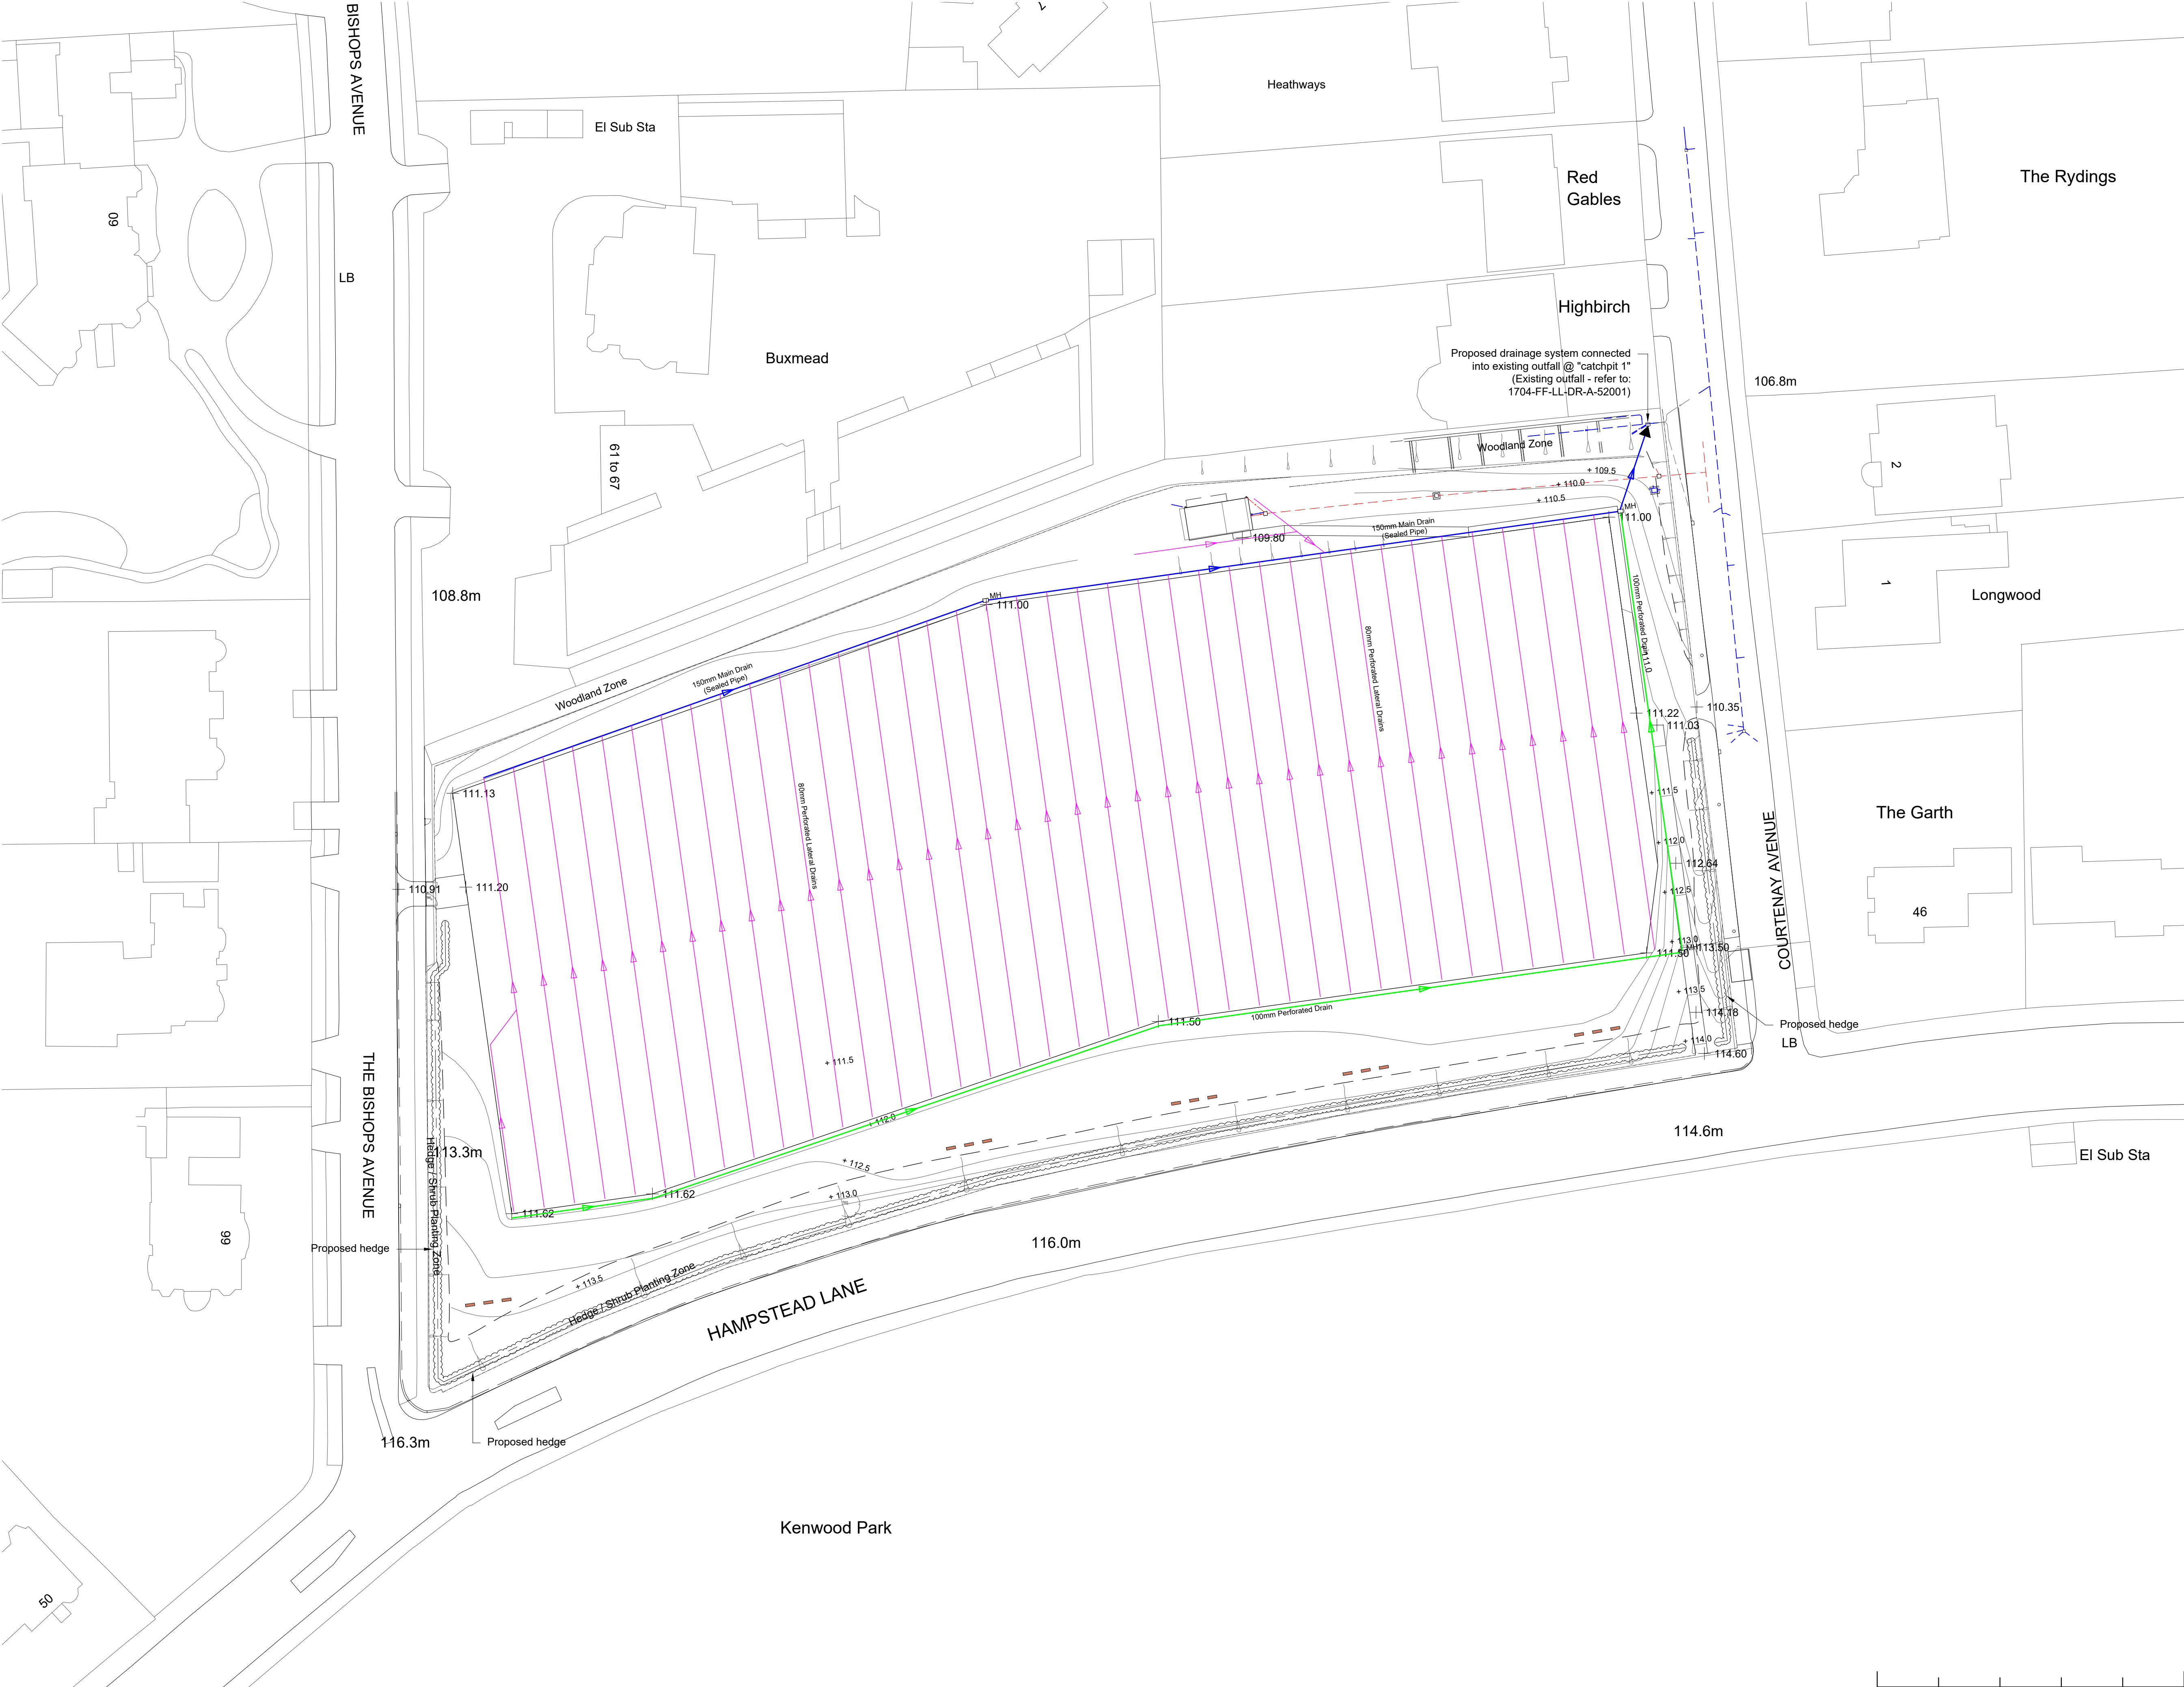

LEGEND: DRAINAGE

80mm Drain

100mm Drain

150mm Drain

MH Manhole

Outfall

PLANNING ISSUE

Client:
Highgate School
Highgate, London

Project:
Far Field: Proposed Pitch Renovation Works
Adjacent Courtenay Avenue, Highgate,
London, N6 4LP

Title:
SITE PLAN
PROPOSED PITCH DRAINAGE SYSTEM

Drawn by:
ODH

Checked by:
DKH

Scale:
1:500

Original size:
A1

Date:
JAN 2023

Revision:
-

Drawing Number:
1704-FF-LL-DR-A-52100

Hemstock Design

Plan: Proposed Pitch Drainage System
Scale - 1:500 @ A1