
 


SITE LOCATION

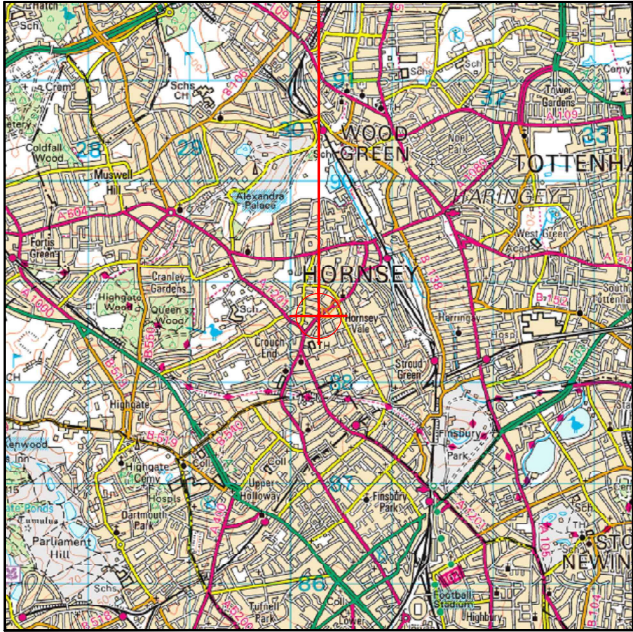


Reproduced by permission of Ordnance Survey on behalf of the Controller of Her Majesty's Stationery Office
All rights reserved, © Crown Copyright licence no. 10022432

SITE AREA PLAN




SITE PHOTOGRAPH

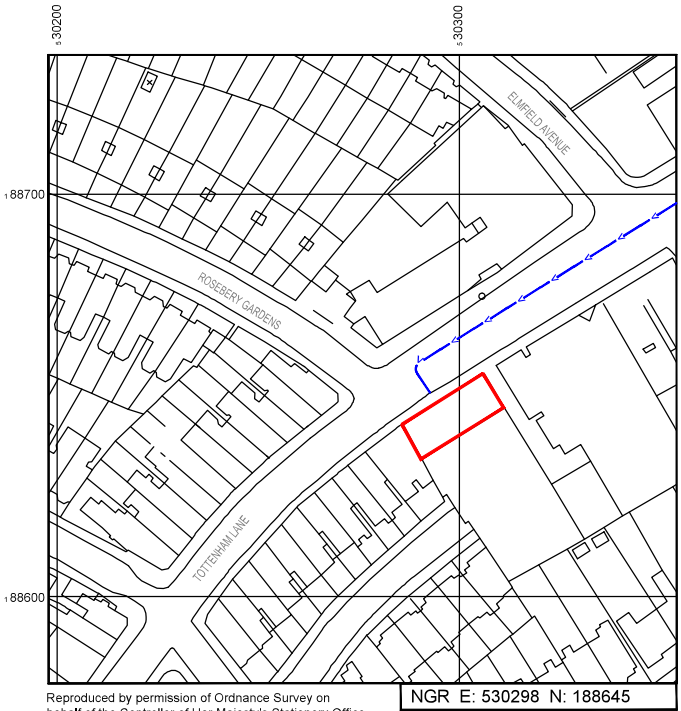

Reproduced by permission of Ordnance Survey on behalf of the Controller of Her Majesty's Stationery Office
All rights reserved, © Crown Copyright licence no. 10022432

 SITE LOCATION PLAN



GOOGLE MAPS QR CODE

GOOGLE MAPS - <https://goo.gl/maps/kWJNFrXxWHEeZTih6>

GOOGLE STREETVIEW - <https://goo.gl/maps/Tqt5jid3NmrmjMR5V9>

NOTES:

1. ALL DIMENSIONS IN MM UNLESS OTHERWISE NOTED.
- DIRECTIONS TO SITE: TAKE M1 TO HENDON LN/A504 IN LONDON. HEAD NORTHWEST ON M1 AFTER 1.9MILES. TAKE THE EXIT TOWARDS M1 AFTER 0.7MILES. USE ANY LANE TO MERGE WITH M1 VIA RAMP TO LONDON AFTER 2.4MILES. AT JUNCTION 2, EXIT ONTO BARNET BY-PASS/GREAT NWY/A1 TOWARD C.LONDON AFTER 1.6MILES. CONTINUE ON HENDON LN/A504, TAKE ALLANDALE AVE TO N CIRCULAR RD/A406. TURN LEFT ONTO HENDON LN/A504 AFTER 0.3MILES. TURN RIGHT ONTO ALLANDALE AVE AFTER 0.4MILES. TURN RIGHT ONTO REGENTS PARK ROAD/A598 AFTER 0.1MILES. KEEP LEFT TO STAY ON REGENTS PARK ROAD/A598 AFTER 36FEET. SITE WILL BE ON RIGHT SIDE
- Site Provider's Property Boundary:
- Access Route To Site:
- Access Route:

Master	MSNL EE / H3G	Project	3UK UNILATERAL	Purpose of Issue	Planning	Issue	A
M001	H3G	Revision / Upgrade Description:					
Date	06/07/2022	First Issue					
Drawn	COM Group						
Checked	Ben Ormshaw						
Reviewed	Dan Cross						
 Hutchison 3G UK Limited 450 Longwater Avenue, Green Park Reading, RG2 6GF Tel: 01628 765 000 Fax: 01628 765 001 H3G Base Station Information Line: 0845 6043000 Available 8am-8pm Monday to Friday							
Design Consultant & Principal Contractor:							
 WHP Telecoms Ltd Unit 1 Maple Park Levenside Road, Leeds LS12 6HH Tel: 0113 3023550 Fax: 0113 2676834 e-mail: info@whptelecoms.com							
Site Name:							
ROSEBERY HOUSE							
Site ID:							
1106086							
Address:							
165 ROSEBERY HOUSE TOTTENHAM LANE A103 CROUCH END, HORNSEY HARINGEY LONDON N8 9BY							
Title:							
002 SITE LOCATION PLAN							
Project:							
3UK UNILATERAL							
Purpose of Issue:							
GENERAL ARRANGEMENT							
EE Cell ID		MSNL Cell ID		3UK Cell ID			
24456		HGY026		N0018			
Master Drawing No							
1106086_HGY026_24456_N0018_M001							
Issue:							
A							



GROUND LEVEL
+0,00m

TOTTENHAM LANE
(30mph)

EXISTING ELEVATION

EXISTING 3No. EE/H3G HUAWEI
AQU4518R11 ANTENNA MOUNTED ON MAFI
4118 TRI SECTOR MOUNTS C/W 3No. EE
ATA802000 MHA (800) 3No. EE/H3G RD0488
MHA (18/21) & 6No. EE RD0433 MHA (18/26)
ON EXISTING MAIN POLE

EXISTING CTIL METER CABINET INSTALLED
ON CONCRETE BASE

EXISTING 4No. CTIL ANTENNA MOUNTED
ON EXISTING SUPPORT POLES FIXED TO
STEEL TRIPOD

EXISTING EE/H3G CRABTREE METER
CABINET INSTALLED ON CONCRETE BASE
C/W THREE PHASE 100A DNO SUPPLY

EXISTING AC VENTS AND DUCTING

EXISTING H3G HUAWEI APM5930 CABINET
INSTALLED ON STEEL FRAME C/W 3No. H3G
5501 RRU (1800/2100) & 2No. RECTIFIER

EXISTING EE 3No. BOB, 6No. 5507 RRU,
3No. 3262 RRUs & 6No. 18/21 DIPLEXOR
MOUNTED ON 3No. SUPPORT POLES
INSTALLED ON EXISTING
FREESTANDING FRAME

EXISTING EE 3No. COMMSCOPE
BOB MOUNTED ON PARAPET WALL

EXISTING EE/H3G 300mm WIDE
COVERED CABLE TRAY TO SUPPORT
EXISTING FIBRES & FEEDERS

EXISTING EE/H3G HUTCHISON WALL
MOUNTED AC DISTRIBUTION BOARD

APPROX ROOF LEVEL
+12,6m AGL

EXISTING EE BTS3900A CABINET ON
EXISTING STEELFRAME C/W 3No. EE 800
RF MODULE, BBU (1800), BBU3900 (2600)
& 3No. RECTIFIER

EXISTING EE/H3G SIEMENS NEC NB-441
CABINET INSTALLED ON EXISTING STEEL
FRAME C/W U21 FLEXI MODULE, 3No. MK2
UCU & 3No. 2100 SBC

EXISTING CTIL ELECTRICAL DISTRIBUTION
ENCLOSURE MOUNTED ON FREE STANDING FRAME

EXISTING EE/H3G 600mm WIDE COVERED
CABLE TRAY TO SUPPORT EXISTING
FIBRES & FEEDERS

MAIN ROOF LEVEL
+11,4m AGL

APPROX ROOF LEVEL
+10,0m AGL

EXISTING SPARE
CONCRETE PLINTHS

EXISTING 4No. CTIL ANTENNA
MOUNTED ON EXISTING SUPPORT
POLES FIXED TO STEEL TRIPOD

EXISTING 1100m HIGH FREE
STANDING HANDRAIL

EXISTING SPARE POLE MOUNTED
ON FREE STANDING CONCRETE
BLOCKS

EXISTING 1250x520 ROOF ACCESS
HATCH

EXISTING SATELLITE DISH ON FREE
STANDING FRAME

EXISTING RF AERIAL MOUNTED
TO PLANT ROOM WALL

EXISTING CTIL 300mm WIDE
CABLE TRAY LAID FLAT ON ROOF

EXISTING CTIL EQUIPMENT
CABINETS ON STEEL FRAME
MOUNTED ON CONCRETE
PLINTHS

EXISTING SITE PLAN

0 1:100 2m 4

NOTES:

- ALL DIMENSIONS IN MM UNLESS OTHERWISE NOTED.


Master: M001 / EE / H3G		Project:	Purpose of Issue:	Issue:
M001	H3G	3UK UNILATERAL	Planning	A
Date:	05/07/2022	Revision / Upgrade Description:		
Drawn:	COM Group	First Issue		
Checked:	Ben Ormshaw			
Approved:	Dan Cross			



Hutchison 3G UK Limited
450 Longwater Avenue, Green Park
Reading, RG2 6SF
Tel: 01635 765 000
Fax: 01628 765 001

H3G Base Station Information line:
0845 6043000
Available 8am-8pm Monday to Friday

Design Consultant & Principal Contractor:

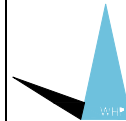

WHP Telecoms Ltd
Unit 1 Maple Park
Leinfilds Road, Leeds
LS12 6HH
Tel: 0113 3023550 Fax: 0113 2676634
e-mail: info@whptelecoms.com

Site Name: **ROSEBERY HOUSE**

Site ID: **1106086**


Address: **165 ROSEBERY HOUSE
TOTTENHAM LANE A103
CROUCH END, HORNSEY
HARINGEY
LONDON
N8 9BY**

Title: **100 EXISTING SITE PLAN**

Project: **3UK UNILATERAL**

Purpose of Issue: **GENERAL ARRANGEMENT**

EE Call ID	MSNL Call ID	3UK Call ID
24456	HGY026	N0018
Master Drawing No: 1106086_HGY026_24456_N0018_M001		
Issue: A		

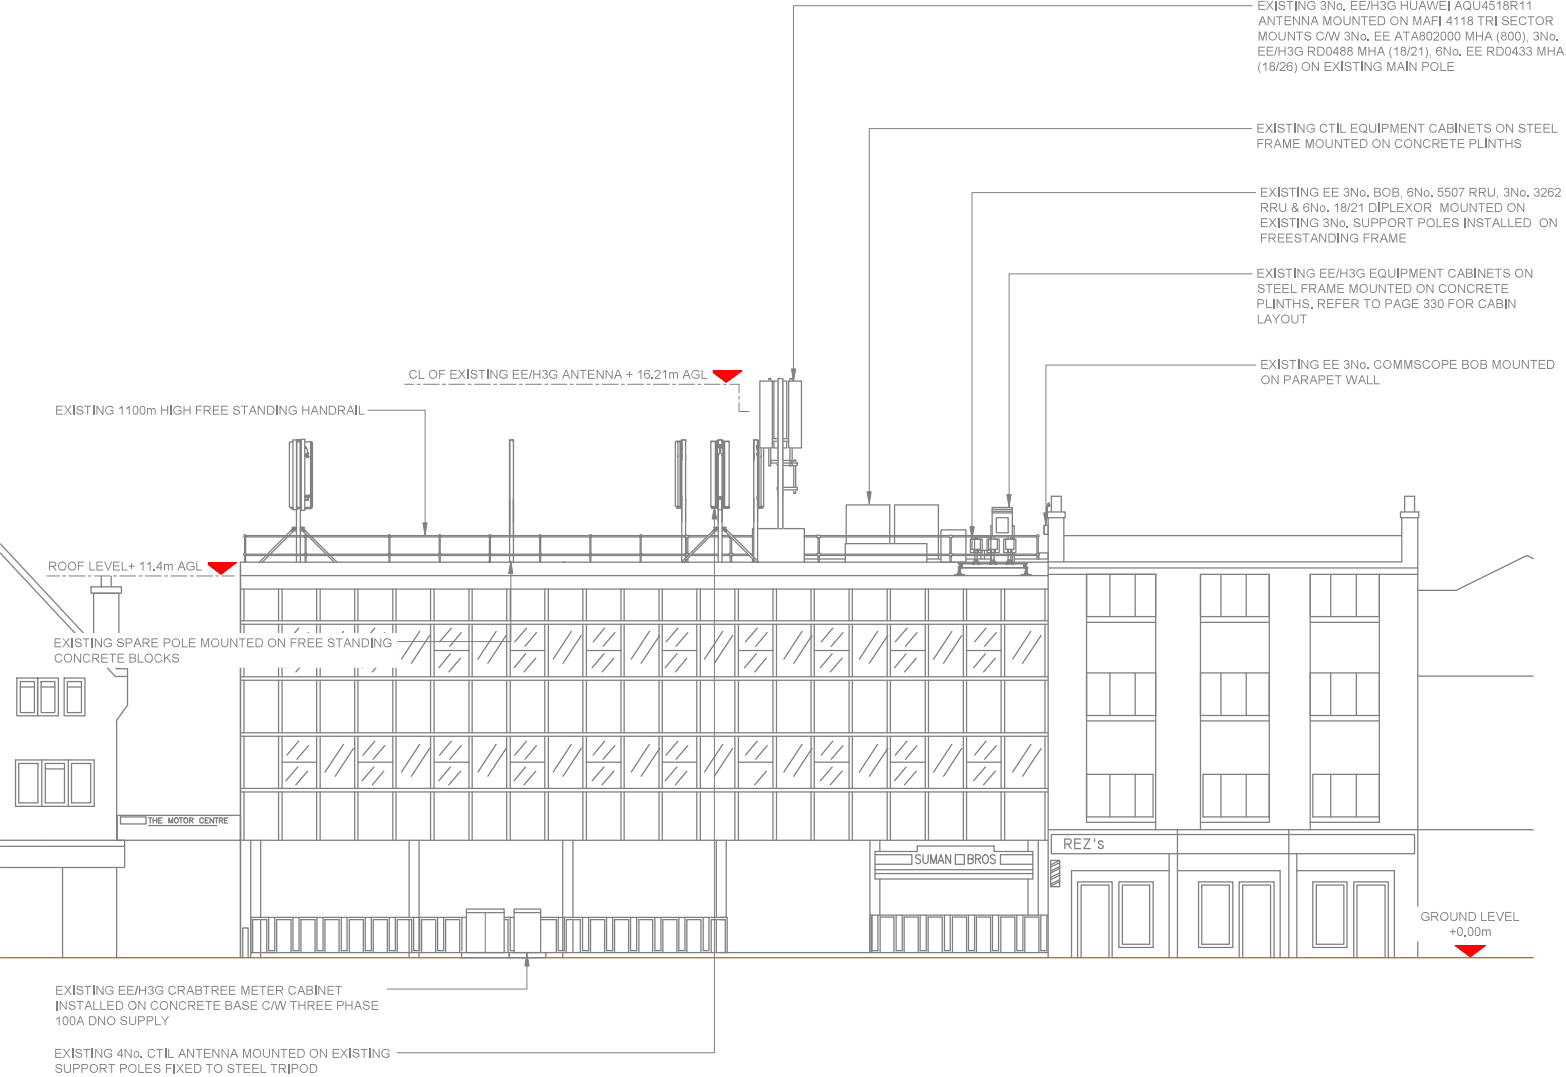

EXISTING SITE ELEVATION

0 1:150 2.5m 5m 6

- NOTES:
1. ALL DIMENSIONS IN MM UNLESS OTHERWISE NOTED.

Master	MSNL Cell ID	MSNL Cell ID	Project	Purpose of Issue	Issue
M001	H3G	3UK UNILATERAL	Planning	A	
Date	05/07/2022	Revision / Upgrade Description:			
Drawn	COM Group	First Issue			
Checked	Ben Ormshaw				
Approved	Ben Ormshaw				




Hutchison 3G UK Limited
450 Longwater Avenue, Green Park
Reading, RG2 6SF
Tel: 01635 785 000
Fax: 01628 765 001

H3G Base Station Information line:
0845 6043000
Available 8am-8pm Monday to Friday

Design Consultant & Principal Contractor:

 **WHP Telecoms Ltd**
Unit 1 Maple Park
Levens Road, Leeds
LS12 6HH
Tel: 0113 3023550 Fax: 0113 2676634
e-mail: info@whptelecoms.com

Site Name:	ROSEBERY HOUSE				
Site ID:	1106086				
Address:	165 ROSEBERY HOUSE TOTTENHAM LANE A103 CROUCH END, HORNSEY HARINGEY LONDON N8 9BY				
Title:	150 EXISTING SITE ELEVATION				
Project:	3UK UNILATERAL				
Purpose of Issue:	GENERAL ARRANGEMENT				
EE Cell ID:	24456	MSNL Cell ID:	HGY026	3UK Cell ID:	N0018
Master Drawing No. 1106086_HGY026_24456_N0018_M001					Issue: A

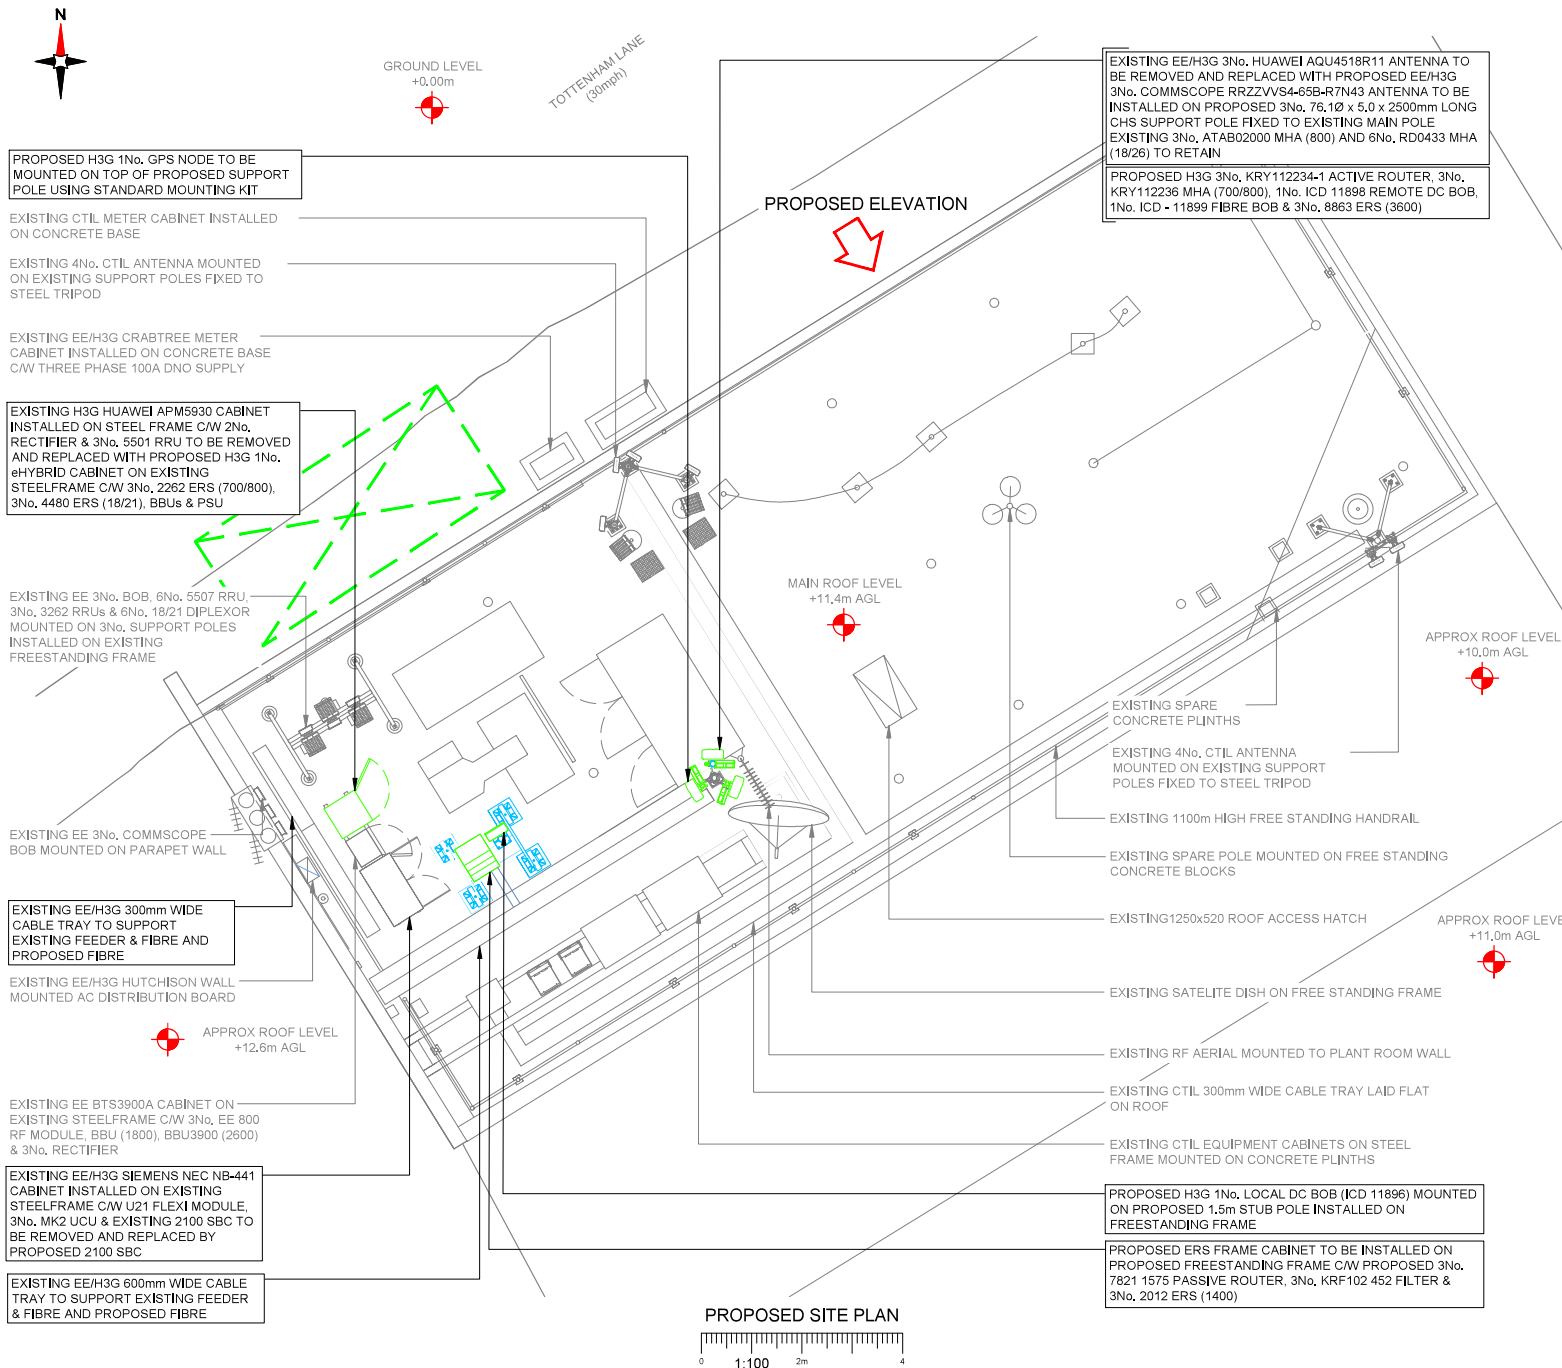

NOTES:

- ALL DIMENSIONS IN MM UNLESS OTHERWISE NOTED.

PROPOSED CRANE OR CHERRY PICKER LOCATION:



NOTE:

PROPOSED CHERRY PICKER/MEWP SET DOWN LOCATION TO BE CONFIRMED ON SITE BY SPECIALIST CONTRACTOR


Rev	Rev	Rev	Rev	Rev	Rev
M001	H3G	3UK UNILATERAL	Planning	A	
Drawn	28/08/2022	Revised / Description	First Issue		
Checked	COM Group				
Approved	Ben Ormshaw				



Hutchison 3G UK Limited
450 Longwater Avenue, Green Park
Reading, RG2 6SF
Tel: 01635 765 000
Fax: 01628 765 001

H3G Base Station Information Line:
0845 6043000
Available 8am-8pm Monday to Friday

 Design Consultant & Principal Contractor:



WHP Telecoms Ltd
Unit 1 Maple Park
Levens Road, Leeds
LS12 6HH
Tel: 0113 3023550 Fax: 0113 2676834
e-mail: info@whptelecoms.com

Site Name: **ROSEBERY HOUSE**

Site ID: **1106086**


Address: **165 ROSEBERY HOUSE
TOTTENHAM LANE A103
CROUCH END, HORNSEY
HARINGEY
LONDON
N8 9BY**

Title: **210 PROPOSED SITE PLAN**


Project: **3UK UNILATERAL**

Purpose of Issue: **GENERAL ARRANGEMENT**

EE Call ID	MSNL Call ID	3UK Call ID	Issue
24456	HGY026	N0018	
Master Drawing No. 1106086_HGY026_24456_N0018_M001			A

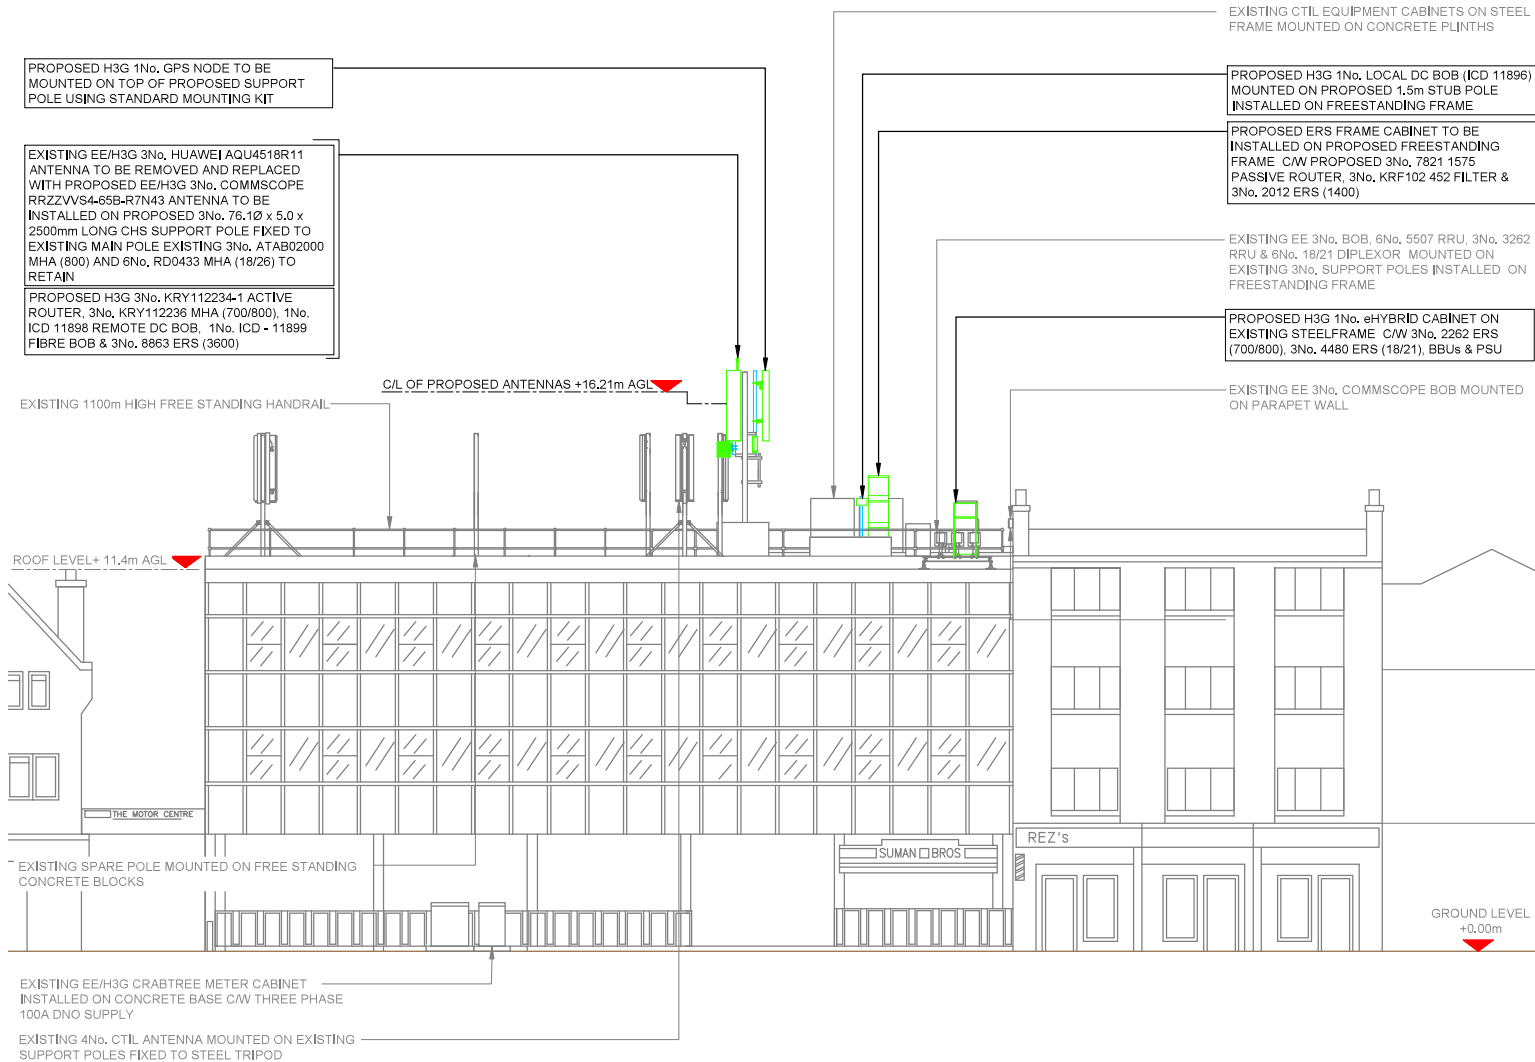

PROPOSED SITE ELEVATION

 

NOTES:

- ALL DIMENSIONS IN MM UNLESS OTHERWISE NOTED.


Rev	Rev	Rev	Rev	Rev	Rev
M001	H3G	3UK UNILATERAL	Planning	A	
Drawn	28/06/2022	Revised / Upgrade Description:			
Checked	COM Group	First Issue			
Approved	Ben Ormshaw				



Hutchison 3G UK Limited
450 Longwater Avenue, Green Park
Reading, RG2 6SF
Tel: 01635 765 000
Fax: 01628 765 001

H3G Base Station Information line:
0845 6043000
Available 8am-8pm Monday to Friday

Design Consultant & Principal Contractor:

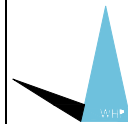

WHP Telecoms Ltd
Unit 1 Maple Park
Levenside Road, Leeds
LS12 6HH
Tel: 0113 3023550 Fax: 0113 2676834
e-mail: info@whptelecoms.com

Site Name:		ROSEBERY HOUSE	
Site ID:		1106086	
Address:		165 ROSEBERY HOUSE TOTTENHAM LANE A103 CROUCH END, HORNSEY HARINGEY LONDON N8 9BY	
Title:		260 PROPOSED SITE ELEVATION	
Project:		3UK UNILATERAL	
Purpose of Issue:		GENERAL ARRANGEMENT	
EE Cell ID:	MSNL Cell ID:	3UK Cell ID:	
24456	HGY026	N0018	
Master Drawing No:		1106086_HGY026_24456_N0018_M001	Issue: A