




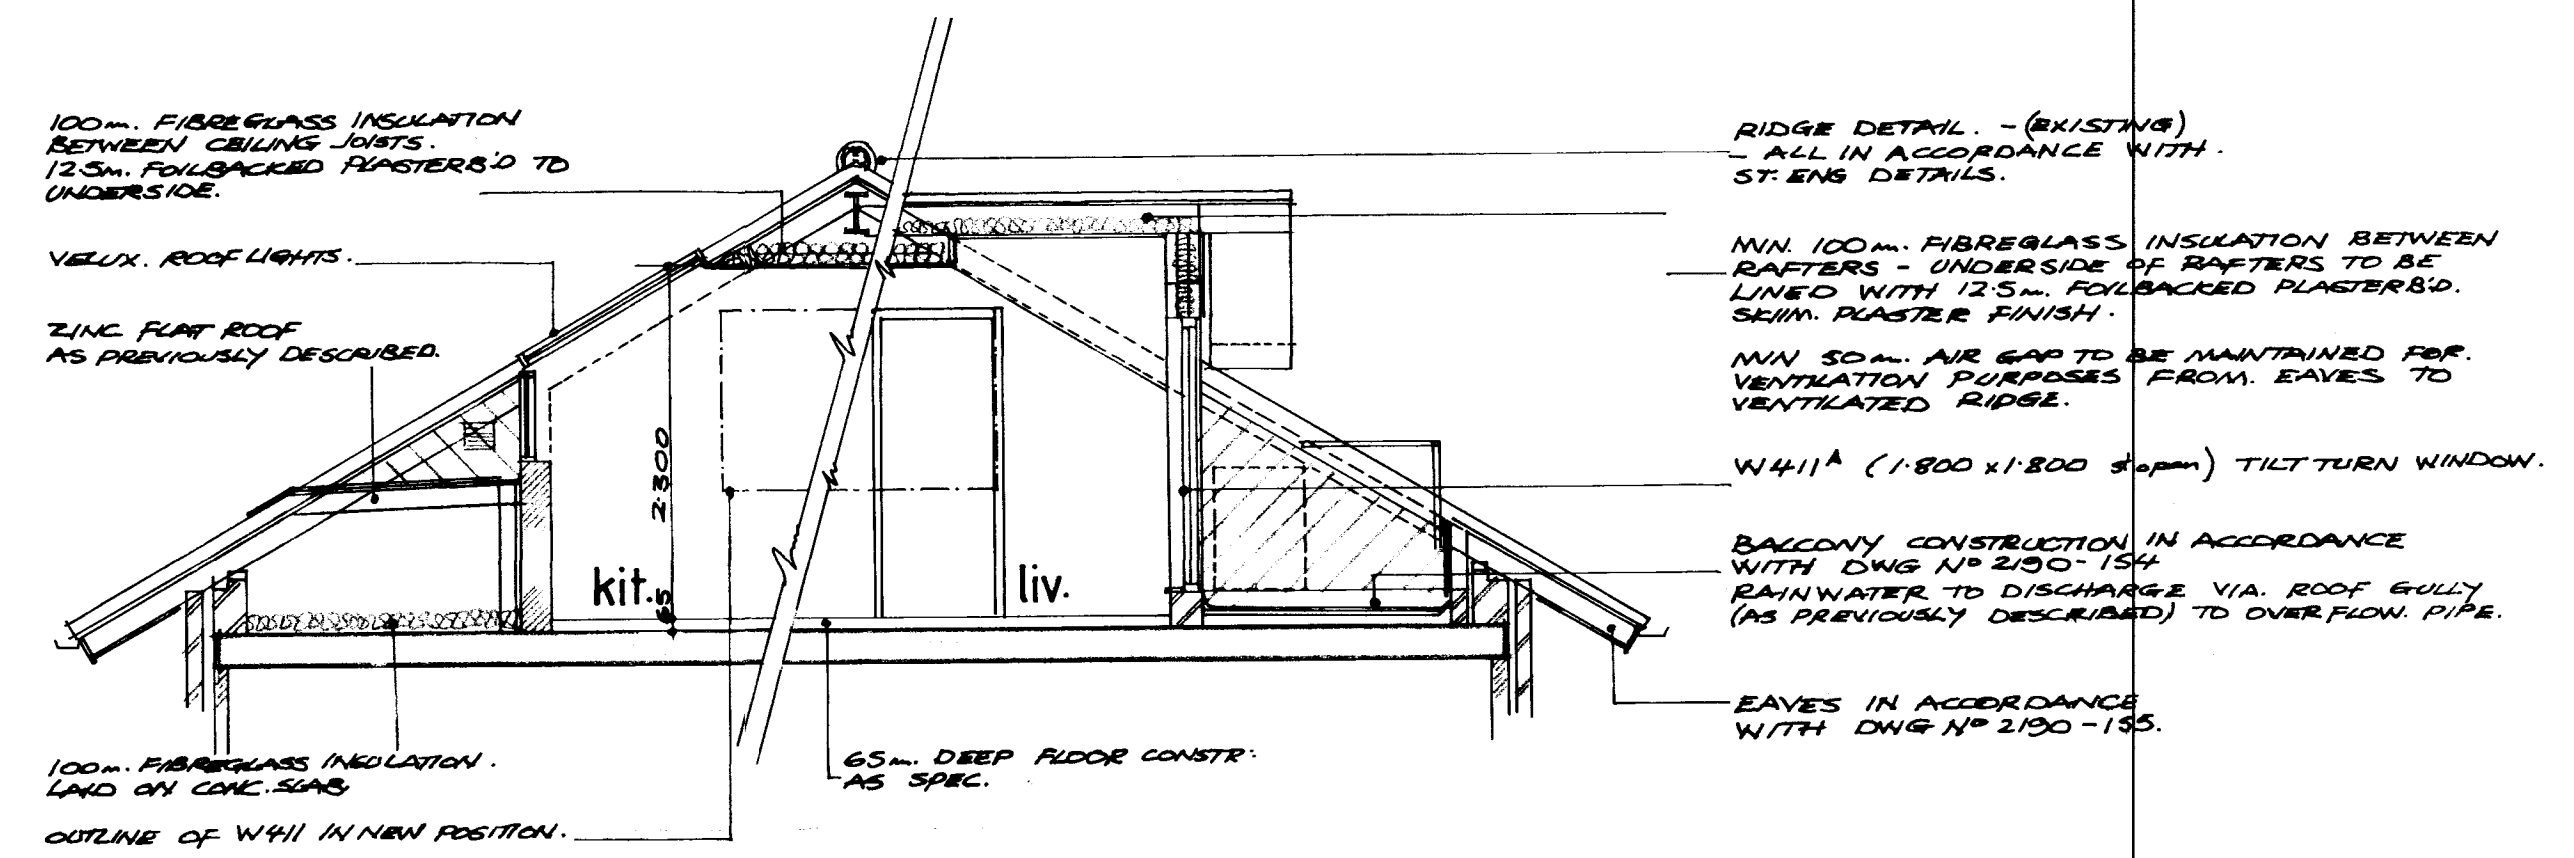

SECTION A-A [attic level]

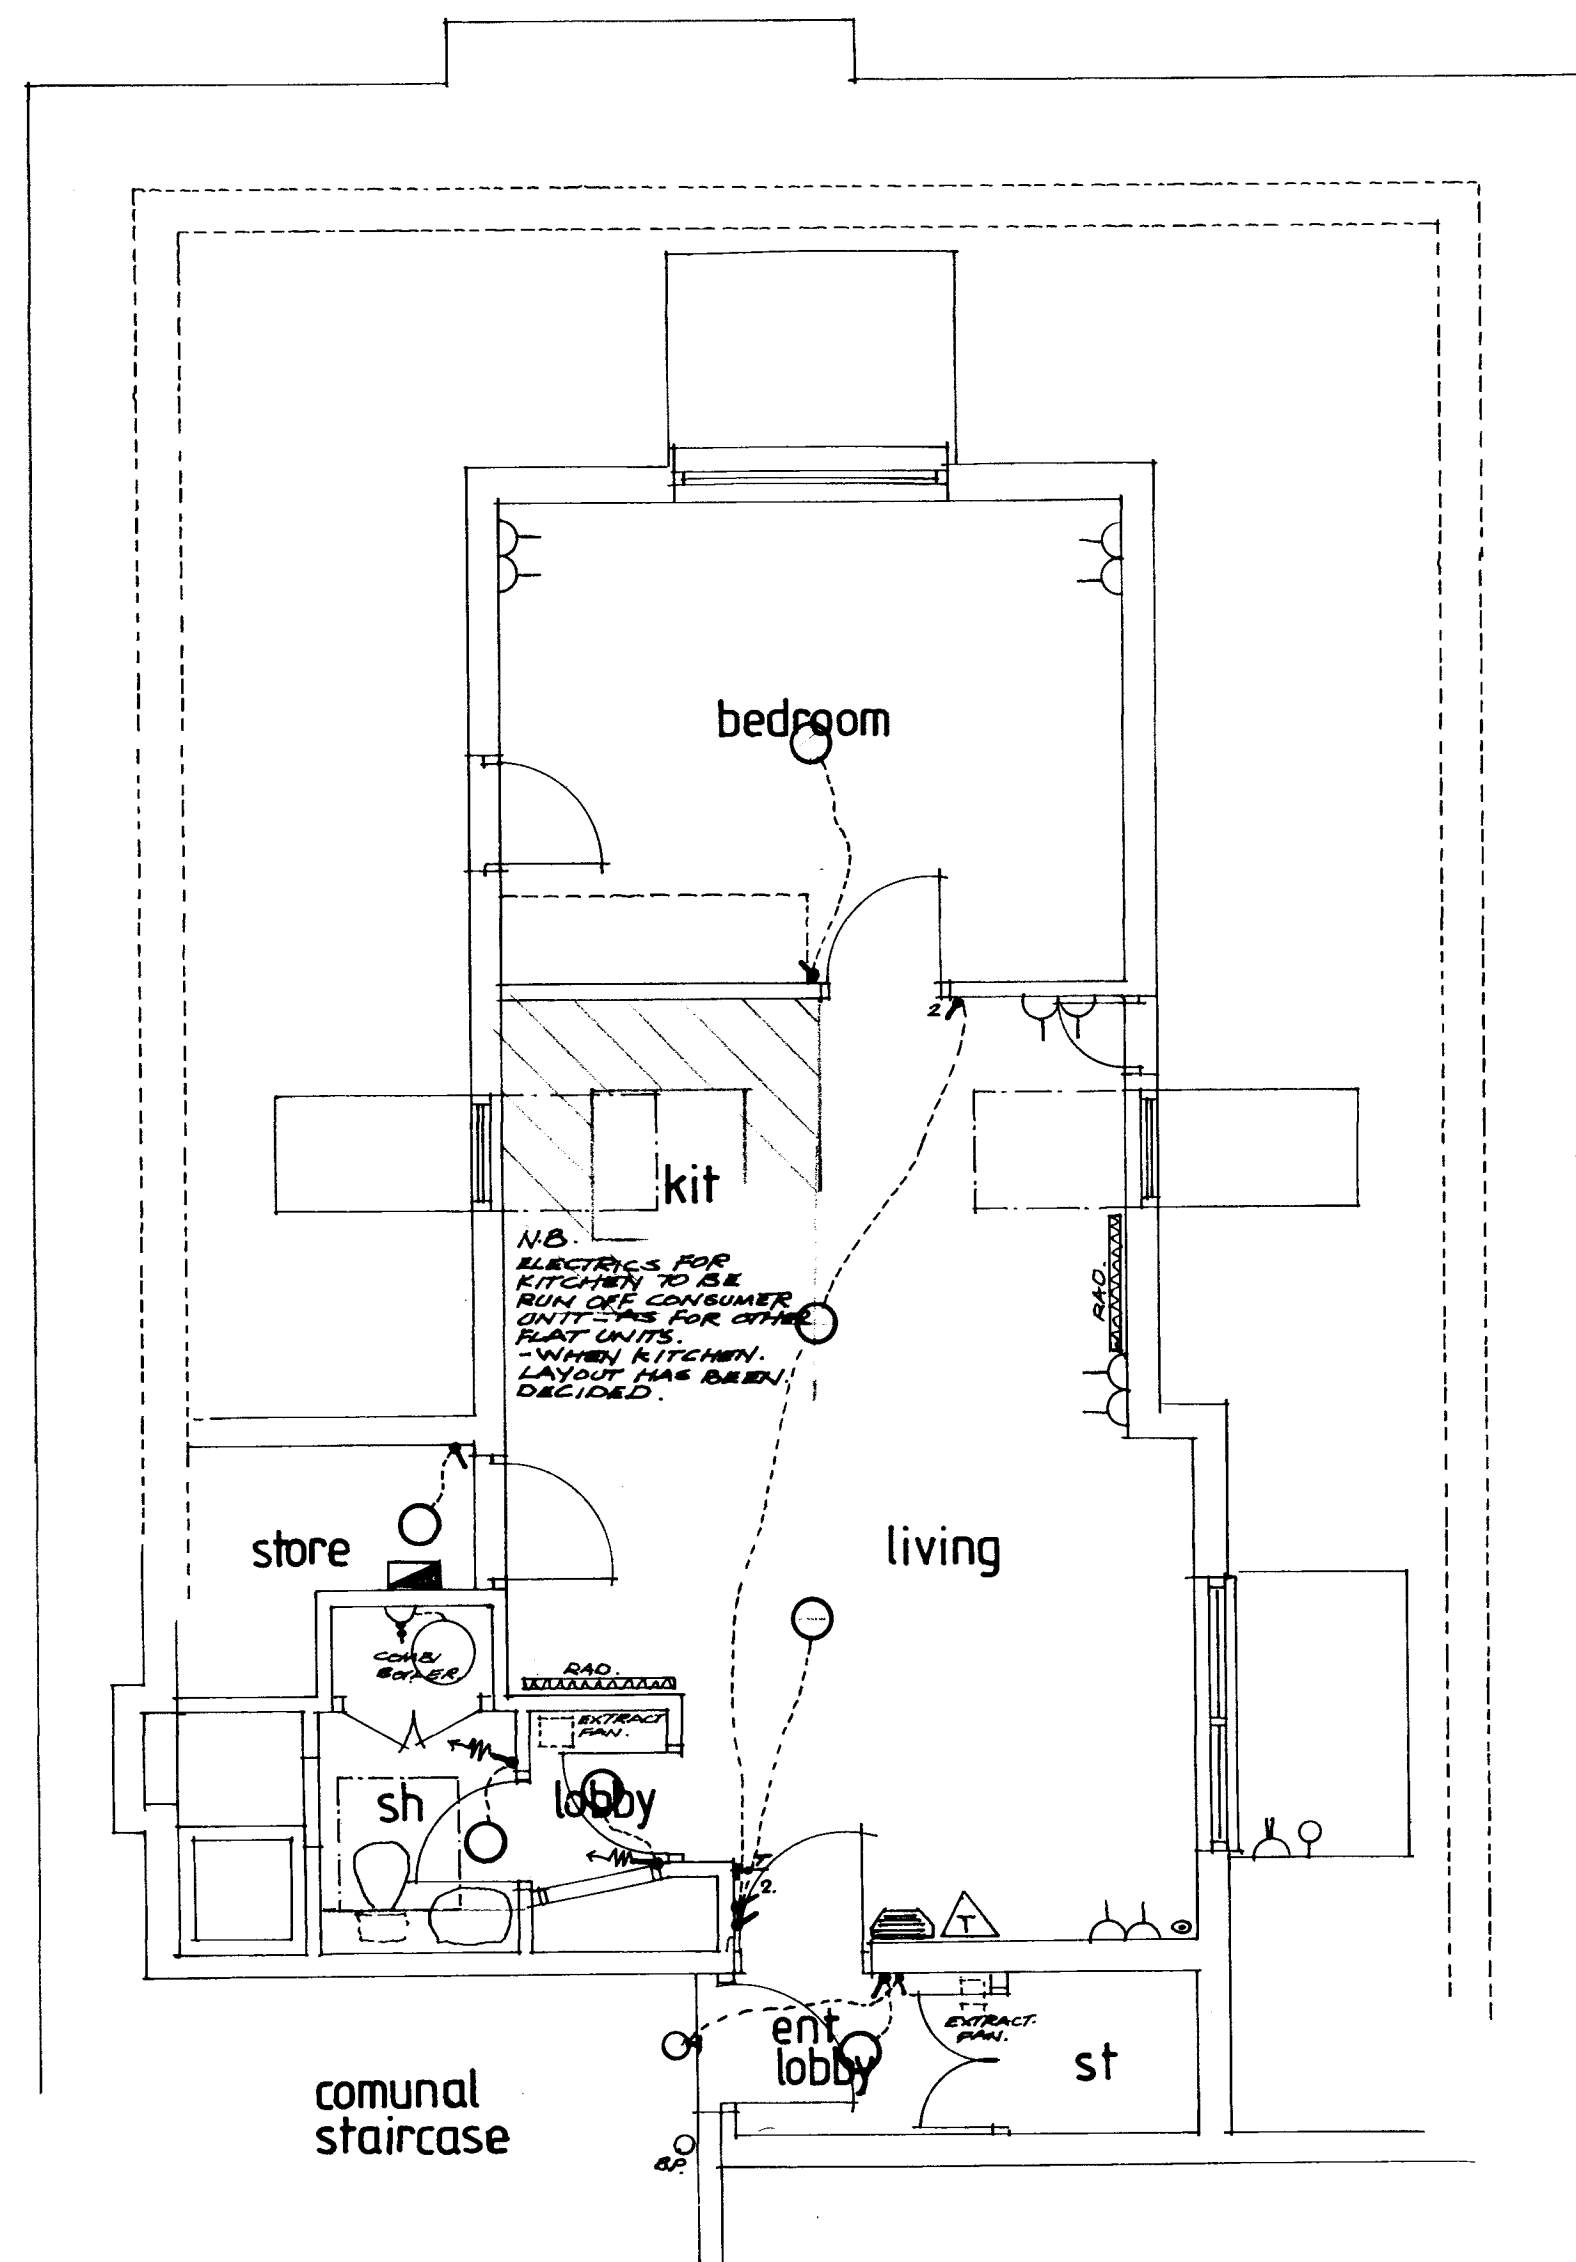

CARETAKERS ROOM ELECTRICAL LAYOUT
TO BE REPO IN CONJUNCTION WITH DNG N° 2100-106 ELECTRICAL.

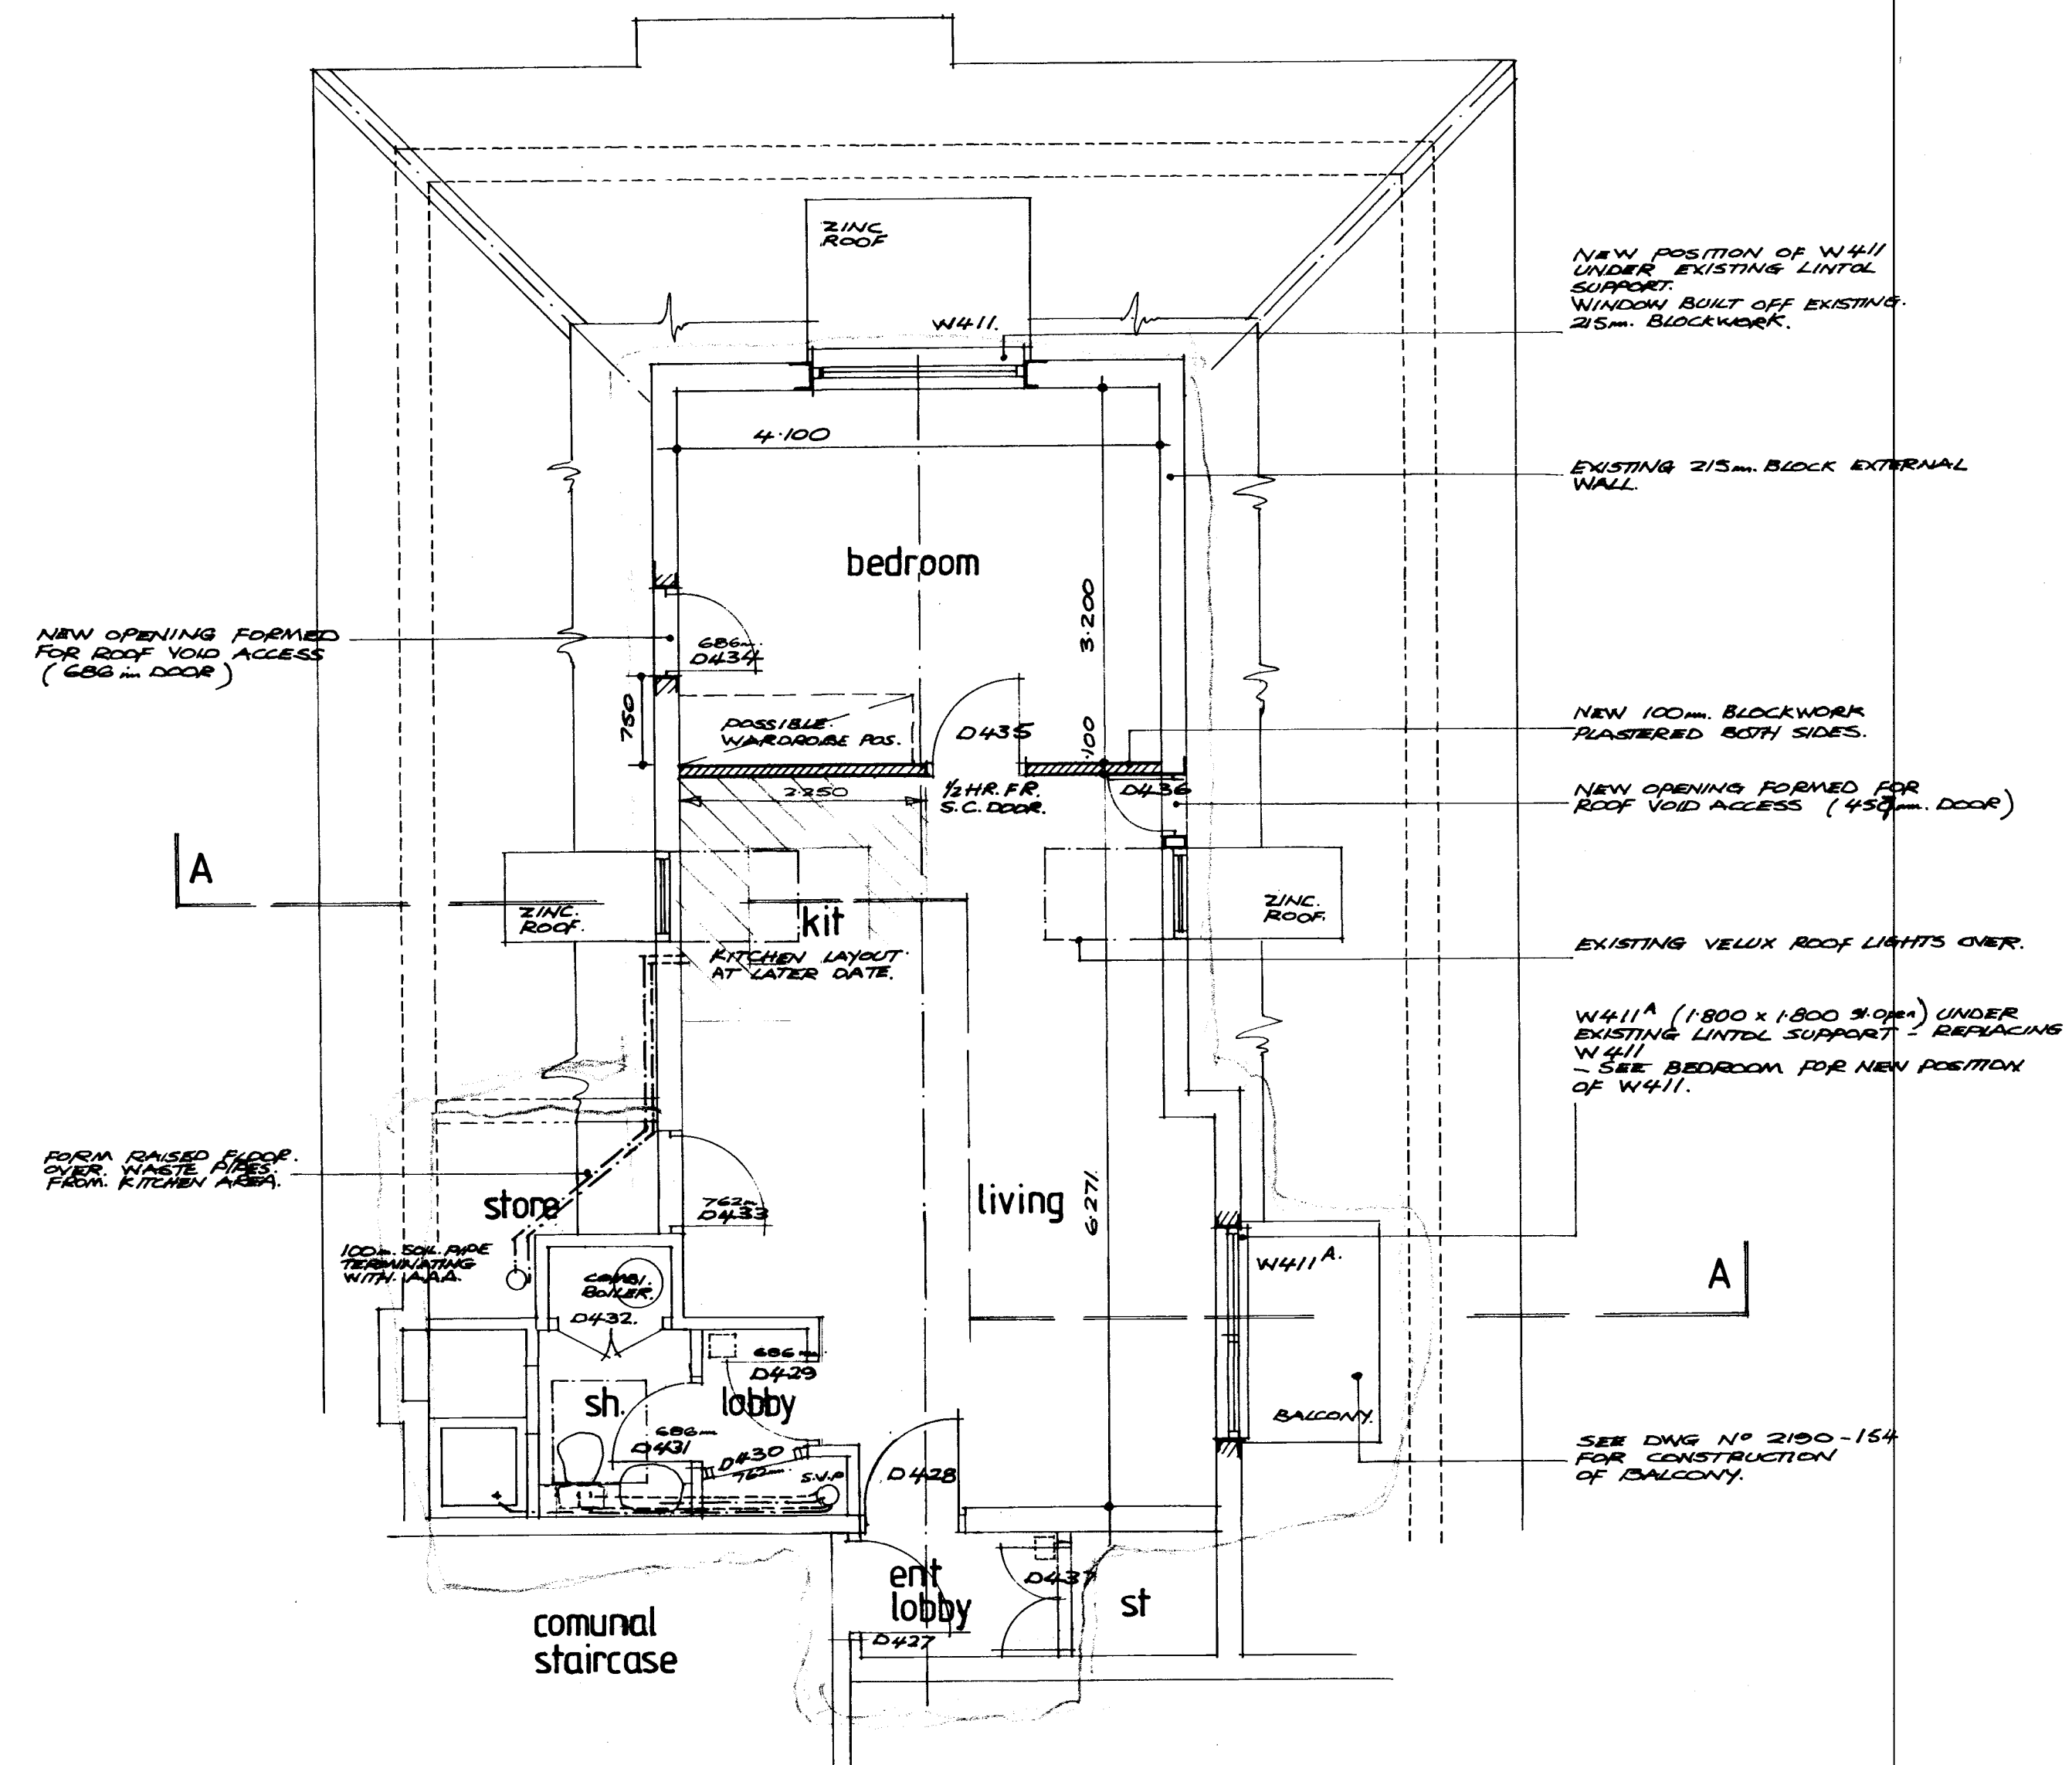

CARETAKERS ROOM — PLAN

REVISIONS

Do not scale, this drawing to be read in conjunction with all relevant consultants, sub-contractors and specialists drawings.

TITLE
38-40 SHEPHERDS HILL
HIGHGATE NG
CLIENT
PROPERTY PARTNERS LTD.
SUBJECT
AMENDMENT TO CARETAKERS ROOM (ATTIC PLAN) INCLUDING REPAIRED ELECTRICAL LAYOUT.

SCALE 1:50

DRAWN DATE FEB 90

JOB DRAWING

2190 - 171

Gerald Murphy Burles Newton & Partners

4/8 Highgate High Street London N6 5JL
35 Alexandra St Southend on Sea Essex SS1 1BW