


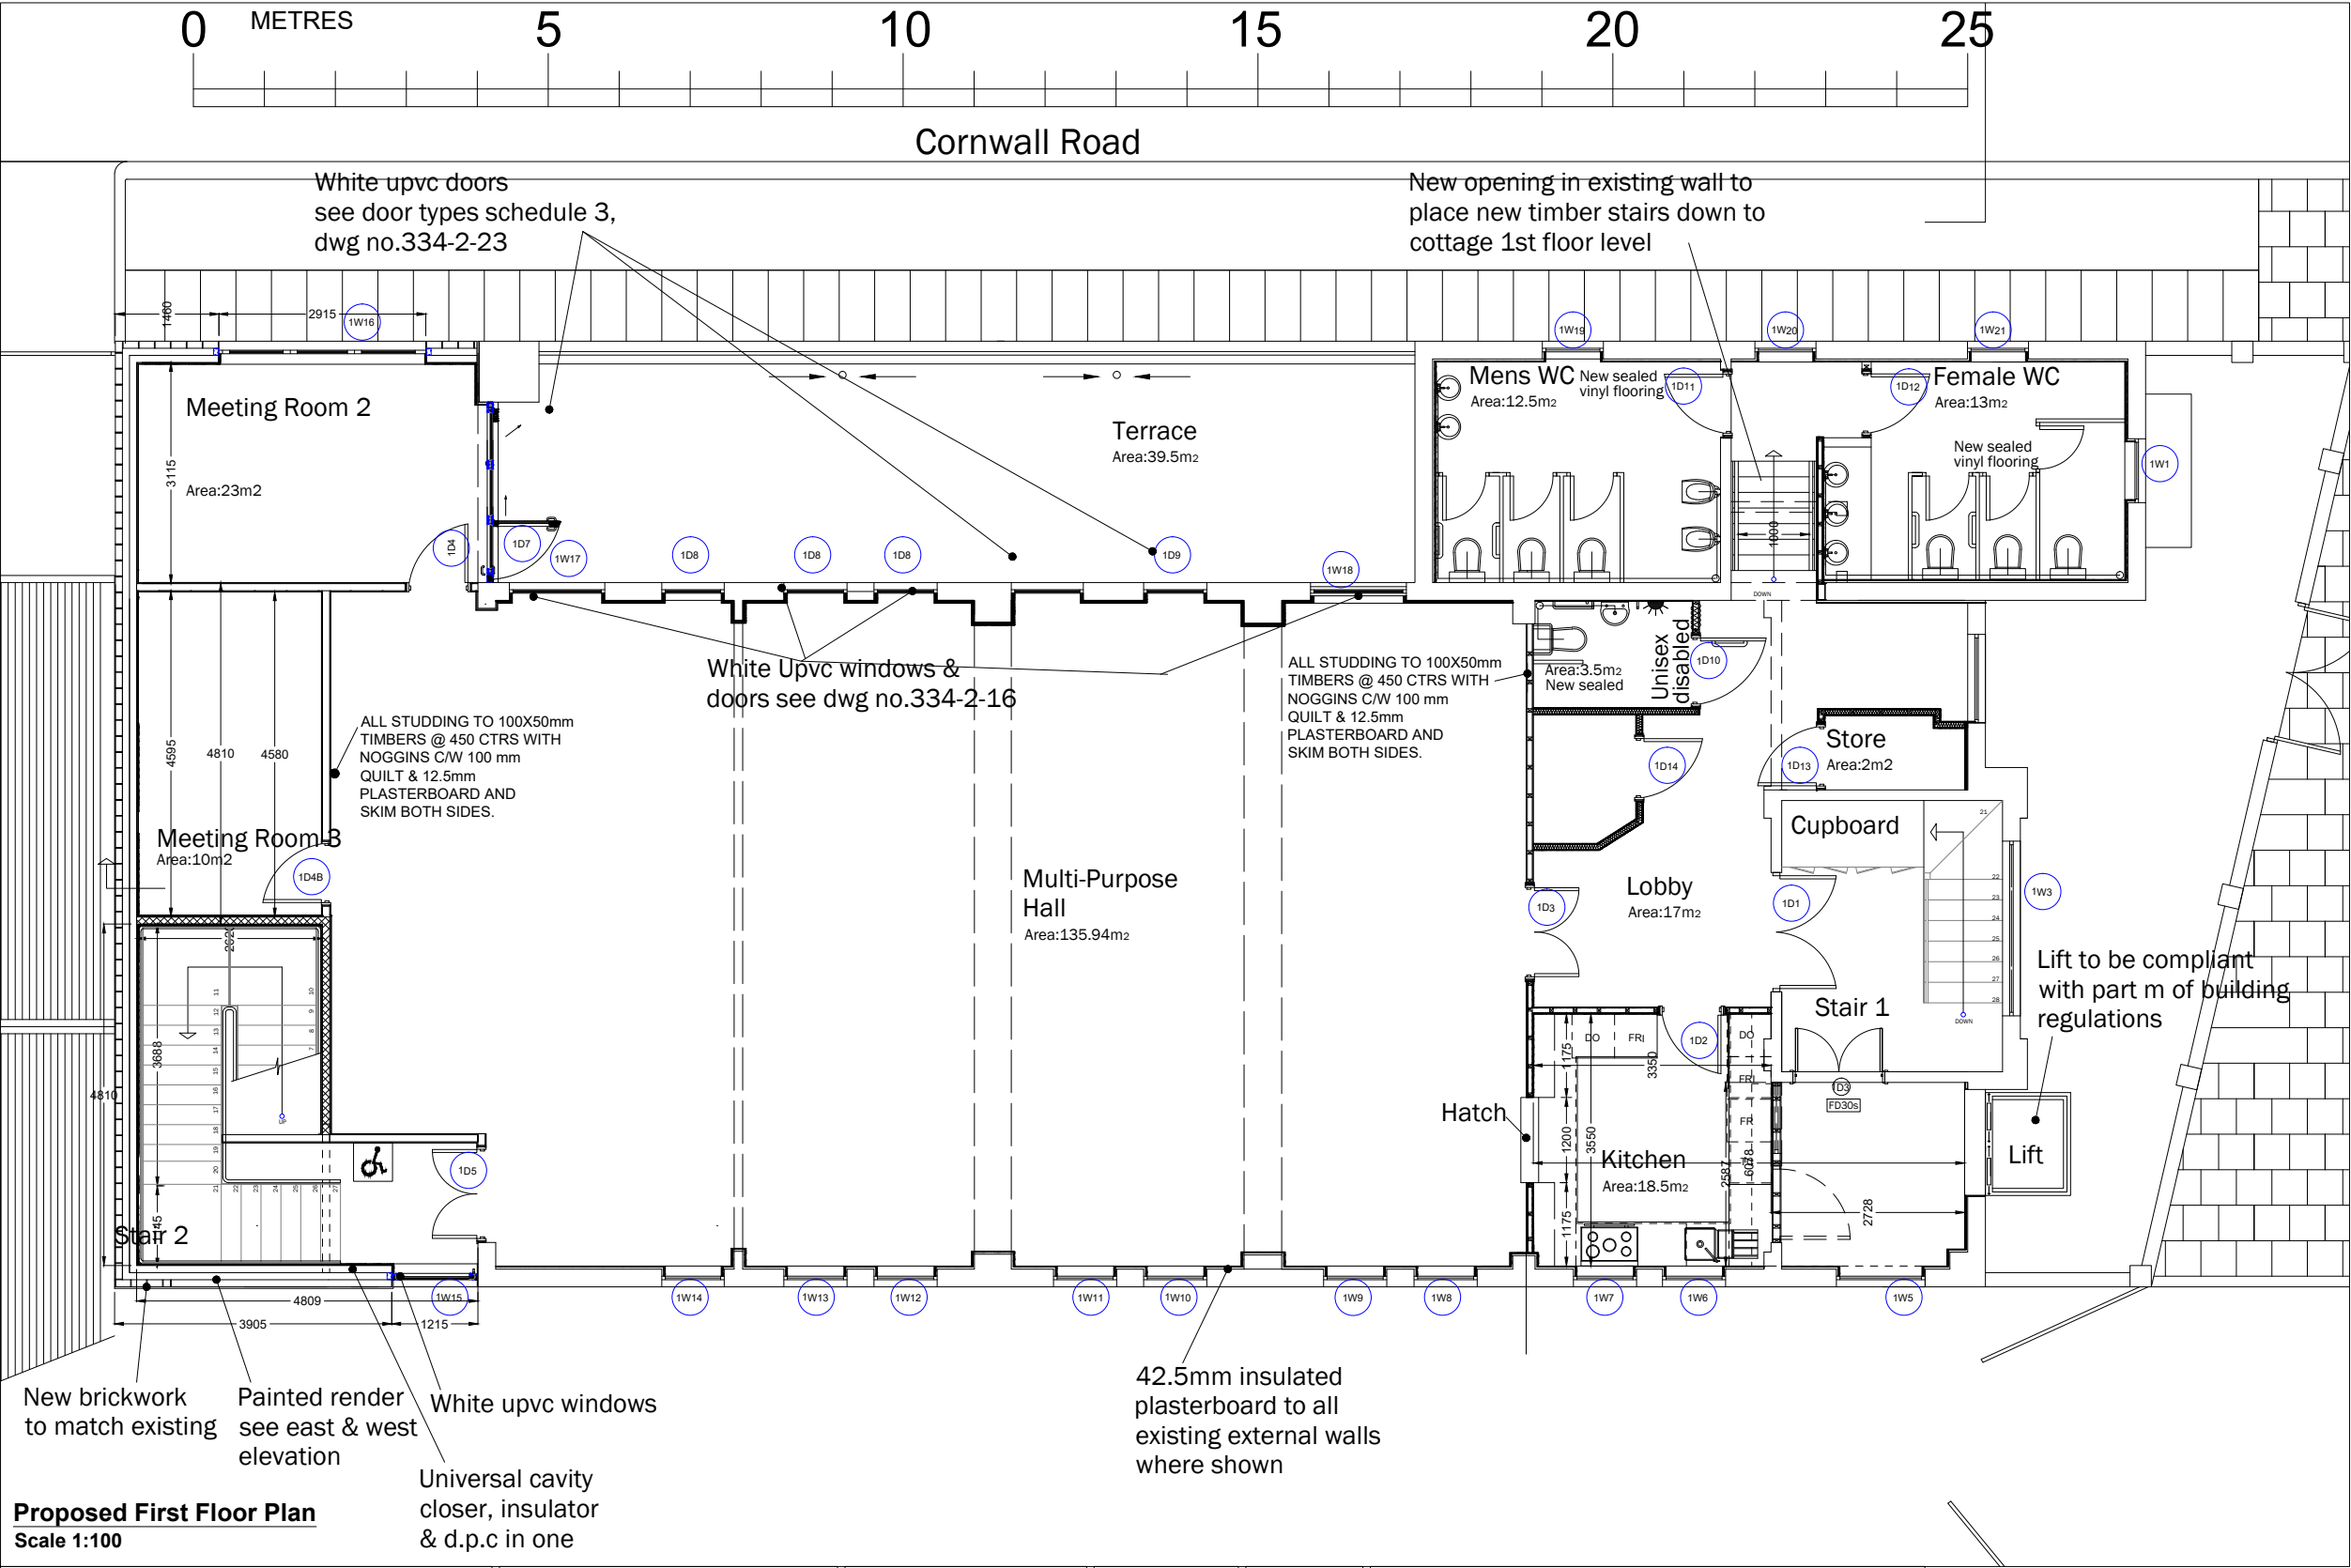

Note: No dimensions to be scaled from this drawing.
All dimensions to be checked on site by contractor.
If in doubt contact architect.

LEGEND:	
SYMBOL	DESCRIPTION
	DOOR AUDIO ENTRY PANEL
	AUDIO ENTRY PHONE
	PIR DETECTOR
	KEYPAD
	DOOR CONTACT
	EXTERNAL ALARM BOX
	SPEAKER MASTER
	SPEAKER POINT (ABOVE CEILING)
	DATA SOCKET
	TV SOCKET
	SAT & RETURN
	BT SOCKET
	TWIN SOCKET OUTLET
	FAN ISOLATOR
	EXTRACT FAN
	SOUNDER
	SMOKE DETECTOR
	PUSH
	SHAVESOCKET
	FUSE BOARD
	ALARM PANEL INCLUDING SPUR
	ENTRY CAMERA
	1.5kw TIMED PANEL HEATER
	BOILER
	LIGHT SWITCH
	2 WAY LIGHT SWITCH
	TIMER PRESS SWITCH
	EXTERNAL PHOTOCELL LIGHT
	PENDANT
	LOW ENERGY PENDANT
	GUID DOWNLIGHT
	I.P. RATED DOWN LIGHT
	16W 2D EMERGENCY LIGHT
	HEAT DETECTOR
	WALL LIGHT
	MAINS POWERED CARBON MONOXIDE ALARM INTERLINKED WITH SMOKE DETECTOR VIA ALARM CONTROLLER
	ELECTRIC WALL MOUNTED AIR CON UNIT
	SUSPENDED LUMINAIRE
	SURFACE MOUNTED LUMINAIRE
	LOW ENERGY SMALL SURFACE MOUNTED LIGHT
	FIRE ALARM CALL POINT

Fire alarm systems to be updated in accordance with BS5839-1

All Emergency lighting to be updated in accordance with BS5266-1

endymion architects

1 Nightingale Mews,
Hornsey, London
N8 7RA
Tel: 020 8340 0004
Email: ea@endymion-architects.com
Website: www.endymionarchitects.com

Project:
SDA Church
West Green Road,
N15 5EG
Client:
SDA Church

Drawing:
Proposed First
Floor Plan
Number:
334-2-04

Scale:
1:100 @ A3
Drawn:
OHC

Date:
01/05/15
Check:
JED

Revisions:
K-24/09/2018 New Lift to be up against cottage & new glazed entrance & canopy.
J - Lift moved from right hand side of frontage to left hand side.

Existing
New
Demolish

KEY:	
	Existing
	New
	Demolish