


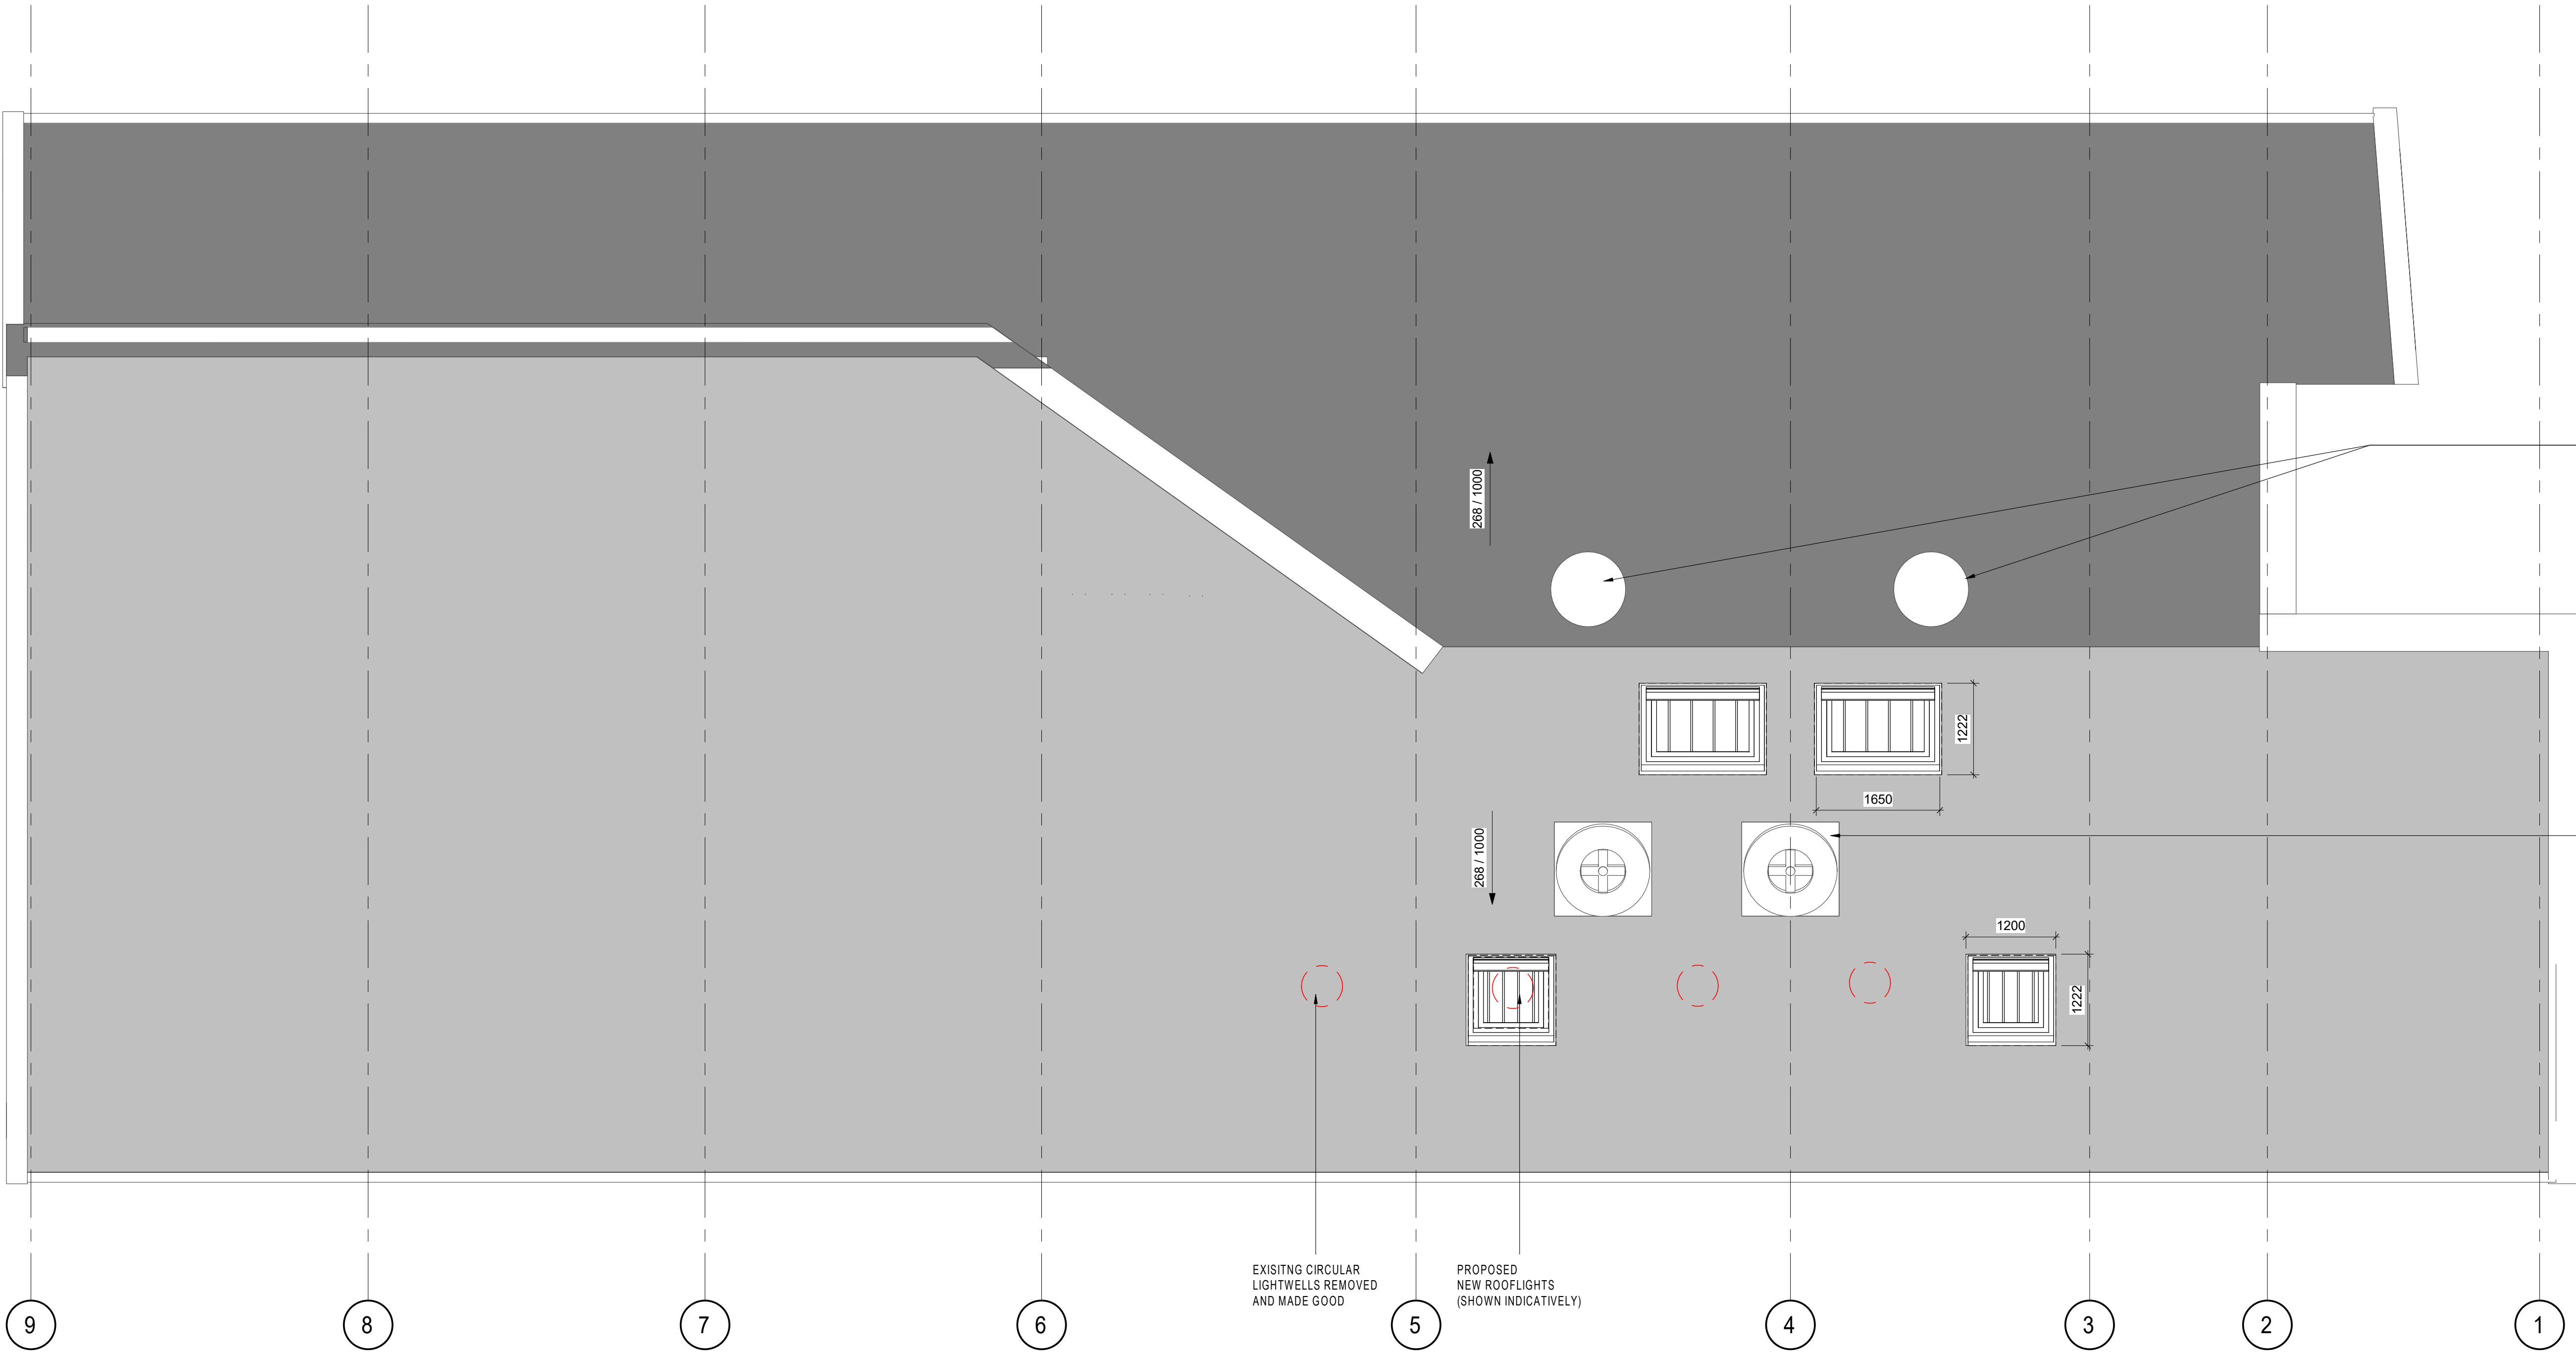


CHIMNEY EXTRACTS

2 NO. EXISTING ROOF MOUNTED VENTILATION FANS TO BE RETAINED


EXISTING CIRCULAR LIGHTWELLS REMOVED AND MADE GOOD

 PROPOSED NEW ROOFLIGHTS (SHOWN INDICATIVELY)



1 PROPOSED ROOF - PLAN

1 : 50

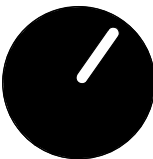

RIBA 3

REVISION	DATE	DESCRIPTION	ARCHITECT	PARTNER
1	07.08.22	STAGE 03 DRAFT ISSUE	LS	ADP
2	13.01.23	PLANNING ISSUE	LS	ADP
3	16.01.23	STAGE 3 ISSUE	LS	ADP

CHECK ALL DIMENSIONS AND VERIFY ON SITE. REPORT ANY ERRORS OR OMISSIONS

The Fire Station
150 Waterloo Road
London
SE1 8SB
T +44 (0) 20 7089 1720
E london@adp-architecture.com
www.adp-architecture.com

JOB TITLE:
**BRUCE GROVE
YOUTH SPACE**

DRAWING TITLE:
PROPOSED ROOF PLAN

SCALE: 1 : 50		DRAWING SHEET SIZE: A1	
JOB CODE: 001550	DRAWING NUMBER: ADP-00-R1-DR- A-1052	REVISION: 3	