


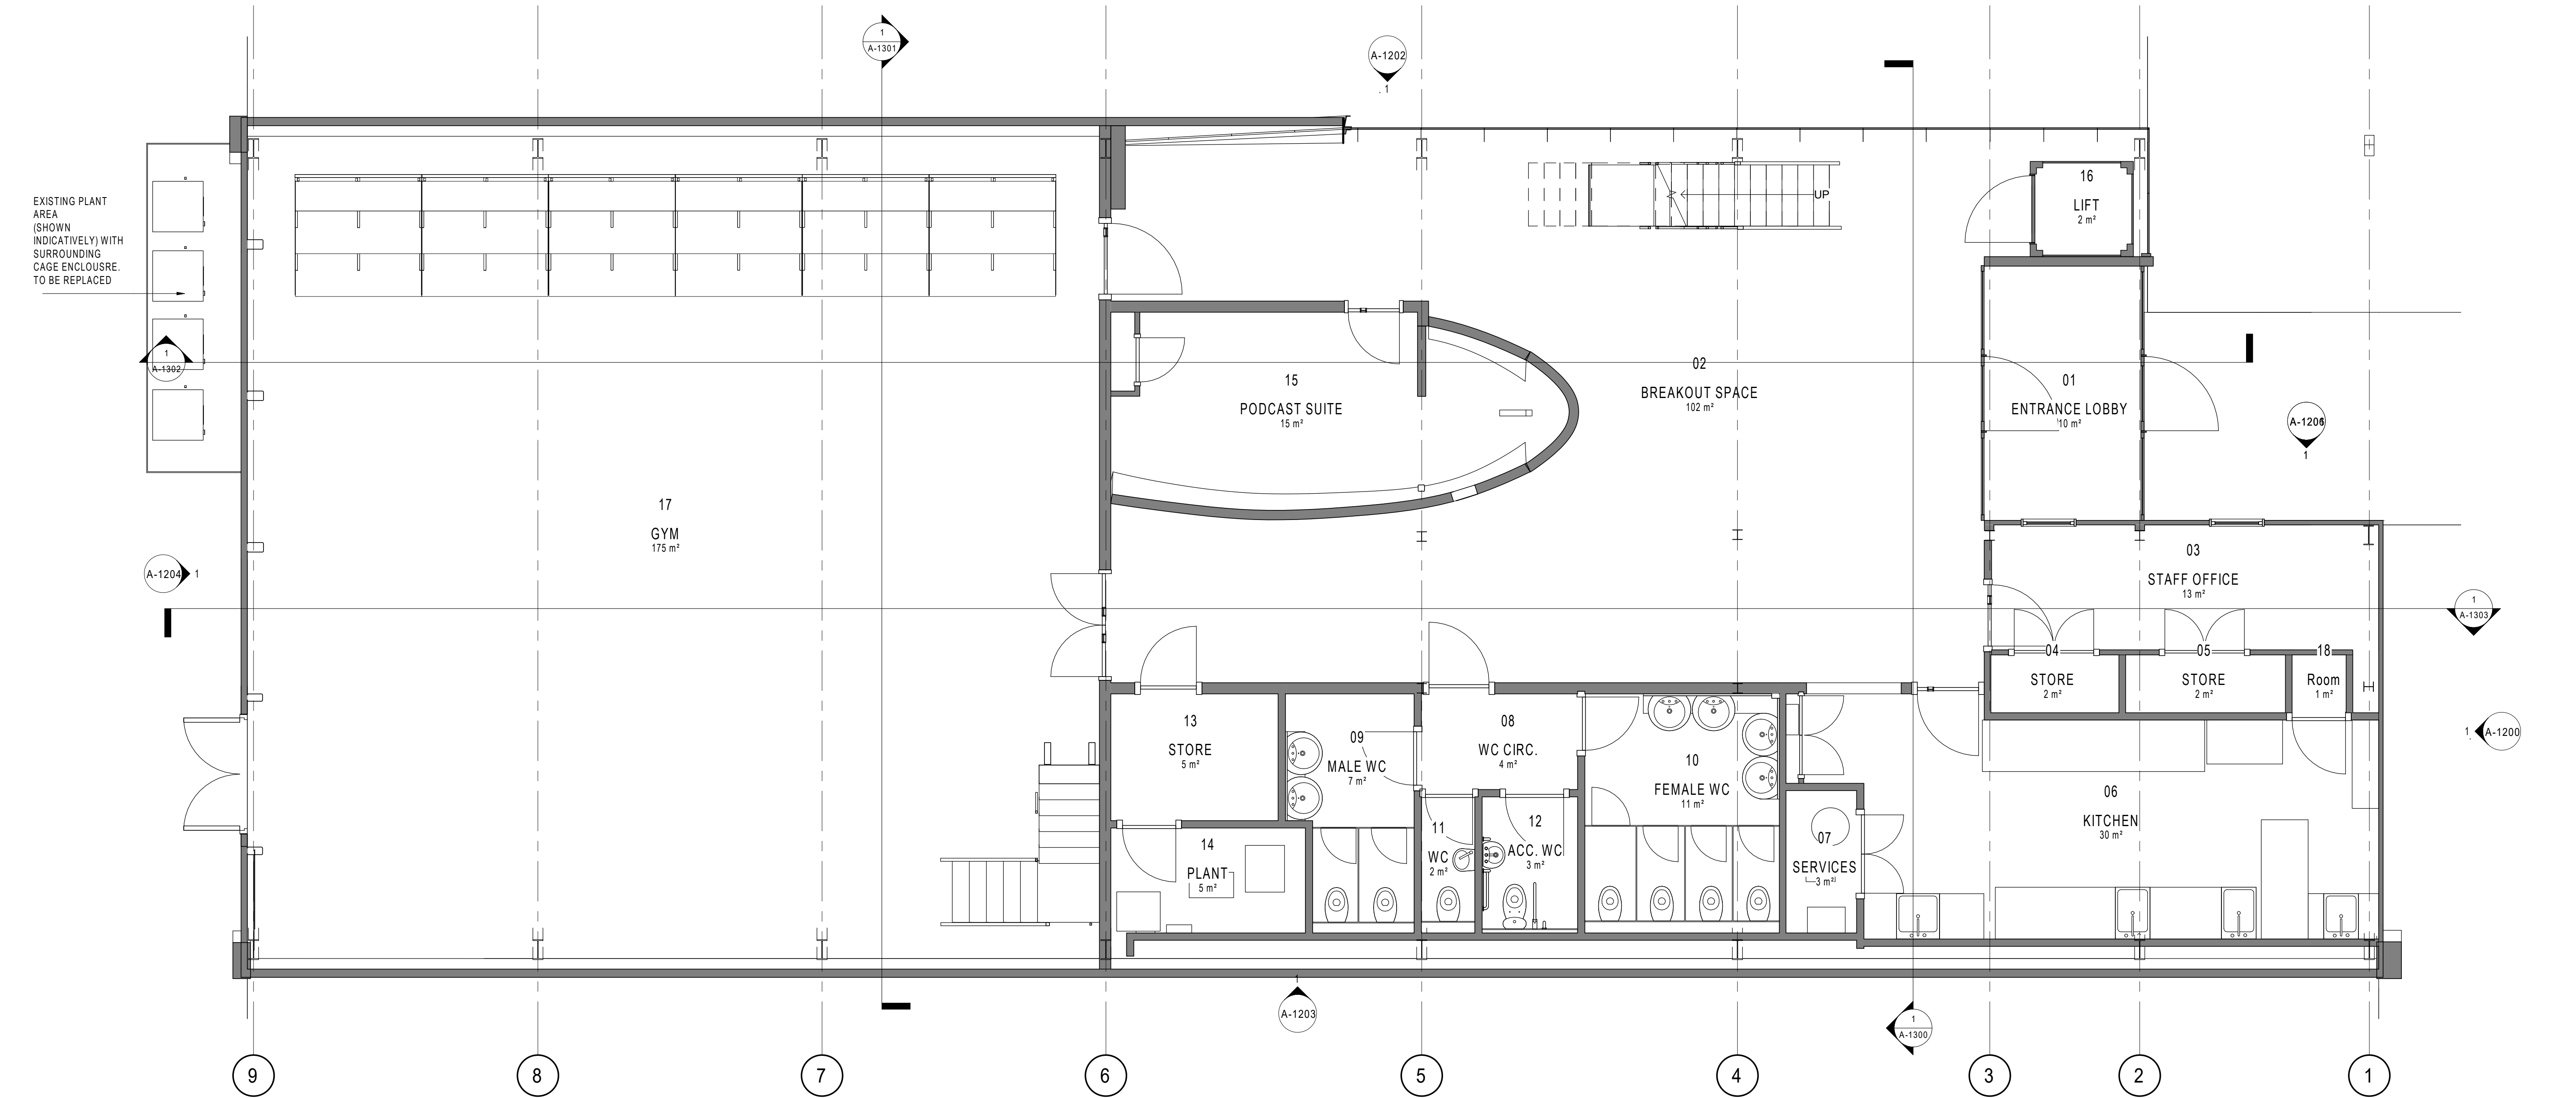

1 EXISTING GROUND FLOOR PLAN
1 : 50

RIBA 3				
REVISION	DATE	DESCRIPTION	ARCHITECT	PARTNER
1	18.05.22	WIP ISSUE	LS	ADP
2	07.09.22	STAGE 63 DRAFT ISSUE	LS	ADP
3	21.12.22	DRAFT PLANNING ISSUE	LS	ADP

CHECK ALL DIMENSIONS AND VERIFY ON SITE. REPORT ANY ERRORS OR OMISSIONS.

adp The Fire Station
150 Waterloo Road
London
SE1 8SB
T +44 (0) 20 7089 1720
E london@adp-architecture.com
www.adp-architecture.com

JOB TITLE:
**BRUCE GROVE
YOUTH SPACE**

DRAWING TITLE:
EXISTING PLAN - GROUND FLOOR

SCALE: 1 : 50		DRAWING SHEET SIZE: A1	
JOB CODE: 001550	DRAWING NUMBER: ADP-00-00-DR- A-0901	REVISION: 3	