
 


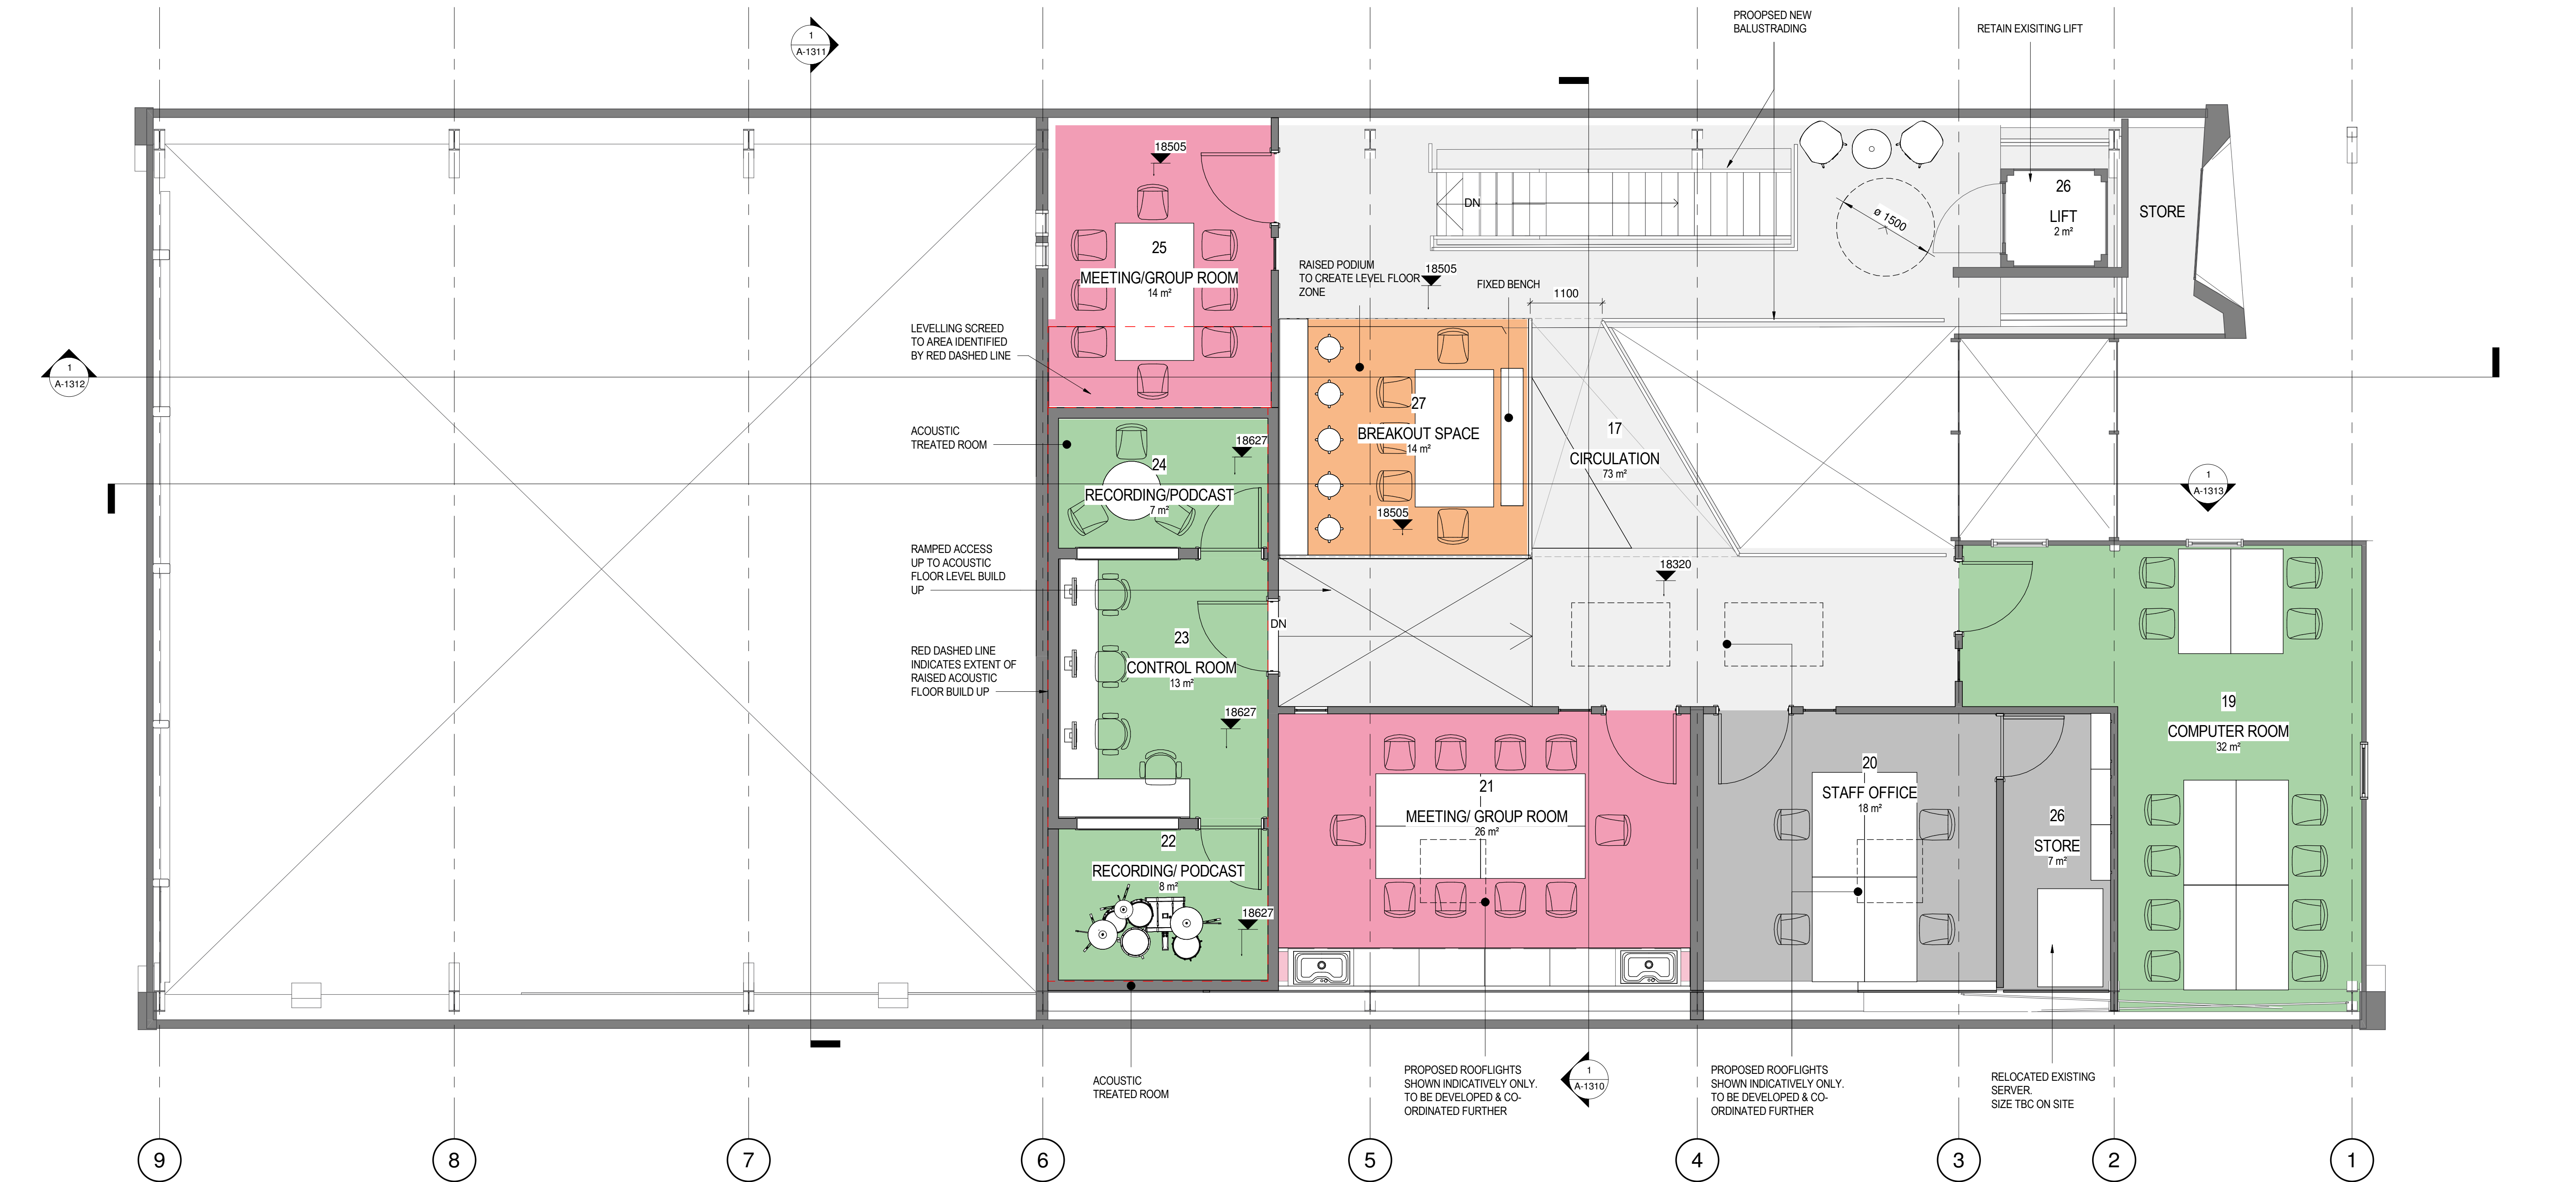

1 PROPOSED FIRST FLOOR PLAN
1 : 50

Department Legend

- ANCILLARY
- BREAKOUT SPACE
- CIRCULATION
- FLEXIBLE GROUP ROOMS
- SPECIALIST SPACE



RIBA 3				
REVISION	DATE	DESCRIPTION	ARCHITECT	PARTNER
1	18.05.22	WIP ISSUE	LS	ADP
2	23.06.22	Stage 02 Issue	LS	ADP
3	09.08.22	Issued to SE for review	LS	ADP
4	07.09.22	STAGE 03 DRAFT ISSUE	LS	ADP
5	21.12.22	Issued for MEP review	LS	ADP
6	21.12.22	DRAFT PLANNING ISSUE	LS	ADP
7	13.01.23	PLANNING ISSUE	LS	ADP
8	16.01.23	STAGE 3 ISSUE	LS	ADP

CHECK ALL DIMENSIONS AND VERIFY ON SITE. REPORT ANY ERRORS OR OMISSIONS.

adp The Fire Station
150 Waterloo Road
London
SE1 8SB
T +44 (0) 20 7089 1720
E london@adp-architecture.com
www.adp-architecture.com

JOB TITLE:
**BRUCE GROVE
YOUTH SPACE**

DRAWING TITLE:
PROPOSED FIRST FLOOR PLAN

SCALE: 1 : 50		DRAWING SHEET SIZE: A1	
JOB CODE: 001550	DRAWING NUMBER: ADP-00-01-DR- A-1051	REVISION: 8	