
 


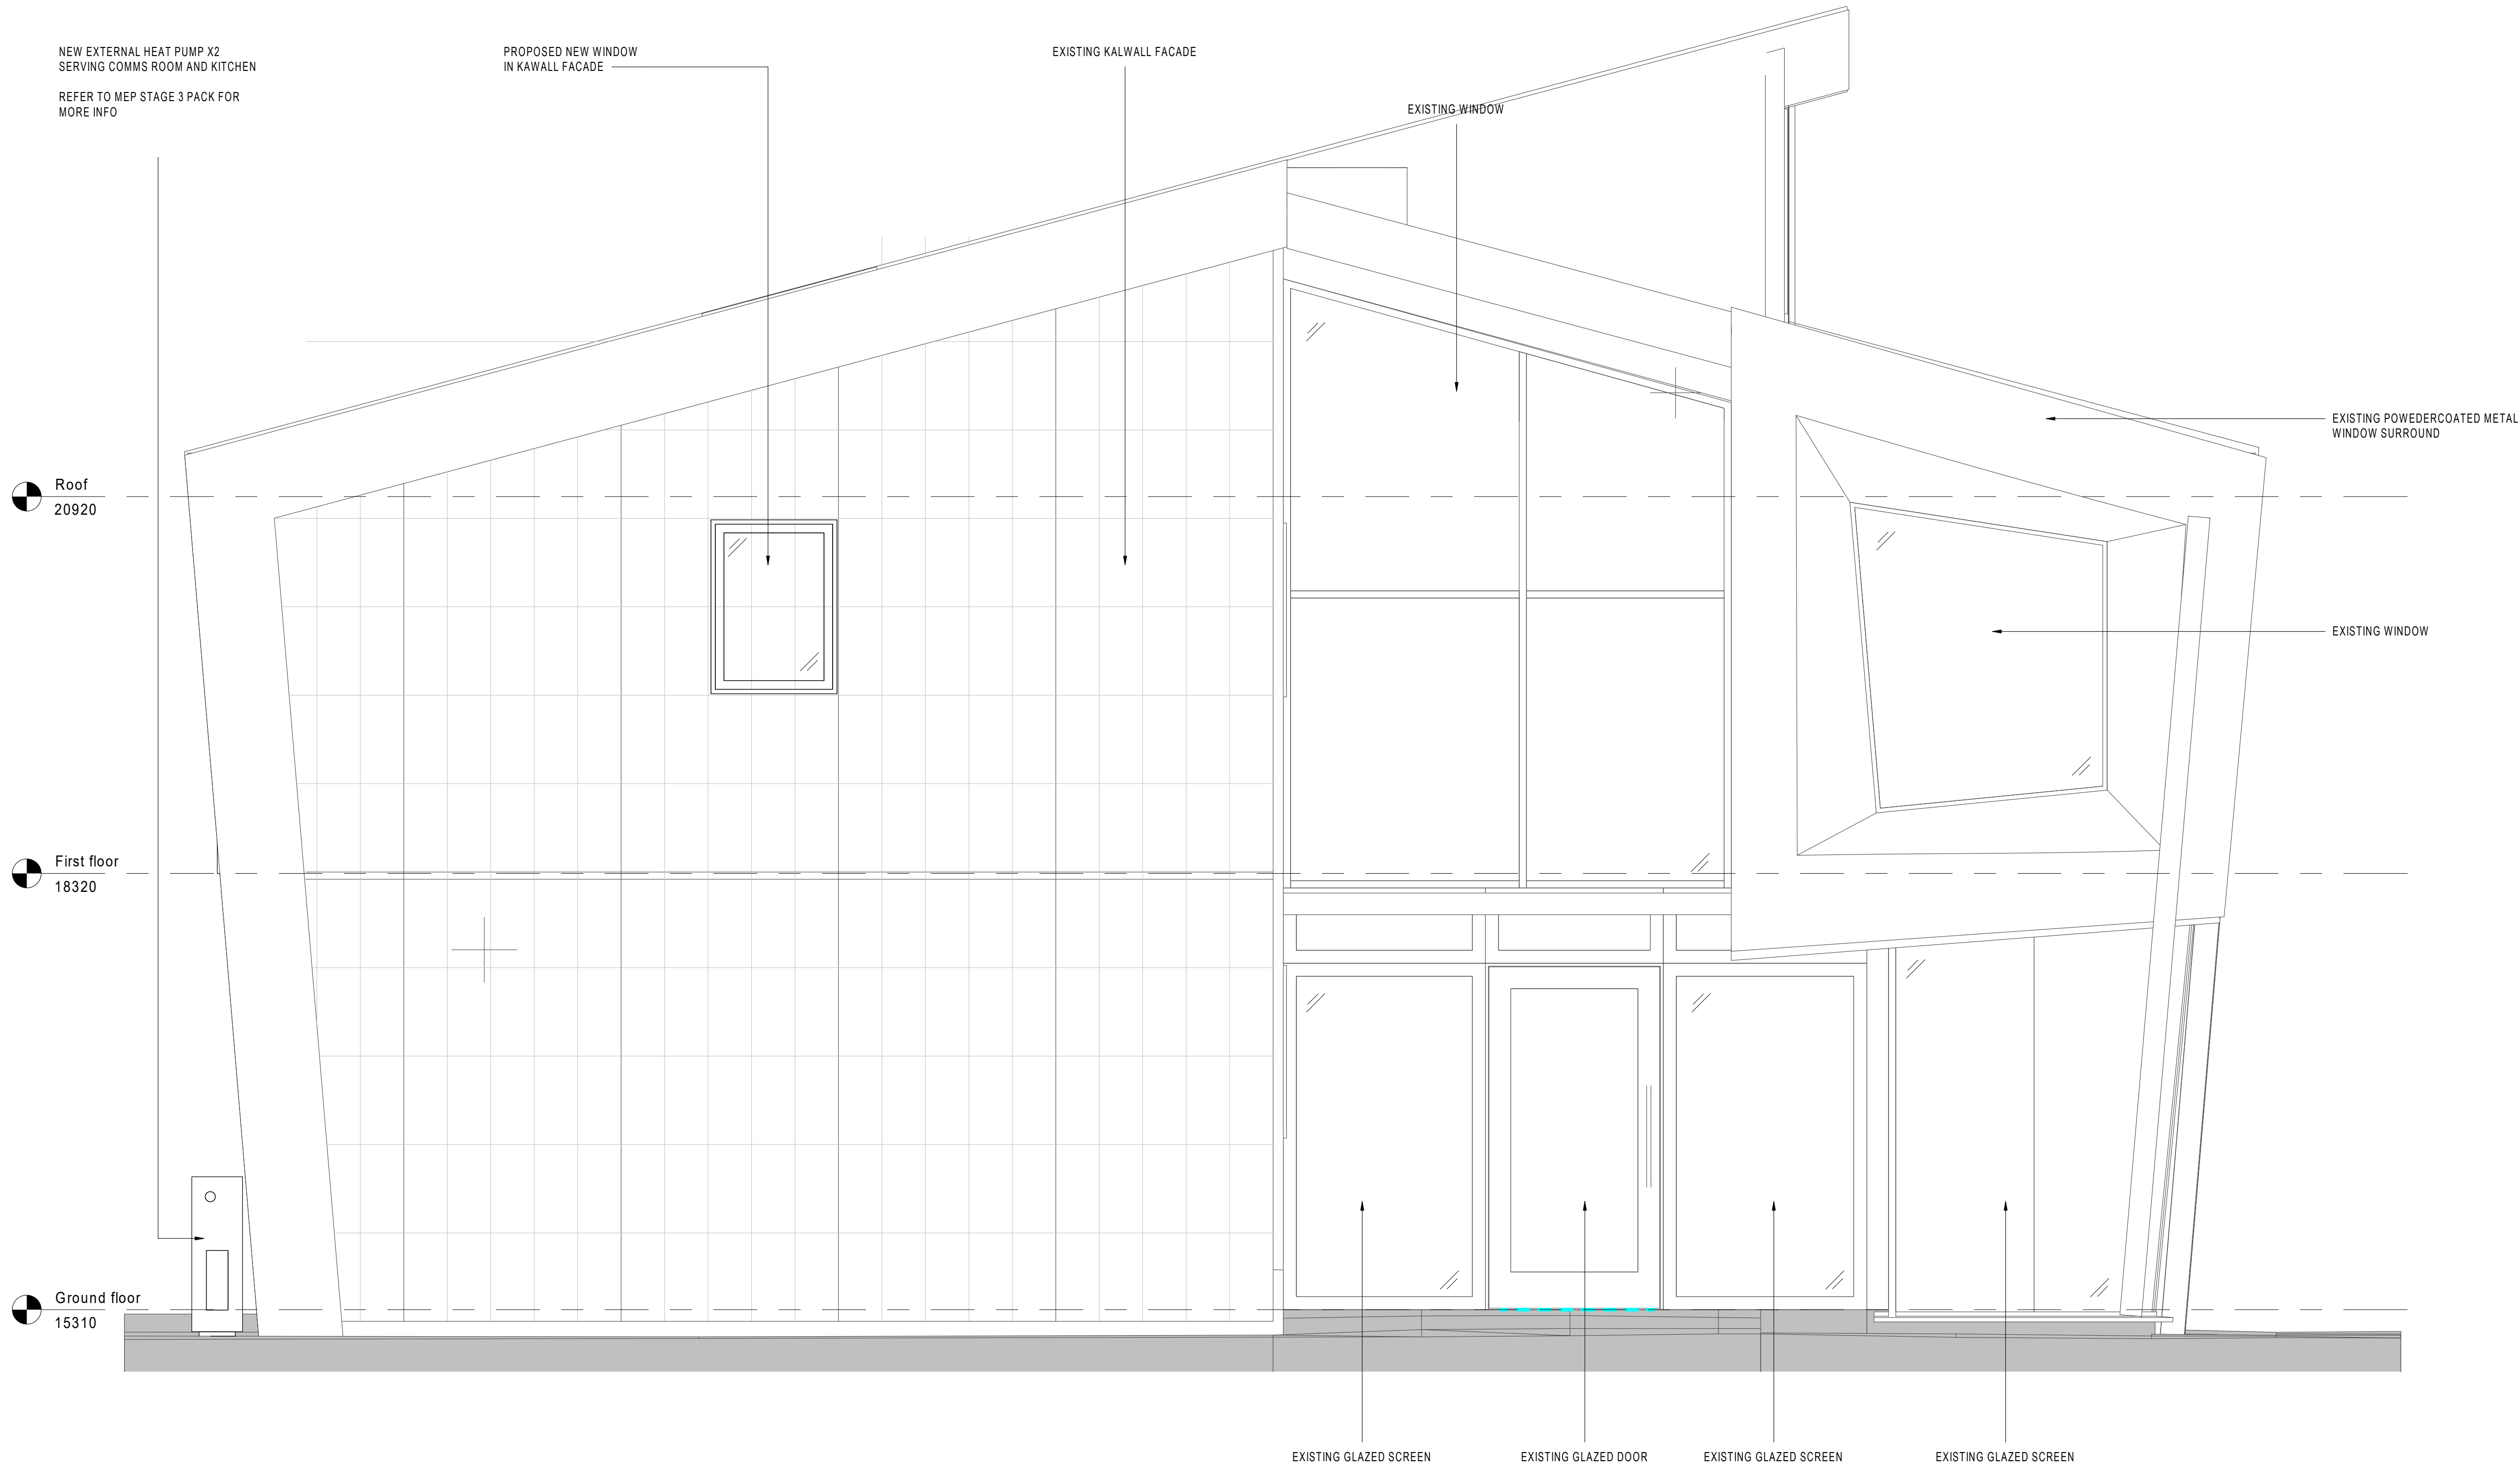

YOUTH SPACE BUILDING KEY



RIBA 3

REVISION	DATE	DESCRIPTION	ARCHITECT	PARTNER
1	09.08.22	Issued to SE for review	LS	ADP
2	07.09.22	STAGE 01 DRAFT ISSUE	LS	ADP
3	21.12.22	DRAFT PLANNING ISSUE	LS	ADP

CHECK ALL DIMENSIONS AND VERIFY ON SITE. REPORT ANY ERRORS OR OMISSIONS

adp

The Fire Station
150 Waterloo Road
London
SE1 8SB
T +44 (0) 20 7089 1720
E london@adp-architecture.com
www.adp-architecture.com

JOB TITLE:
**BRUCE GROVE
YOUTH SPACE**

DRAWING TITLE:
PROPOSED FRONT ELEVATIONS

SCALE: As indicated		DRAWING SHEET SIZE: A1	
JOB CODE: 001550	DRAWING NUMBER: ADP-00-ZZ-DR- A-1205		REVISION: 3

1 PROPOSED FRONT ELEVATION

1 : 25