

 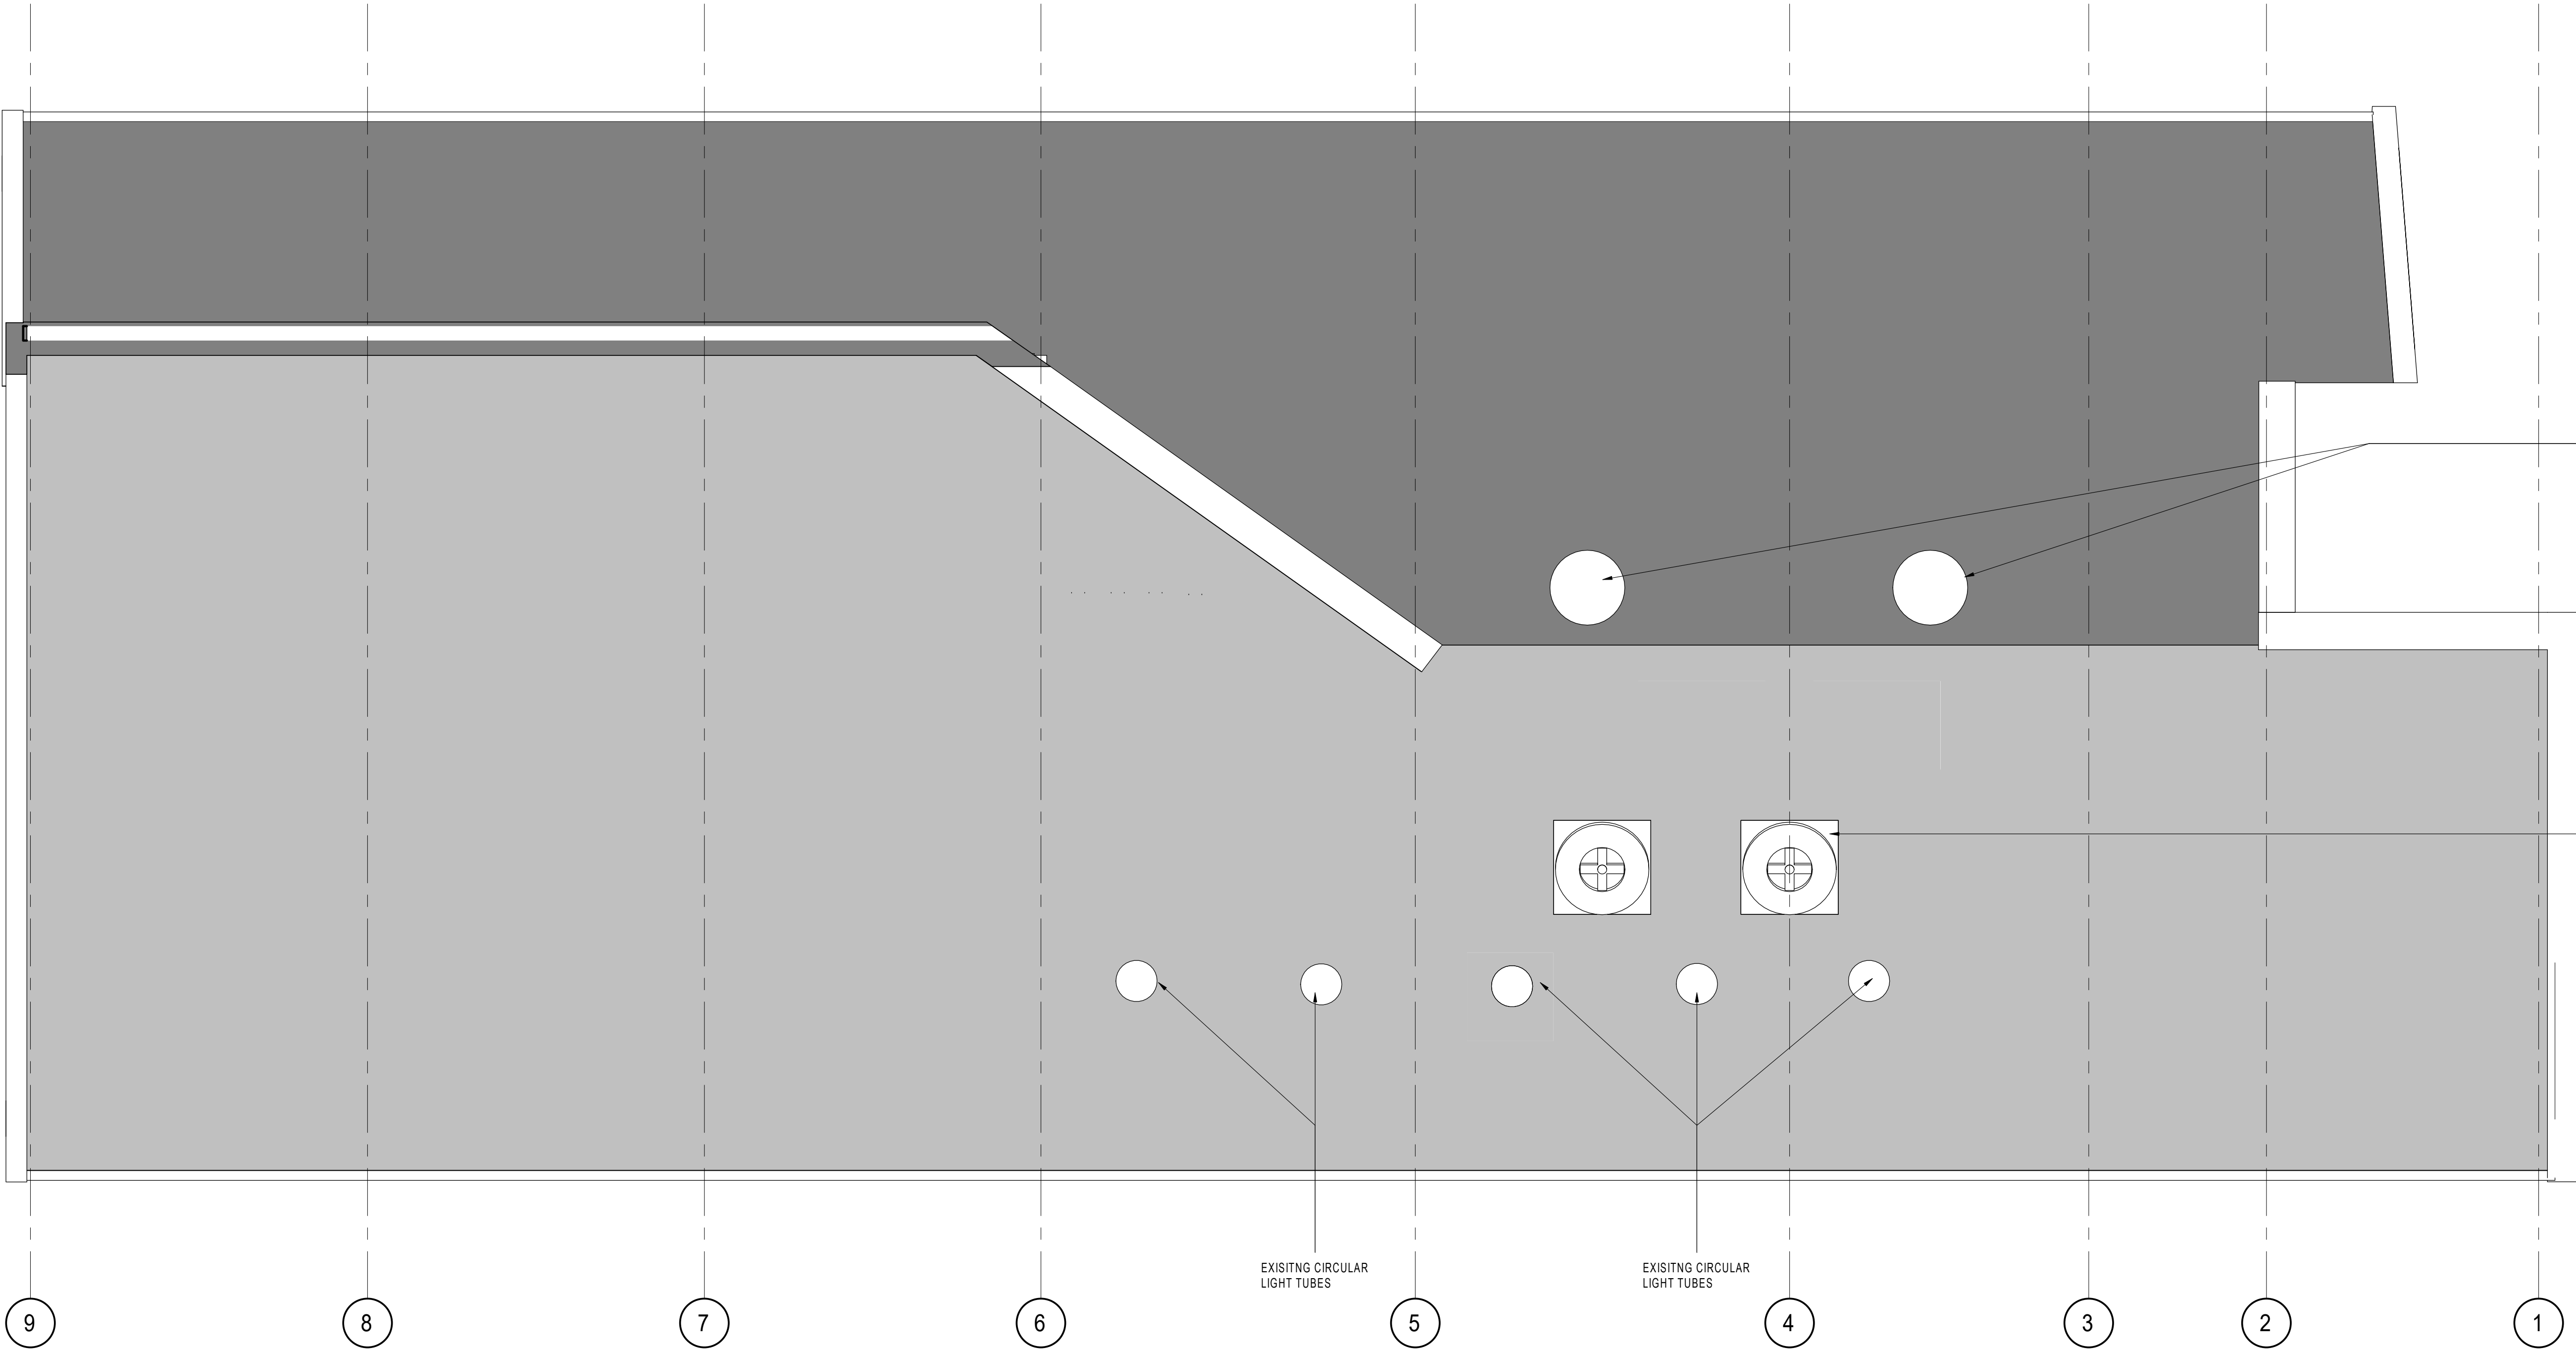


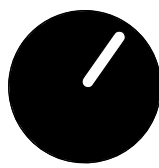

1 EXISTING ROOF PLAN
1 : 50



RIBA 3

REVISION	DATE	DESCRIPTION	ARCHITECT	PARTNER
----------	------	-------------	-----------	---------

CHECK ALL DIMENSIONS AND VERIFY ON SITE. REPORT ANY ERRORS OR OMISSIONS



The Fire Station
150 Waterloo Road
London
SE1 8SB
T +44 (0) 20 7089 1720
E london@adp-architecture.com
www.adp-architecture.com

JOB TITLE:
**BRUCE GROVE
YOUTH SPACE**

DRAWING TITLE:
EXISTING ROOF PLAN

SCALE: 1 : 50	DRAWING SHEET SIZE: A1	
JOB CODE: 001550	DRAWING NUMBER: ADP-00-R1-DR- A-0903	REVISION: