


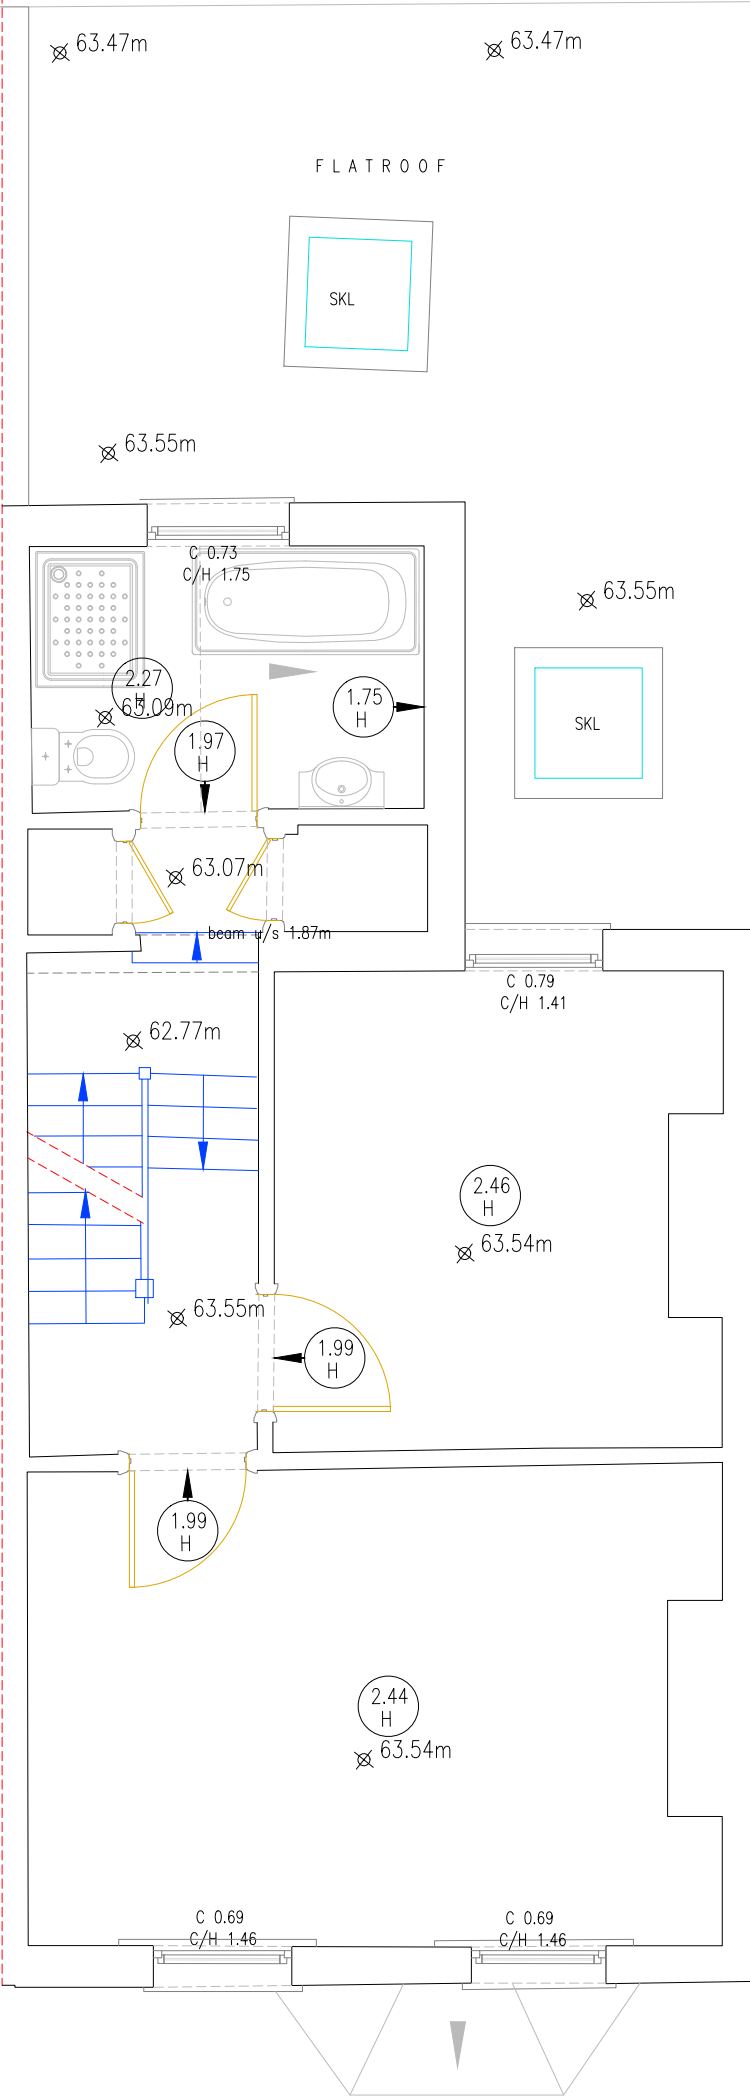

SCALE: 1:50

BUILDING LEGEND			
WINDOW DETAIL HEIGHTS(m)	C	AIR BRICK	AB
FLOOR TO CILL HEIGHT	C/S	AIR CONDITIONING UNIT	ACU
CILL TO HEAD OF WINDOW	C/H	RAIN WATER OUTLET	RWO
ABCH DETAIL HEIGHTS(m)	S	RAIN WATER GUTTER	RWG
FLOOR TO SPRING	H	RAIN WATER PIPE	RWP
FLOOR TO HEAD	H	SOIL VENT PIPE	SVP
		FIRE HYDRANT RISER	FHR
HEIGHT	FL	FLOOR LEVEL	FL
FALS BEAM	SFL	SOFFIT LEVEL	SFL
FALS CEILING	F/B	THRESHOLD LEVEL	THL
	F/C		
SUSPENDED CEILING	S/C	UP ARROW	↑
SLOPE UP	S/UP	HEIGHT (m)	1.23
UNDERROSE	U/S		H
CUPBOARD	CBD		
SKYLIGHT	SKL		

NOTES	
GRID	THE SURVEY GRID IS BASED ON LOCAL COORDINATES
LEVELING	ALL LEVELS ARE BASED ON LOCAL DATUM
DRAINAGE	INVERT LEVELS, PIPE SIZES AND PIPE CONNECTIONS HAVE BEEN SURVEYED BY VISUAL INSPECTION ONLY AND THEREFORE THE COMPLETE ACCURACY OF THIS INFORMATION CANNOT BE GUARANTEED
COPYRIGHT: This drawing is copyright and may not be altered reproduced or used without the written permission of icelabz.	

01	First Visit	SV	14/04/2023
REV	DESCRIPTION	Surveyor	SURVEY DATE
01		PV	BR 21/04/23
REV	DESCRIPTION	DRAWN	APPR DATE

**ICELABZ**

Tel No: 02037443020
www.icelabz.co.uk

Fax No: 02089316849
info@icelabz.co.uk

LAND SURVEYING MEASURED BUILDING SURVEY SETTING OUT

PROJECT TITLE 9, Bruce Castle Road, Tottenham, London, Haringey, N17 8NL			
DRAWING DETAIL First Floor Plan			
CLIENT Soaring Heights Care Ltd			Scale 1:50
Page Size A3	Checked YR	Approved YR	INFORMATION FINAL
Drawing Number MB-SURV-BCR-1F-001	Rev 01	Date 21/04/2023	