


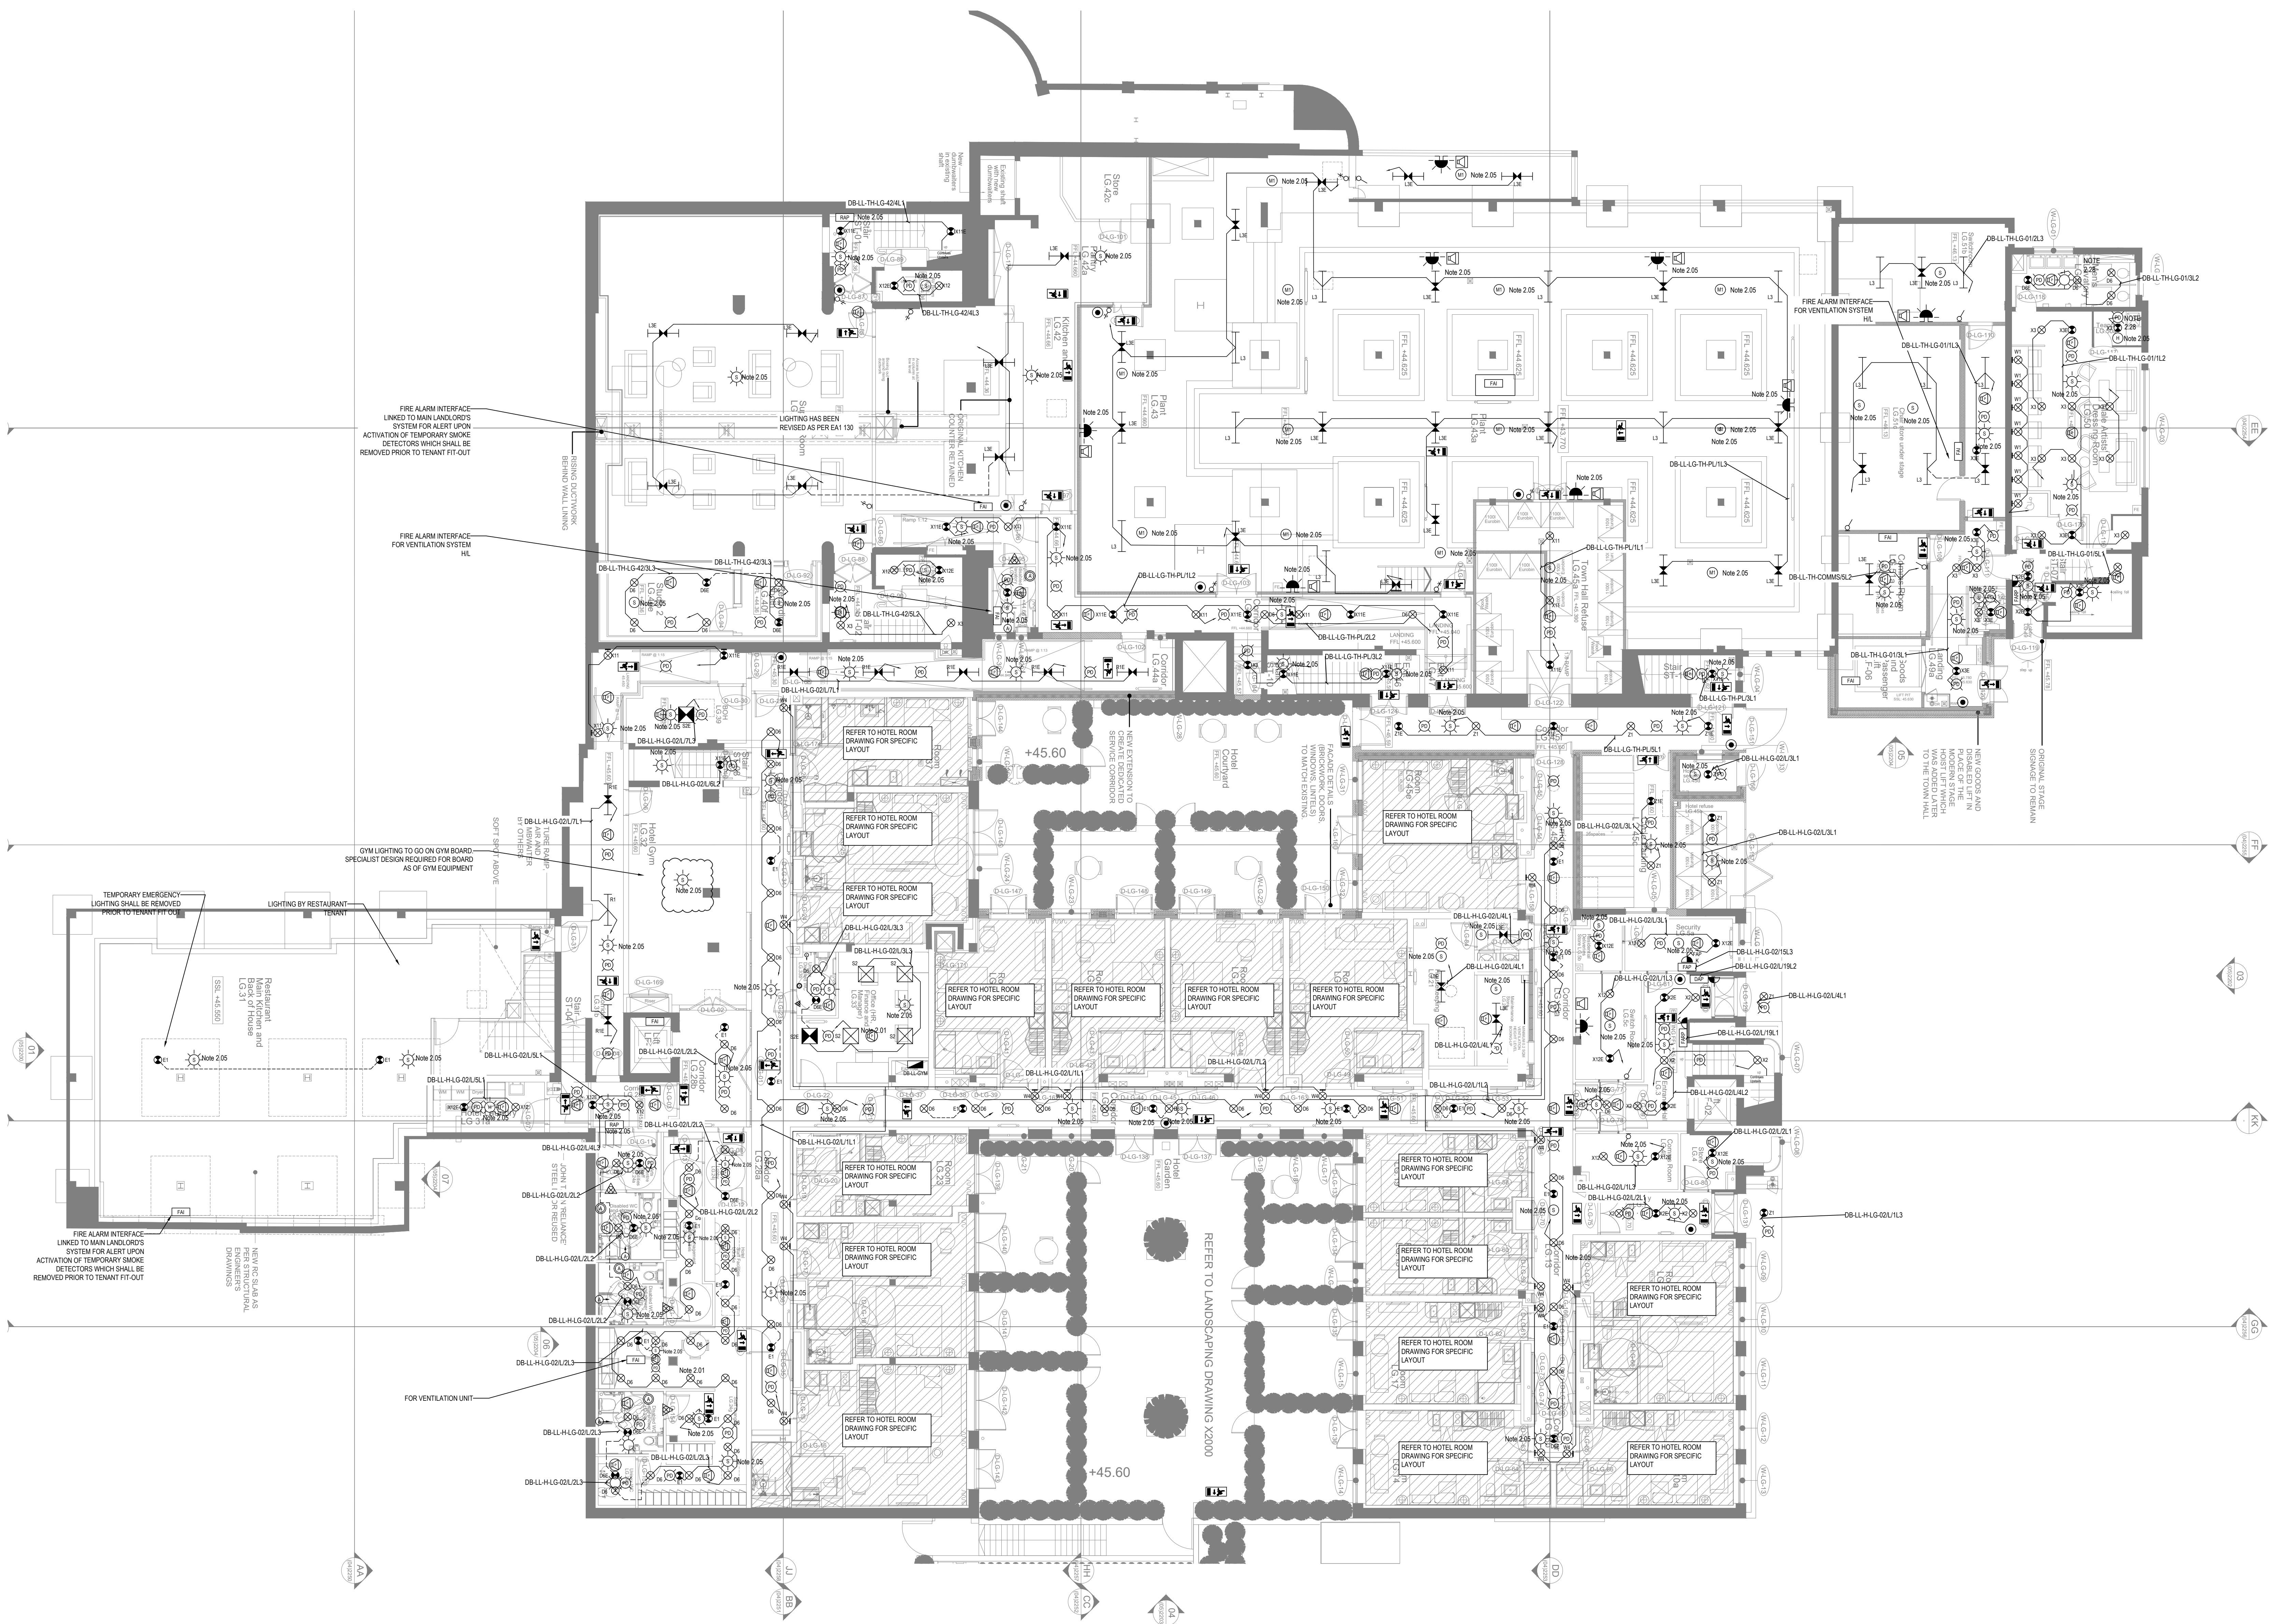

Copyright © Design and Patents Inc 1988

The copyright & design right of the design documents & of the design remains that of Whitecode Ltd. All copies are only for information about the application. They may not be used for any other purpose or copied without the express written permission of Whitecode Ltd.

Notice of Information

It shall remain the responsibility of the Installer/Contractor to ensure that there are no conflicts with information provided by themselves & that of any manufacturers information or relevant requirements of statutory bodies or client specifications/Er's. If any conflicts do exist it is the responsibility of the Installer/Contractor to inform The Consultant/Client immediately Verbally & in writing.

BUYERS are warned that this is a working drawing and is not intended to be treated as descriptive material describing in relation to any descriptive material describing, in relation to any descriptive material property or development, any of the specific Matters prescribed by an Order made under the above Act. The contents of this drawing may be subject to change at any time and alterations and variations can occur during the progress of the works without revision of the drawing. Consequently the layout, form, contents & dimensions of the finished construction may differ materially from those shown. Nor do the contents of this drawing constitute a contract, part of any contract or a warranty.

General Electrical Note

- Mechanical services shown for coordination purposes only. Refer to mechanical drawings for mechanical services information.
- Before commencing work on site, please read Design Risk Management Information. All manufacturer's instructions to be observed prior to installation.
- All electrical installers shall be carried out in accordance with BS 7671. This drawing shall be used in conjunction with the electrical symbols legend & typical mounting heights drawings.
- Where electrical boxes, conduits, trunking, pattresses or luminaires penetrate floors, walls, roofs, ceilings or other partitions, they must be suitably fixed in order to avoid the spread of fire through the electrical system, as per section 527.2 of BS 7671: Approved Document B.
- Dimensioned setting out details to be confirmed by architect.
- All discrepancies are to be queried with WDA before works commence.
- Electrical contractor to allow for supply and install of power assisted doors.

Electrical Installation Notes

0.01 All switches and sockets must be installed at least 300mm from internal room corners to meet the requirements of Lifetime Homes, 150mm from beds and 300mm from sink basin to comply with BS7671.

2. Common Area Notes

- [illegible]

NOTE : B
SERVICE VOIDS TO BE SURVEYED ON
PROCUREMENT AND INSTALLATION T
CAN BE UNOBSTRUCTED IN SPACE

NOTE: A
DRAWING IS CONSTRUCTION ISSUE PROVISIONALLY ONLY
EAST WING IS CURRENTLY THE ONLY AREA THAT HAS BEEN
FULLY COORDINATED AND DETAILED WITH DESIGN TEAM.

BACKGROUND PLAN AS PER: KDS ARCHITECTS		
DRAWING No: 3670-KDS-TH-LG-DR-A-03-1999	REVISION: C5	DATE RECEIVED: 31.10.2022

14.12.2022	Smoke alarm added to gym	IV	JM	
22.06.2022	Lighting updated to comments. Fire signs updated to fire strategy drawings	IV	JM	
02.06.2022	Comments added	IV	JM	
11.05.2022	Lighting updated	IV	JM	
22.01.2021	Consultation Issue	IV	JM	
09.12.2020	Consultation Issue	IV	JM	
13.11.2020	Preliminary Issue	IV	JM	
21.09.2020	Preliminary Issue	IV	JM	
Rev	Date	Description	Drawn	Checked

Current purpose:	CONSTRUCTION	Scale: 1:100	Size: A0
Original Issue Date:	21.09.2020	Drawn: IV	Chkd: JM



HITECODE
CONSULTING

**BUILDING SERVICES DESIGN
CONSULTANTS**
26-27 The Hill, Northfleet, Gravesend
Kent, DA11 9EU
www.whitecode.co.uk
T: 01322 285977 E: design@whitecode.co.uk

ELECTRICAL SERVICES LAYOUT
TOWN HALL
LOWER GROUND FLOOR

HORNSEY TOWN HALL

Client:	ARDMORE	Rev:	C6
Draw Number:			

Responses to LIP Comments 23/05/2022

1. It is assumed that all services are coordinated with architectural and structural layouts >Noted
2. It is assumed that this drawing complies with the EPG and any deviations are highlighted. >Noted
3. Layout does not incorporate the instruction for the Laundry room - initial Architectural & MEP RCP and detail notes are to be added to capture this change. - The luminaires schedule has been designed to reflect this change
4. Luminaires X1 and X4 do not appear on Luminaires schedule : The Luminaires schedule has been designed to reflect this change
5. Please provide lux level calculations : To be provided
6. Confirm DO lighting can be accommodated within ceiling void : Yes
7. Supper room lighting layout does not appear to incorporate detail instruction : Initial architectural RCP and detail notes are to be added to capture this change
8. Please provide dimensions setting out for each component : To be incorporated on architectural RCPs
9. Please include lighting control wiring diagrams : Please refer to manufacturer data sheets
10. Show where exposed conduit is used to light switches : To be shown on an off drawing
11. Confirm installation proposal where fixing to steel purlins : Contractor to confirm