


SITE LOCATION


 


Reproduced by permission of Ordnance Survey on behalf of the Controller of Her Majesty's Stationary Office
All rights reserved. © Crown Copyright licence no. 100062043

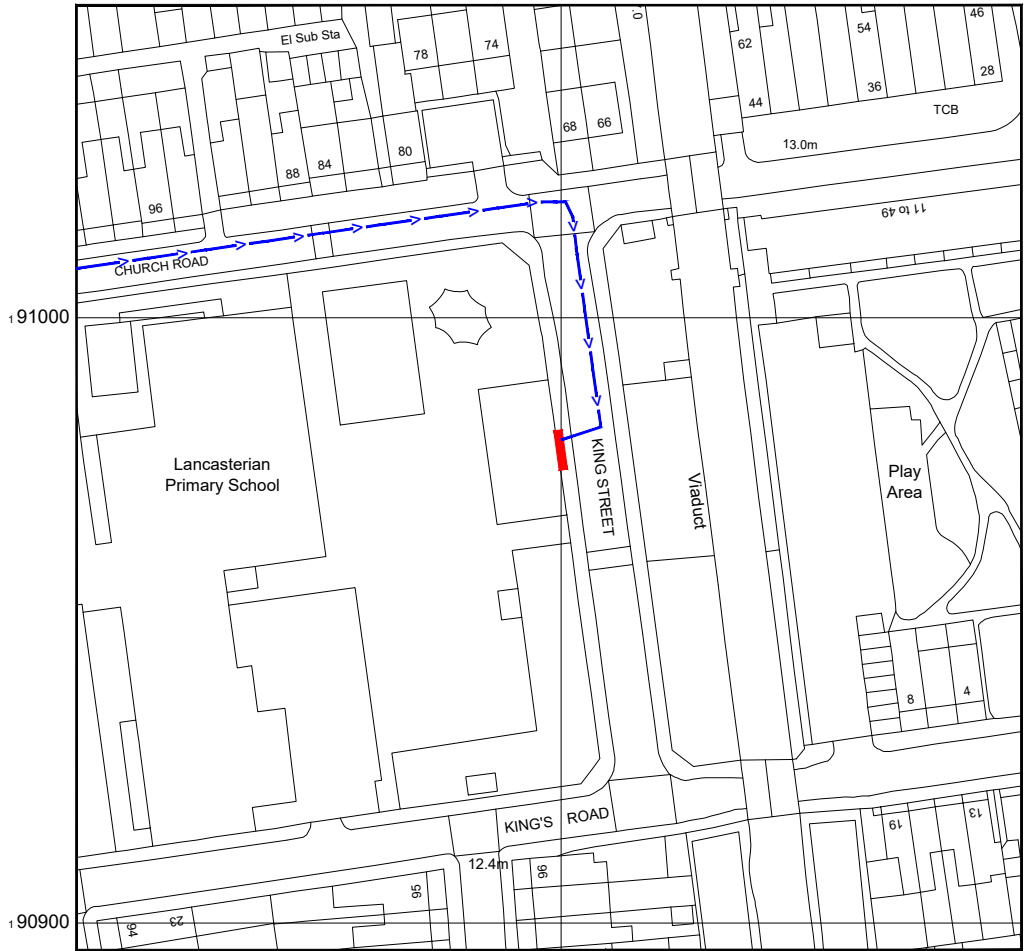


Reproduced by permission of Ordnance Survey on behalf of the Controller of Her Majesty's Stationary Office
All rights reserved. © Crown Copyright licence no. 100062043

SITE AREA PLAN

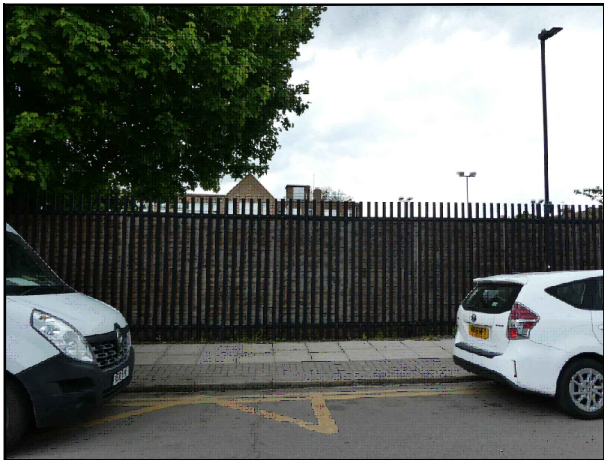

SITE PHOTOGRAPH

 SITE LOCATION PLAN



GOOGLE MAPS QR CODE

GOOGLE MAPS - <https://goo.gl/maps/X2V31EjUUEFFv6HY8>

GOOGLE STREETVIEW - <https://goo.gl/maps/WtPWPxWVnQRrGQo37>

NOTES:

1. ALL DIMENSIONS IN MM UNLESS OTHERWISE NOTED.

DIRECTIONS TO SITE:

Head west on M25. At junction 25, take the A10 exit to London N/London C/Enfield/Hertford. At Waltham Cross Interchange, take the 1st exit onto Great Cambridge Rd/A10. Continue straight to stay on Great Cambridge Rd/A10. At the roundabout, take the 2nd exit and stay on Great Cambridge Rd/A10. Turn left onto All Hallows Rd. Turn left onto Church Ln. Turn right onto Church Rd. Turn right onto King St. Follow King St and site location is on the left hand side.

Site Provider's
Property Boundary:



Access Route To Site:



Access Route:



Master:	MBNL / EE:	Project:	Purpose of Issue:	Issue:
M001	MBNL	3UK DNSW	Planning	A
Date:	15/05/2023	Revision / Upgrade Description:		
Drawn:	CDN	First Issue - Site nomination dated: TBC		
Checked:	DH			
Approved:	SD			

CK Hutchison
Networks (UK)
Limited

Green Park
450 Longwater Avenue
Reading
RG30 3UR

Design Consultant & Principal Contractor:



WHP Telecoms

Unit 1 Maple Park,
Low Fields Avenue, Leeds
LS12 6HH

Tel: 01133023550
e-mail: info@whptelecoms.com

Site Name:
KING STREET STREETWORKS

Site ID:
HGY22126

Address:
KING STREET, TOTTENHAM,
LONDON BOROUGH OF HARINGEY,
LONDON, GREATER LONDON, ENGLAND,
N17 8NN

Title:
002 SITE LOCATION PLAN

Project:
3UK DNSW

Purpose of Issue:
PLANNING


EE Cell ID:	MBNL Cell ID:	Cell ID:
TBC	HGY197	N1172

Master Drawing No:	Issue:
HGY22126_M001	A





 EXISTING SITE PLAN



- NOTES:
1. ALL DIMENSIONS IN MM UNLESS OTHERWISE NOTED.

Master:	MBNL / EE:	Project:	Purpose of Issue:	Issue:
M001	MBNL	3UK DNSW	Planning	A
Date:	15/05/2023	Revision / Upgrade Description:		
Drawn:	CDN	First Issue - Site nomination dated: TBC		
Checked:	DH			
Approved:	SD			

**CK Hutchison
Networks (UK)
Limited**

Green Park
450 Longwater Avenue
Reading
RG30 3UR

Design Consultant & Principal Contractor:



WHP Telecoms
Unit 1 Maple Park,
Low Fields Avenue, Leeds
LS12 6HH

Tel: 01133023550
e-mail: info@whptelecoms.com

Site Name:
KING STREET STREETWORKS

Site ID:
HGY22126

Address:
**KING STREET, TOTTENHAM,
LONDON BOROUGH OF HARINGEY,
LONDON, GREATER LONDON, ENGLAND,
N17 8NN**




Title:
100 EXISTING SITE PLAN

Project:
3UK DNSW

Purpose of Issue:
PLANNING

EE Cell ID:	MBNL Cell ID:	Cell ID:
TBC	HGY197	N1172
Master Drawing No:		
HGY22126_M001		
Issue:		
A		



 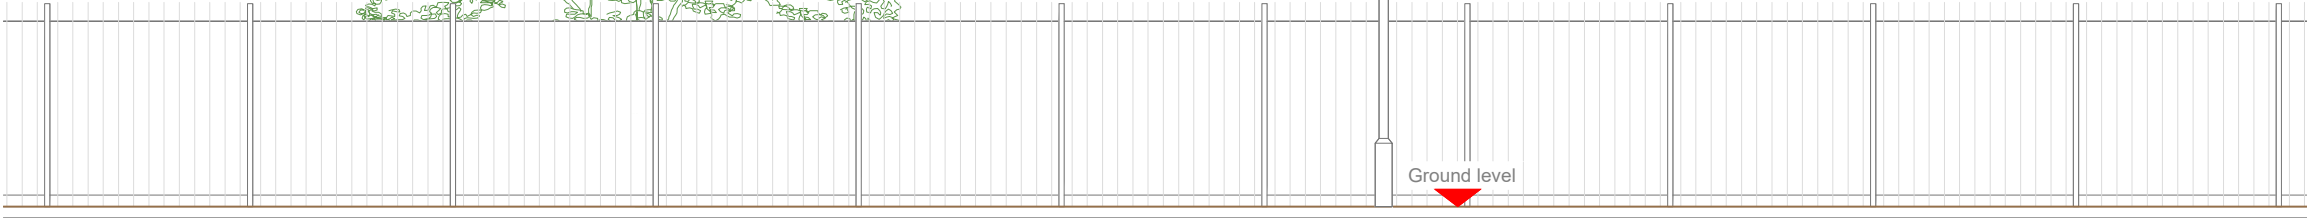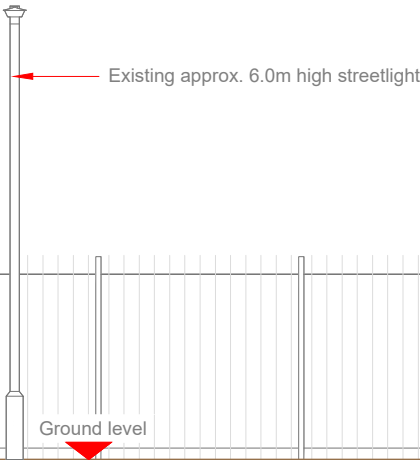

- NOTES:
1. ALL DIMENSIONS IN MM UNLESS OTHERWISE NOTED.

Master:	MBNL / EE:	Project:	Purpose of Issue:	Issue:
M001	MBNL	3UK DNSW	Planning	A
Date:	15/05/2023	Revision / Upgrade Description:		
Drawn:	CDN	First Issue - Site nomination dated: TBC		
Checked:	DH			
Approved:	SD			

CK Hutchison
Networks (UK)
Limited
Green Park
450 Longwater Avenue
Reading
RG30 3UR



Design Consultant & Principal Contractor:

WHP Telecoms
Unit 1 Maple Park,
Low Fields Avenue, Leeds
LS12 6HH

Tel: 01133023550
e-mail: info@whptelecoms.com

Site Name:				KING STREET STREETWORKS			
Site ID:				HGY22126			
Address:				KING STREET, TOTTENHAM, LONDON BOROUGH OF HARINGEY, LONDON, GREATER LONDON, ENGLAND, N17 8NN			
Title:				150 EXISTING ELEVATION A			
Project:				3UK DNSW			
Purpose of Issue:				PLANNING			
EE Cell ID: TBC		MBNL Cell ID: HGY197		Cell ID: N1172			
Master Drawing No:						Issue:	
HGY22126_M001						A	



Antenna Aperture ID	Proposed 4G/5G Bearing
A1	0°
A2	0°
B1	120°
B2	120°
C1	240°
C2	240°


NOTES:

1. ALL DIMENSIONS IN MM UNLESS OTHERWISE NOTED.


100mm

50mm

10mm

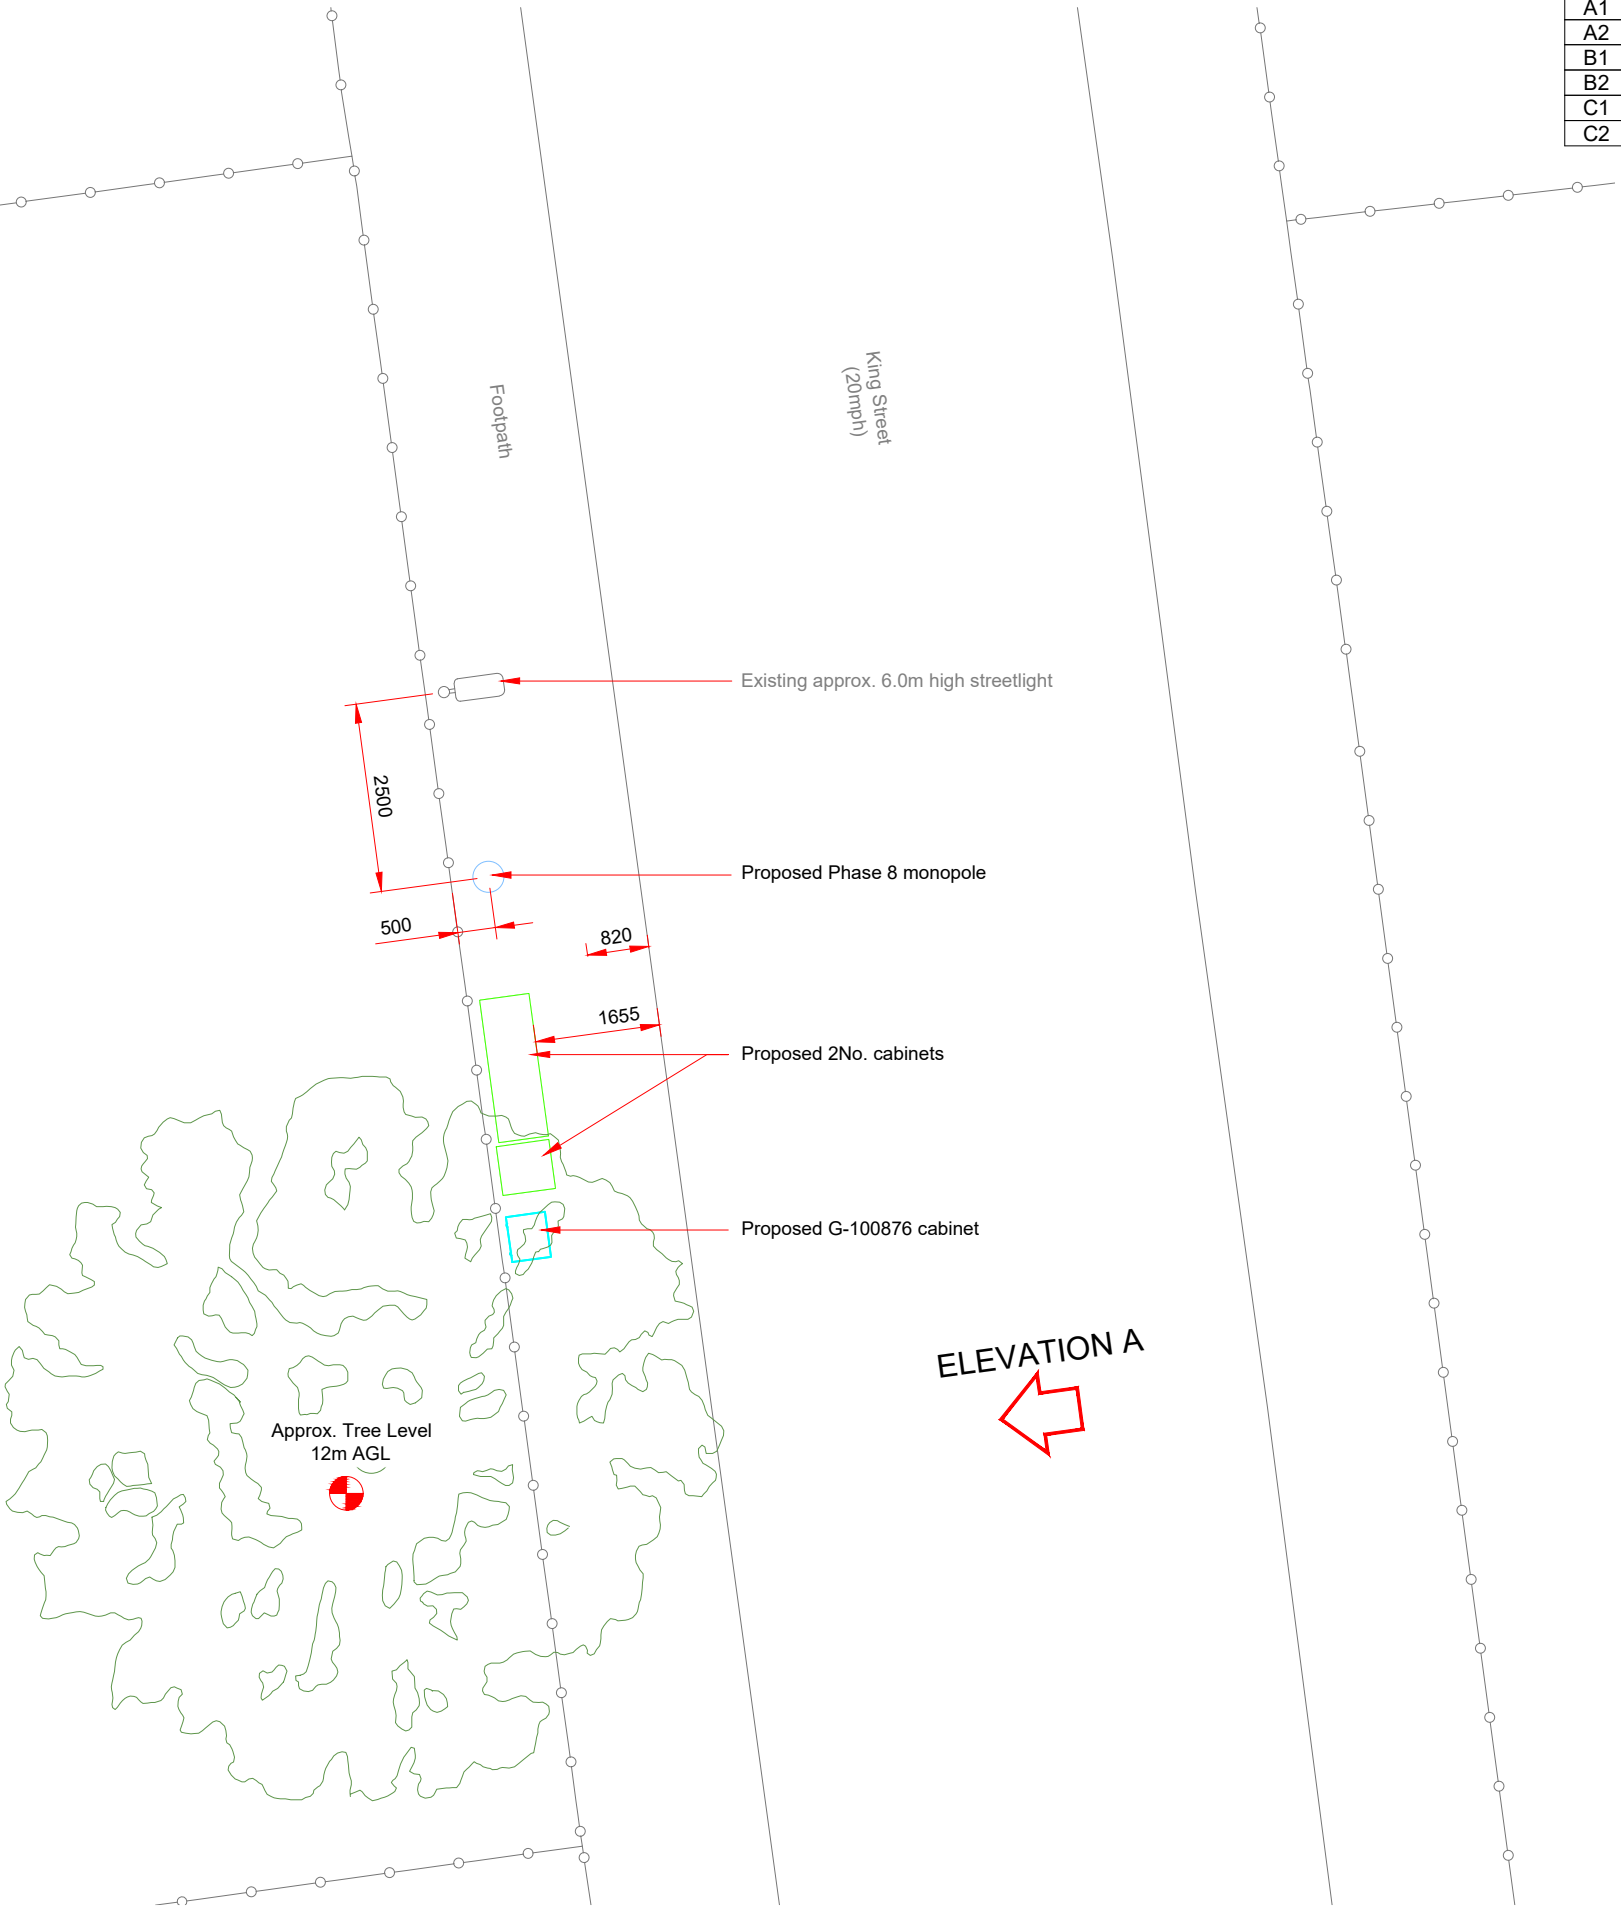

PROPOSED SITE PLAN

 

ELEVATION A

Master:	MBNL / EE:	Project:	Purpose of Issue:	Issue:
M001	MBNL	3UK DNSW	Planning	A
Date:	15/05/2023	Revision / Upgrade Description:		
Drawn:	CDN	First Issue - Site nomination dated: TBC		
Checked:	DH			
Approved:	SD			

CK Hutchison Networks (UK) Limited

Green Park
450 Longwater Avenue
Reading
RG30 3UR

Design Consultant & Principal Contractor:




WHP Telecoms
Unit 1 Maple Park,
Low Fields Avenue, Leeds
LS12 6HH

Tel: 01133023550
e-mail: info@whptelecoms.com

Site Name:				KING STREET STREETWORKS			
Site ID:				HGY22126			
Address:				KING STREET, TOTTENHAM, LONDON BOROUGH OF HARINGEY, LONDON, GREATER LONDON, ENGLAND, N17 8NN			
Title:				210 PROPOSED SITE PLAN			
Project:				3UK DNSW			
Purpose of Issue:				PLANNING			
EE Cell ID:		MBNL Cell ID:		Cell ID:			
TBC		HGY197		N1172			
Master Drawing No:						Issue:	
HGY22126_M001						A	



100mm
50mm
10mm

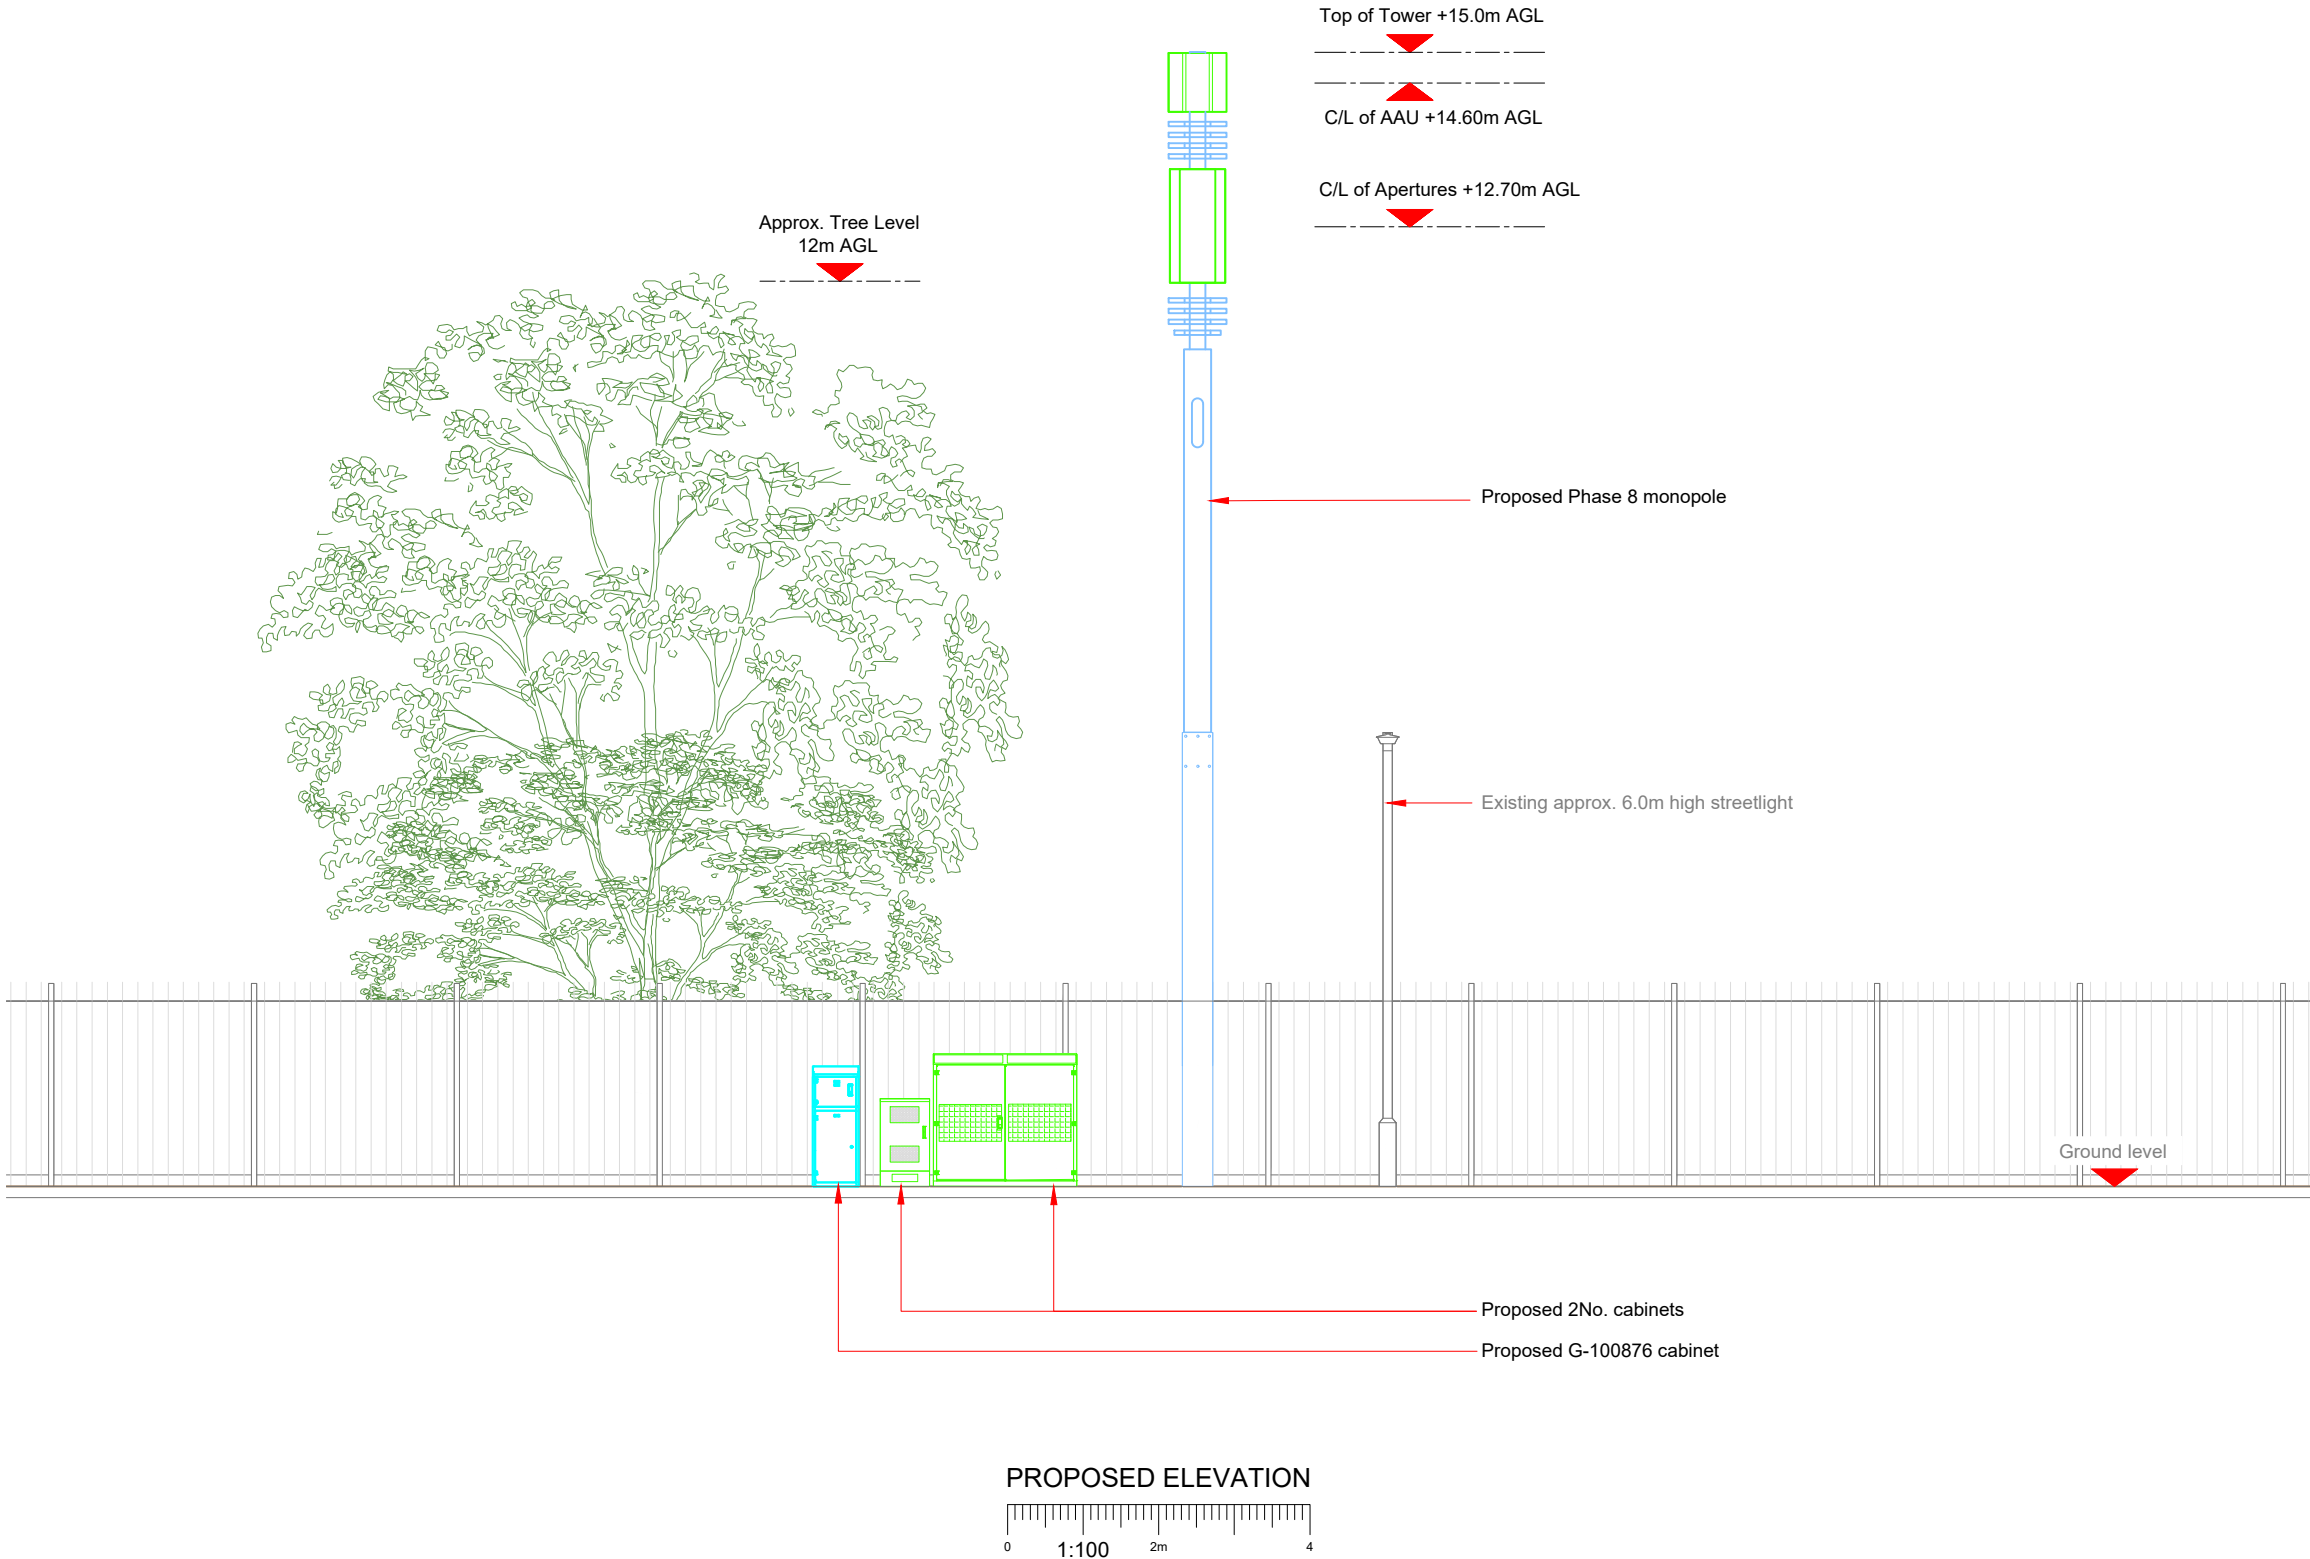

Antenna Aperture ID	Proposed 4G/5G Bearing
A1	0°
A2	0°
B1	120°
B2	120°
C1	240°
C2	240°

NOTES:
1. ALL DIMENSIONS IN MM UNLESS OTHERWISE NOTED.

Master:	MBNL / EE:	Project:	Purpose of Issue:	Issue:
M001	MBNL	3UK DNSW	Planning	A
Date:	15/05/2023	Revision / Upgrade Description:		
Drawn:	CDN	First Issue - Site nomination dated: TBC		
Checked:	DH			
Approved:	SD			

CK Hutchison Networks (UK) Limited

Green Park
450 Longwater Avenue
Reading
RG30 3UR

Design Consultant & Principal Contractor:



WHP Telecoms
Unit 1 Maple Park,
Low Fields Avenue, Leeds
LS12 6HH

Tel: 01133023550
e-mail: info@whptelecoms.com

Site Name:
KING STREET STREETWORKS

Site ID:
HGY22126

Address:
KING STREET, TOTTENHAM,
LONDON BOROUGH OF HARINGEY,
LONDON, GREATER LONDON, ENGLAND,
N17 8NN

Title:
260 PROPOSED ELEVATION

Project:
3UK DNSW

Purpose of Issue:
PLANNING

EE Cell ID: TBC	MBNL Cell ID: HGY197	Cell ID: N1172
--------------------	-------------------------	-------------------

Master Drawing No: HGY22126_M001	Issue: A
-------------------------------------	-------------