


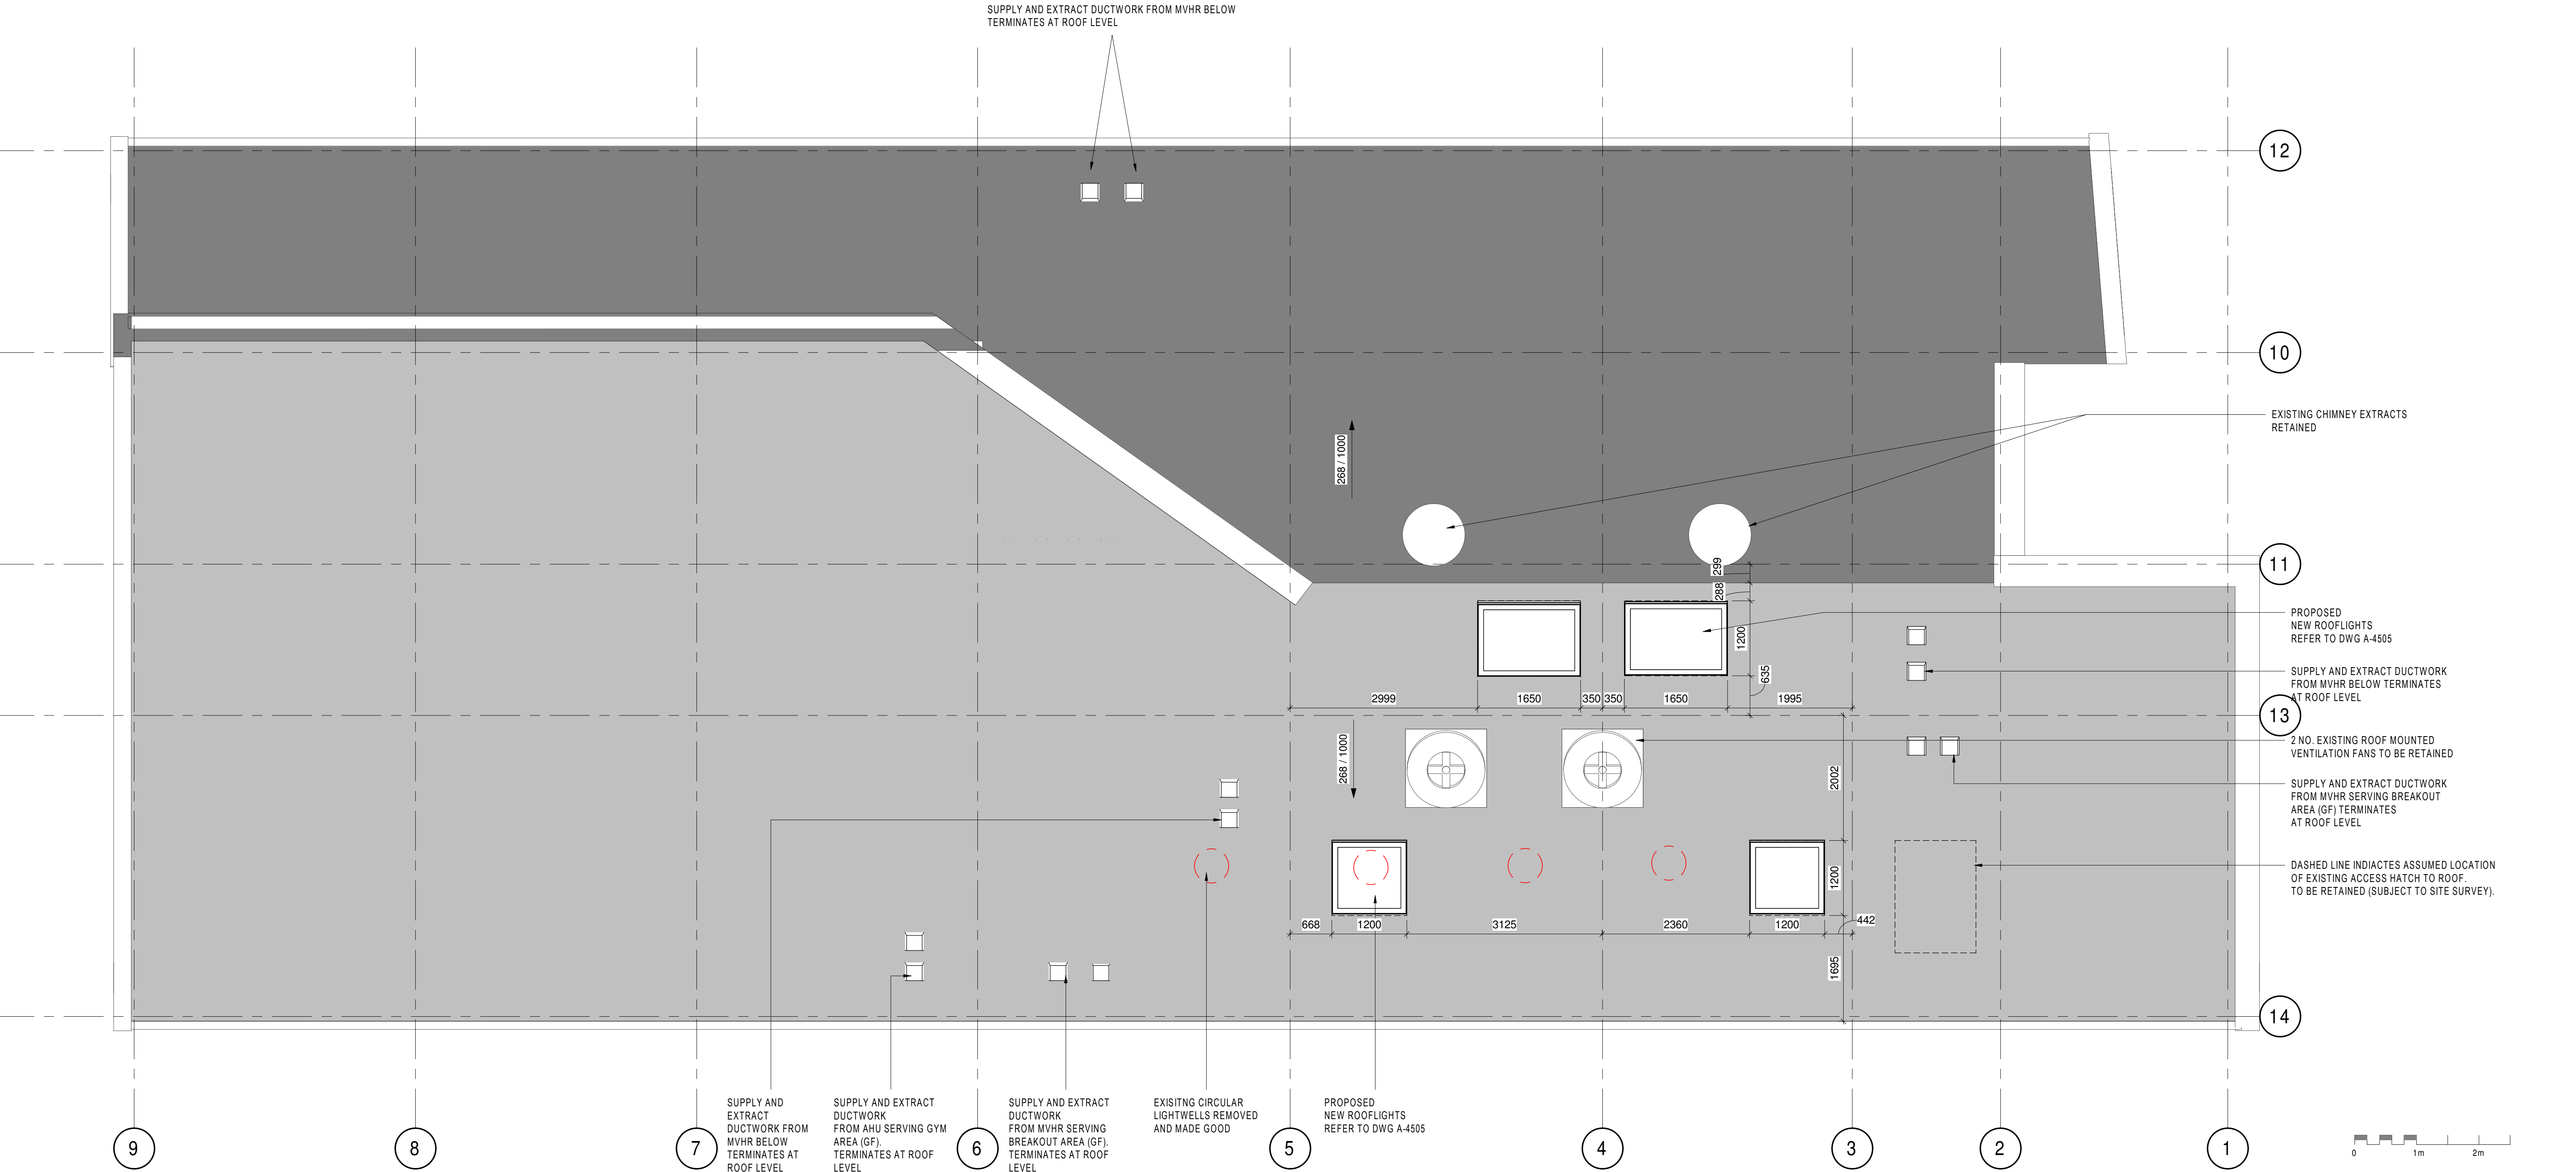

1 PROPOSED ROOF - PLAN
1 : 50

- NOTE:**
- REFER TO MEP DRAWINGS FOR DETAILED MECHANICAL EQUIPMENT INFORMATION
 - REFER TO MEP DRAWINGS/RISK REGISTER FOR ACCESS AND MAINTENANCE REQUIREMENTS

RIBA 4				
REVISION	DATE	DESCRIPTION	ARCHITECT	PARTNER
1	07.08.22	STAGE 03 DRAFT ISSUE	LS	ADP
2	13.01.23	PLANNING ISSUE	LS	ADP
3	16.01.23	STAGE 3 ISSUE	LS	ADP
4	02.06.23	STAGE 4 ISSUE	LS	ADP

CHECK ALL DIMENSIONS AND VERIFY ON SITE. REPORT ANY ERRORS OR OMISSIONS

The Fire Station

150 Waterloo Road

London

SE1 8SB

T +44 (0) 20 7089 1720

E london@adp-architecture.com

www.adp-architecture.com

JOB TITLE: BRUCE GROVE YOUTH SPACE			
DRAWING TITLE: PROPOSED ROOF PLAN			
SCALE: 1 : 50		DRAWING SHEET SIZE: A1	
JOB CODE: 001550	DRAWING NUMBER: ADP-00-R1-DR- A-1052	REVISION: 4	