
 


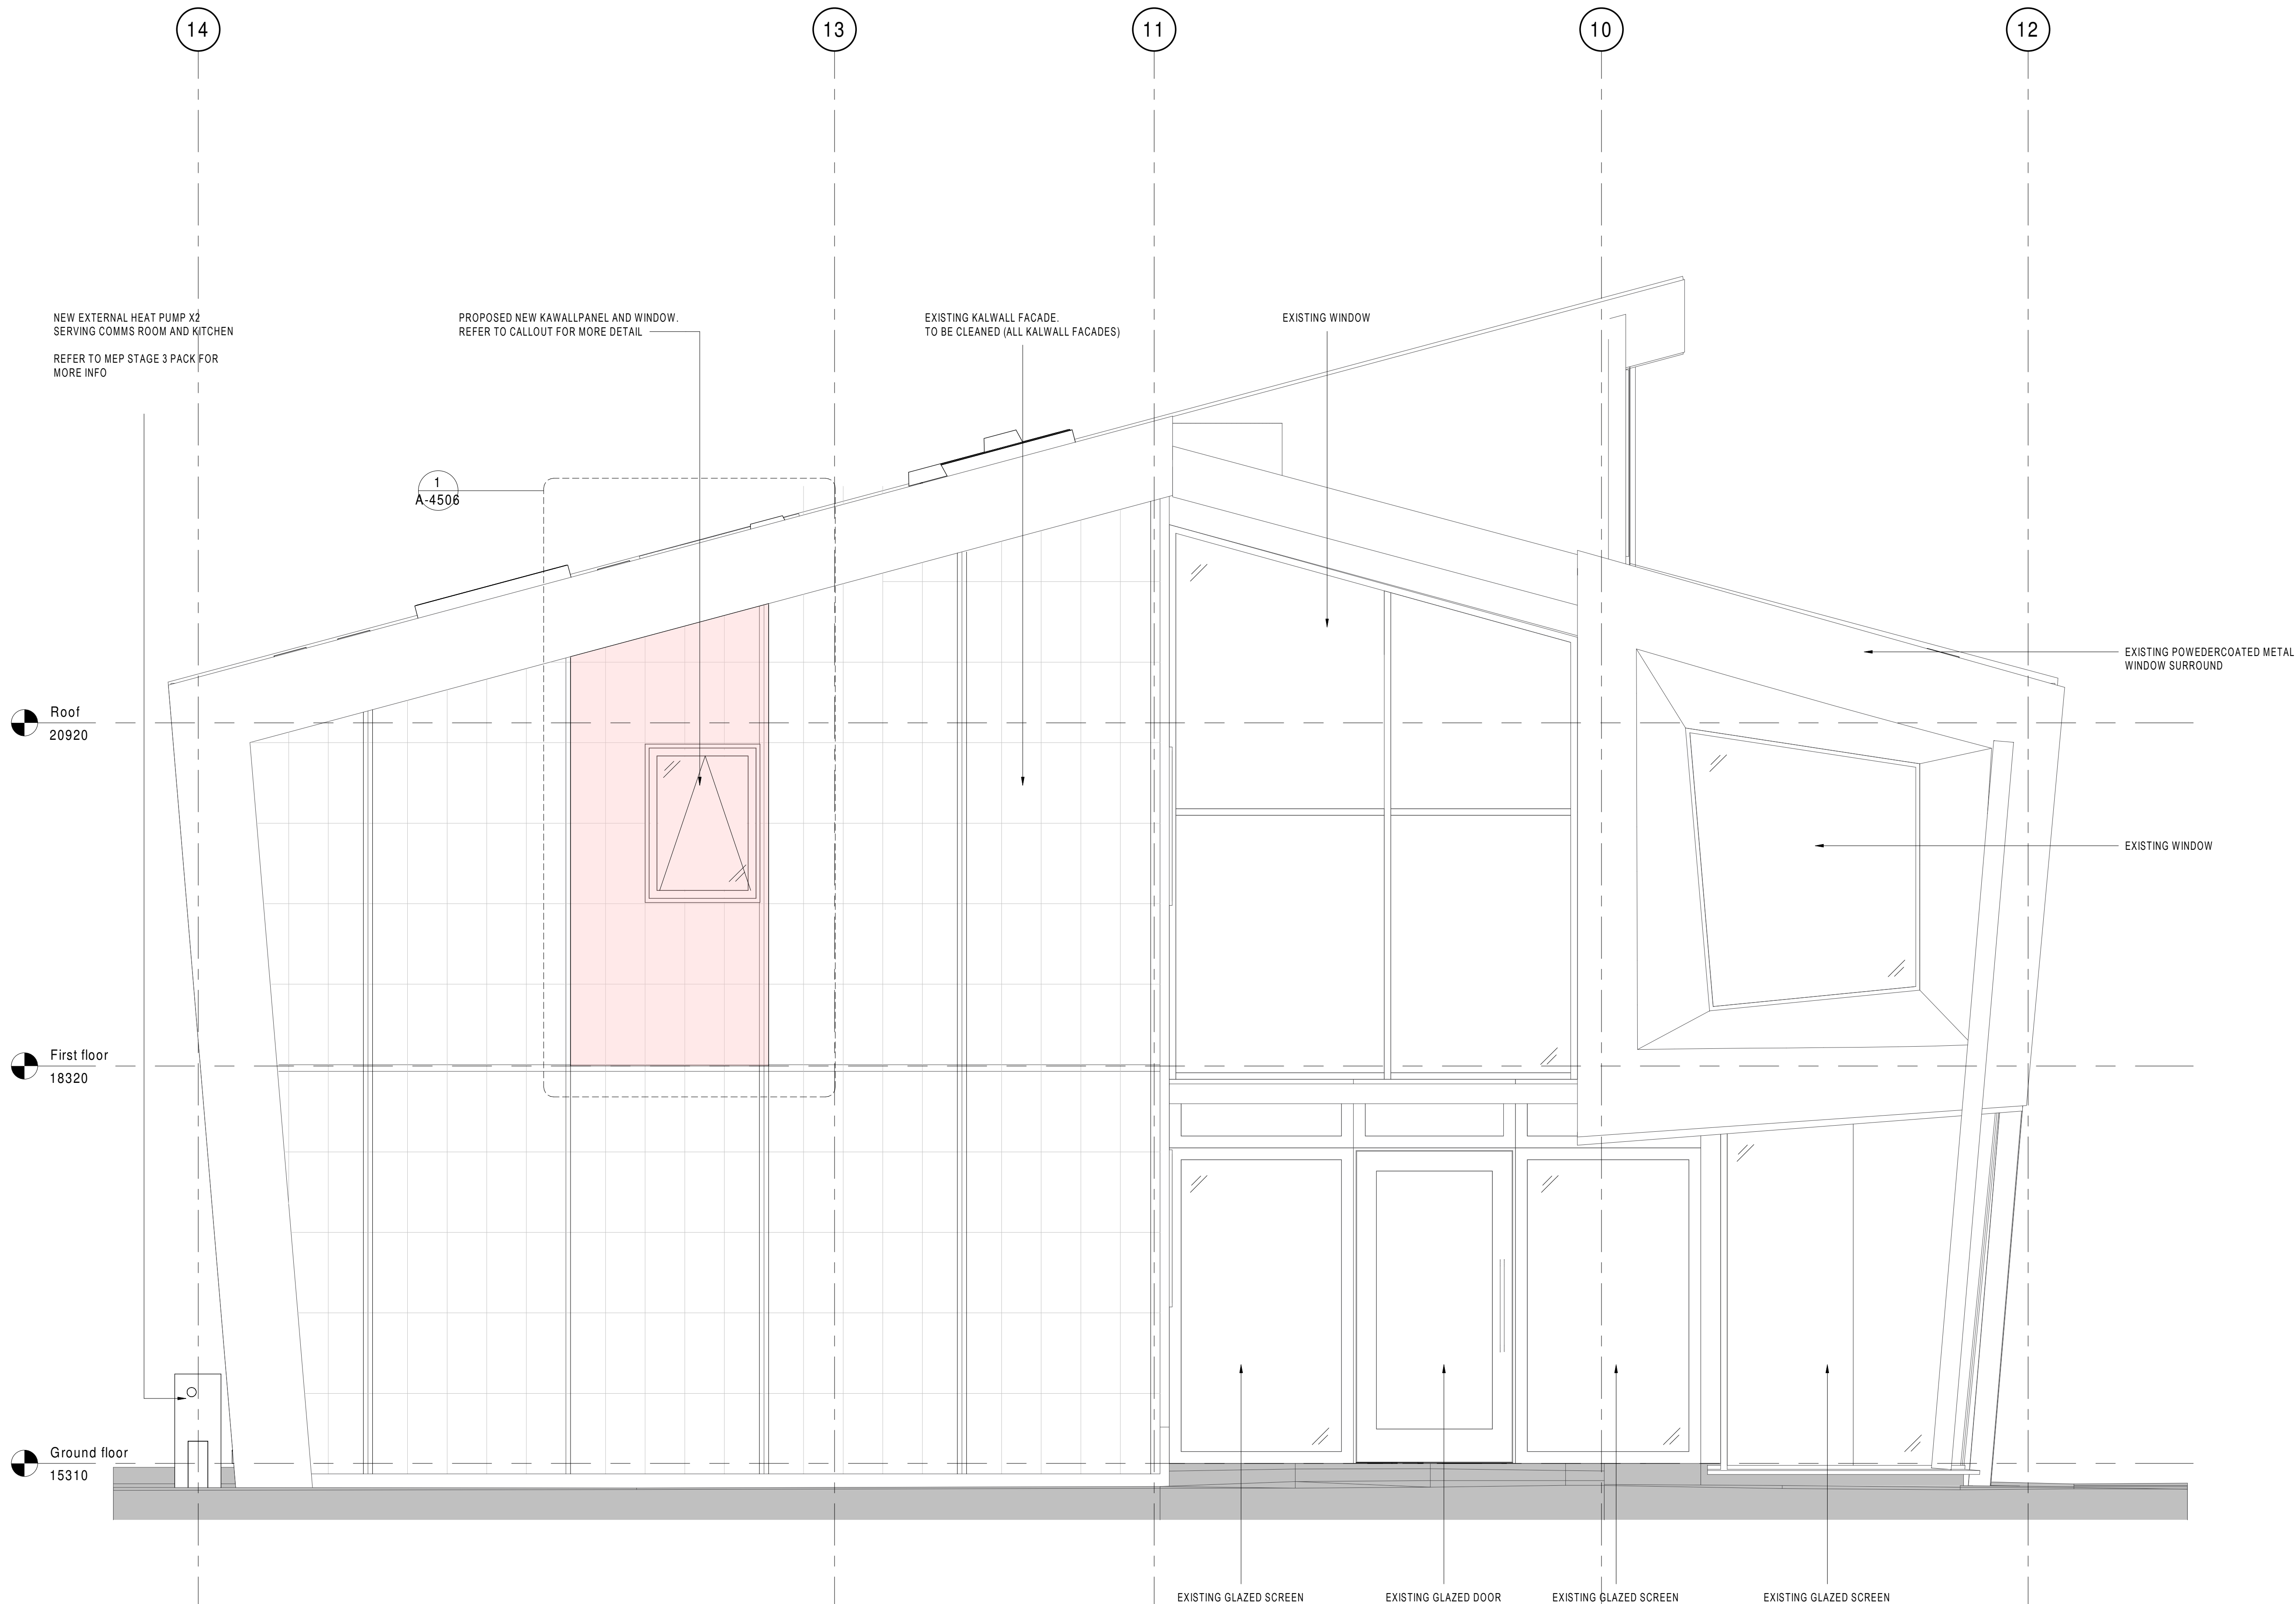

YOUTH SPACE BUILDING KEY



RIBA 4

REVISION	DATE	DESCRIPTION	ARCHITECT	PARTNER
1	09.08.22	Issued to SE for review	LS	ADP
2	07.09.22	STAGE 01 DRAFT ISSUE	LS	ADP
3	21.12.22	DRAFT PLANNING ISSUE	LS	ADP
4	13.01.23	PLANNING ISSUE	LS	ADP
5	16.01.23	STAGE 3 ISSUE	LS	ADP
6	02.06.23	STAGE 4 ISSUE	LS	ADP

CHECK ALL DIMENSIONS AND VERIFY ON SITE. REPORT ANY ERRORS OR OMISSIONS

adp
The Fire Station
150 Waterloo Road
London
SE1 8SB
T +44 (0) 20 7089 1720
E london@adp-architecture.com
www.adp-architecture.com

JOB TITLE:
**BRUCE GROVE
YOUTH SPACE**

DRAWING TITLE:
PROPOSED FRONT ELEVATIONS

SCALE: As indicated	DRAWING SHEET SIZE: A1	REVISION: 6
JOB CODE: 001550	DRAWING NUMBER: ADP-00-ZZ-DR- A-1205	

1 PROPOSED FRONT ELEVATION
1 : 25