
 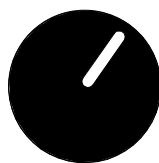



1 EXISTING ROOF PLAN

1 : 50

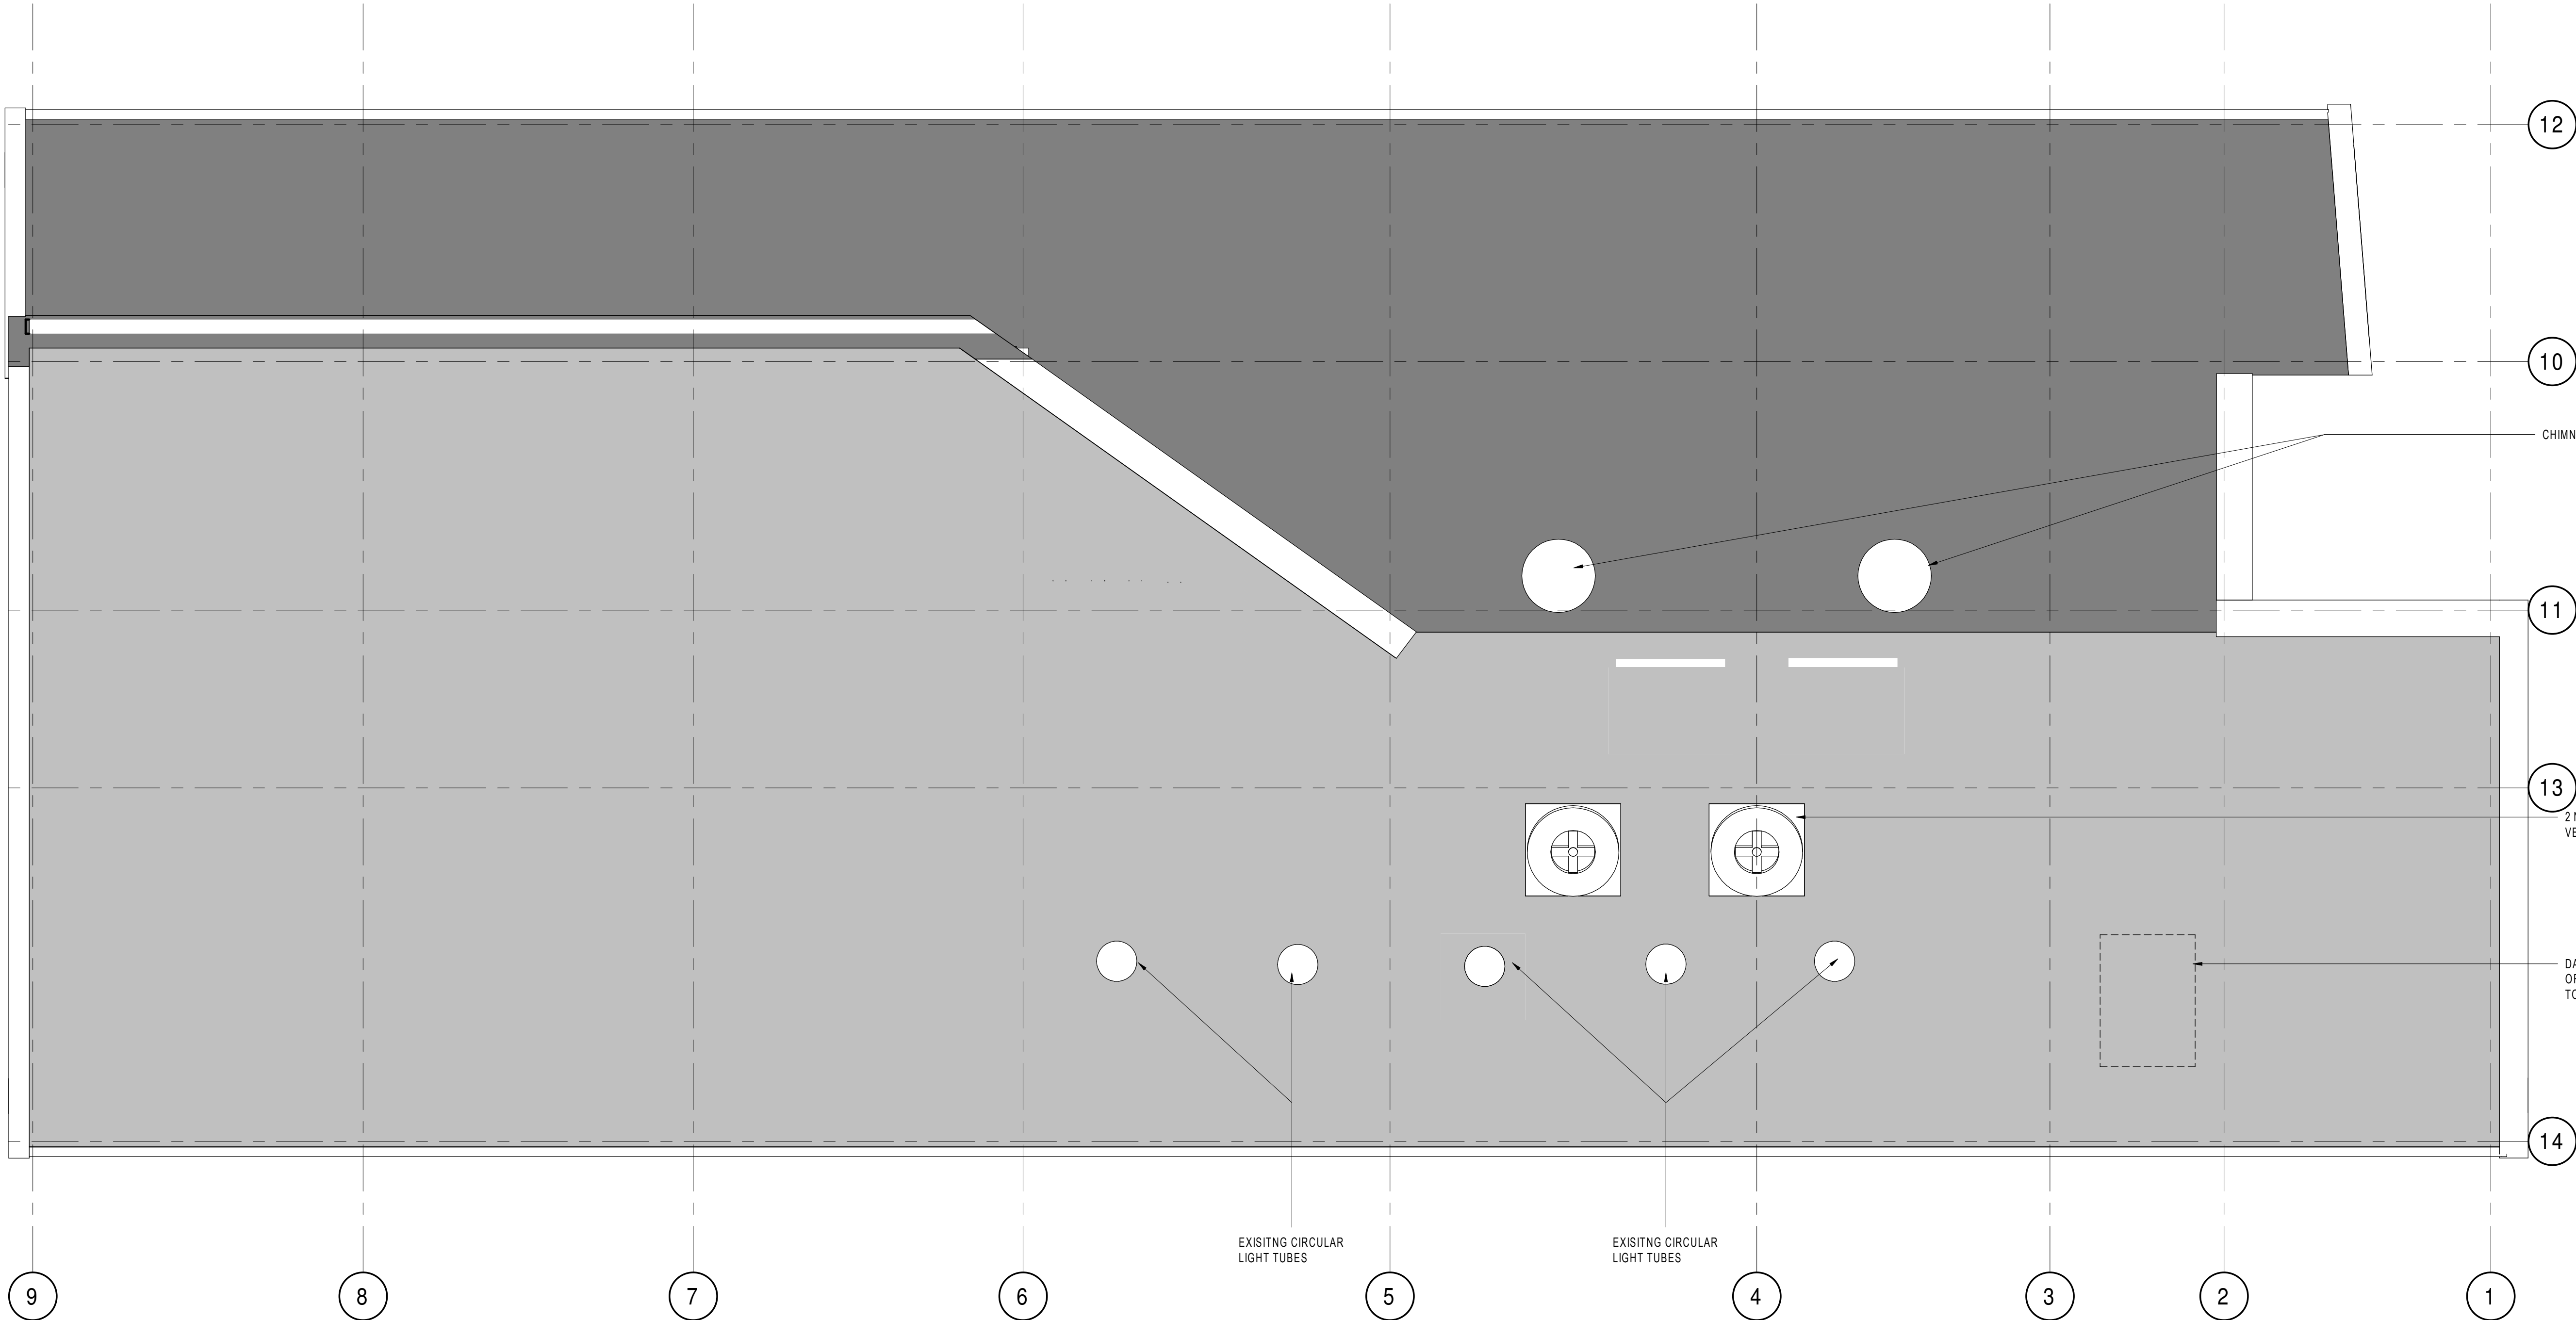

RIBA 4

REVISION	DATE	DESCRIPTION	ARCHITECT	PARTNER
1	13.01.23	PLANNING ISSUE	LS	ADP
2	16.01.23	STAGE 3 ISSUE	LS	ADP
3	02.06.23	STAGE 4 ISSUE	LS	ADP

CHECK ALL DIMENSIONS AND VERIFY ON SITE. REPORT ANY ERRORS OR OMISSIONS

The Fire Station

150 Waterloo Road

London

SE1 8SB

T +44 (0) 20 7089 1720

E london@adp-architecture.com

www.adp-architecture.com

JOB TITLE:
**BRUCE GROVE
YOUTH SPACE**

DRAWING TITLE:
EXISTING ROOF PLAN

SCALE: 1 : 50		DRAWING SHEET SIZE: A1	
JOB CODE: 001550	DRAWING NUMBER: ADP-00-R1-DR- A-0903	REVISION: 3	