
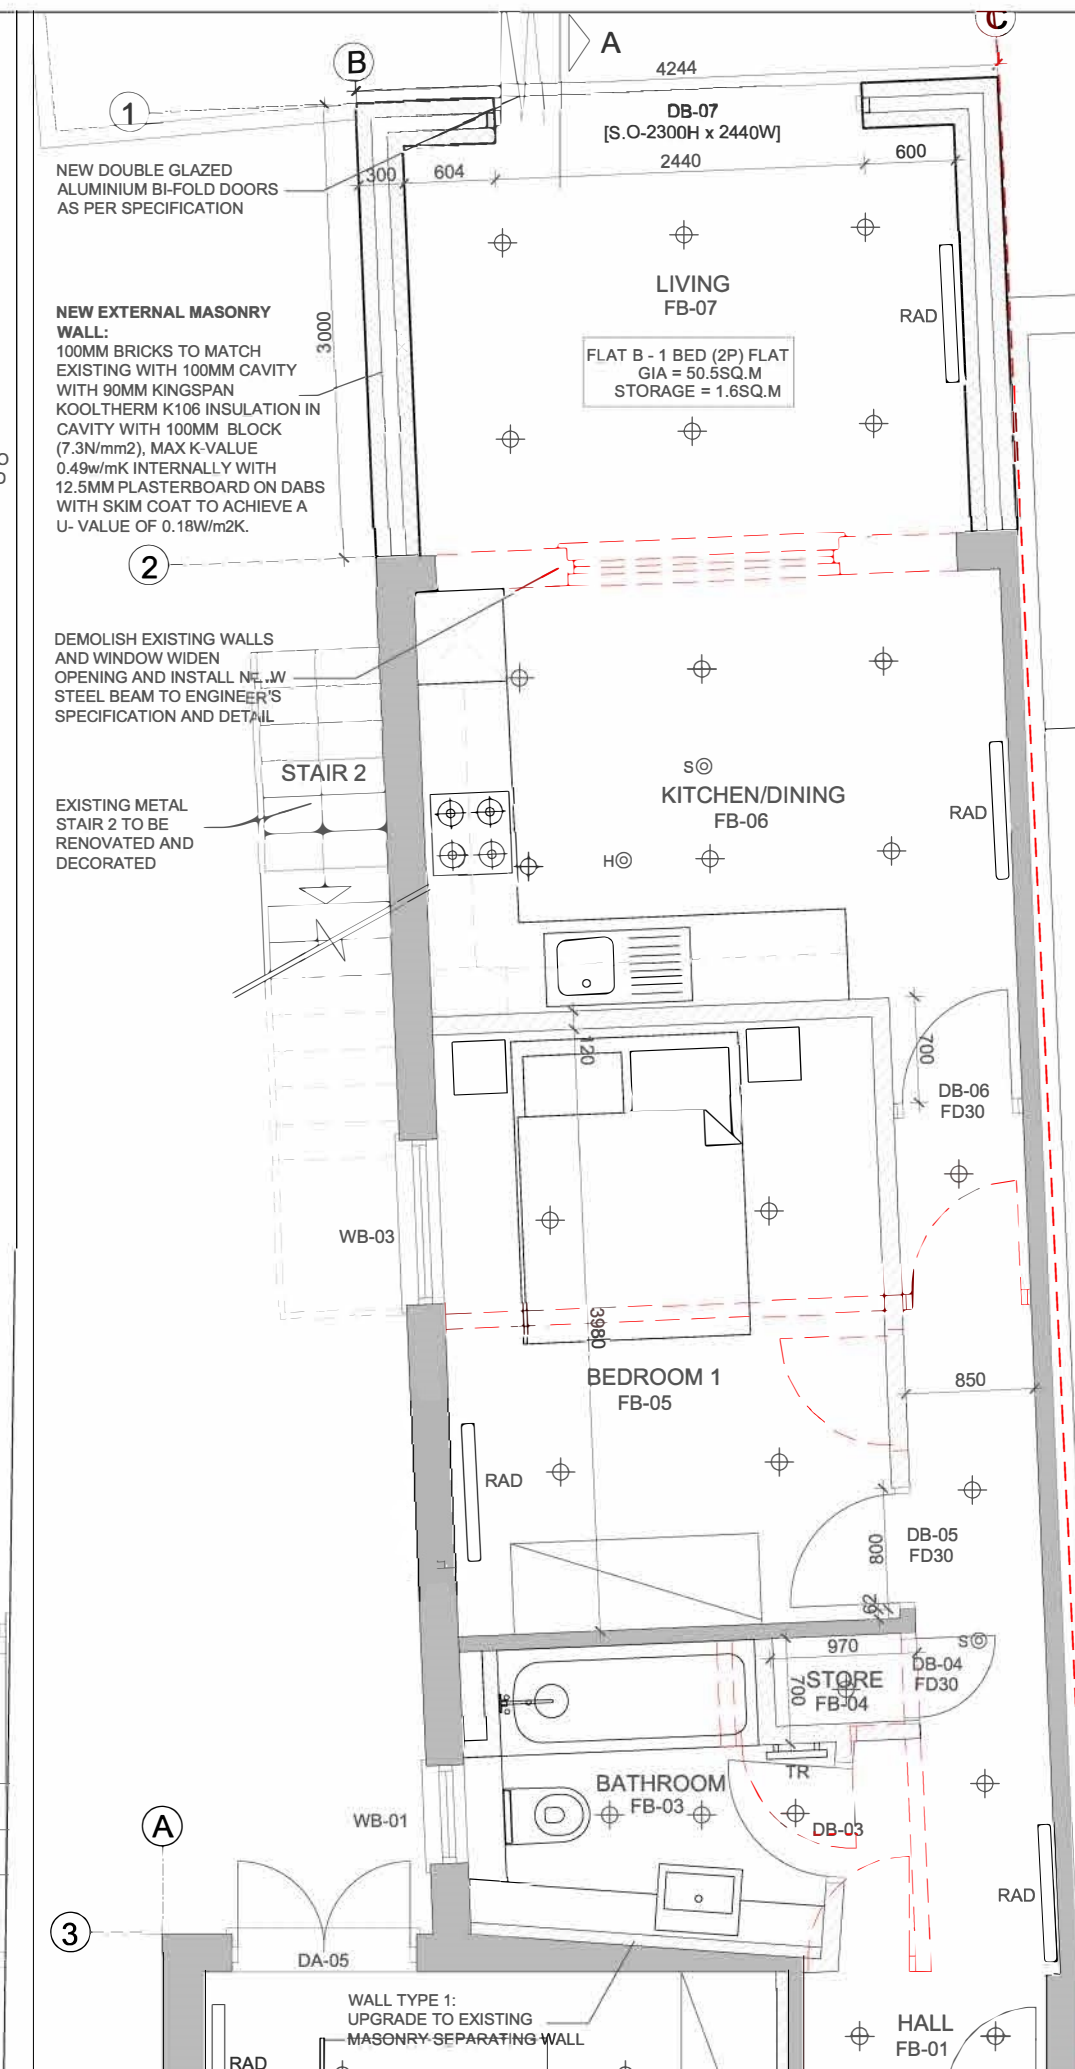


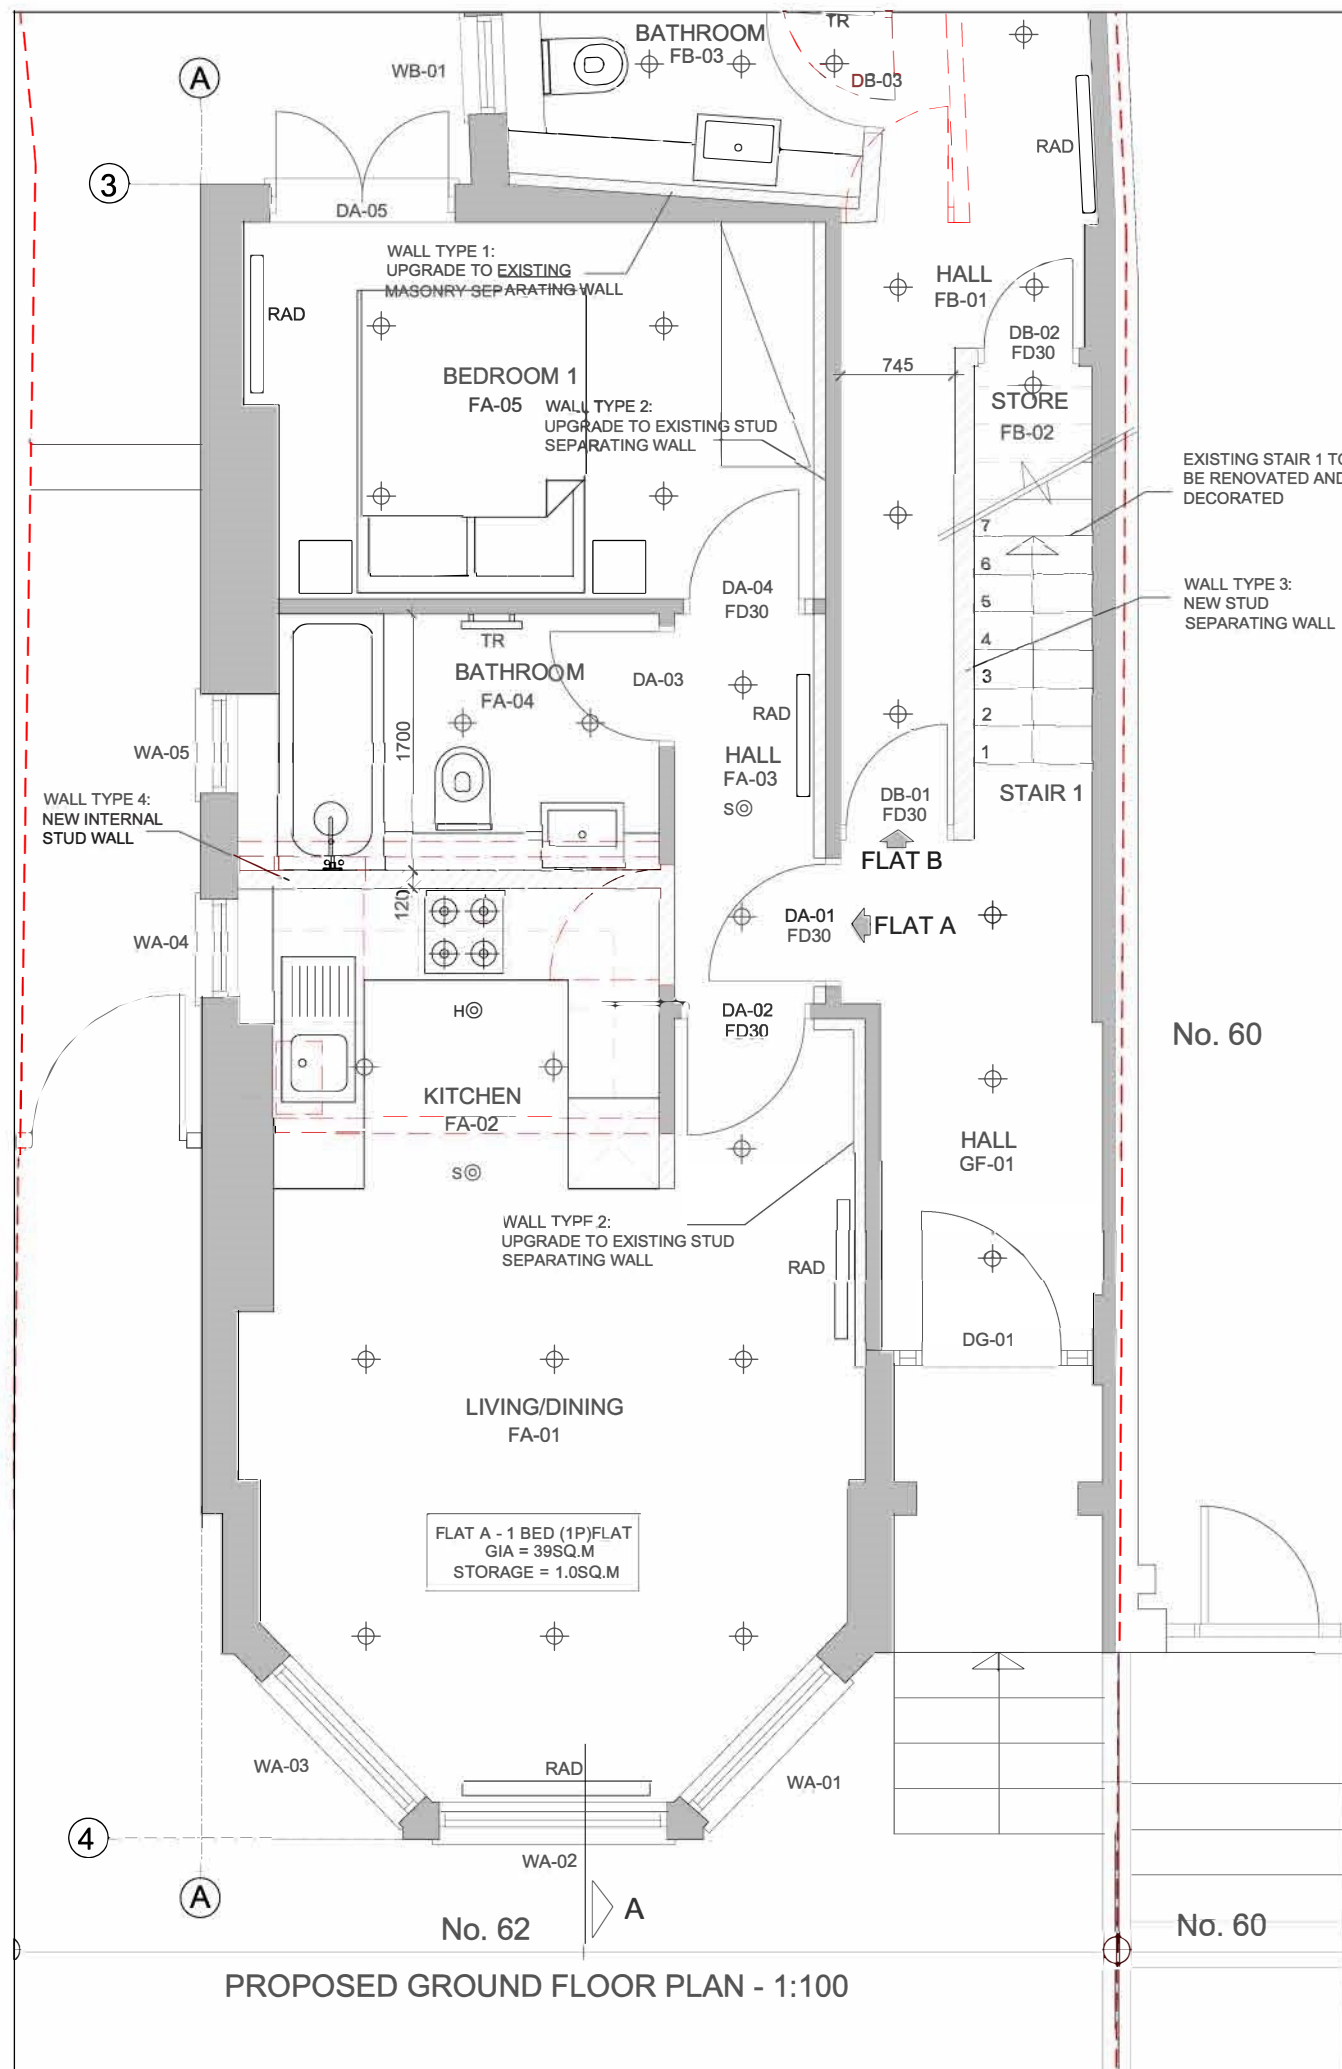

NOTES:

KEY TO FITTINGS

- 2 GANG SWITCHED 13A SOCKET
- 1 GANG SWITCHED 5A SOCKET
- LIGHT SWITCH
- TWO WAY LIGHT SWITCH
- TV TV POINT
- SMOKE DETECTOR
- HEAT DETECTOR
- PANEL RADIATOR
- TOWEL RAIL
- EXTRACT FAN activated by light switch
- CEILING MOUNTED LIGHT
- RECESSED CEILING DOWNLIGHTER
- WALL MOUNTED LIGHT

EXISTING WALL

NEW BLOCK WALLS

NEW BRICK WALLS

NEW STUD WALLS

STUD SEPARATING WALLS

DEMOLITION

DIMENSION TO BE CHECKED ON SITE

REFER TO STRUCTURAL ENGINEER'S DRAWING FOR STRUCTURAL WORKS

NOTES:

Revision	Description	Date	By
1	BEDROOM 1 WINDOW REMOVED	24/02/23	PL

REVISIONS

CONSTRUCTION

Project
ALTERATION AND EXTENSION

Location
62 COLNEY HATCH LANE
LONDON, N10 1EA

Drawing
PROPOSED GROUND FLOOR PLAN

Date	Drawn	PL
FEB. 2023		

Scale
1:50@A3

WB London
ARCHITECTURAL AND DEVELOPMENT CONSULTANTS
tel: 0208 406 0083 mobile: 07932065400
e-mail: perry@wb-london.com

Dwg. No.
1807-300

D