


SITE LOCATION



 
Reproduced by permission of Ordnance Survey on behalf of the Controller of Her Majesty's Stationary Office
All rights reserved. © Crown Copyright licence no. 100062043

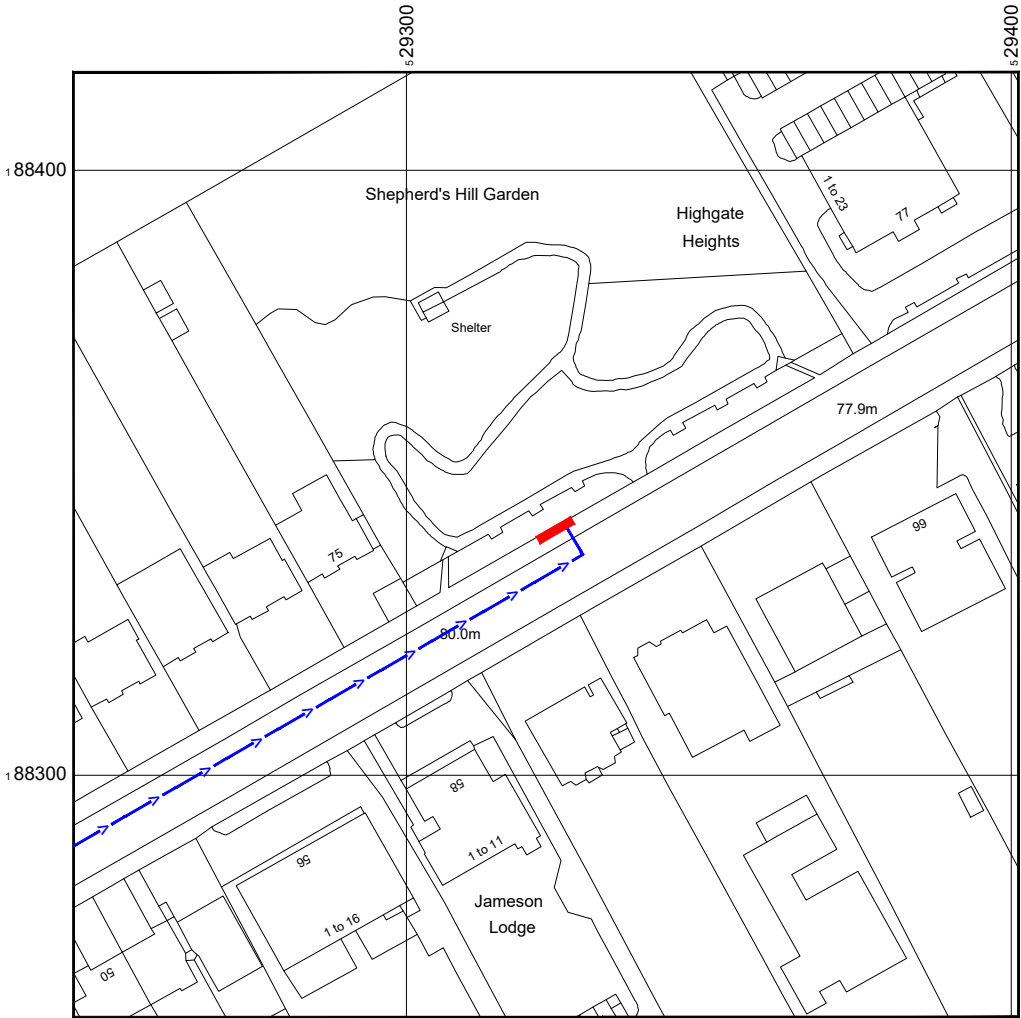

Reproduced by permission of Ordnance Survey on behalf of
the Controller of Her Majesty's Stationary Office
All rights reserved. © Crown Copyright licence no. 100062043


NGR E: 529328 N: 188343

SITE AREA PLAN



SITE PHOTOGRAPH

 SITE LOCATION PLAN



GOOGLE MAPS QR CODE

GOOGLE MAPS - <https://goo.gl/maps/oXLt39wF2MuupVsv9>

GOOGLE STREETVIEW - <https://goo.gl/maps/kHZHmMsf83EXNBfV8>

NOTES:

1. ALL DIMENSIONS IN MM UNLESS OTHERWISE NOTED.
- DIRECTIONS TO SITE:
Head south on M1. Keep left. Merge onto N Circular Rd./A406. Keep right to continue on Fallosen Wy/A1. Continue onto Lyttelton Rd. Continue onto Aylmer Rd/A1. Turn left onto Shepherds Hl. Follow Shepherds Hl and site location is on the left hand side.



Master:	MBNL / EE:	Project:	Purpose of Issue:	Issue:
M001	MBNL	3UK DNSW	Planning	A
Date:	15/05/2023	Revision / Upgrade Description:		
Drawn:	CDN	First Issue - Site nomination dated: TBC		
Checked:	DH			
Approved:	SD			

CK Hutchison Networks (UK) Limited
Green Park
450 Longwater Avenue
Reading
RG30 3UR

Design Consultant & Principal Contractor:

WHP Telecoms
Unit 1 Maple Park,
Low Fields Avenue, Leeds
LS12 6HH

Tel: 01133023550
e-mail: info@whptelecoms.com

Site Name:
SHEPHERDS HILL STREETWORKS

Site ID:
HGY22059

Address:
**SHEPHERDS HILL, SHEPHERDCROUCH
END, LONDON BOROUGH OF HARINGEY,
ENGLAND,
N6 5RR**


Title:
002 SITE LOCATION PLAN

Project:
3UK DNSW


Purpose of Issue:
PLANNING

EE Cell ID:	MBNL Cell ID:	Cell ID:
80885	HGY196	N1167

Master Drawing No:	Issue:
HGY22059_M001	A

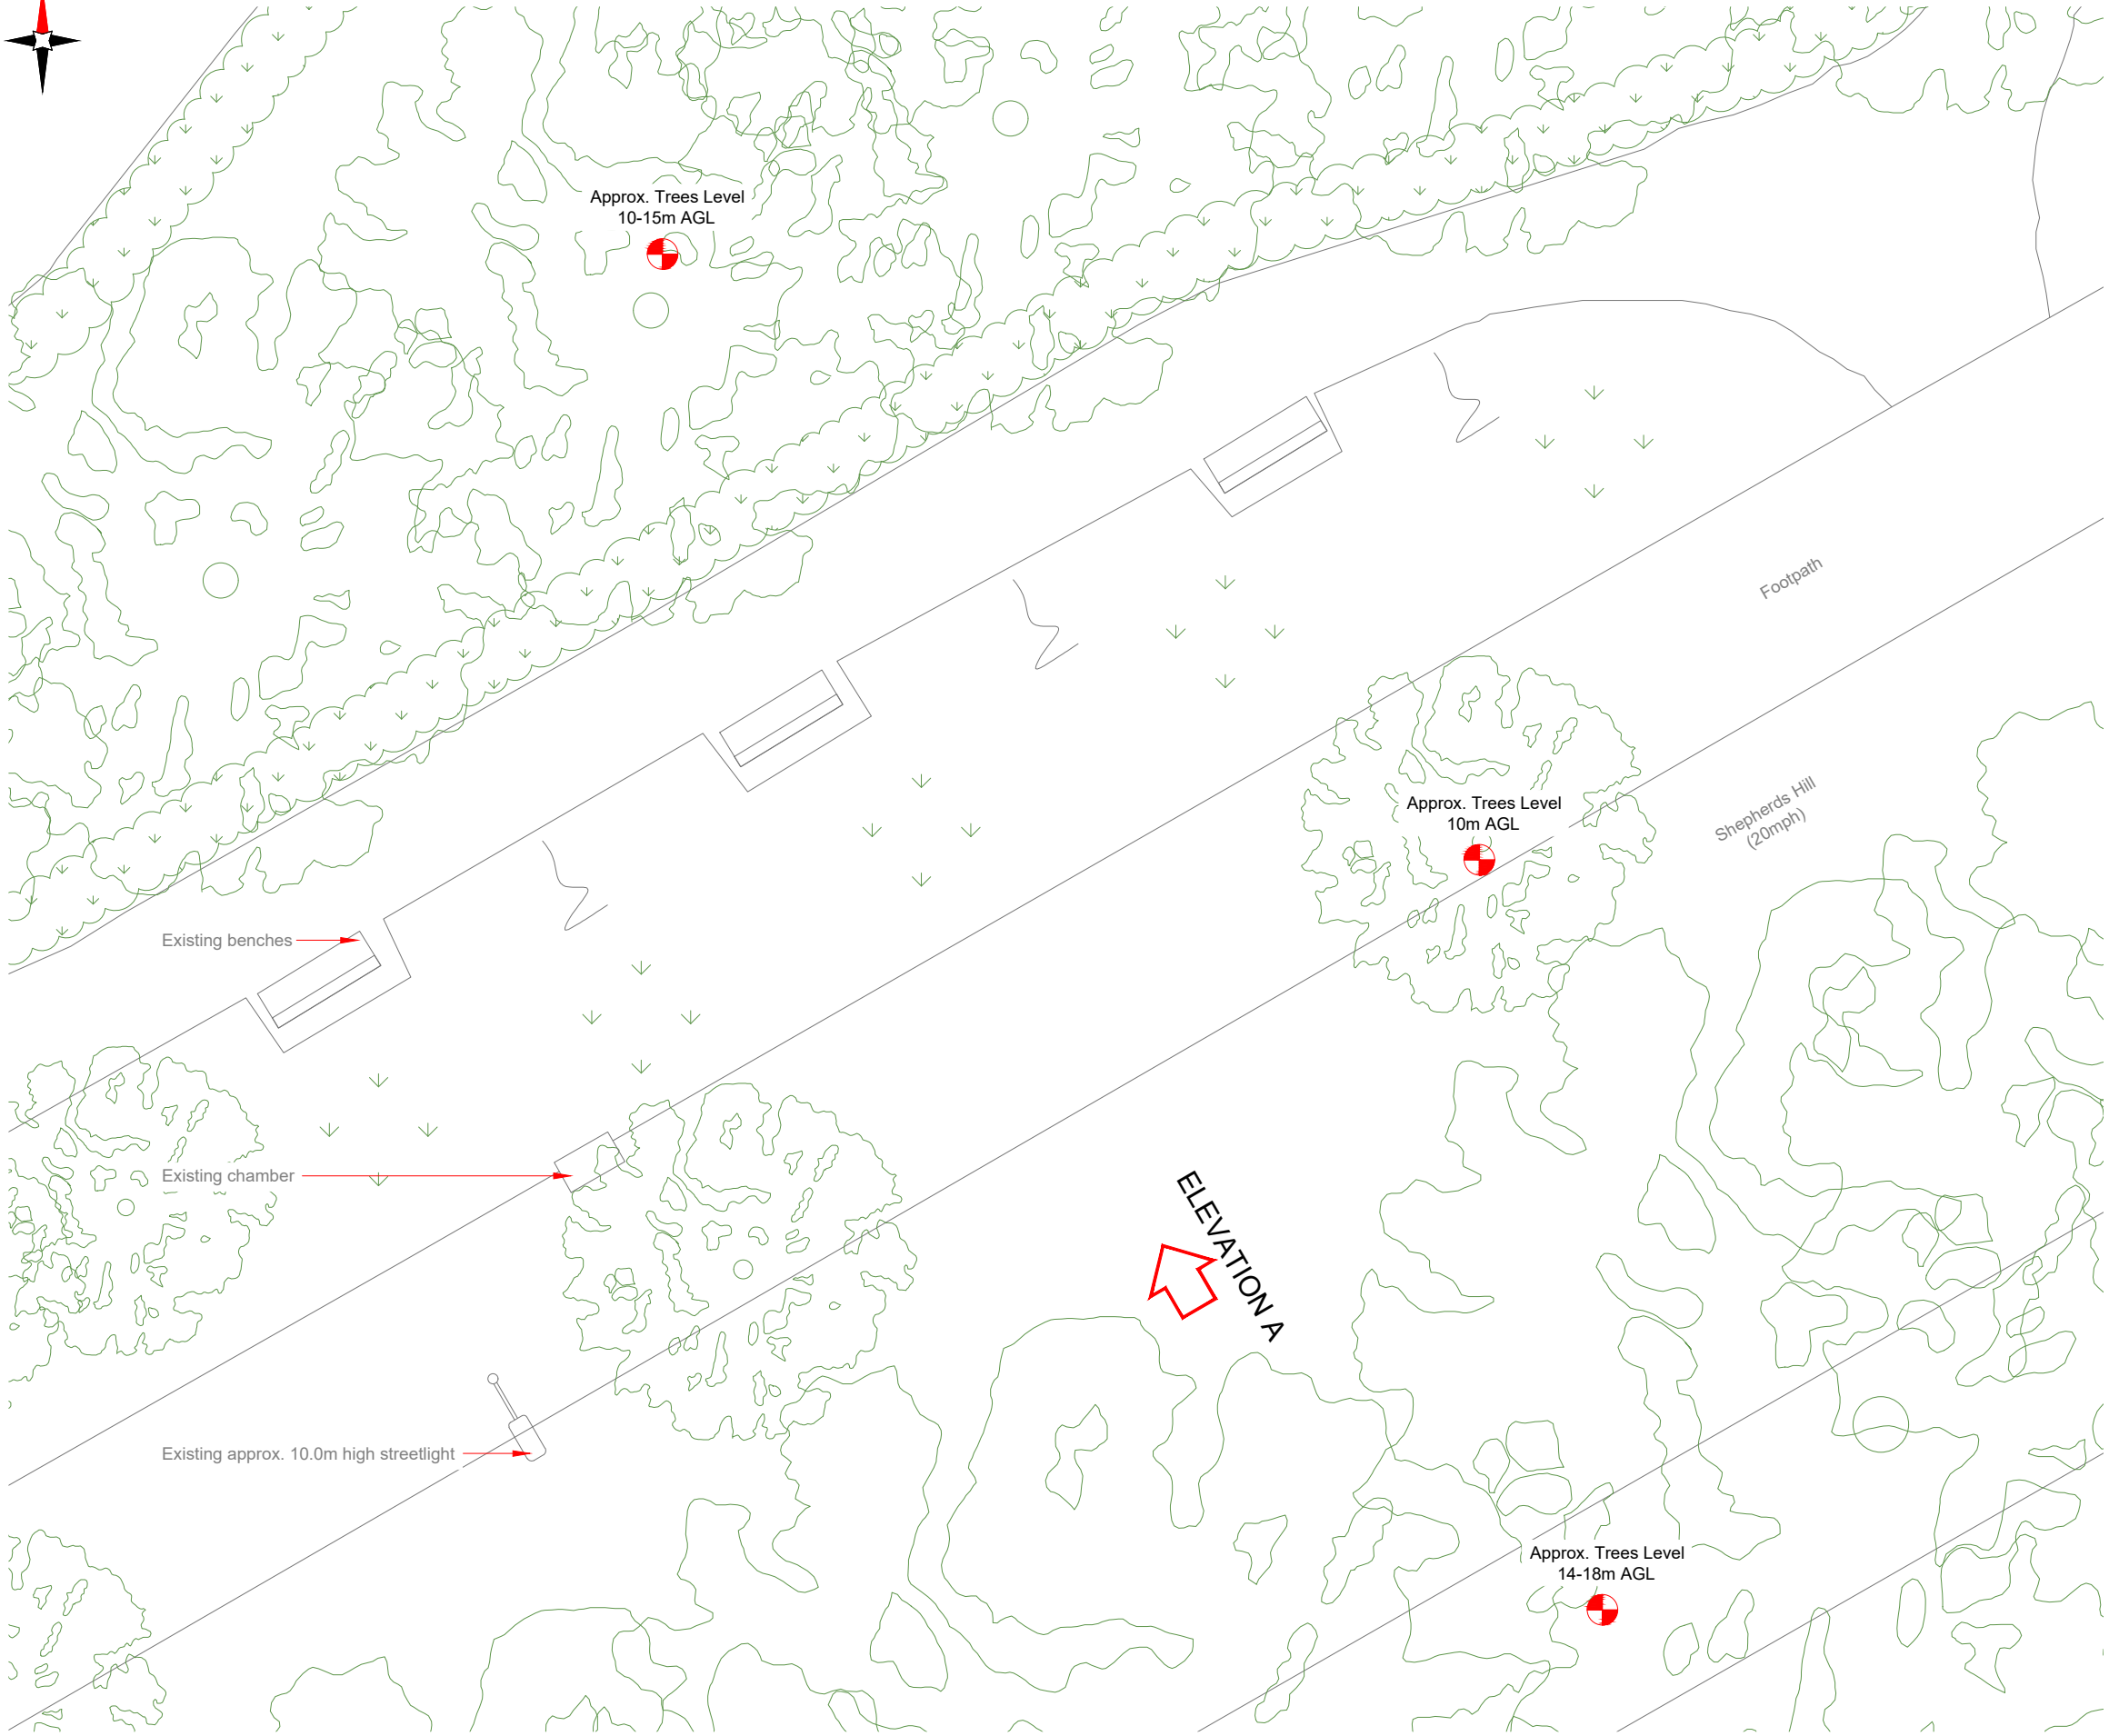

EXISTING SITE PLAN

 

NOTES:

1. ALL DIMENSIONS IN MM UNLESS OTHERWISE NOTED.

Master:	MBNL / EE:	Project:	Purpose of Issue:	Issue:
M001	MBNL	3UK DNSW	Planning	A
Date:	15/05/2023	Revision / Upgrade Description:		
Drawn:	CDN	First Issue - Site nomination dated: TBC		
Checked:	DH			
Approved:	SD			

CK Hutchison Networks (UK) Limited

Green Park
450 Longwater Avenue
Reading
RG30 3UR

Design Consultant & Principal Contractor:



WHP Telecoms
Unit 1 Maple Park,
Low Fields Avenue, Leeds
LS12 6HH

Tel: 01133023550
e-mail: info@whptelecoms.com

Site Name:

SHEPHERDS HILL STREETWORKS

Site ID:

HGY22059

Address:

**SHEPHERDS HILL, SHEPHERDCROUCH
END, LONDON BOROUGH OF HARINGEY,
ENGLAND,
N6 5RR**

Title:

100 EXISTING SITE PLAN

Project:

3UK DNSW

Purpose of Issue:

PLANNING

EE Cell ID:	MBNL Cell ID:	Cell ID:
80885	HGY196	N1167

Master Drawing No:

HGY22059_M001

Issue:

A

 
100mm

50mm

10mm



EXISTING ELEVATION A



NOTES:

1. ALL DIMENSIONS IN MM UNLESS OTHERWISE NOTED.

Master:	MBNL / EE:	Project:	Purpose of Issue:	Issue:
M001	MBNL	3UK DNSW	Planning	A
Date:	15/05/2023	Revision / Upgrade Description:		
Drawn:	CDN	First Issue - Site nomination dated: TBC		
Checked:	DH			
Approved:	SD			

CK Hutchison
Networks (UK)
Limited

Green Park
450 Longwater Avenue
Reading
RG30 3UR

Design Consultant & Principal Contractor:



WHP Telecoms

Unit 1 Maple Park,
Low Fields Avenue, Leeds
LS12 6HH

Tel: 01133023550
e-mail: info@whptelecoms.com

Site Name:
SHEPHERDS HILL STREETWORKS

Site ID:
HGY22059

Address:
SHEPHERDS HILL, SHEPHERDCROUCH
END, LONDON BOROUGH OF HARINGEY,
ENGLAND,
N6 5RR


Title:
150 EXISTING ELEVATION A

Project:
3UK DNSW

Purpose of Issue:
PLANNING

EE Cell ID: 80885	MBNL Cell ID: HGY196	Cell ID: N1167
----------------------	-------------------------	-------------------

Master Drawing No: HGY22059_M001	Issue: A
-------------------------------------	-------------

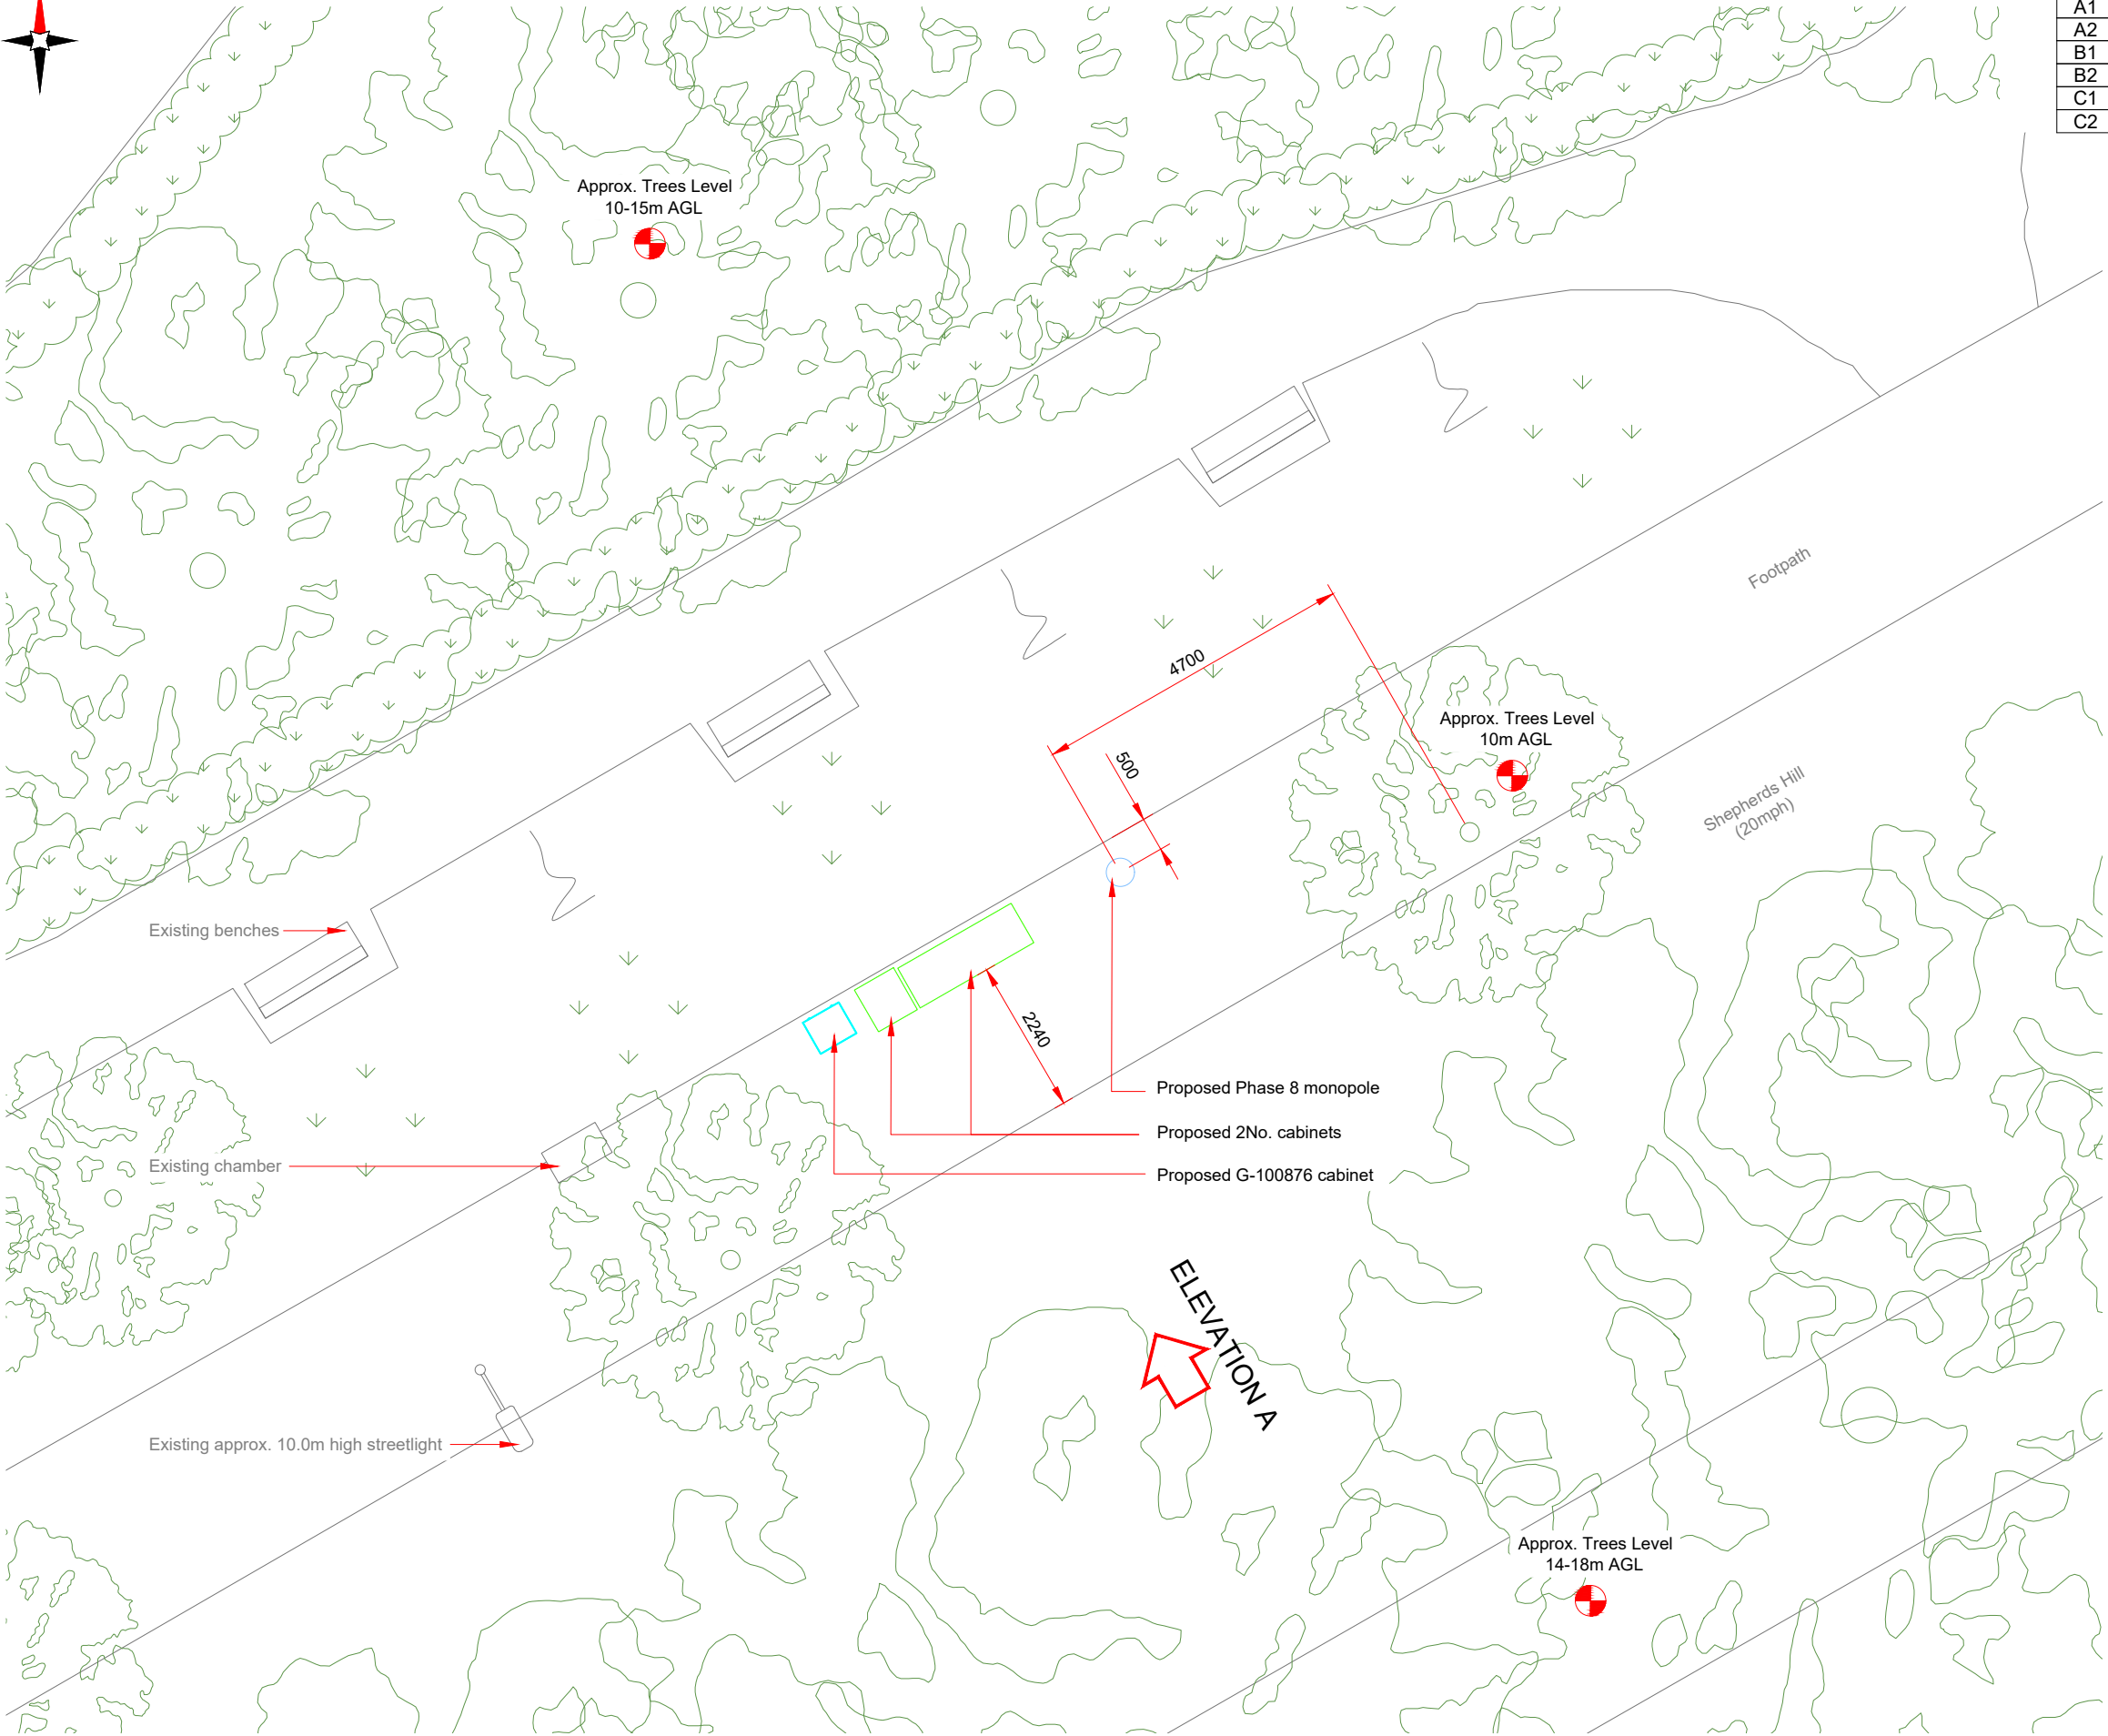

Antenna Aperture ID	Proposed 4G/5G Bearing
A1	0°
A2	0°
B1	120°
B2	120°
C1	240°
C2	240°

- NOTES:
- ALL DIMENSIONS IN MM UNLESS OTHERWISE NOTED.

Master:	MBNL / EE:	Project:	Purpose of Issue:	Issue:
M001	MBNL	3UK DNSW	Planning	A
Date:	15/05/2023	Revision / Upgrade Description:		
Drawn:	CDN	First Issue - Site nomination dated: TBC		
Checked:	DH			
Approved:	SD			

CK Hutchison Networks (UK) Limited

Green Park
450 Longwater Avenue
Reading
RG30 3UR

Design Consultant & Principal Contractor:



WHP Telecoms

Unit 1 Maple Park,
Low Fields Avenue, Leeds
LS12 6HH

Tel: 01133023550
e-mail: info@whptelecoms.com

Site Name:
SHEPHERDS HILL STREETWORKS

Site ID:
HGY22059

Address:
**SHEPHERDS HILL, SHEPHERDCROUCH
END, LONDON BOROUGH OF HARINGEY,
ENGLAND,
N6 5RR**

Title:
210 PROPOSED SITE PLAN

Project:
3UK DNSW

Purpose of Issue:
PLANNING


EE Cell ID: 80885	MBNL Cell ID: HGY196	Cell ID: N1167
-----------------------------	--------------------------------	--------------------------

Master Drawing No: HGY22059_M001	Issue: A
--	--------------------

Antenna Aperture ID	Proposed 4G/5G Bearing
A1	0°
A2	0°
B1	120°
B2	120°
C1	240°
C2	240°

NOTES:

1. ALL DIMENSIONS IN MM UNLESS OTHERWISE NOTED.

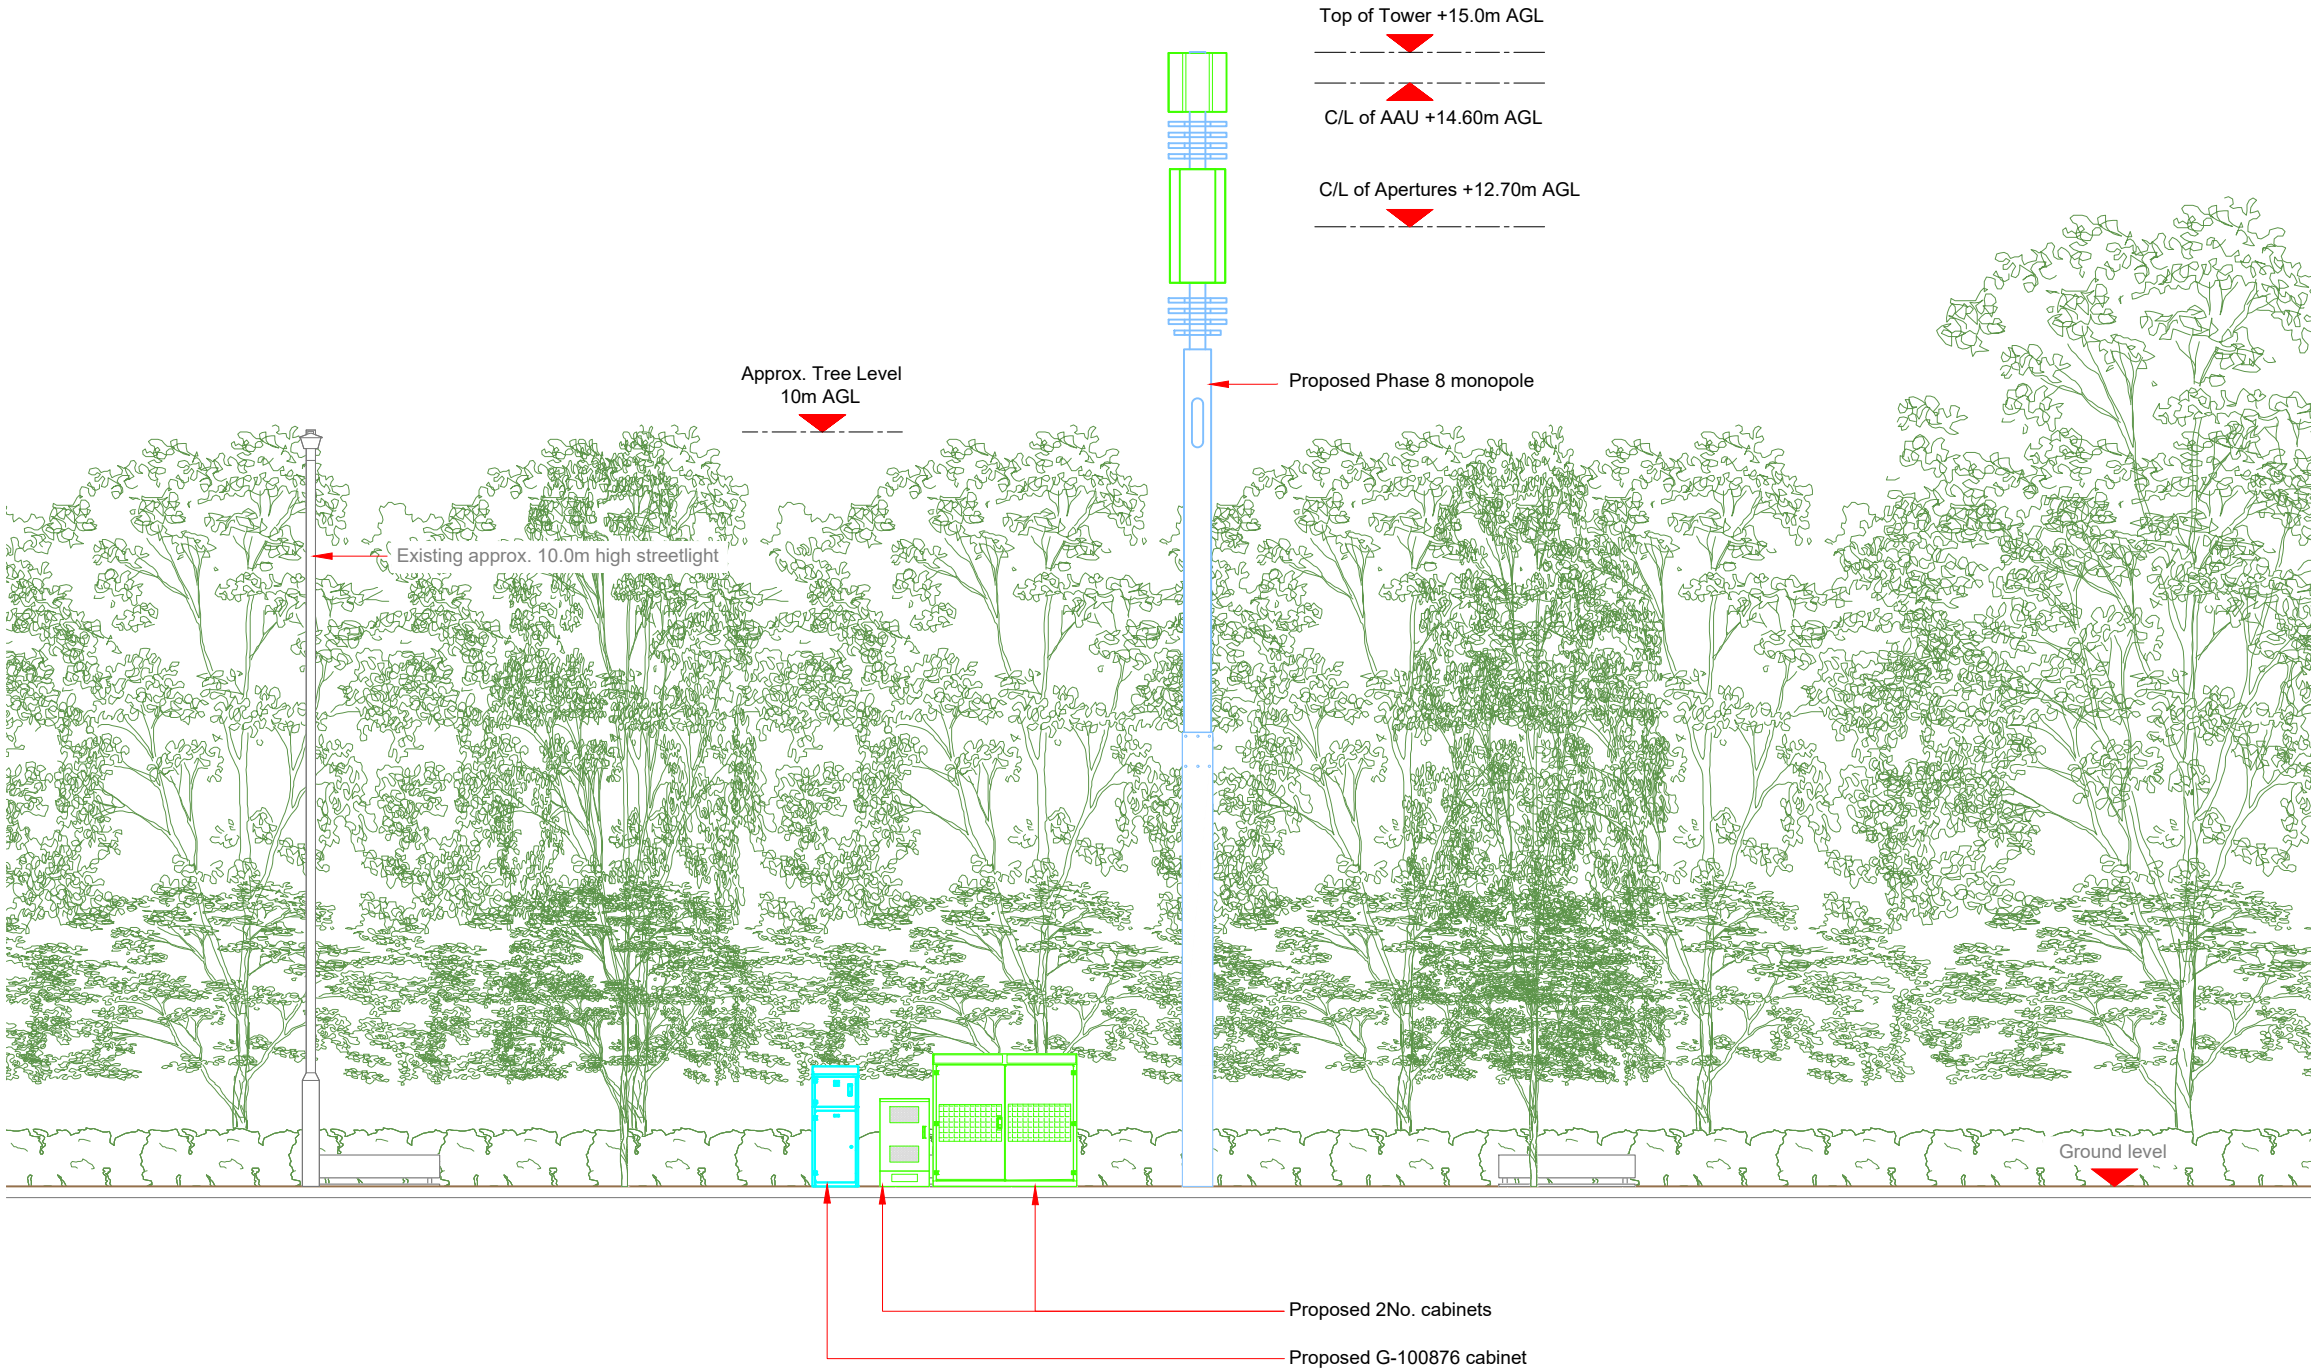

Master:	MBNL / EE:	Project:	Purpose of Issue:	Issue:
M001	MBNL	3UK DNSW	Planning	A
Date:	15/05/2023	Revision / Upgrade Description:		
Drawn:	CDN	First Issue - Site nomination dated: TBC		
Checked:	DH			
Approved:	SD			

**CK Hutchison
Networks (UK)
Limited**

Green Park
450 Longwater Avenue
Reading
RG30 3UR

Design Consultant & Principal Contractor:



WHP Telecoms
Unit 1 Maple Park,
Low Fields Avenue, Leeds
LS12 6HH

Tel: 01133023550
e-mail: info@whptelecoms.com

Site Name:
SHEPHERDS HILL STREETWORKS

Site ID:
HGY22059

Address:
**SHEPHERDS HILL, SHEPHERDCROUCH
END, LONDON BOROUGH OF HARINGEY,
ENGLAND,
N6 5RR**

Title:
260 PROPOSED ELEVATION

Project:
3UK DNSW

Purpose of Issue:
PLANNING

EE Cell ID: 80885	MBNL Cell ID: HGY196	Cell ID: N1167
-----------------------------	--------------------------------	--------------------------

Master Drawing No: HGY22059_M001	Issue: A
--	--------------------