 

 
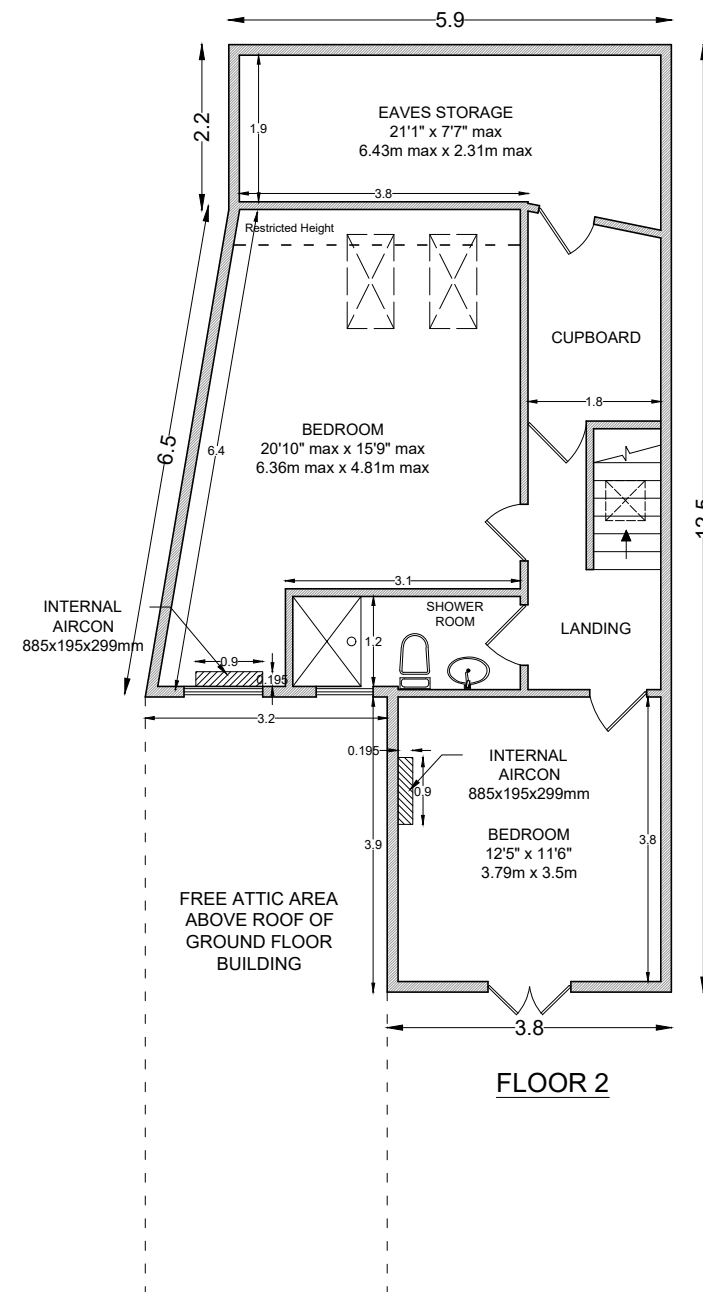



Project 2 INTERNAL 1 EXTERNAL AIRCONS INSTALLMENT		Structure	----	Drg. Title		Drawn by		Date		Scale	1 : 100	
		Plumbing	----	FLOOR PLAN		ALIZA AYMAN ANSARI						
		Electrical	----	Drg. Status		Drg. Issued		Revision		Date		Sheet size:
		Contractor	----			---	00			A3		

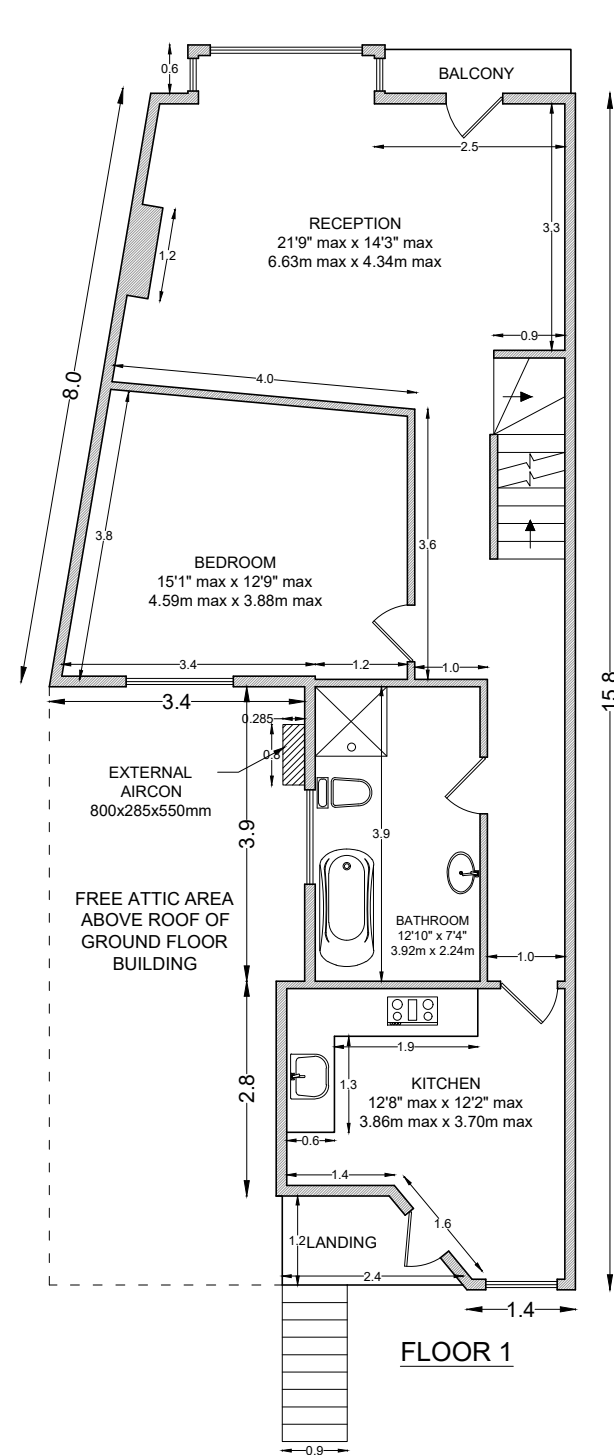


Project 2 INTERNAL 1 EXTERNAL AIRCONS INSTALLMENT		Structure Plumbing Electrical Contractor	----- ----- ----- -----	Drg. Title FLOOR PLAN	Drawn by ALIZA AYMAN ANSARI	Date	Scale 1 : 100
				Drg. Status	Drg. Issued ---	Revision 00 Date	Sheet size: A3

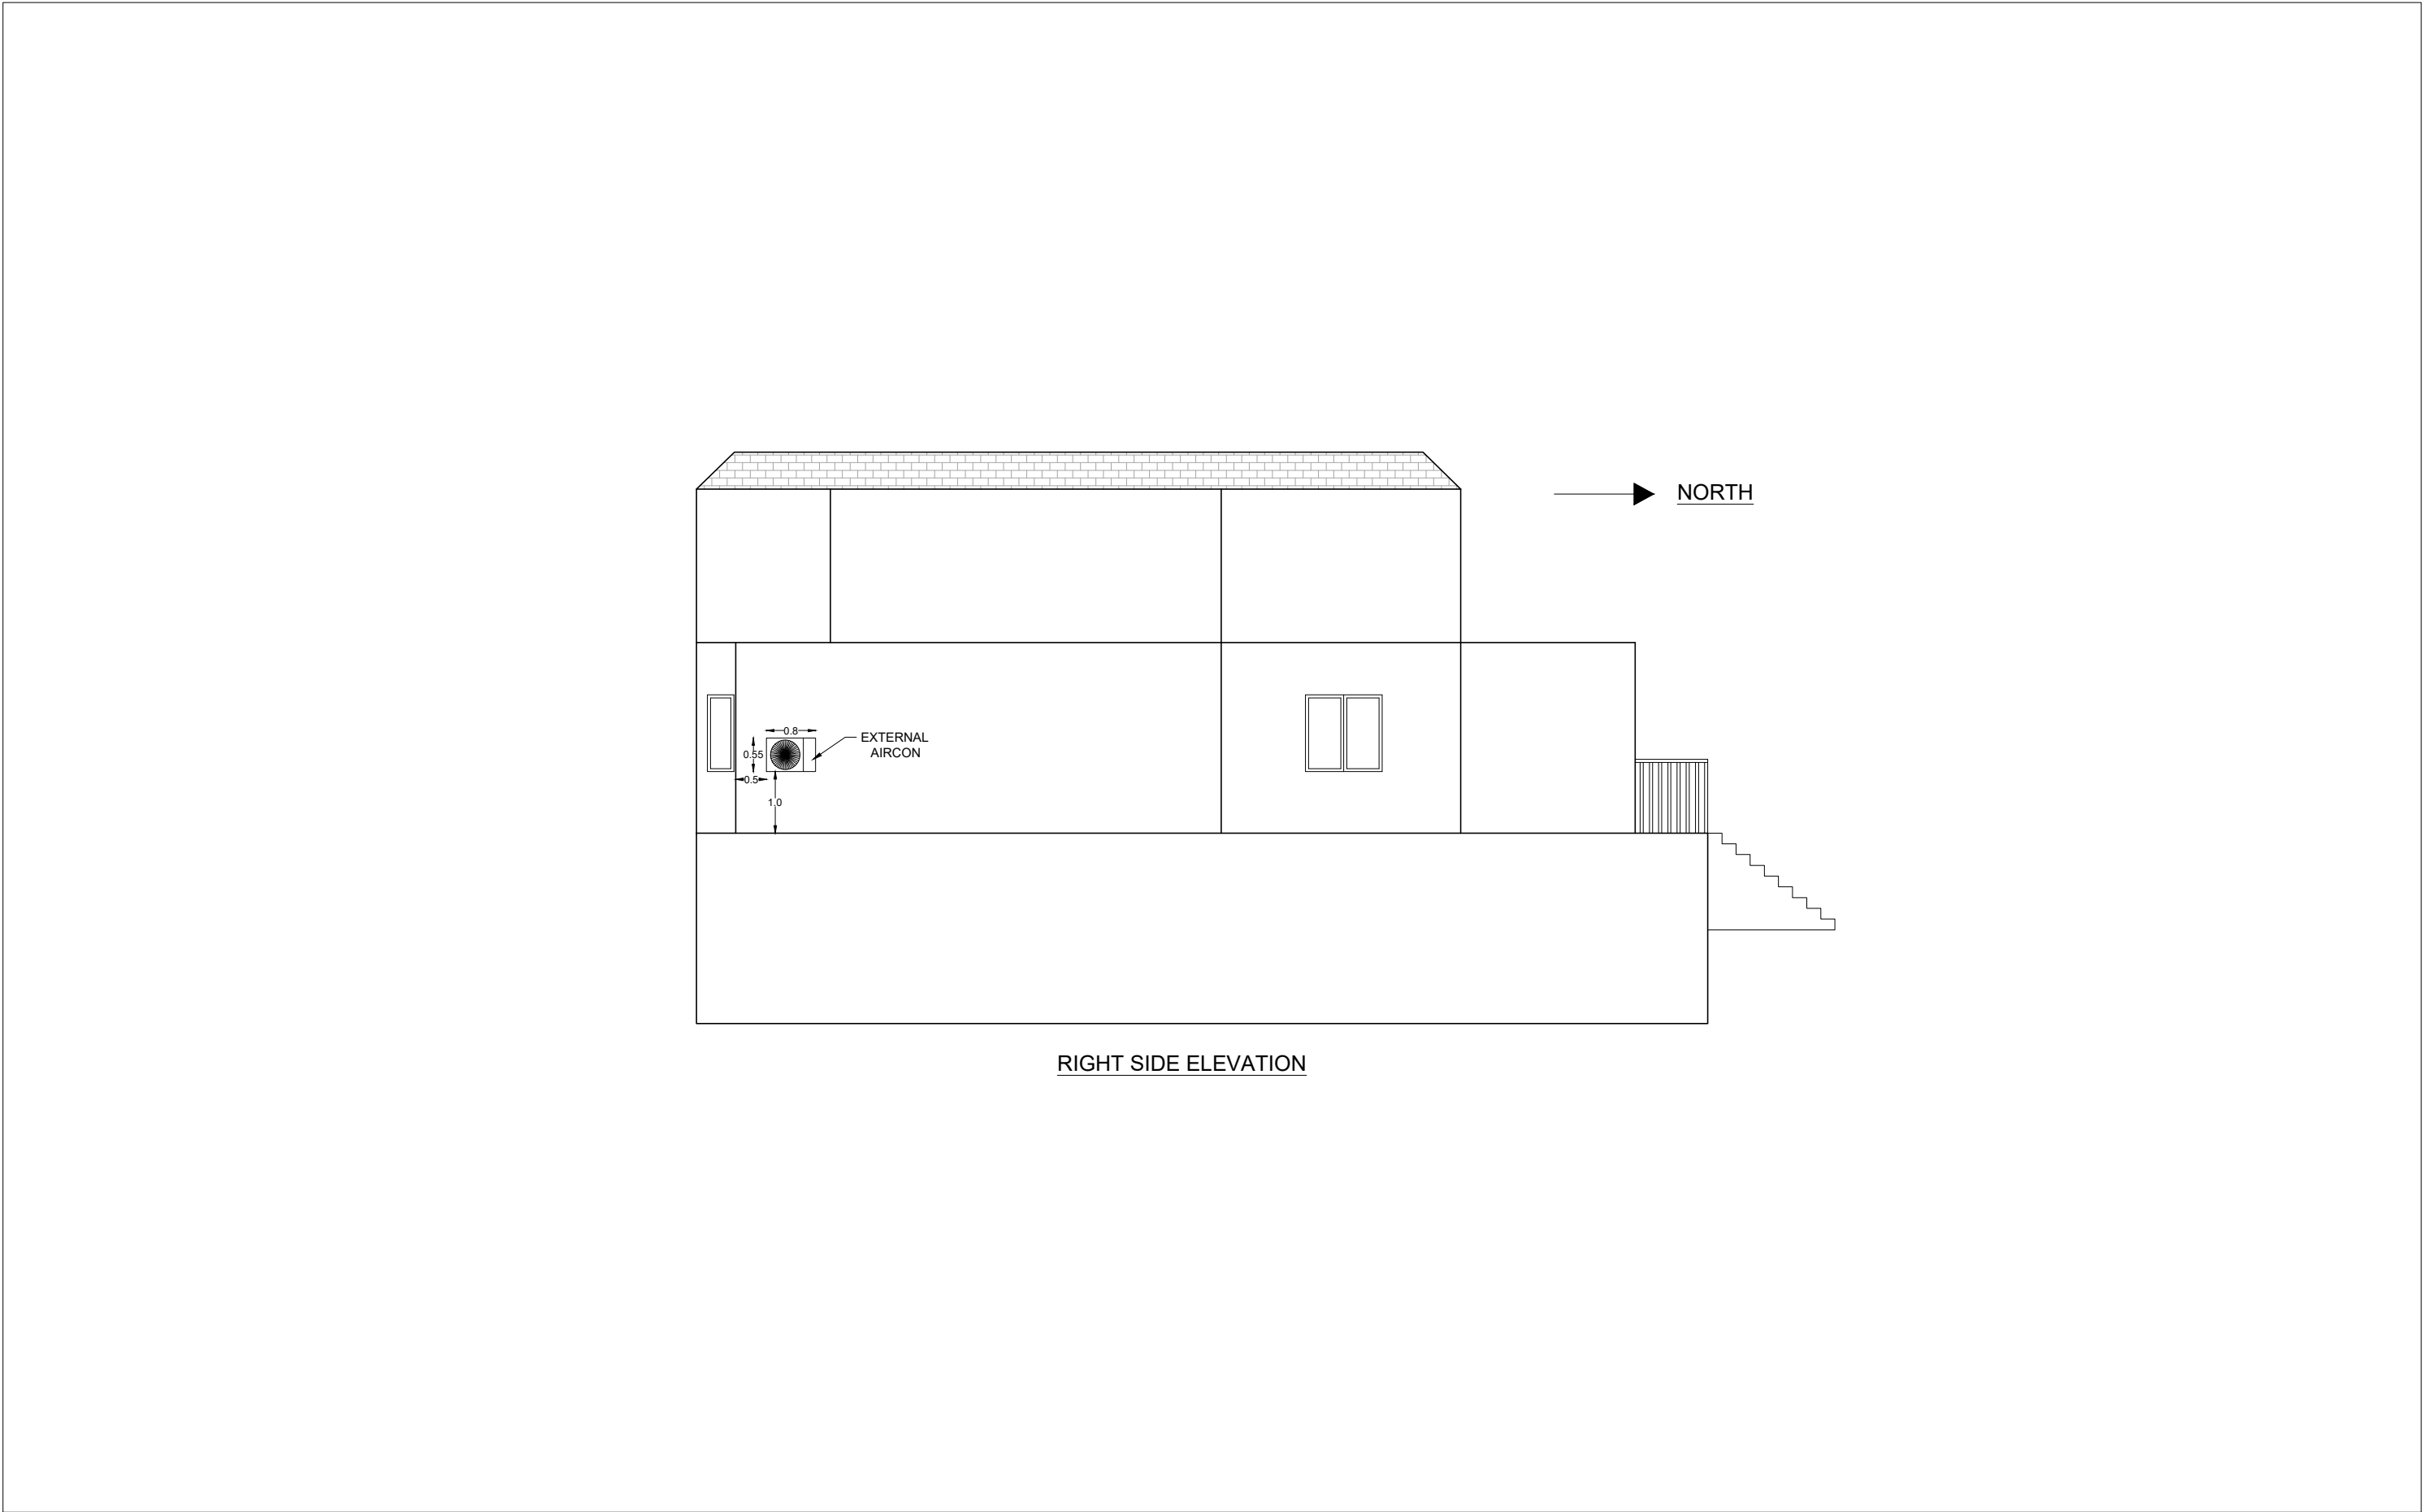

RIGHT SIDE ELEVATION

Project 2 INTERNAL 1 EXTERNAL AIRCONS INSTALLMENT		Structure	-----	Drg. Title	Drawn by	Date	Scale
		Plumbing	-----	ELEVATION	ALIZA AYMAN ANSARI		1 : 100
		Electrical	-----	Drg. Status	Drg. Issued	Revision	Sheet size:
		Contractor	-----		---	00	A3

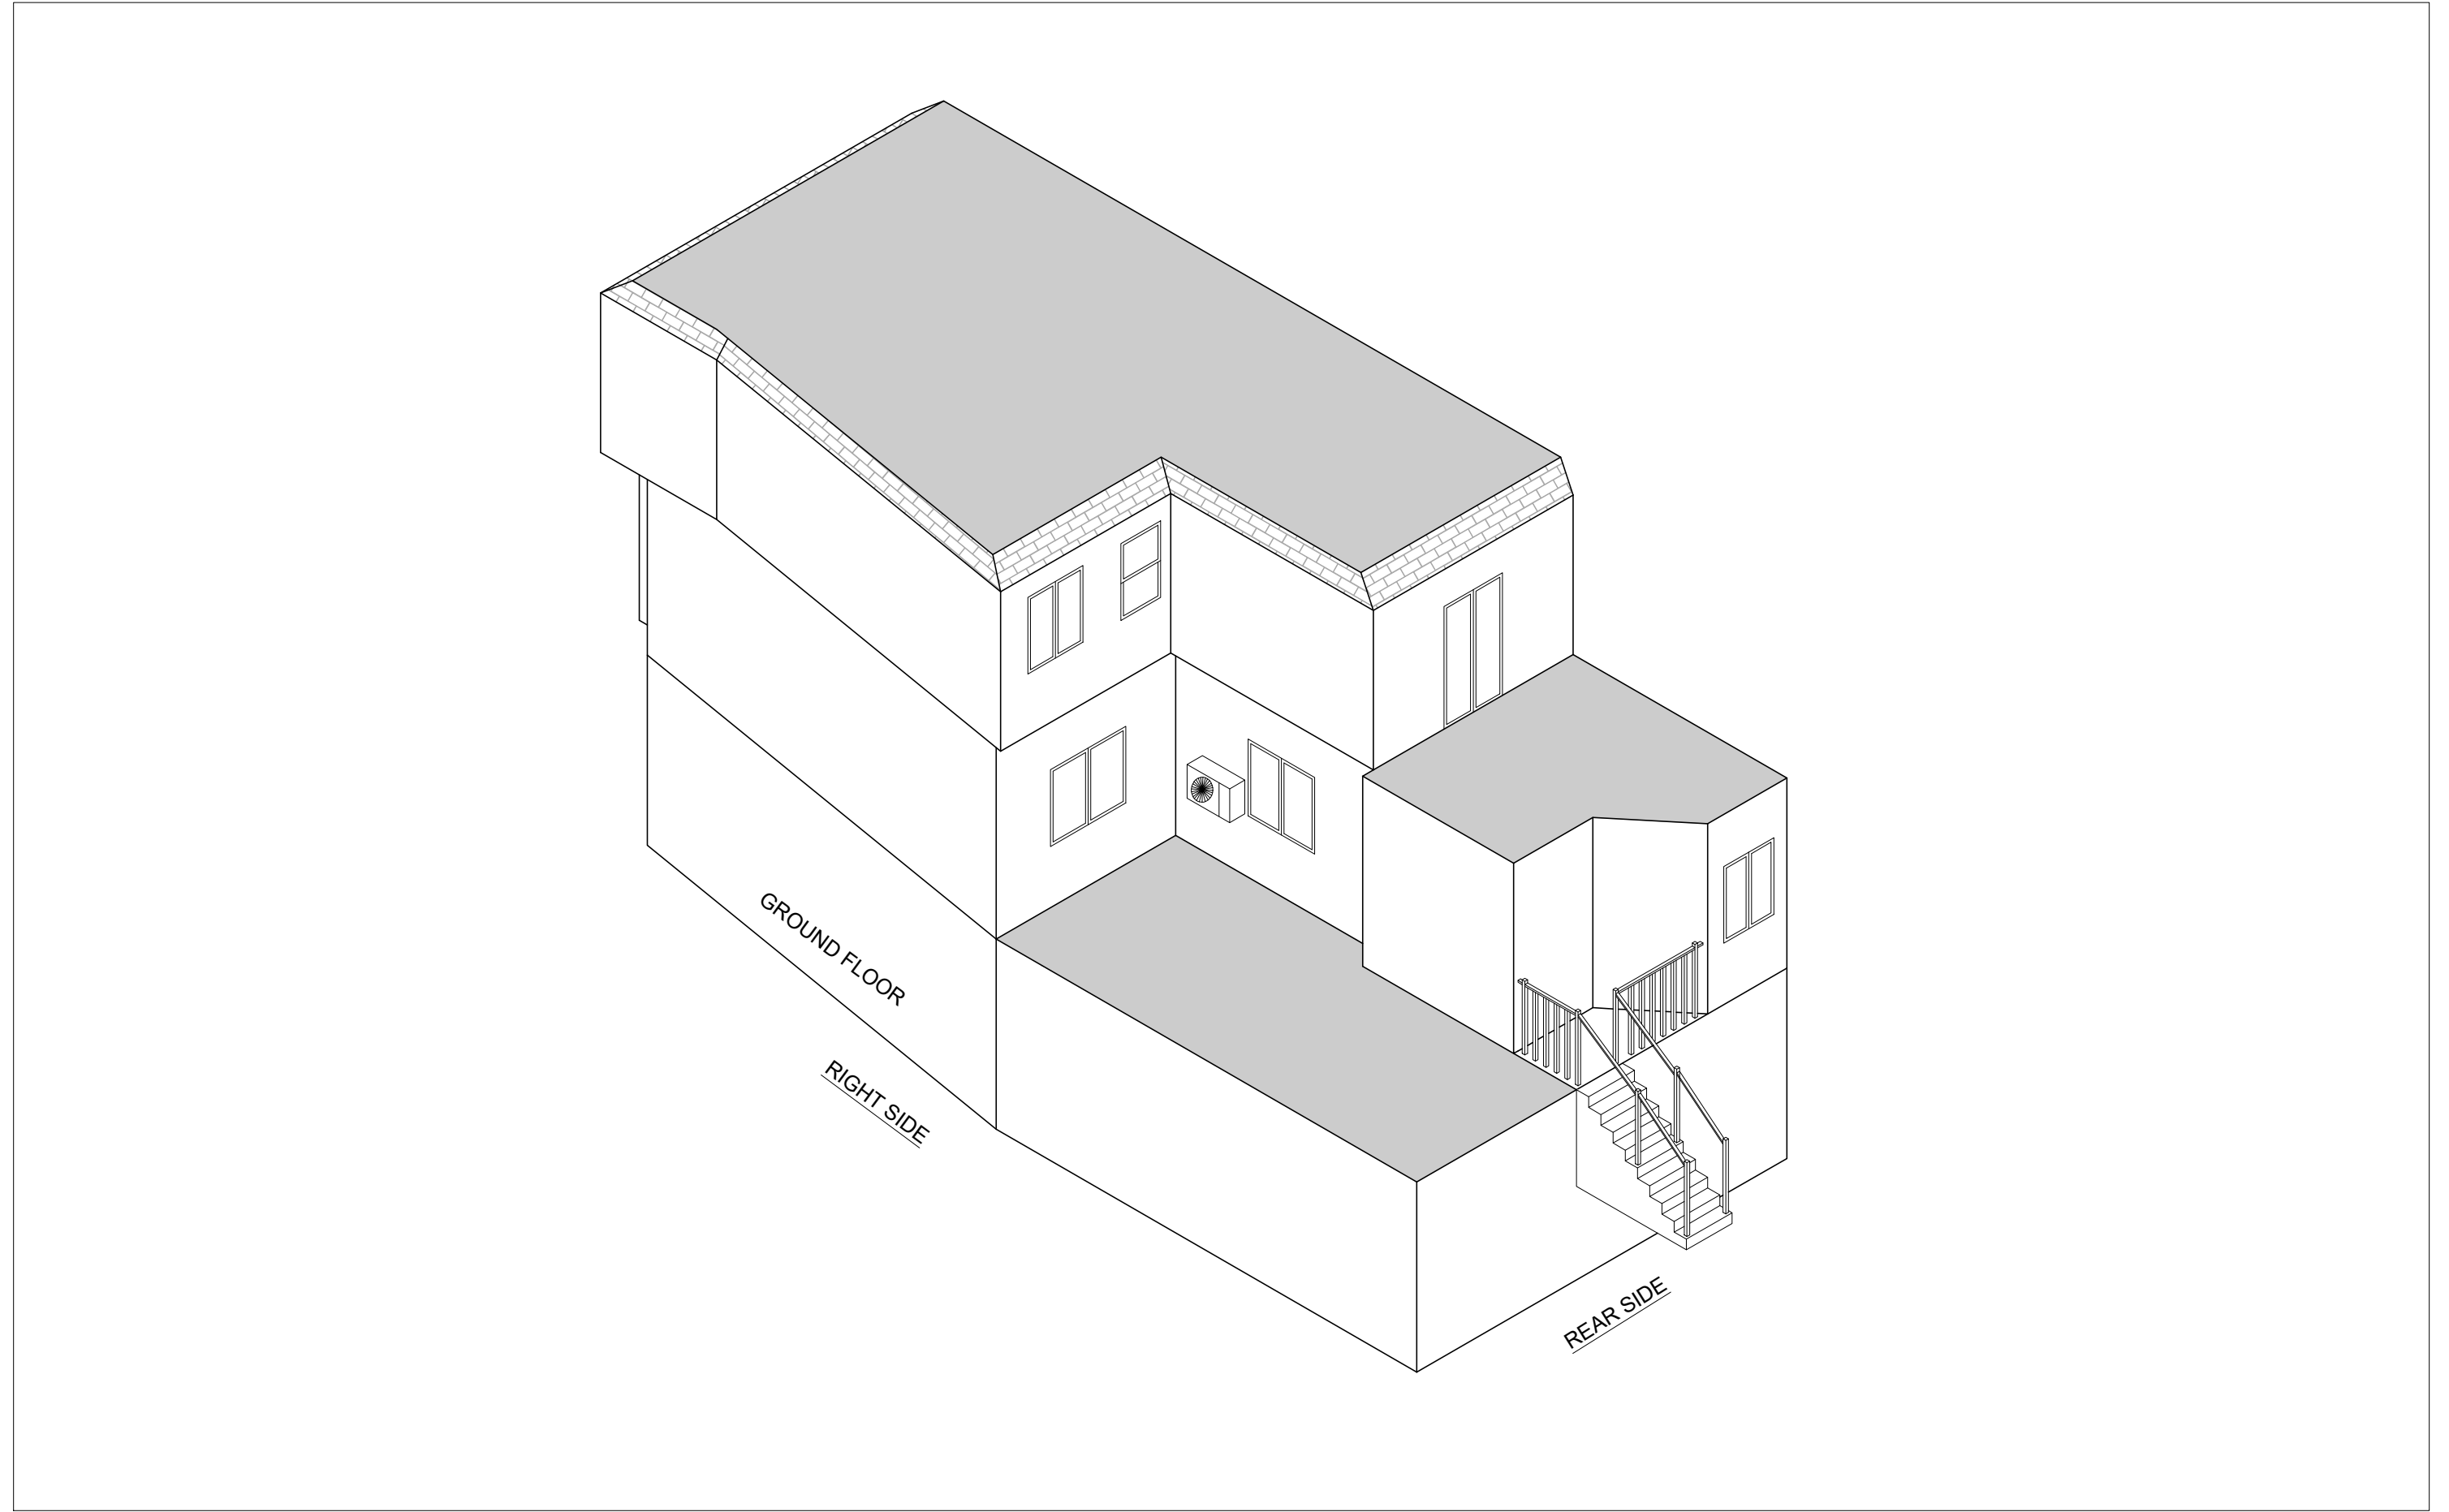

Project 2 INTERNAL 1 EXTERNAL AIRCONS INSTALLMENT		Structure	----	Drg. Title	Drawn by	Date	Scale 1 : 100
		Plumbing	----	FLOOR PLAN	ISOMETRIC VIEW		
		Electrical	----	Drg. Status	Drg. Issued	Revision	Sheet size:
		Contractor	----		---	00	A3