


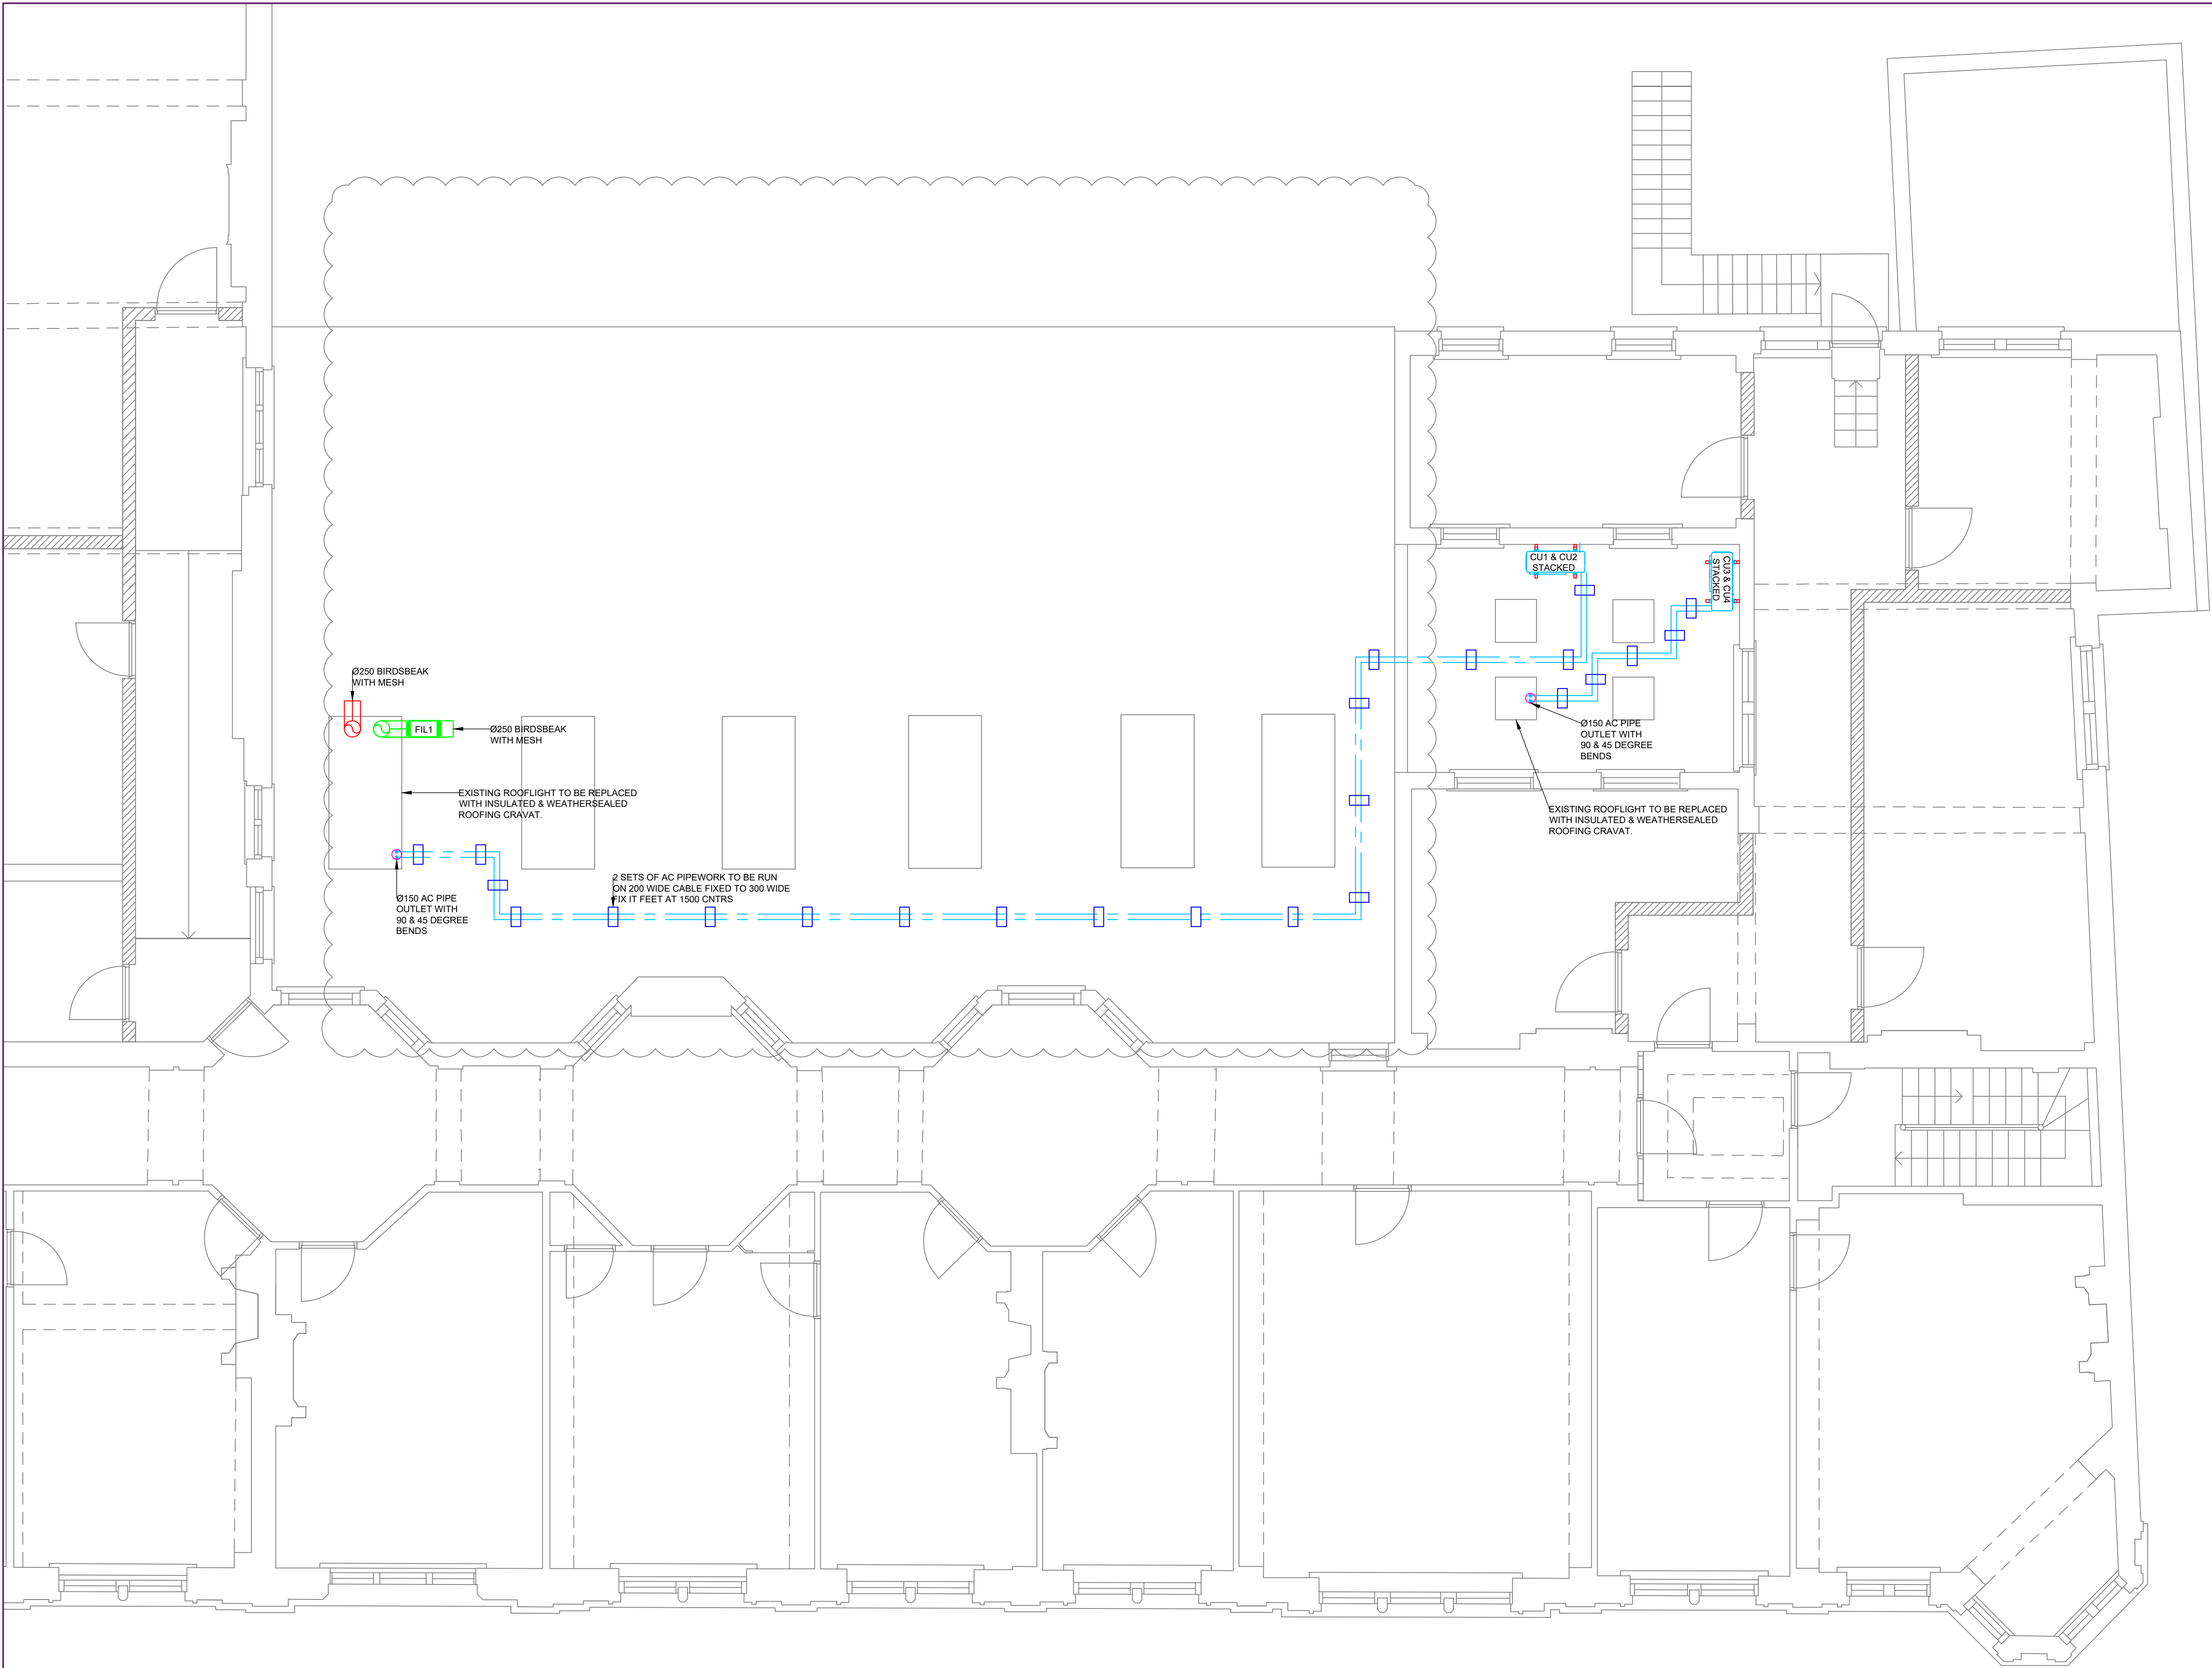

DUCTWORK COLOUR KEY		
—	EXTRACT EXHAUST AIR	
—	EXTRACT RETURN AIR	
—	FRESH AIR SUPPLY (PRIMARY)	
—	FRESH AIR INLET	
—	AC SUPPLY AIR (SECONDARY)	
—	TOILET EXTRACT	

REV	REVISION DESCRIPTION	REV DATE
A	REVISED HVAC LAYOUT DUE TO SITE MTG 11.04.23	23.04.23



Spiritus
Technical Services Ltd

1 BRADDOCK COURT
BASINGSTOKE
HAMPSHIRE
RG21 6AS

M:07889 605592
E: CRAIG@SPIRITUSTECHNICALSERVICES.CO.UK

CLIENT:
GS CONTRACTS LTD

SITE:
THE TRAMPERY
639 HIGH ROAD
LONDON. N17 8AA

DRAWING TITLE:
PROPOSED HVAC FIRST FLOOR FLAT
ROOF LAYOUT

DRAWN BY: CB	DATE: 01.04.2022	SCALE: 1:50 @ A1
DRAWING NUMBER: STS0638-M02	REVISION: A	
DRAWING STATUS: FOR COMMENT		

