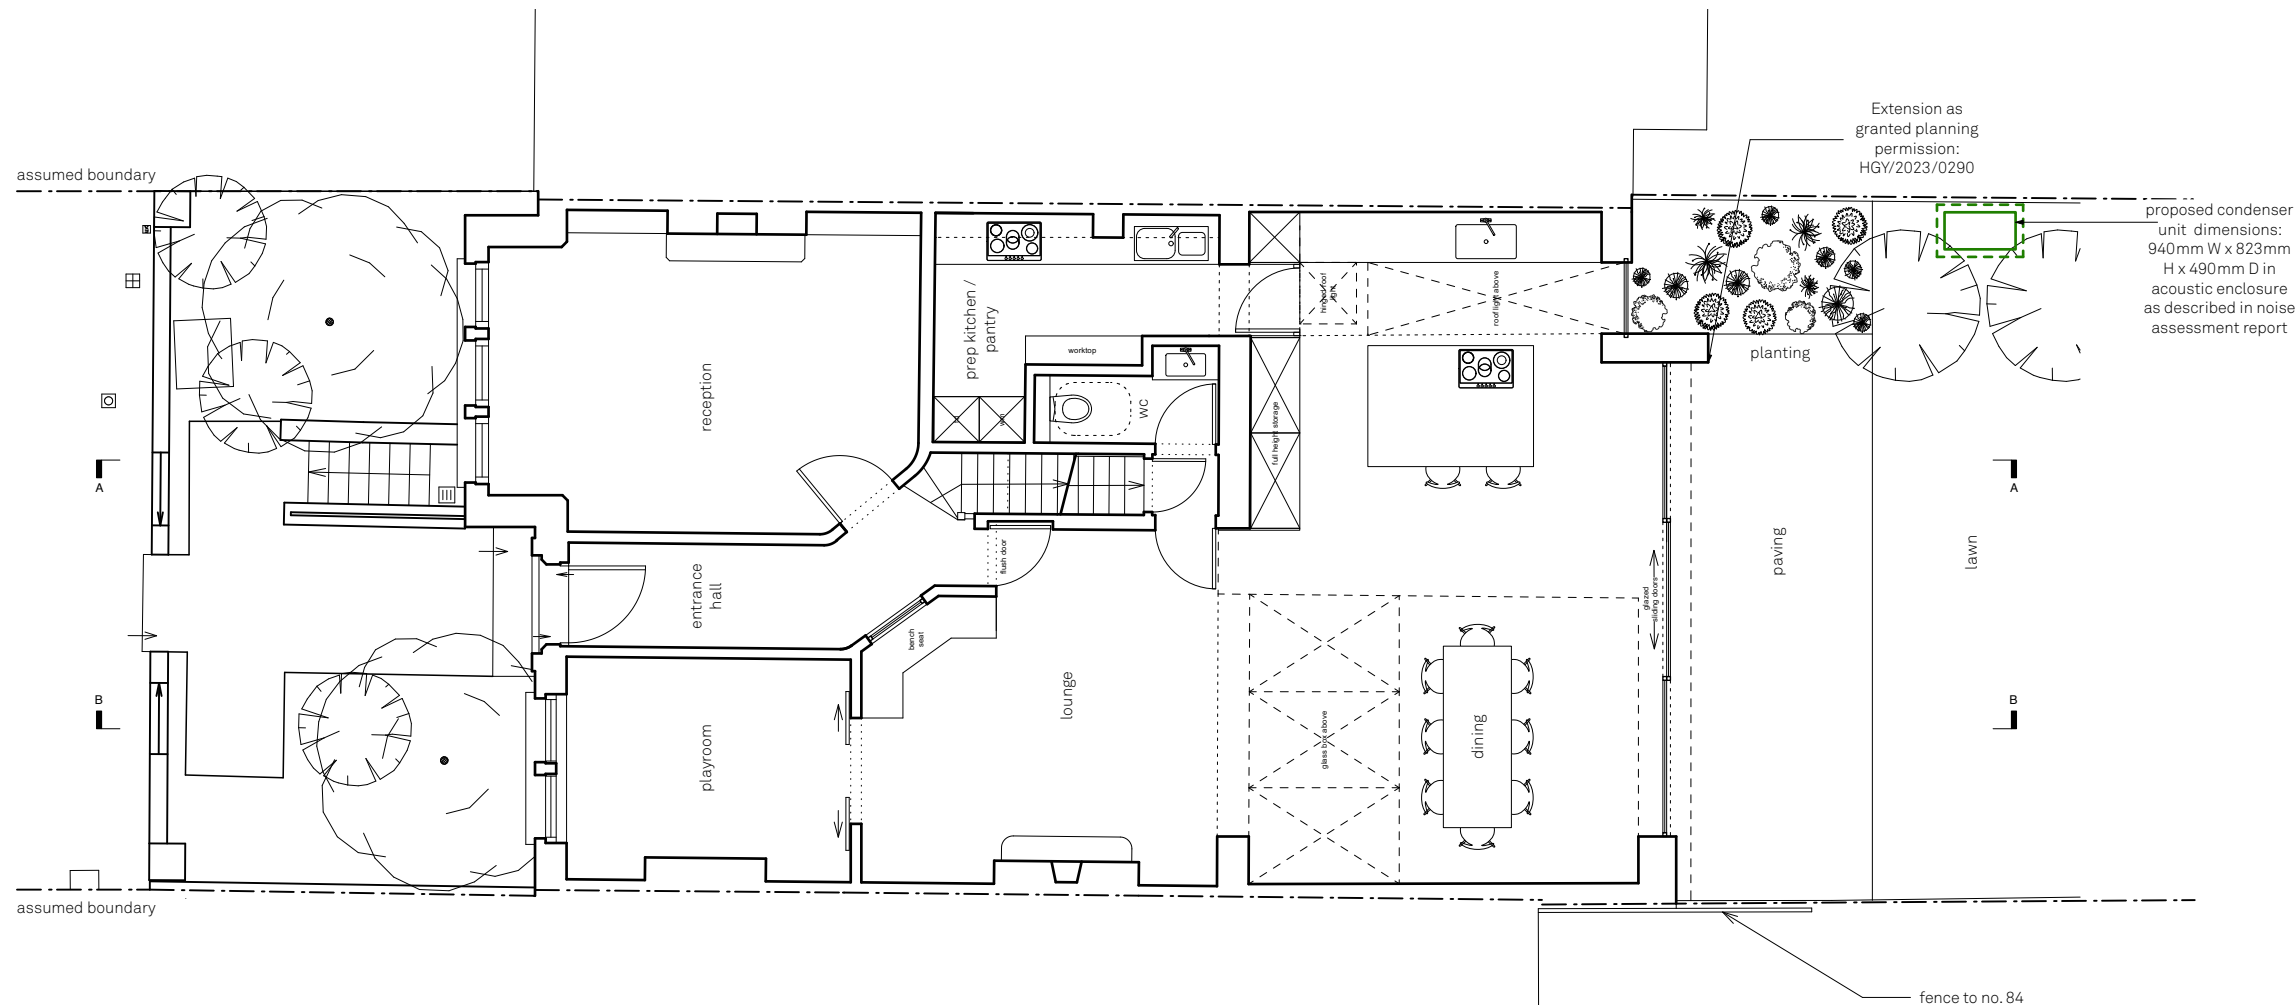


 Proposed air conditioning condenser unit

Proposed GF Plan

Muswell House

86 Muswell Road

Drawn By

WM/KO

Scale

1:100

Status

Project Stage

Planning

Issue Notes

Date

Paul Archer Design Ltd


Unit D204 Lana House 116 Commercial Street London E1 6NF

Tel. 020 3668 2668


896.217

paul archer
design

www.paularcherdesign.co.uk

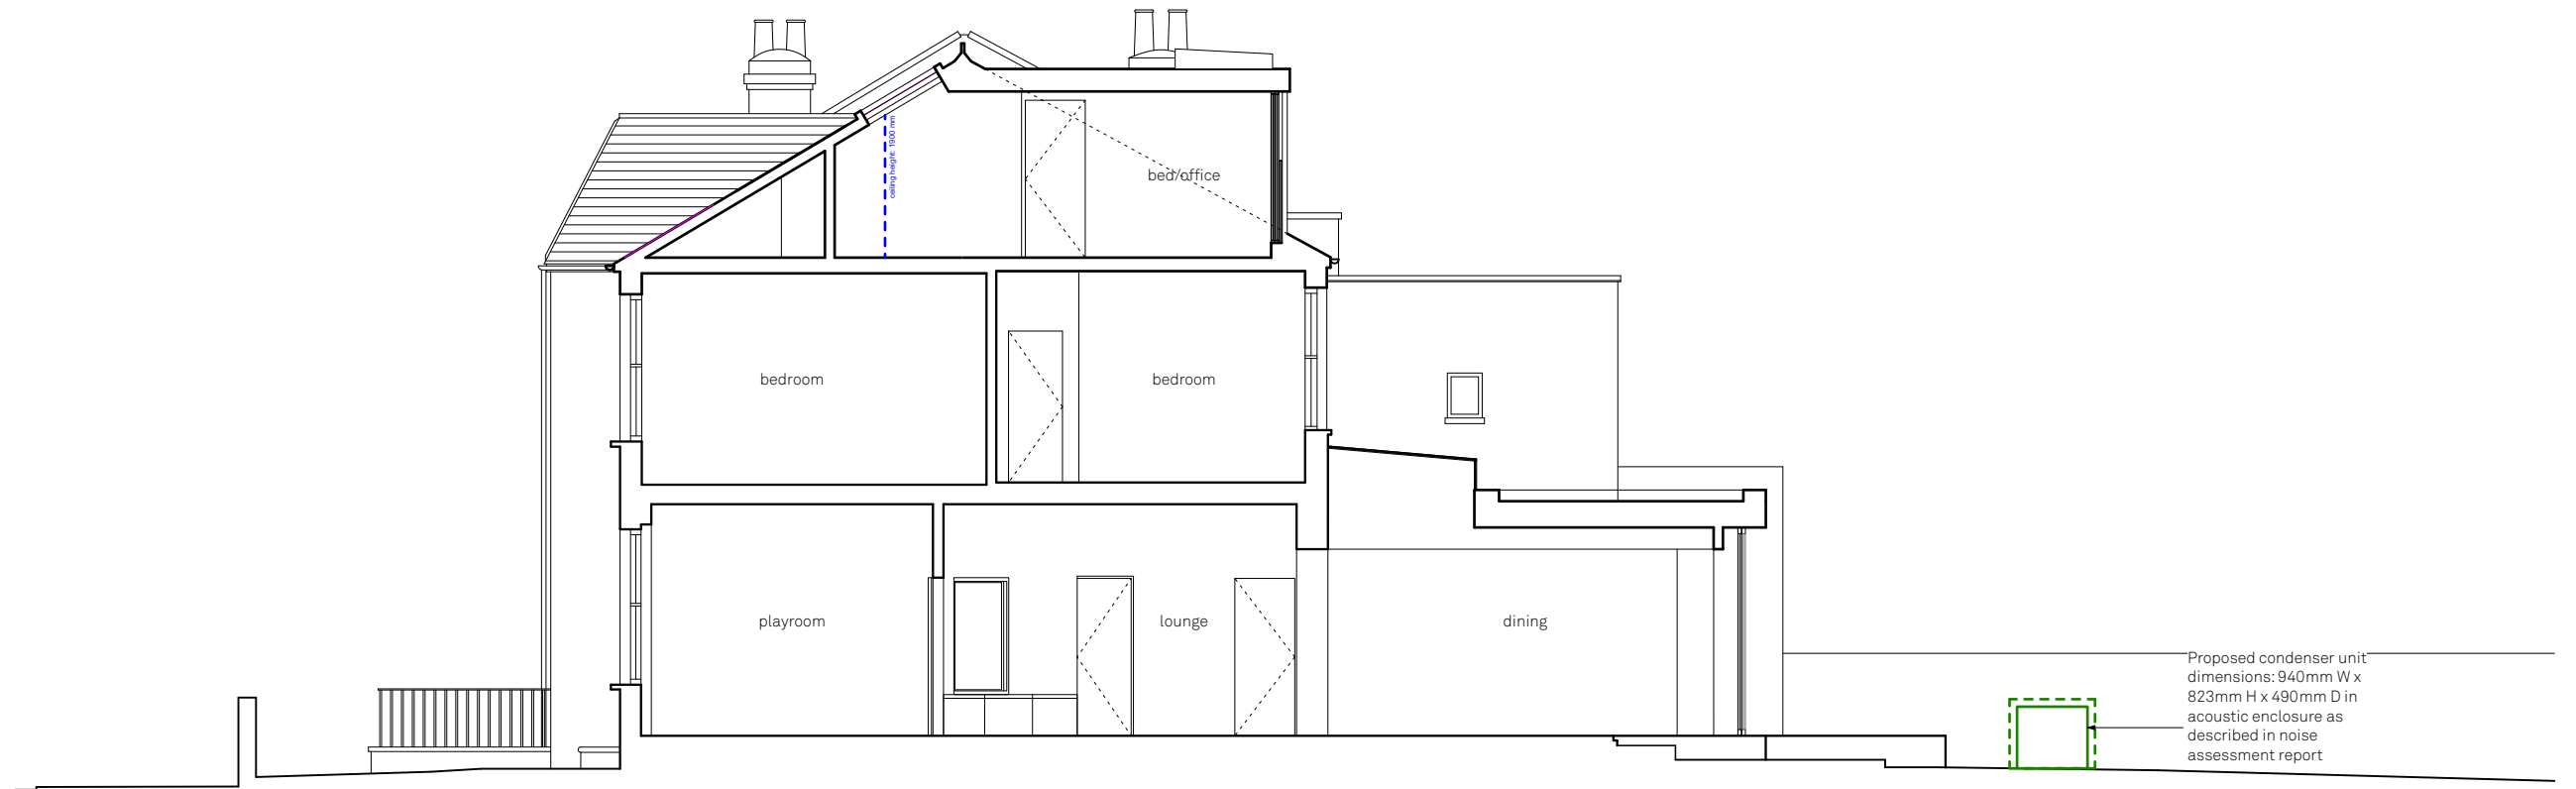

Proposed condenser unit
dimensions: 940mm W x
823mm H x 490mm D in
acoustic enclosure as
described in noise
assessment report

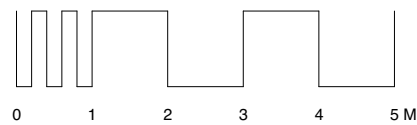

 Proposed air conditioning condenser unit

Proposed Section

Muswell House
86 Muswell Road
Drawn By WM/KO
Scale 1:100
Status
Project Stage Planning

Paul Archer Design Ltd


Issue	Notes	Date
-------	-------	------

Unit D204 Lana House 116 Commercial Street London E1 6NF Tel. 020 3668 2668

896.218

paul archer
design

www.paularcherdesign.co.uk

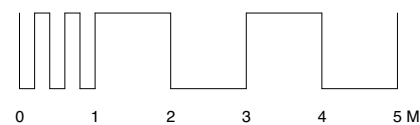

 Proposed air conditioning condenser unit

Proposed Rear Elevation

Muswell House
86 Muswell Road
Drawn By WM/KO
Scale 1:100
Status
Project Stage Planning

Issue	Notes	Date
-------	-------	------

Paul Archer Design Ltd

Unit D204 Lana House 116 Commercial Street London E1 6NF

Tel. 020 3668 2668

896.219

paul archer
design

www.paularcherdesign.co.uk