




Project No.	AR0699	
Dwg No.	AR-PL-2001	
Revision	A	
Scale at A3	1:100	
Date	11-10-'23	
Designed	SS	Checked AC
Drawn	SS	Approved AC

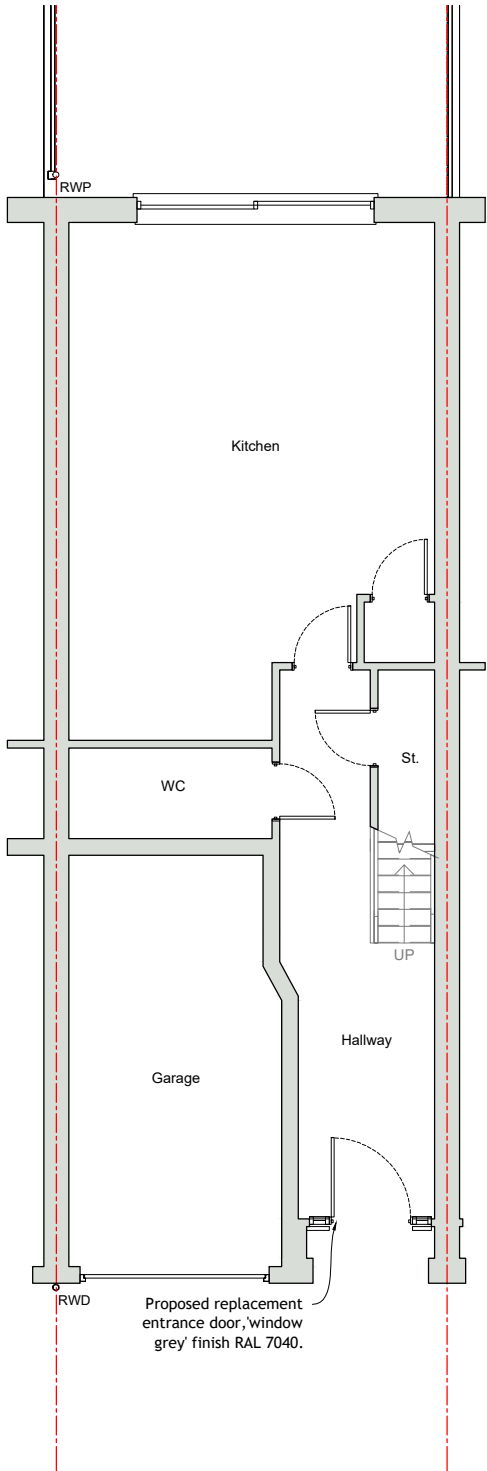

Proposed Ground Floor Plan
Scale 1:100

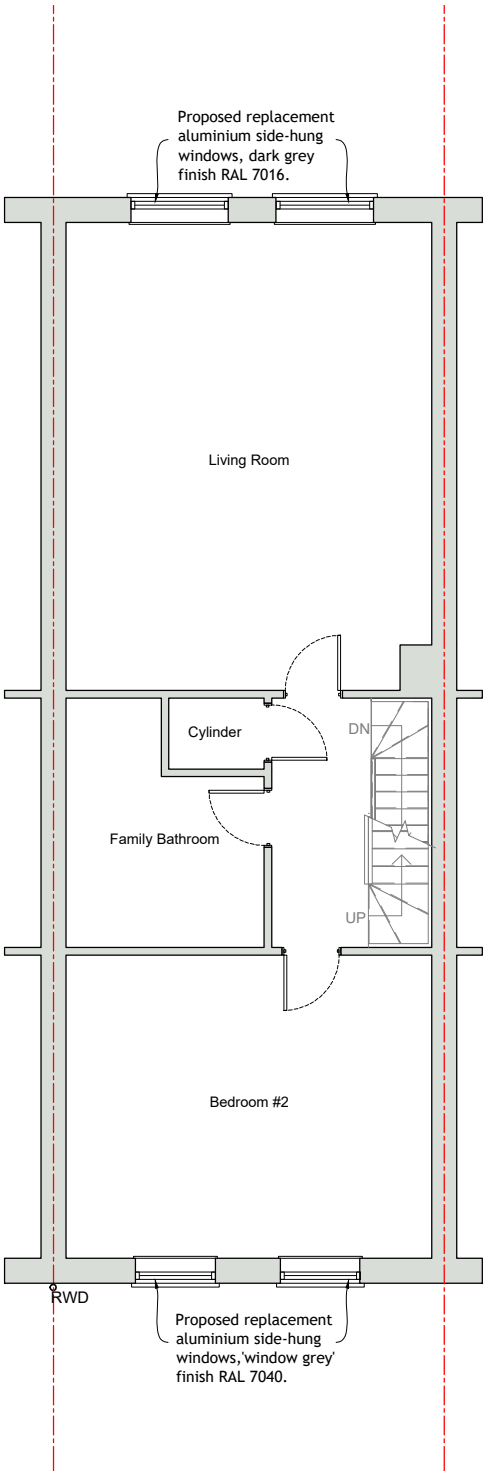

Proposed First Floor Plan
Scale 1:100

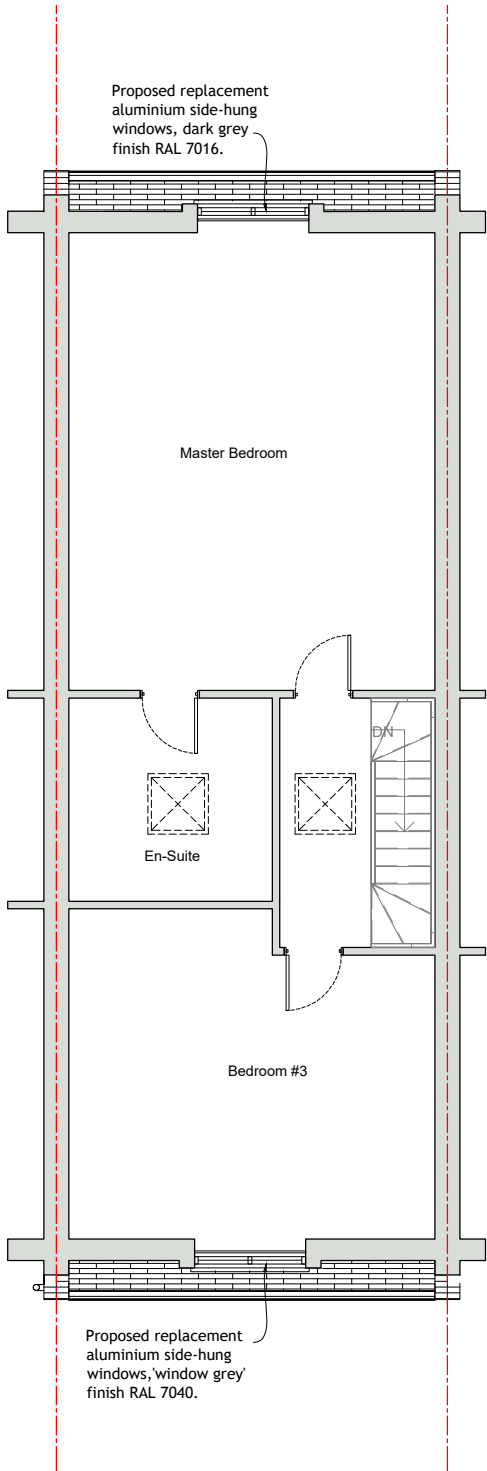

Proposed Second Floor Plan
Scale 1:100

