

FACILITY TYPE

FOOTBALL AND RUGBY ONLY
NON-INFILL SYNTHETIC TURF PITCH PLAYZONE
WITH PERIMETER FENCING, FLOODLIGHTING,
HARD-STANDING AREA AND EQUIPMENT

CONSTRUCTION

40mm 3G NON-INFILL SYNTHETIC TURF
15mm PREFABRICATED SHOCKPAD
250mm SUB BASE (INC BLINDING LAYER)
FORMATION LAYER

DIMENSIONS

FENCE TO FENCE = 30 X 20m
2NR GOAL RECESSES = 3.66 X 1m
SPECTATOR AREA = 30 X 2m
ACCESS ROUTE = NEW POROUS ASPHALT PATH

LINE MARKING

GOAL BOXES = 10.0 X 5.0m
GOAL LINE = 3.66Lm
CENTRE LINE = 20Lm
CENTRE CIRCLE = 0.2M RADIUS
TRY LINE = 2NR 20Lm

PERIMETER FENCING

3m NEW TWIN BAR PANEL FENCING
2NR SINGLE GATE ACCESS
1 NR DOUBLE GATES
COLOUR RAL6005 - DARK GREEN
4m NEW FENCING OVER GOALS - WHITE
BALL STOP NETTING OVER FENCING TO
SOUTHERN END TOTAL HEIGHT OF NETTING 5m

LED FLOODLIGHTING

8.0m HIGH STAND ALONE FLOODLIGHT COLUMNS
4NR LUMINAIRES)
AVERAGE LUX = 120LUX
UNIFORMITY = 0.65
(LIGHTING PLAN SEPARATE)

STREET LIGHTING


8 NR STREET LIGHTS TO EXISTING PATHS

EQUIPMENT

2NR GOALS (INTEGRAL TO FENCING)
2NR BENCHES
2NR WASTE BINS
1NR STORAGE CONTAINER

AFTER CARE

BI-MONTHLY VISITS REQUIRED FOR DURATION
OF END OF DEFECTS PERIOD (6NR VISITS)

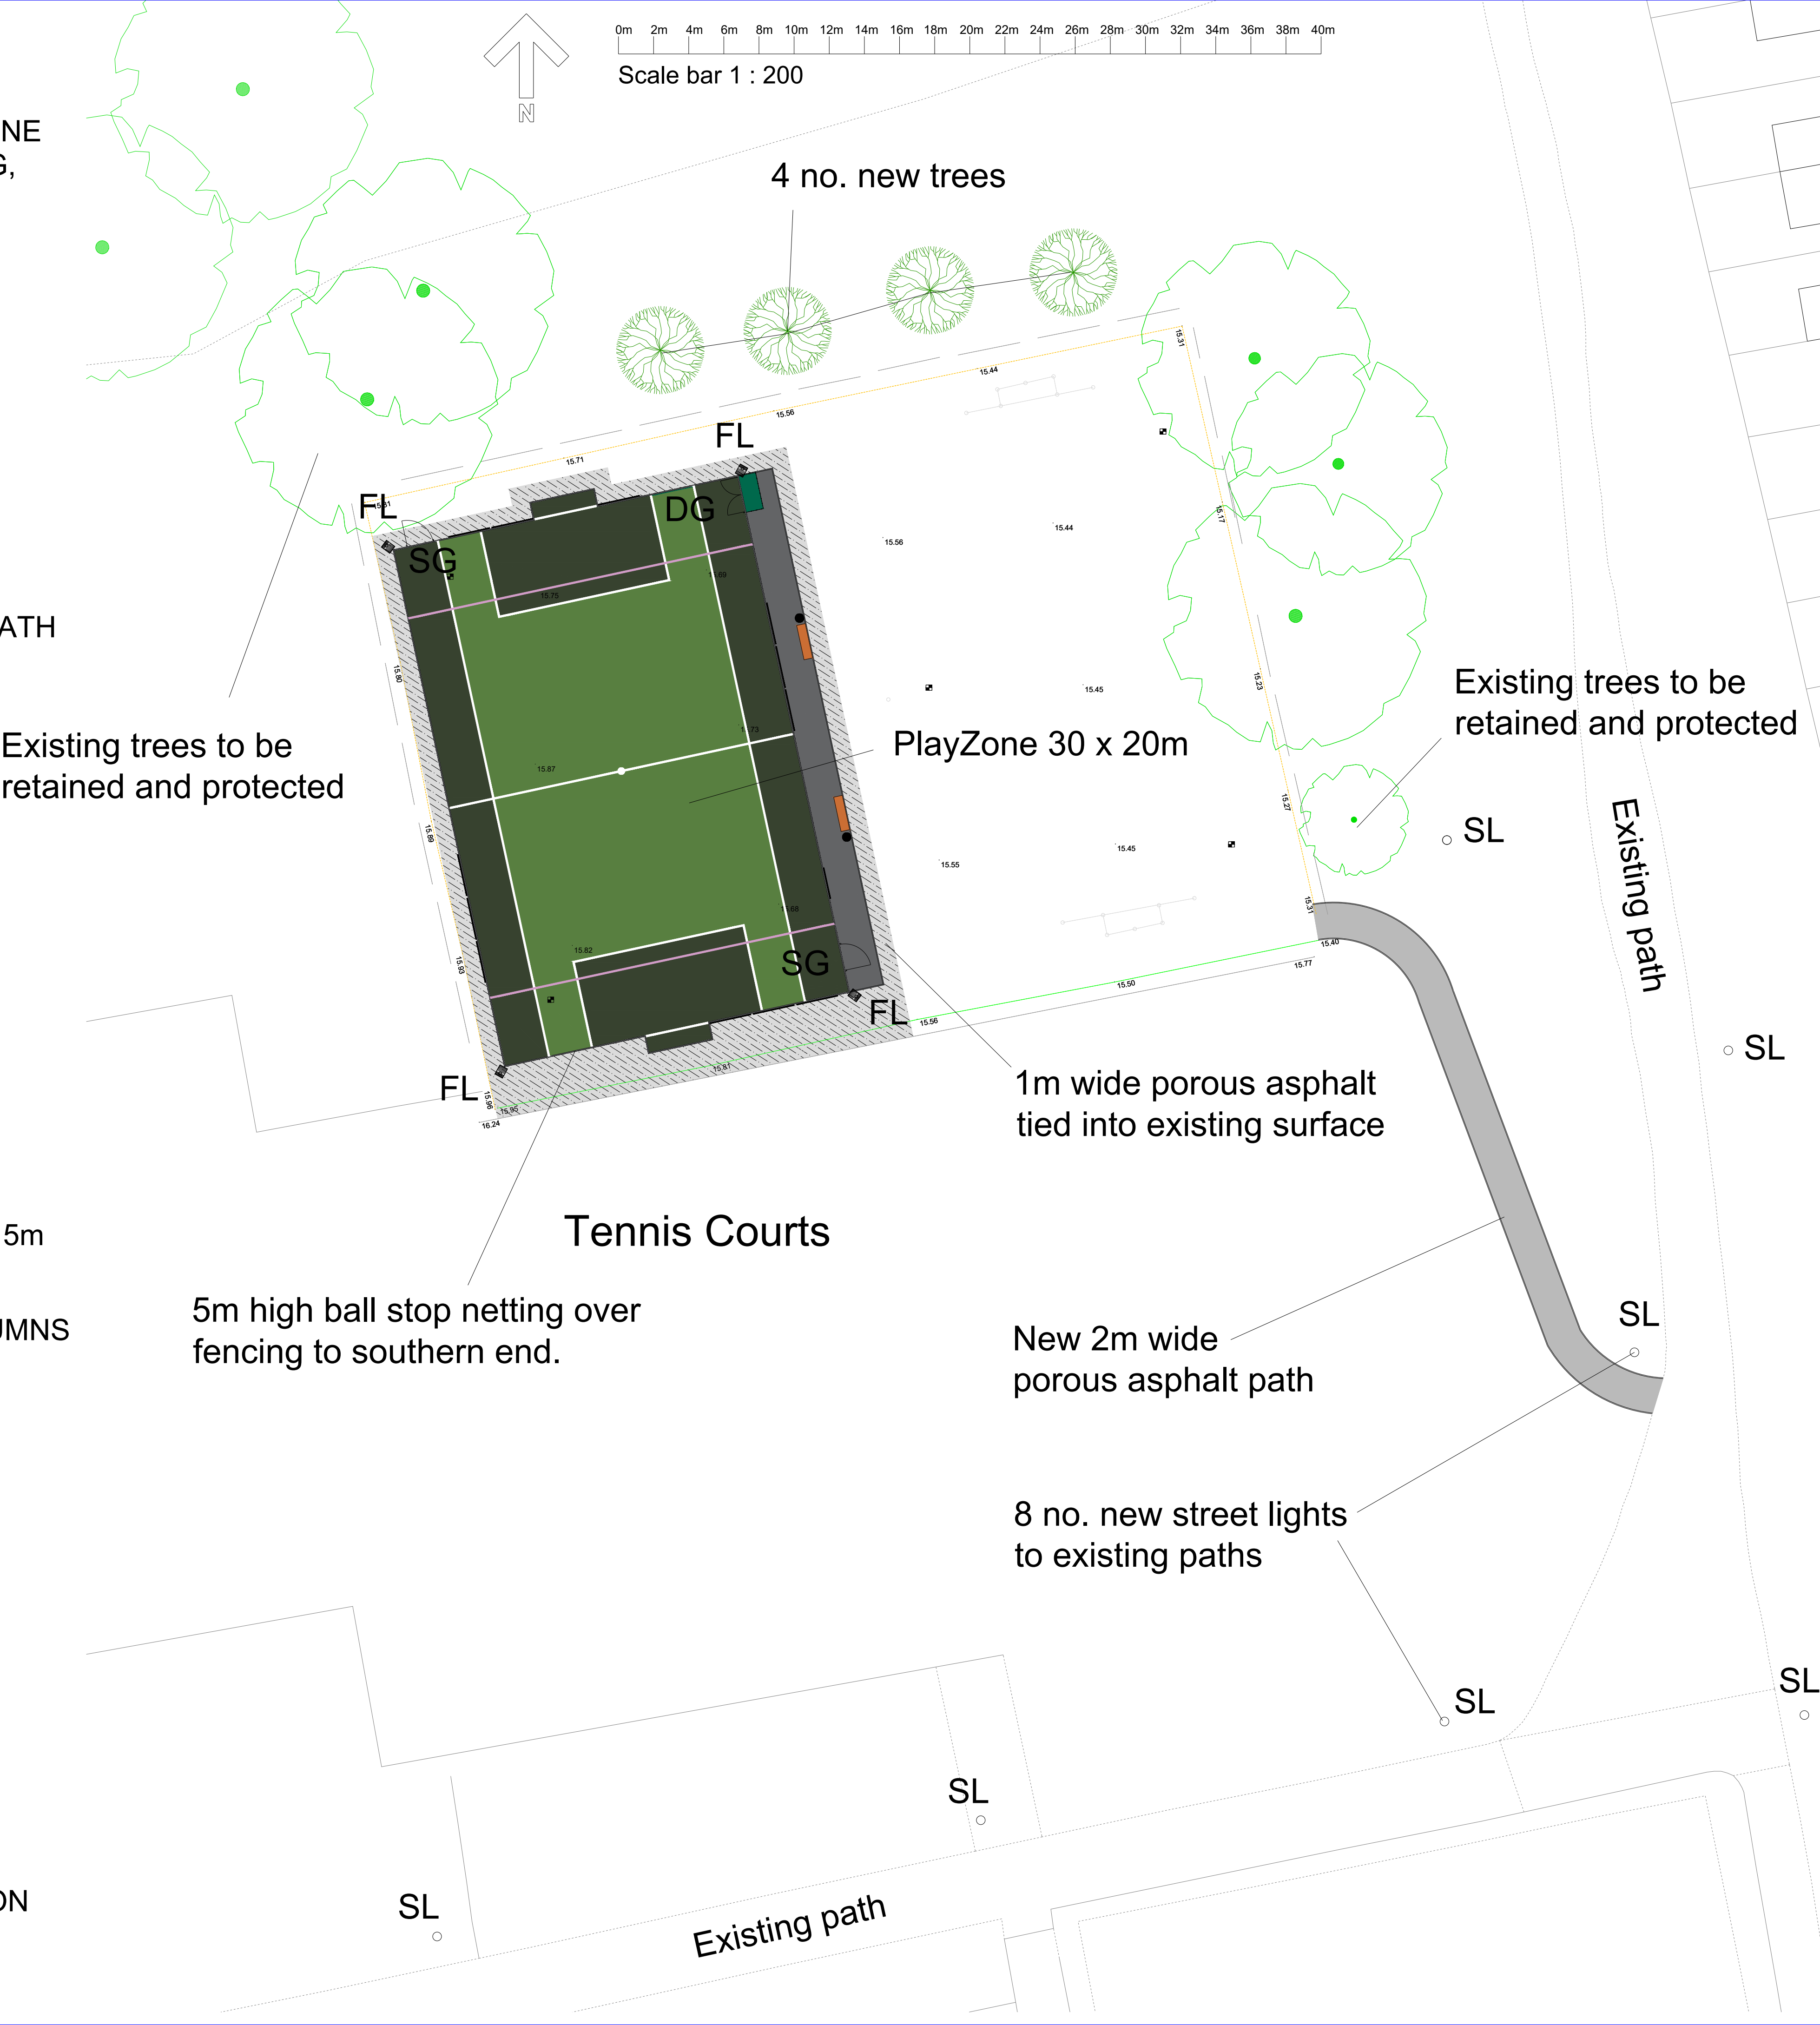

NOTES	
	PAINTED MACADAM SURFACE
	MACADAM SPECTATOR AREA AND ACCESS
DG	DOUBLE GATE
SG	SINGLE GATE
FL	FLOODLIGHT
SL	STREET LIGHT
FOR PLAYZONE AND PATHWAY LIGHTING DETAILS REFER TO LIGHTING DESIGNS.	

Initial Issue					
Rev	A	m	e	n	d
	m	e	n	t	
		Date		By	
Client					
LONDON BOROUGH HARINGEY					
Project					
BRUCE CASTLE PARK PLAYZONE					
Drawing					
PROPOSED LAYOUT WITH PATH					
McARDLE SPORT TEC					
Drawn	NJM		Date	15-07-24	
Checked	01		Plot No	01	
			Prelim	Check	Final
Job No			Drawing No	MCA-MUK3299-02	
			Rev	F	