



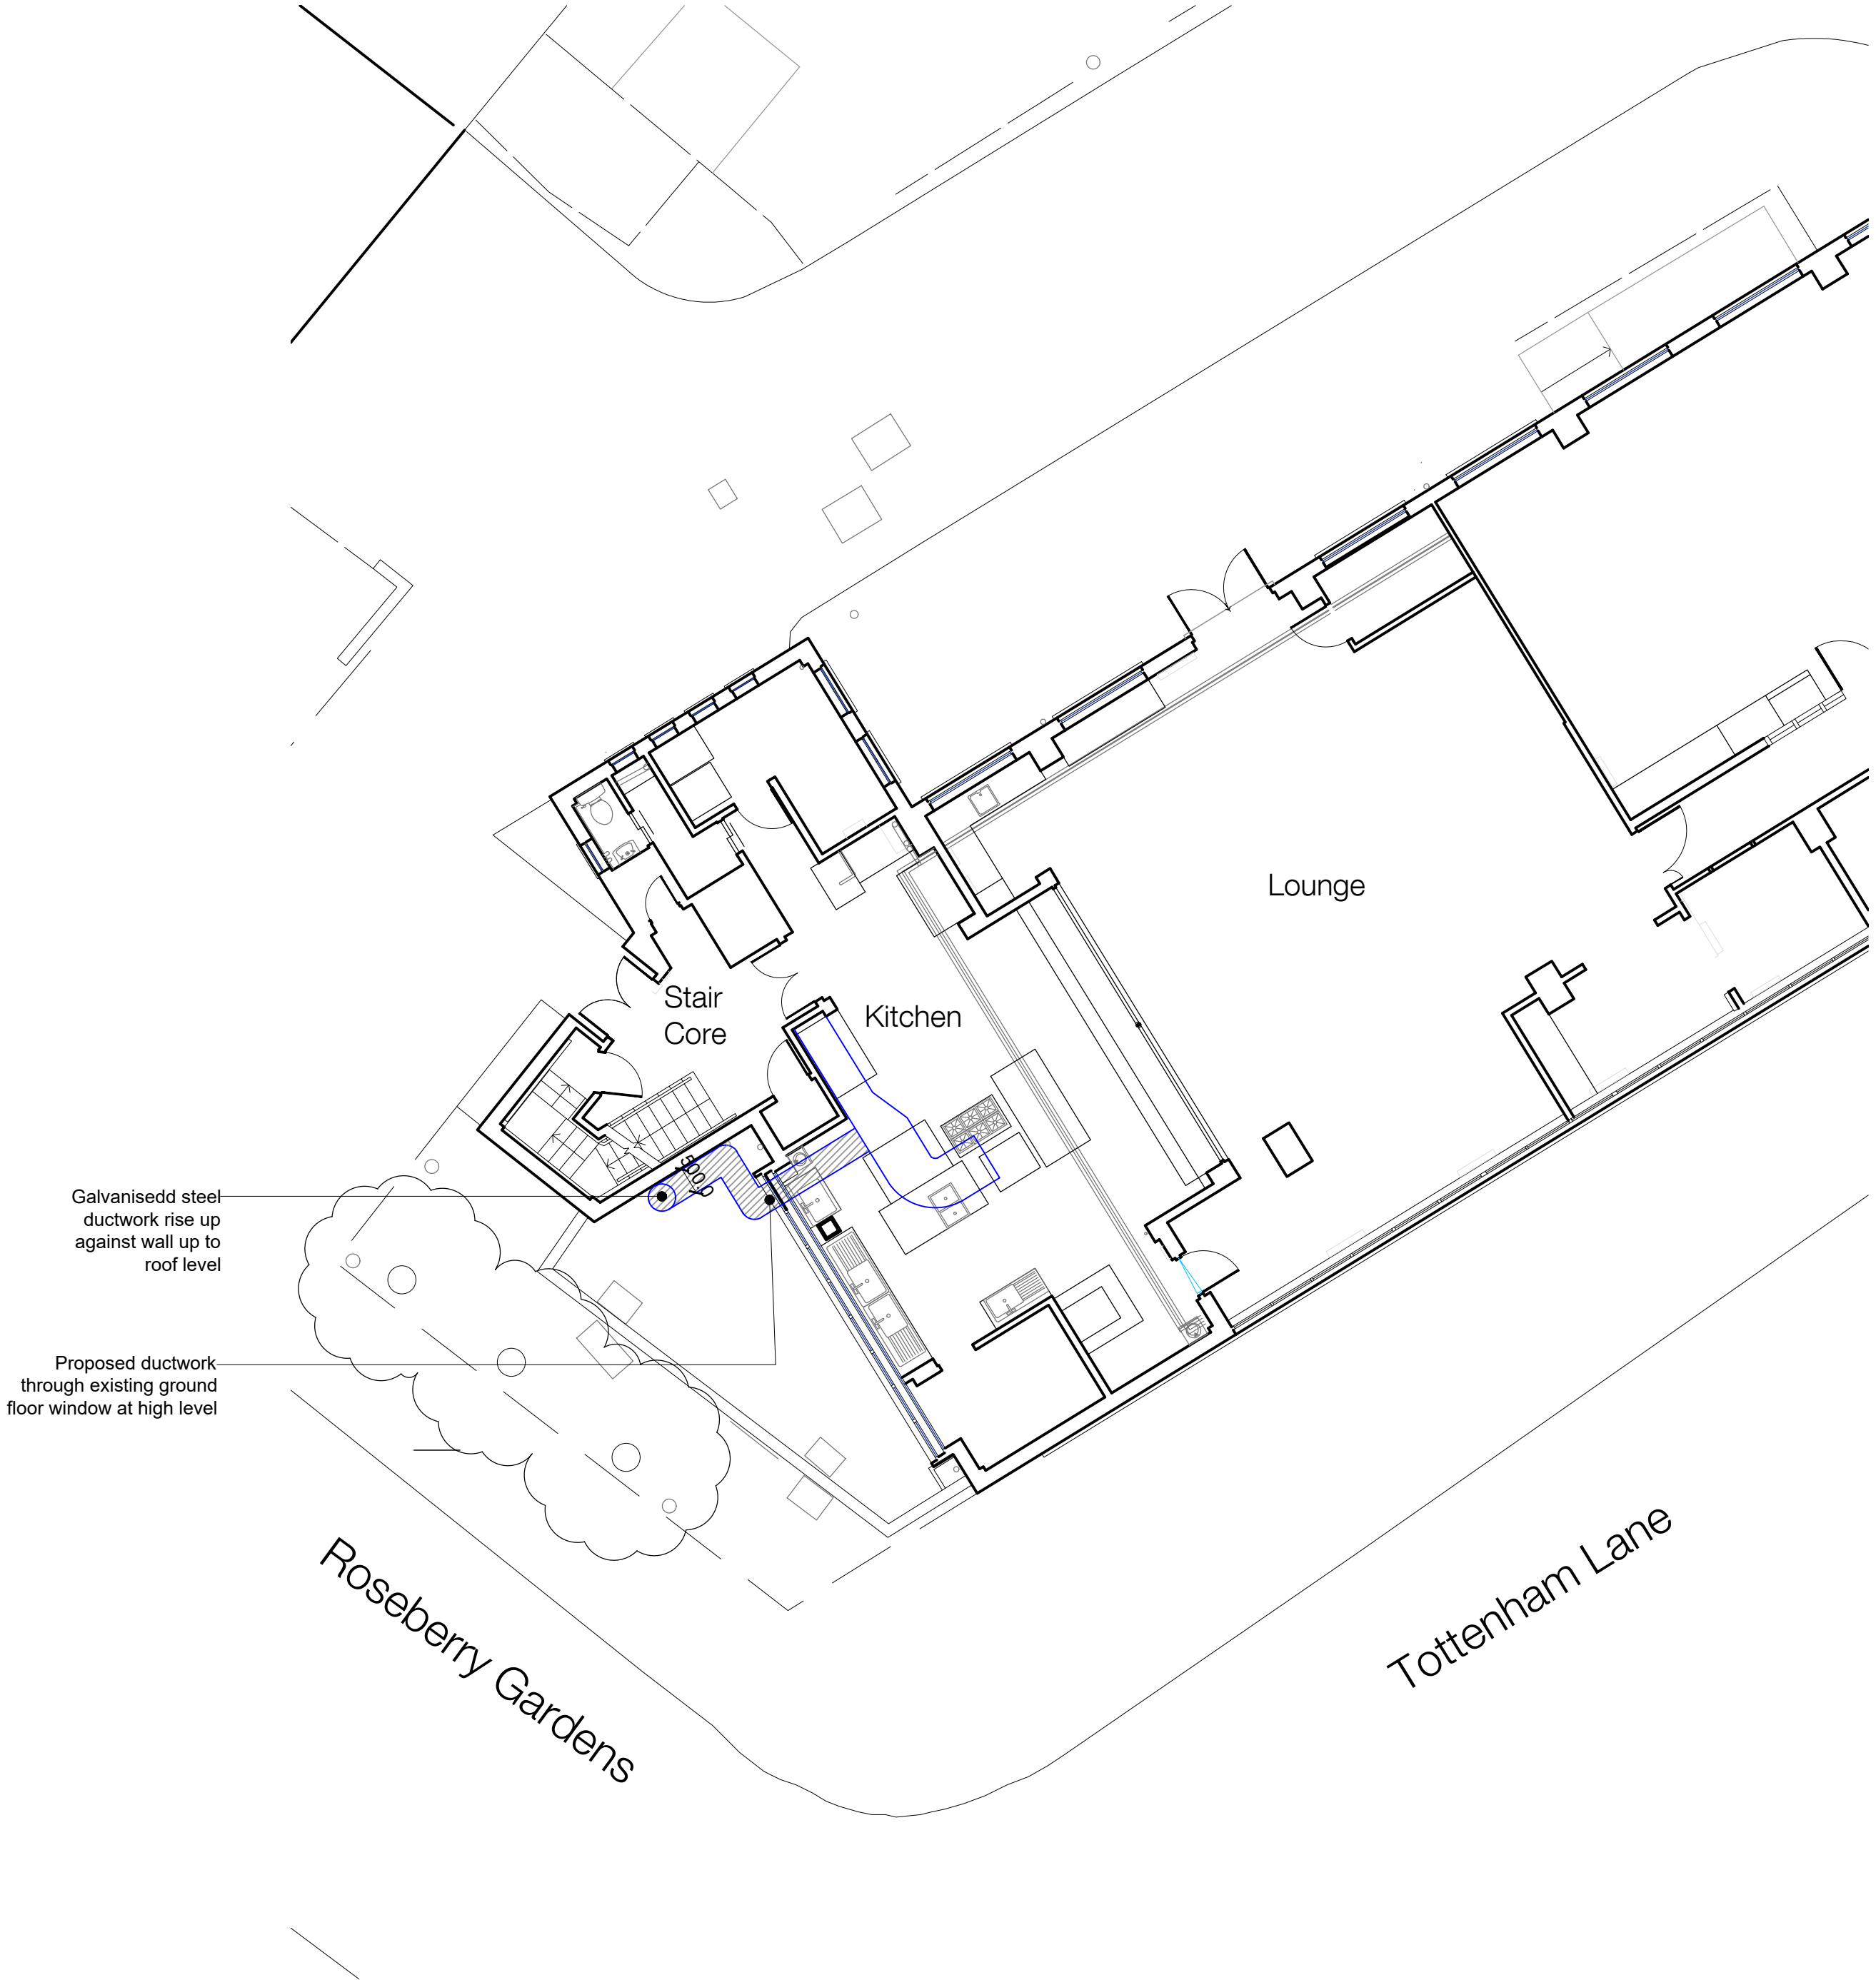

01 Proposed Ground Floor Plan
1:100

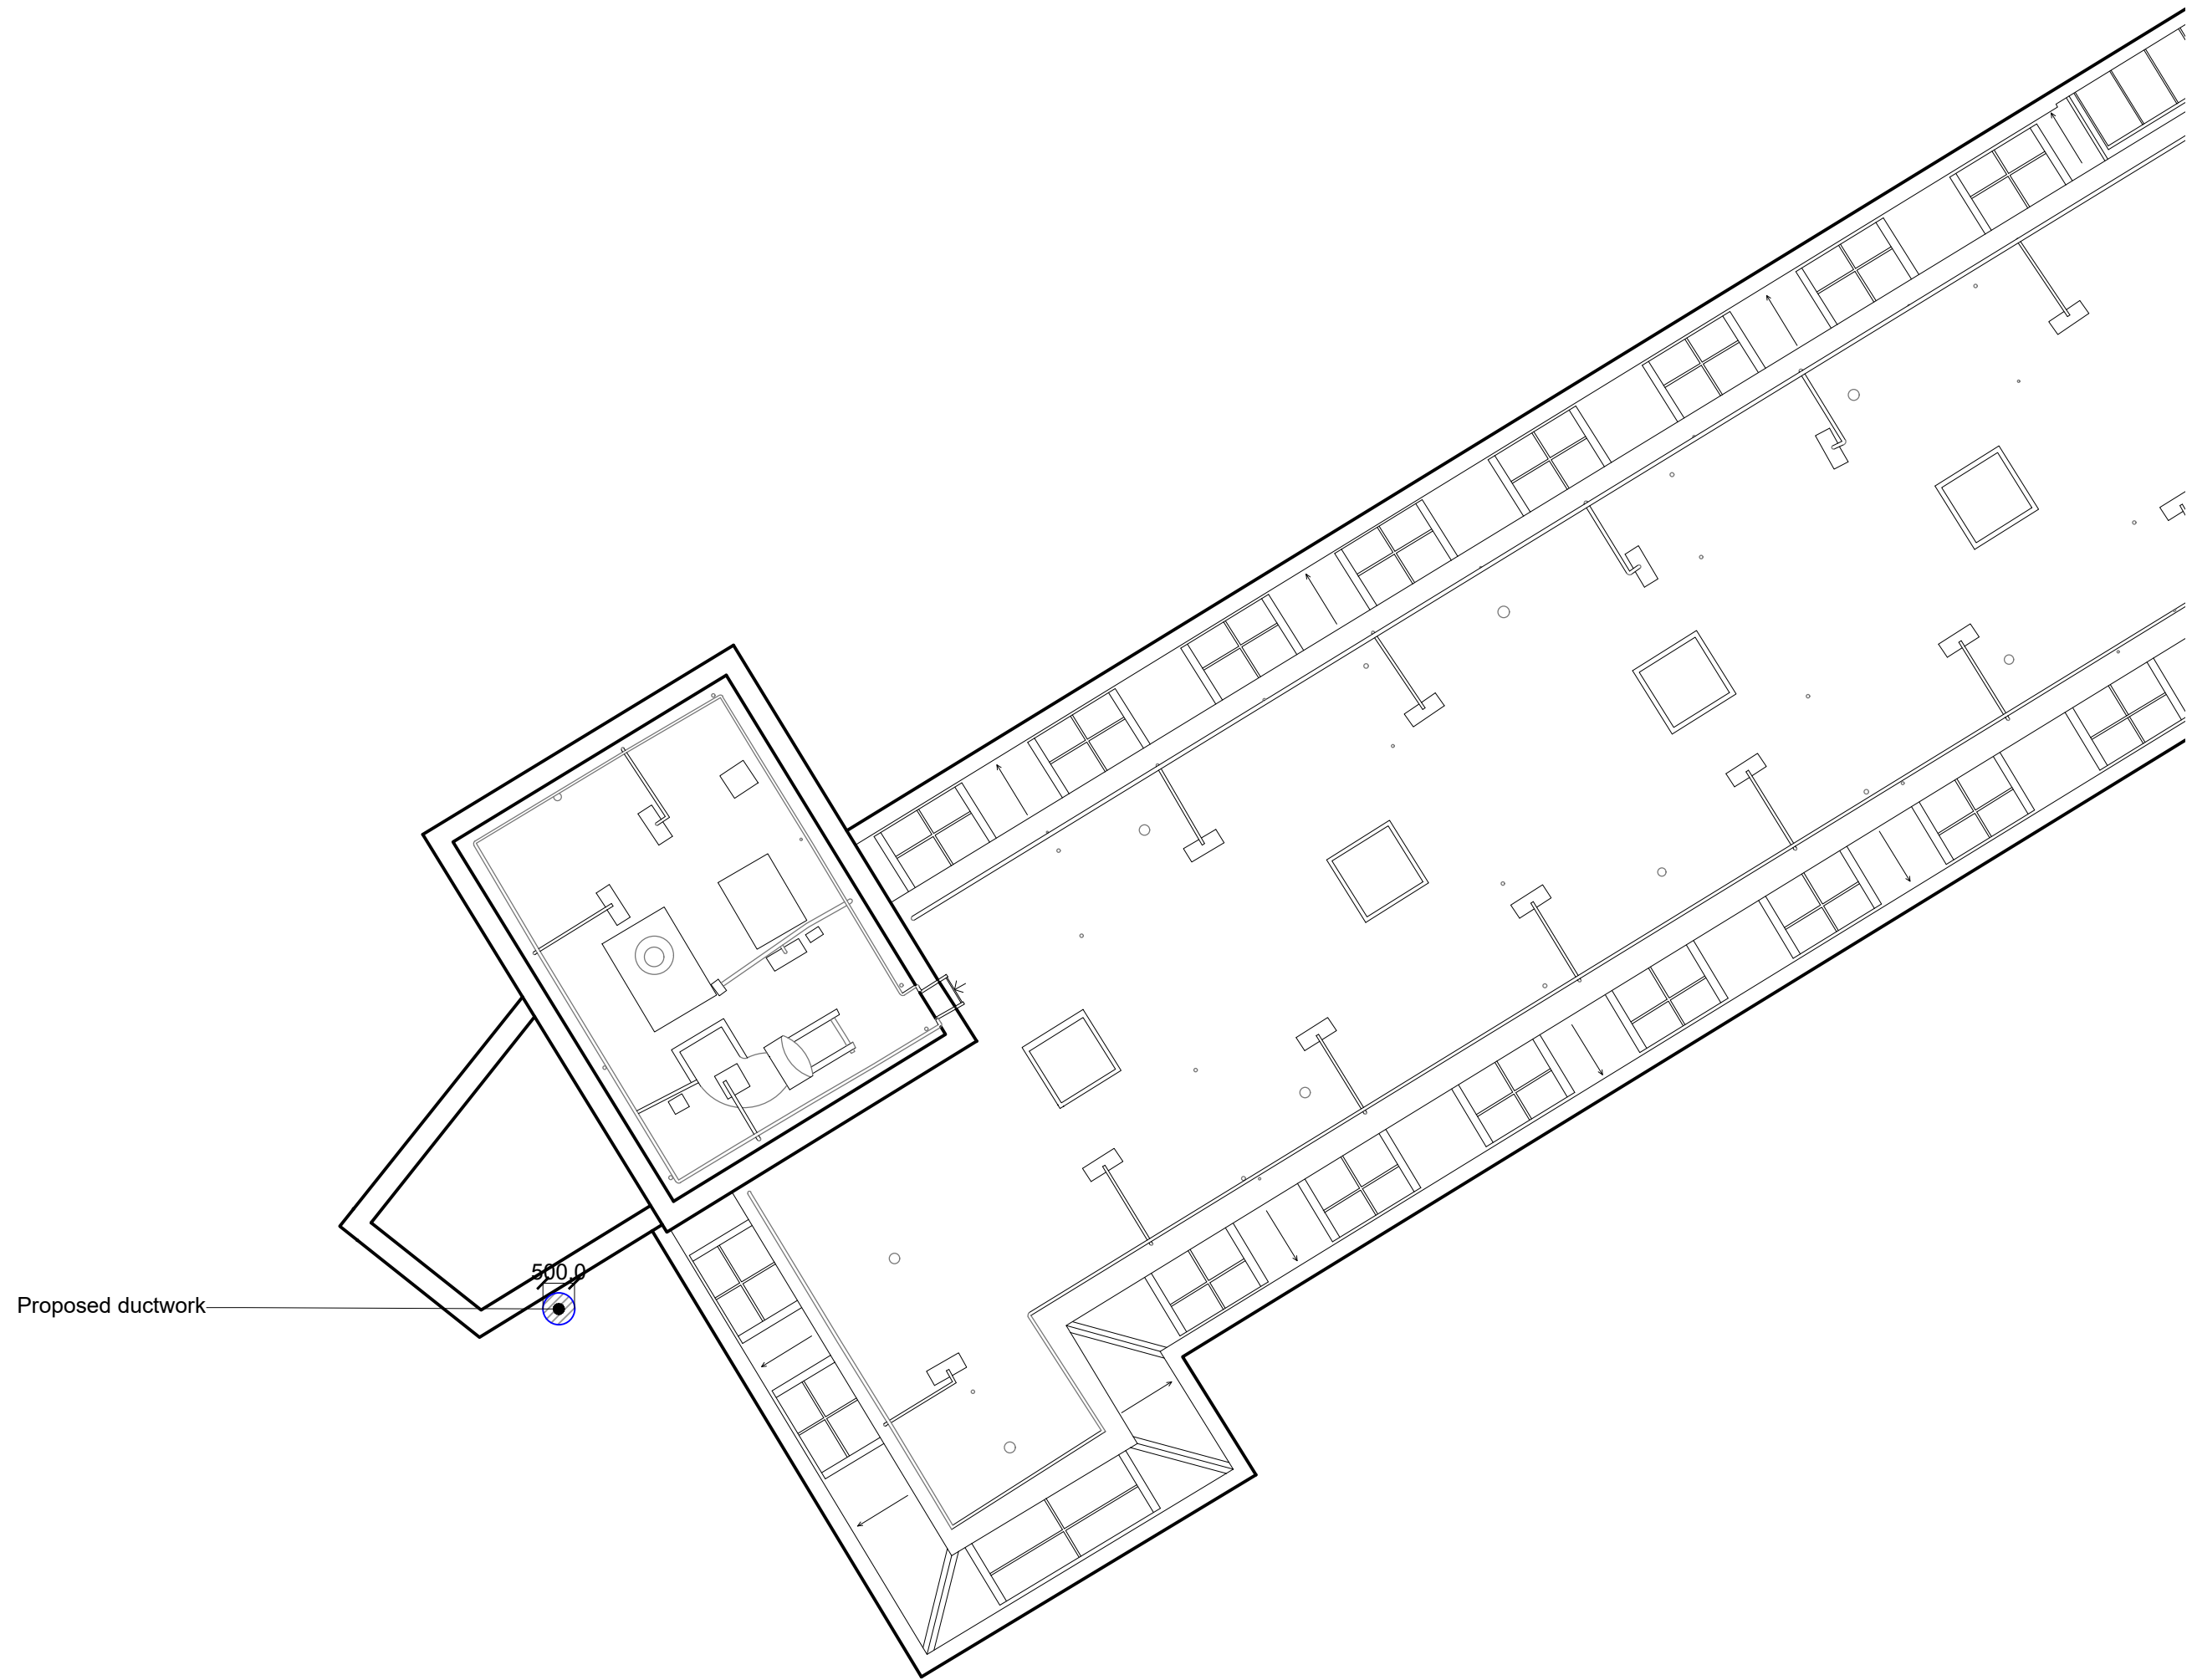

02 Proposed Rooftop Plan
1:100

Notes

1. Do not scale this drawing.
2. All dimensions must be checked on site and any discrepancies verified with the architect.
3. Unless shown otherwise, all dimensions are to structural surfaces.
4. Drawing to be read with all other issued information. Any discrepancies to be brought to the attention of the architect.
5. This drawing is the copyright of Levitt Bernstein and may not be copied, altered or reproduced in any form, or passed to a third party without license or written consent.

This is not a construction drawing, it is unsuitable for the purpose of construction and must on no account be used as such.

P1	15.02.2026	Planning	KS
Rev	Date	Description	Initials

Project name

YMCA Lcan Kitchen Ductwork Alterations

Drawing number Rev

4079_LB_ZZ-ZZ-D-A-1201 P1

Drawing

Proposed Ground floor and Rooftop Plan

Purpose of issue	Date
Planning	FEB 26
Scale	Drawn
1:100 @ A1	KS
Client	Checked
YMCA Lcan	BM

levittbernstein.co.uk

London
Thane Studios
2-4 Thane Villas
London N7 7PA
+44 (0)20 7275 7676

Manchester
Eastgate
2 Castle Street
Manchester M3 4LZ
+44 (0)16 1669 8740

