


1.00 DO NOT SCALE THIS DRAWING. WORK TO DIMENSIONS GIVEN.
2.00 ALL DIMENSIONS TO BE VERIFIED FROM SITE MEASUREMENT.
3.00 ALL DRAWINGS SHALL BE READ IN CONJUNCTION WITH THE MECHANICAL
AND ELECTRICAL PROJECT SPECIFIC SPECIFICATIONS.

Copyright : triangle consulting engineers

NOTES:

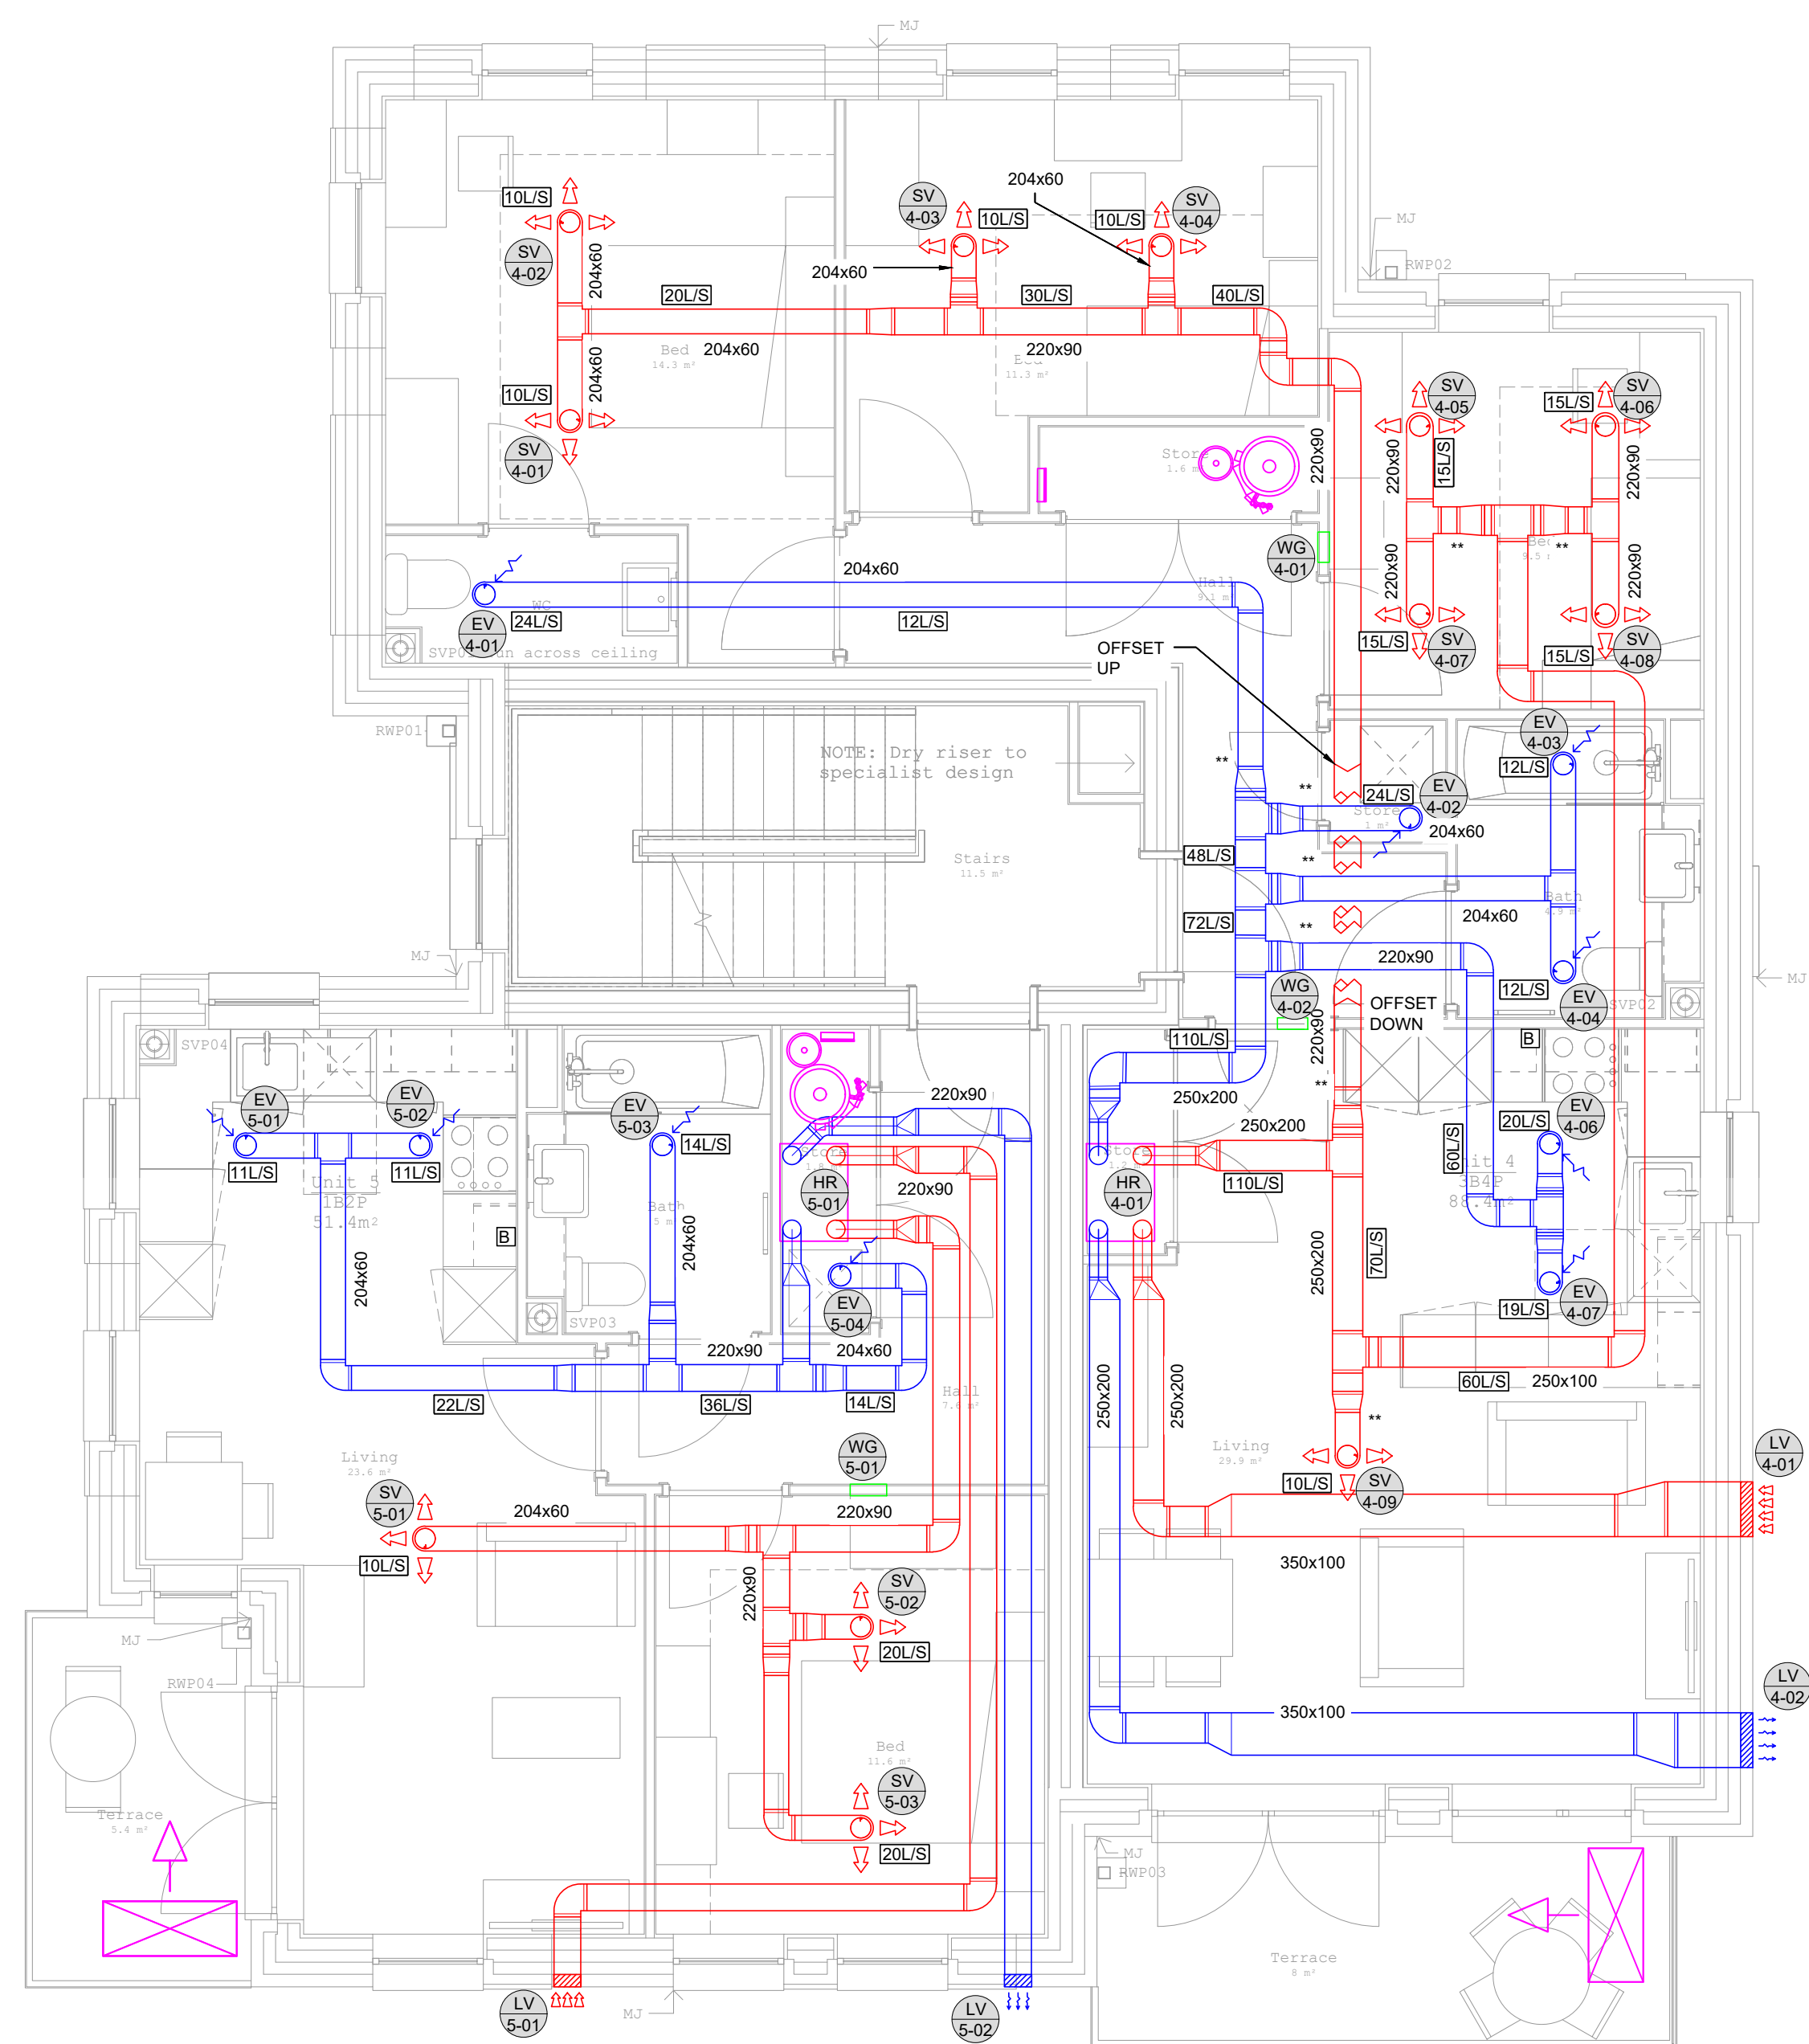

R1	DW	GENERALLY UPDATED	03/02/2026
Rev.	By	Description	Date



5 WESTGATE
TADCASTER LS24 9AB
Tel : 0113 287 7222
www.triangleltd.com

Client
Alexander James Contracting Ltd

Project
Jansons Road

Drawing Title
Mechanical Services
Second Floor
Ventilation Layout

Drawing Status Review	Designed by: DWC	Checked by: DW
Drawing Number 25133/M/302		Rev. R1
Drawing Scale 1:50	Drawing Size A1	Date Created Jan 26