



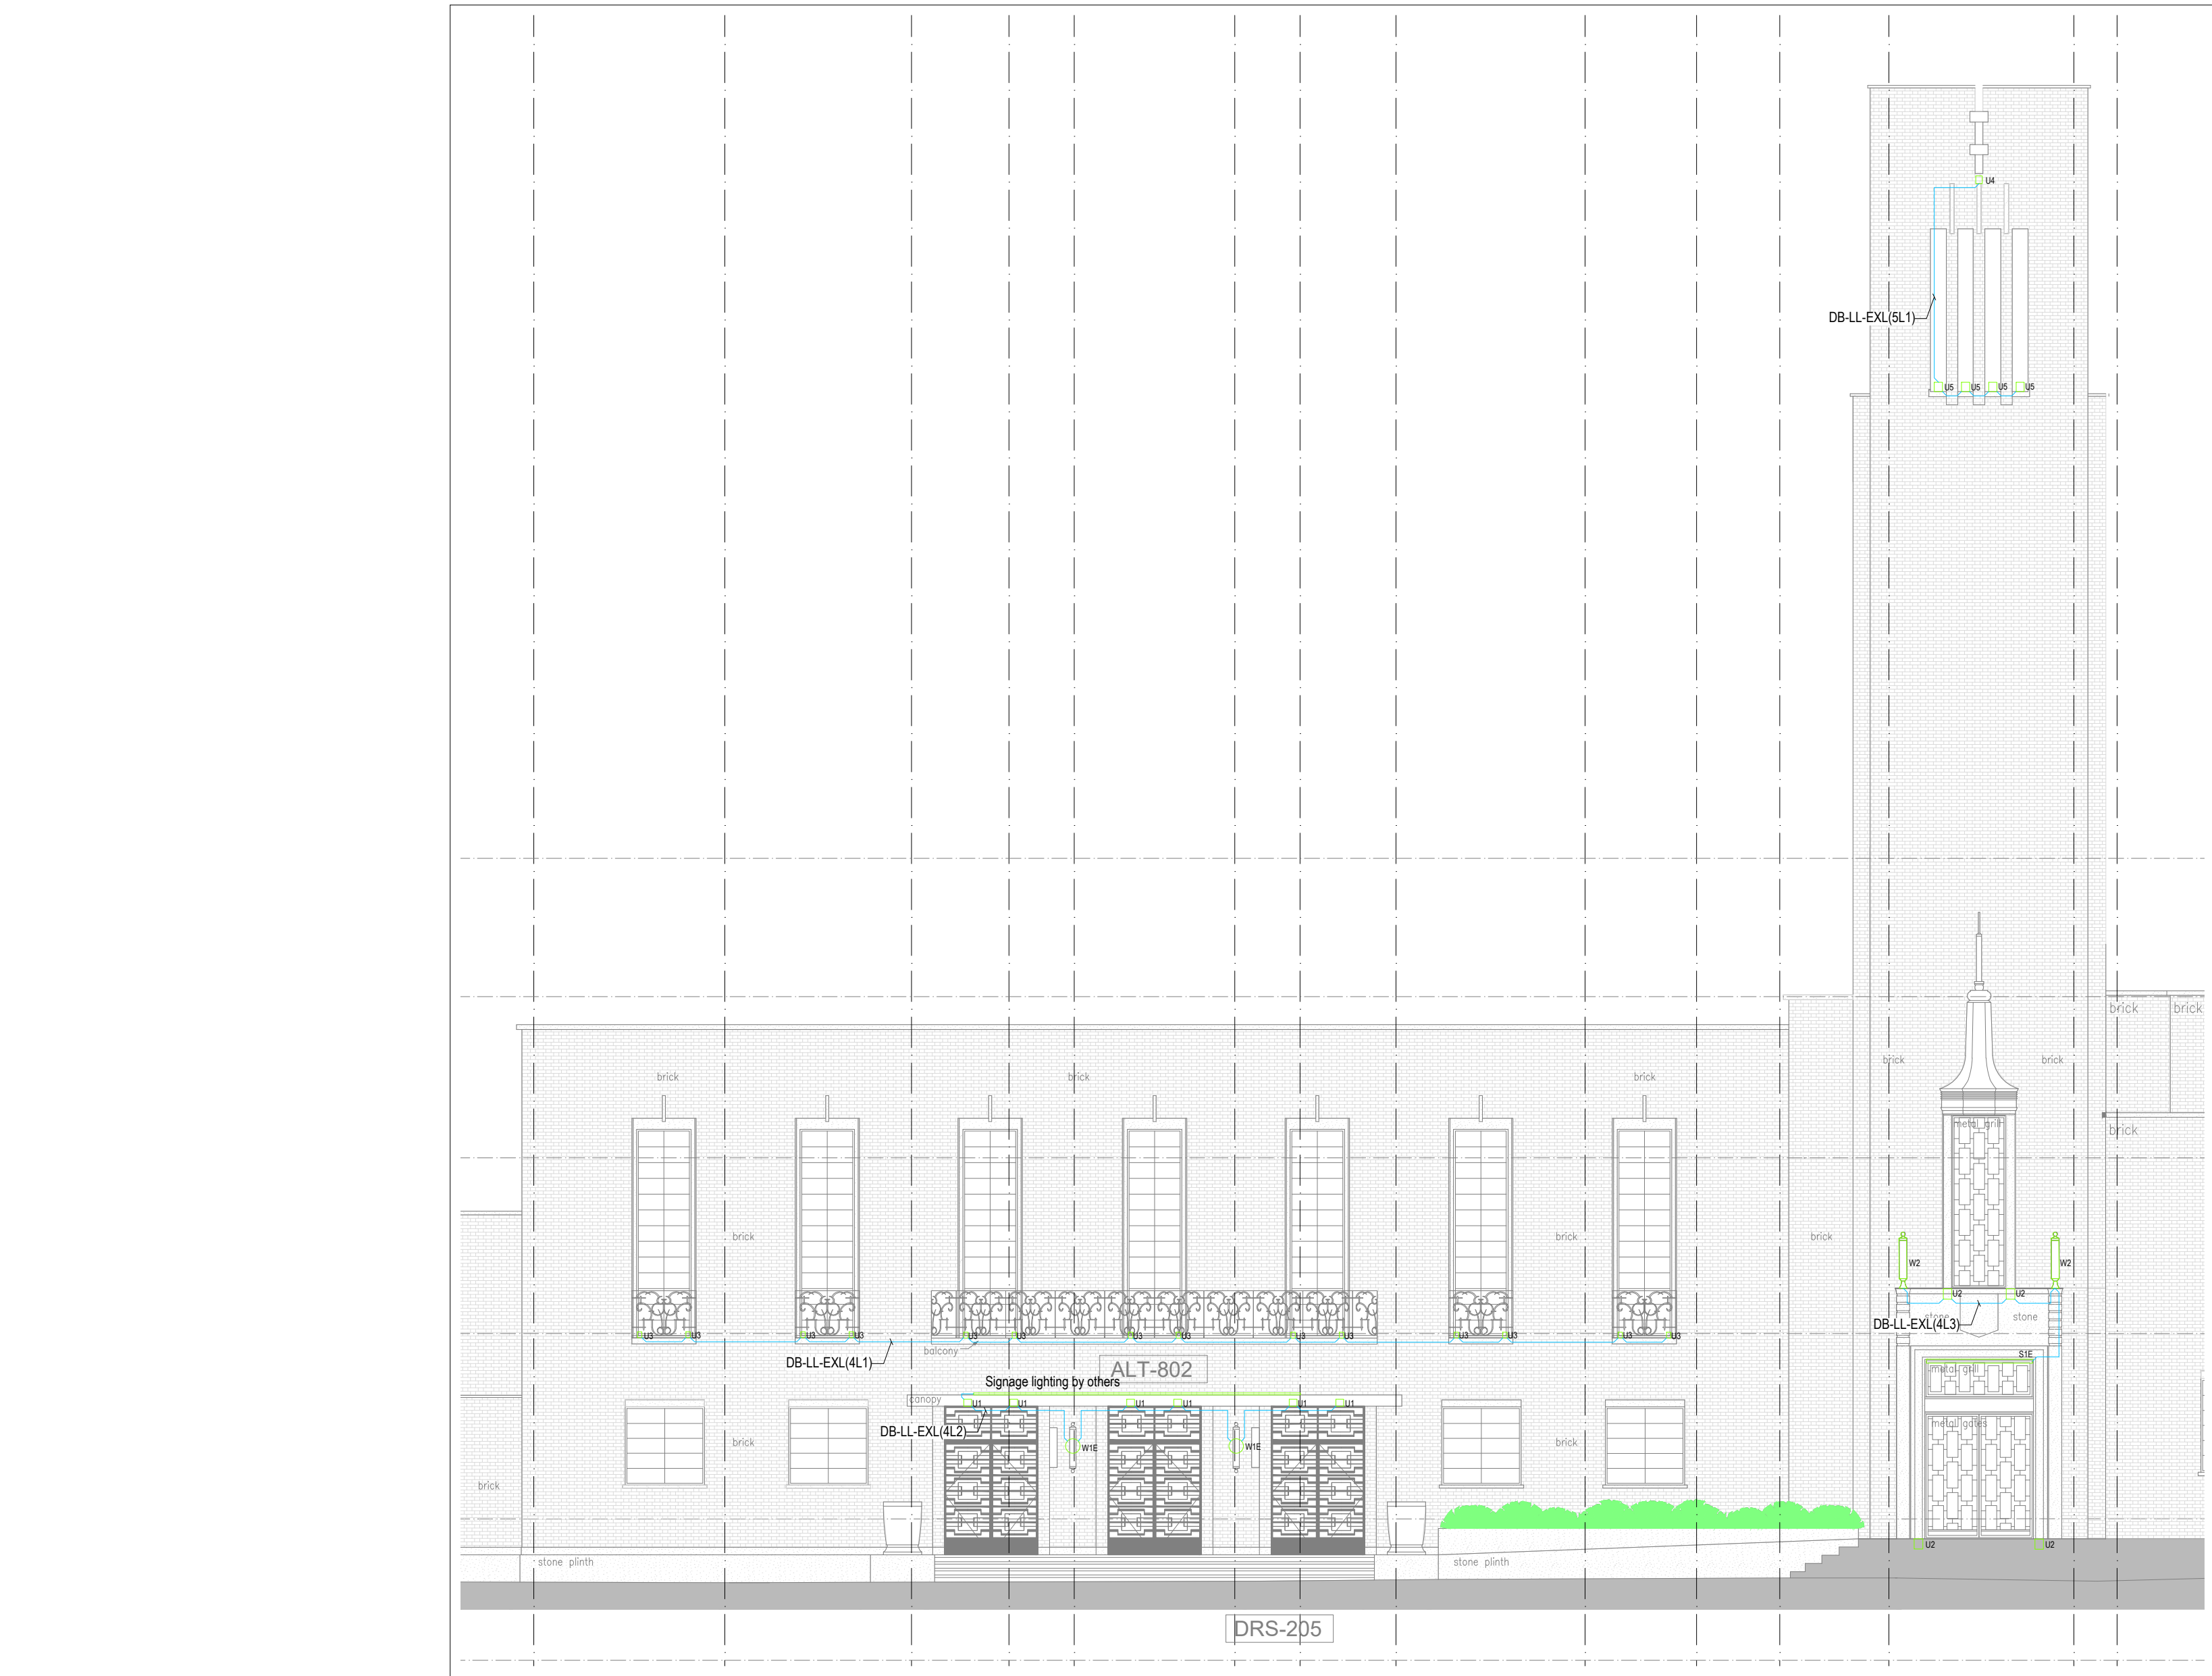

West Facade

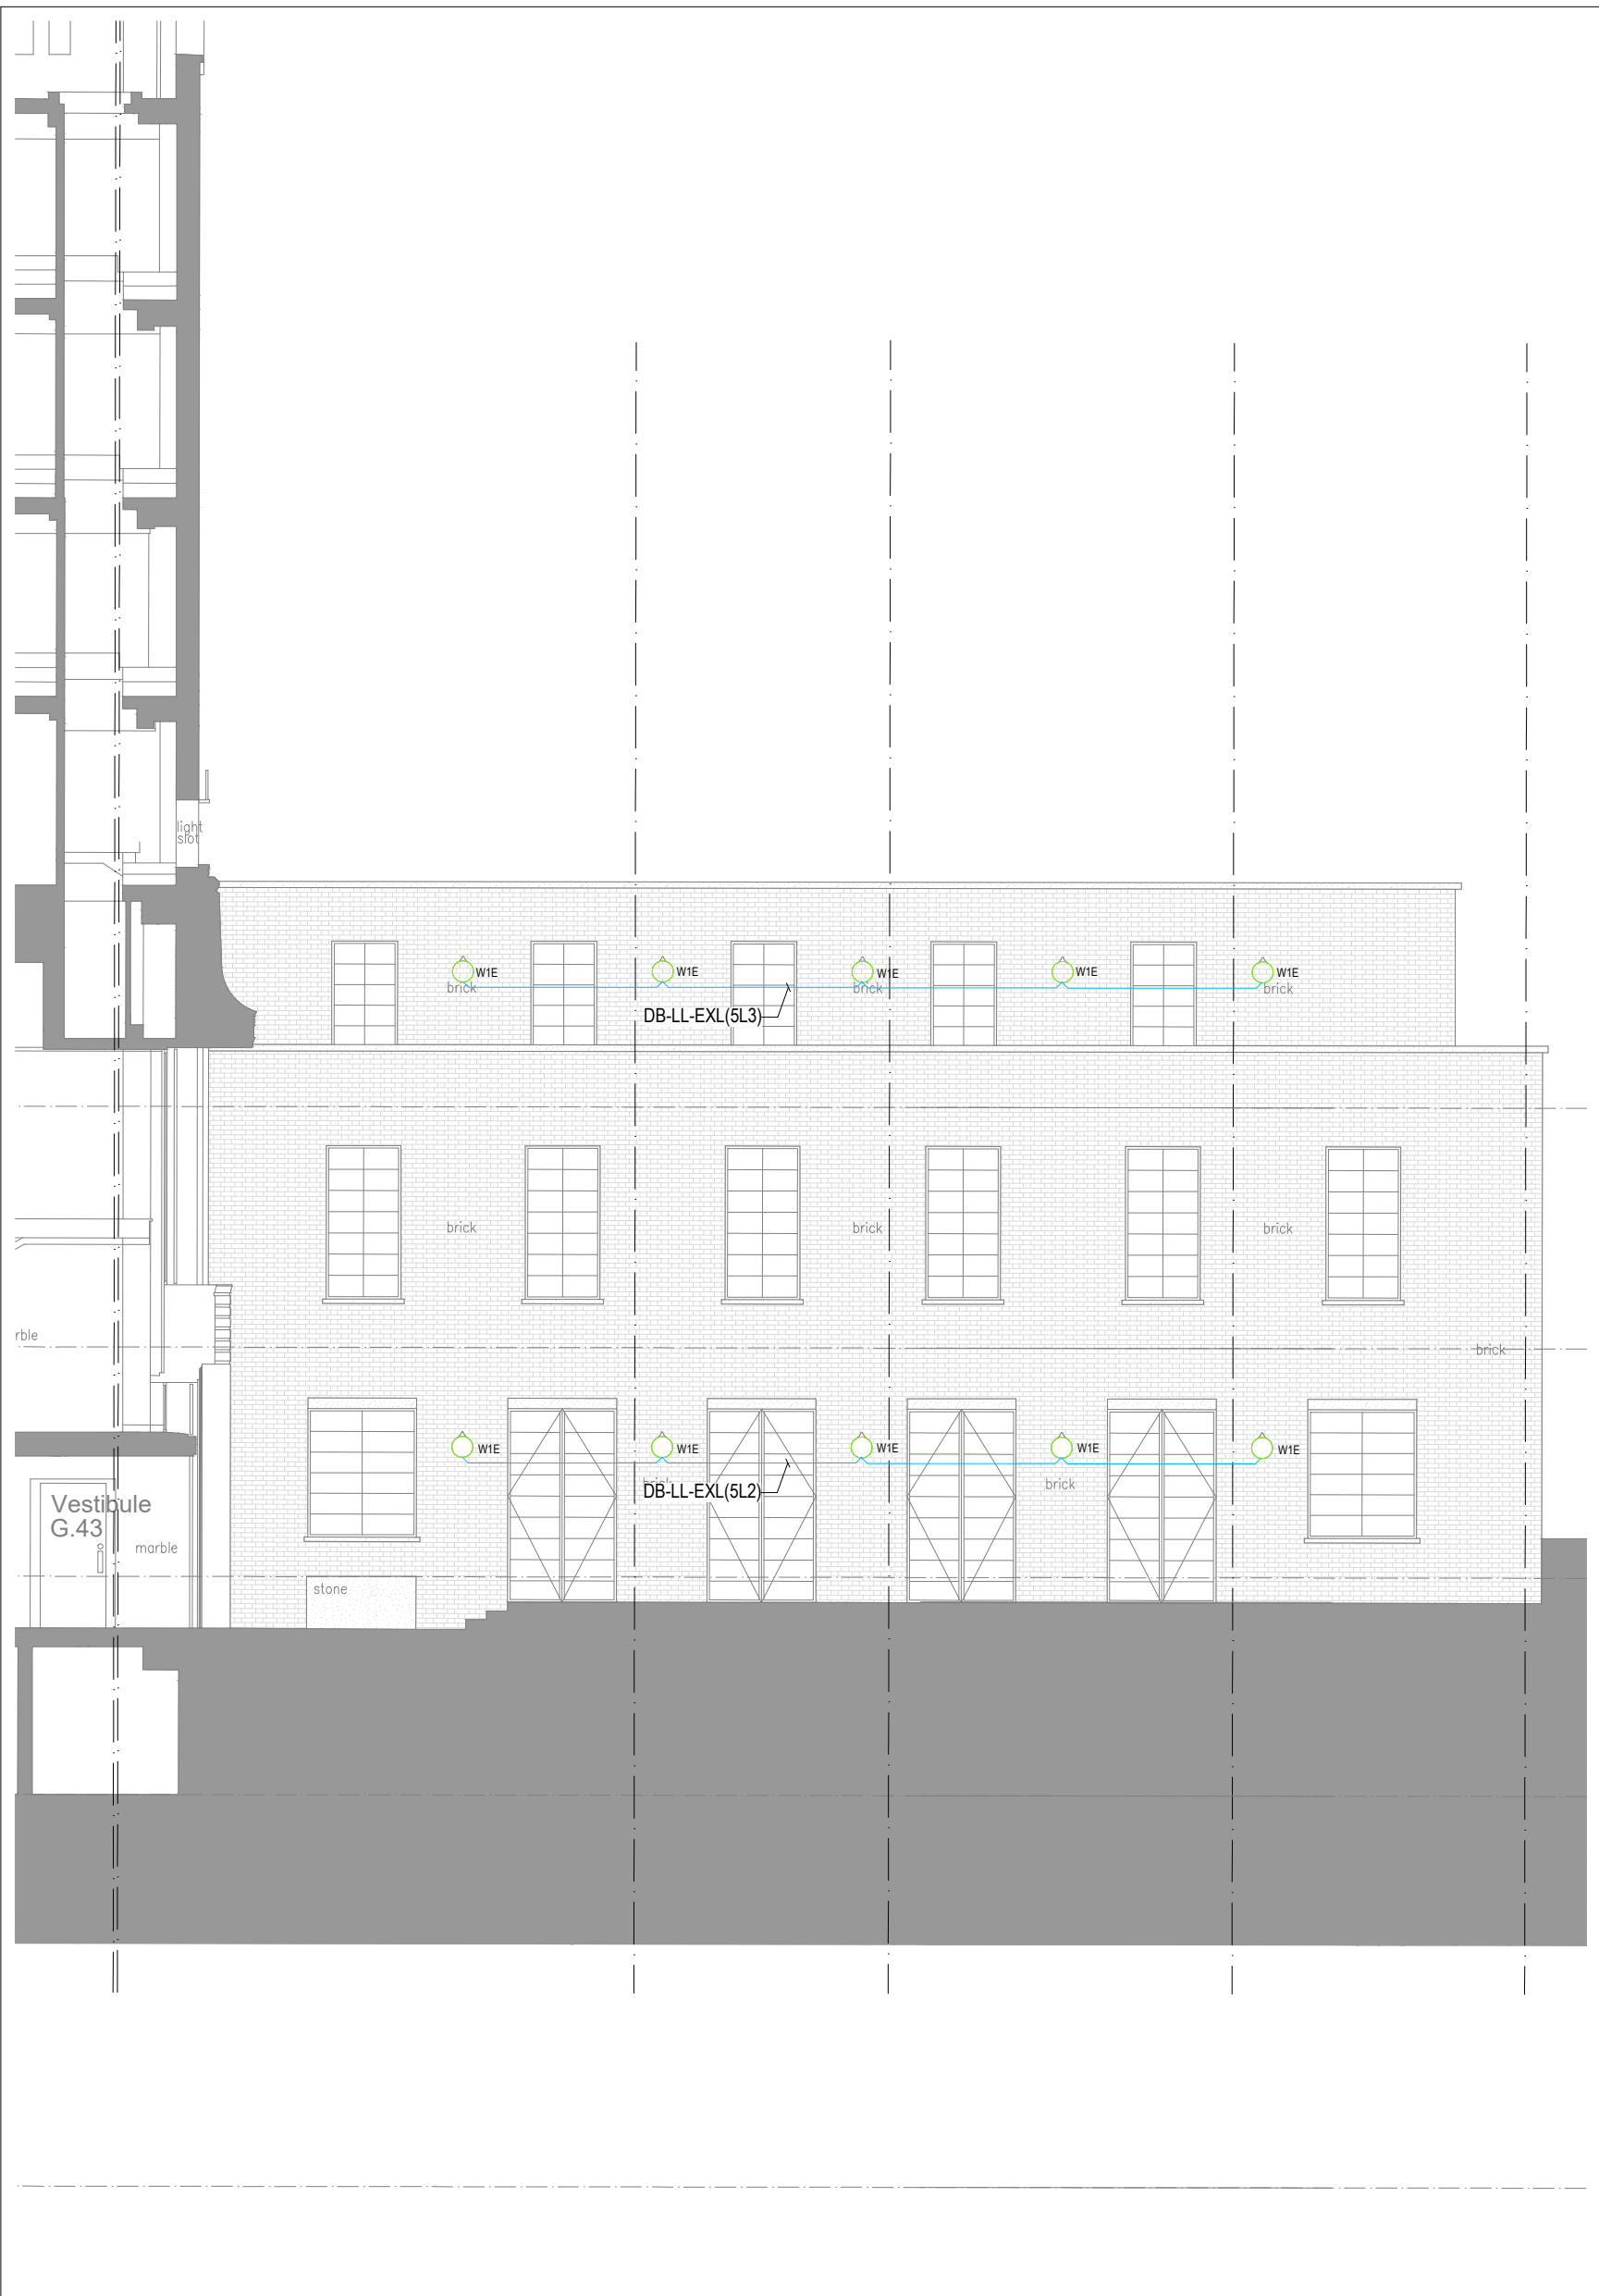

North Facade

Copyright: Designs and Patents Act 1988

The copyright & design right of the design documents & of the design remains that of Whitecode Ltd. All copies are only for information about the application, they may not be used for any other purpose or copied without the express written permission of Whitecode Ltd.

Conflicts of Information

It shall remain the responsibility of the installer/contractor to ensure that there are no conflicts with information provided by themselves & that of any manufacturers information or relevant requirements of statutory Bodies or Client specification/Er's. If any conflicts do exist it is the responsibility of the installer/contractor to inform The Consultant/Client immediately Verbally & in writing.

WARNING TO HOUSE PURCHASERS - Property Misdescriptions Act 1991

Buyers are warned that this is a working drawing and is not intended to be treated as descriptive material describing, in relation to any descriptive material describing, in relation to any descriptive particular property or development, any of the Specific Matters prescribed by an Order made under the above Act. The contents of this drawing may be subject to change at any time & alterations and variations can occur during the progress of the works without revision of the drawing. Consequently the layout, form, contents & dimensions of the finished construction may differ materially from those shown. Nor do the contents of this drawing constitute a contract, part of any contract or a warranty.

NOTES

General Electrical Notes

- Mechanical services shown for coordination purposes only. Refer to mechanical drawings for mechanical services information.
- Before commencing work on site, please read Design Risk Management Information.
- All manufacturer's instructions to be reviewed prior to installation.
- All electrical installations shall be carried out in accordance with BS 7671.
- This drawing is to be read in conjunction with the electrical symbols legend & typical mounting heights drawings.
- Where electrical boxes, conduits, trunking, pattresses or luminaires penetrate floors, walls, roofs, ceilings or other partitions, they must be suitably fire-stopped in order to arrest the spread of fire through the electrical system; as per section 527.2 of BS 7671 and Approved Document B.
- Dimensioned setting out details to be confirmed by architect.
- All discrepancies are to be queried with WCL before works commence.

Tag	Description
W1E	Octant Wall Mounted Luminaire IP67 Rated
W2	Octant Wall Mounted Refurbished Luminaire IP67 Rated
U1	Lucifer Lighting 3 series LED downlight 3000K IP54
U2	Louis Poulsen RADIS 210 LED 3K ZOOM IP66, IP67, IP69K, IK10 rated Ground recessed uplight
U3	Meyer Superlight Nano 2 Wide Beam 3000K IP67
U4	Meyer Superlight Nano 3 3000K IP67
U5	Meyer Superlight Nano 4 RGBW IP67
S1E	KKDC SEN Louvre IP rated 3000k

DRAWING ISSUED TO AS-BUILT STATUS FOLLOWING NO FURTHER COMMENTS FROM ARDMORE AGAINST THE CONSTRUCTION ISSUE DRAWING.

BACKGROUND PLAN AS PER:		KDS
3670-KDS-TH-ZZ-DR-A-04-2255	REVISION	DATE REVISION
3670-KDS-TH-ZZ-DR-A-05-2200	C1	13.03.2020
	C1	21.10.2020

AB	24.09.2024	AS BUILT	PM	JM
C2	11.01.2024	Circuit references changes	JH	JM
C1	22.11.2023	Construction Issue	IV	JM
I1	06.04.2023	Issue for information	LMS	JM
Rev	Date	Description	Dwn	Chkd
Current purpose:	AS BUILT	Scale: 1:100	Size:	A1
Original Issue Date:	06.04.2023	Dwn: LMS	Chkd: JM	

BUILDING SERVICES DESIGN
CONSULTANTS
25-27 The Hill, Northfleet, Gravesend
Kent, DA11 9EU
www.whitecode.co.uk
T: 01322 289977 E: design@whitecode.co.uk

Title:

EXTERNAL LIGHTING LAYOUT
TOWN HALL FACADES

Project:

HORNSEY
TOWN HALL

Client:

ARDMORE

Dwg Number:

10687-E-0-0004

Rev:

AB