



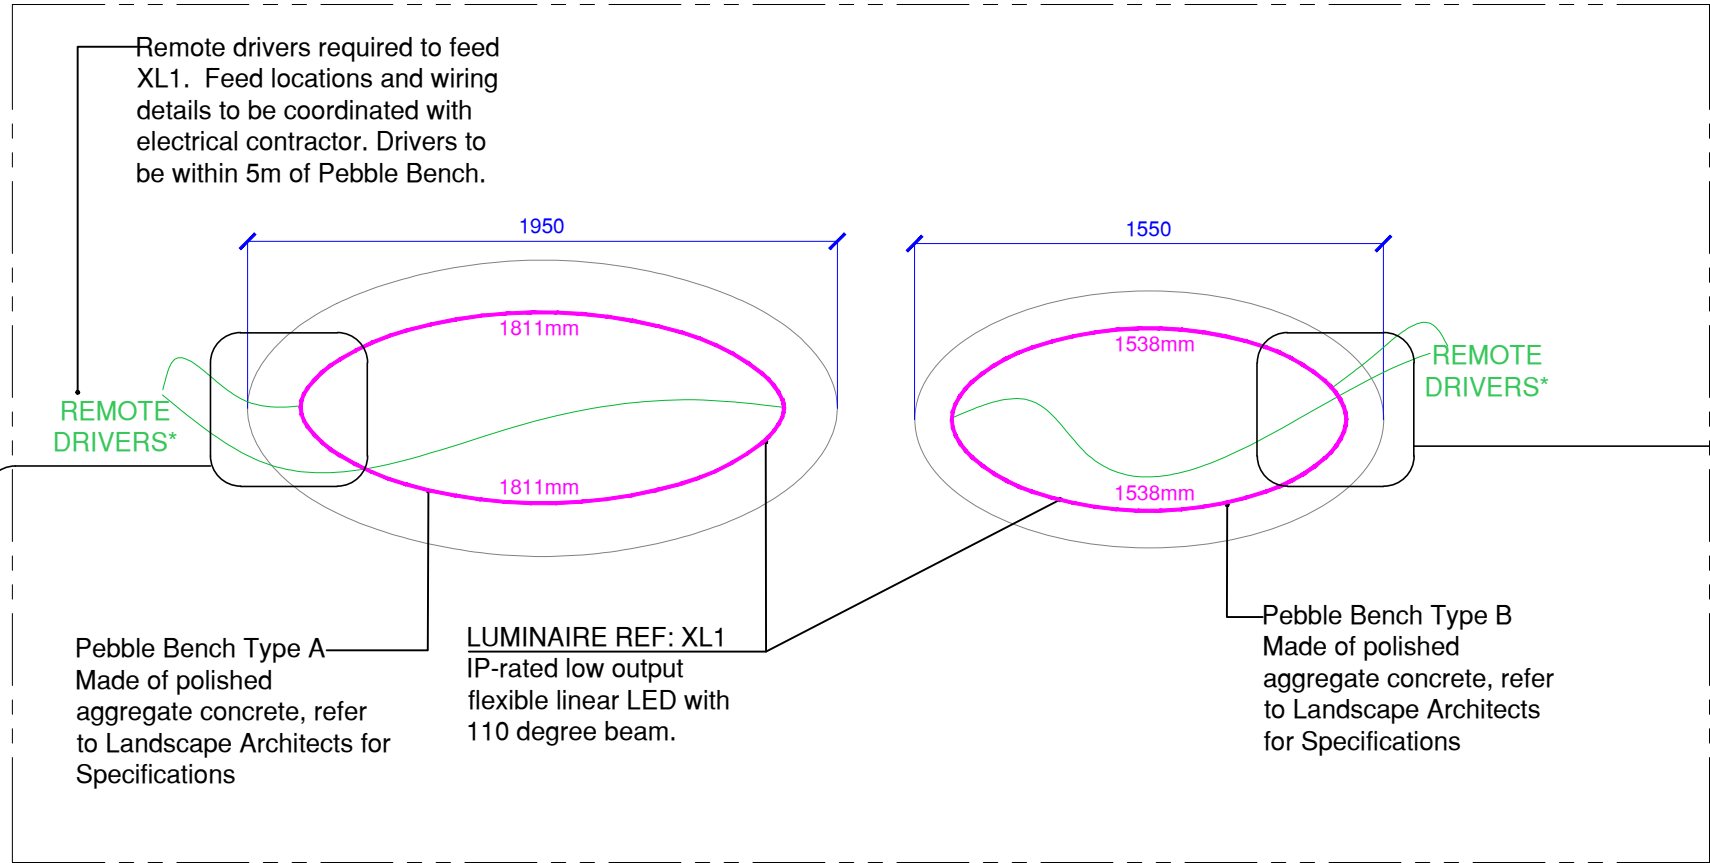


01 Pebble Bench Lighting Plan

Scale = 1:20

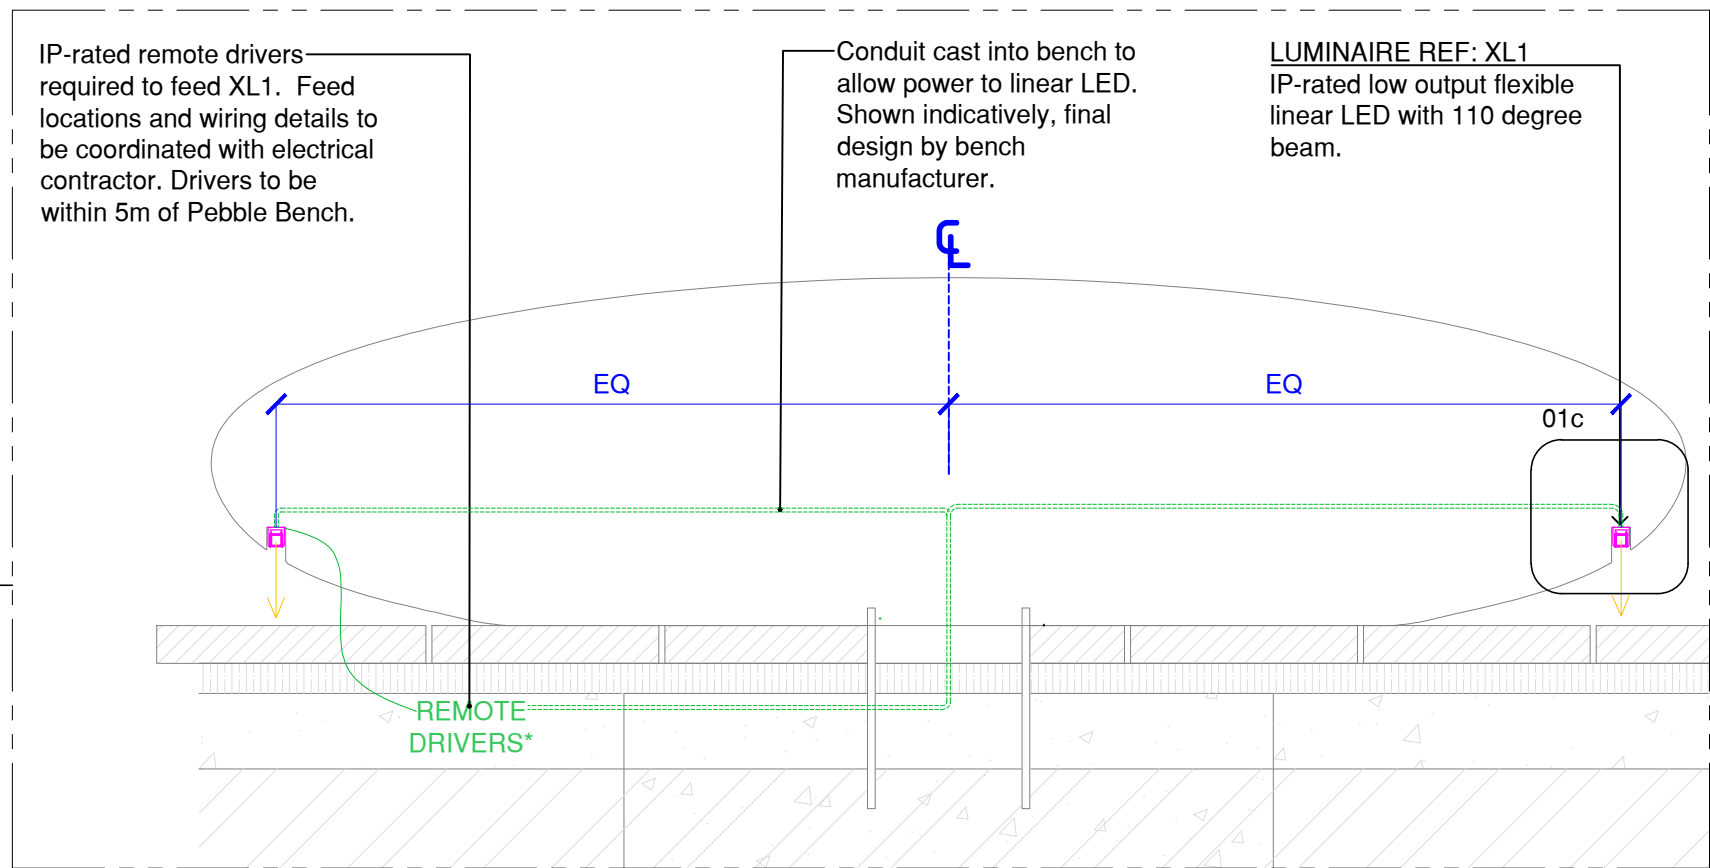


01a Bench Type 1A Lighting - Section

Scale = 1:10

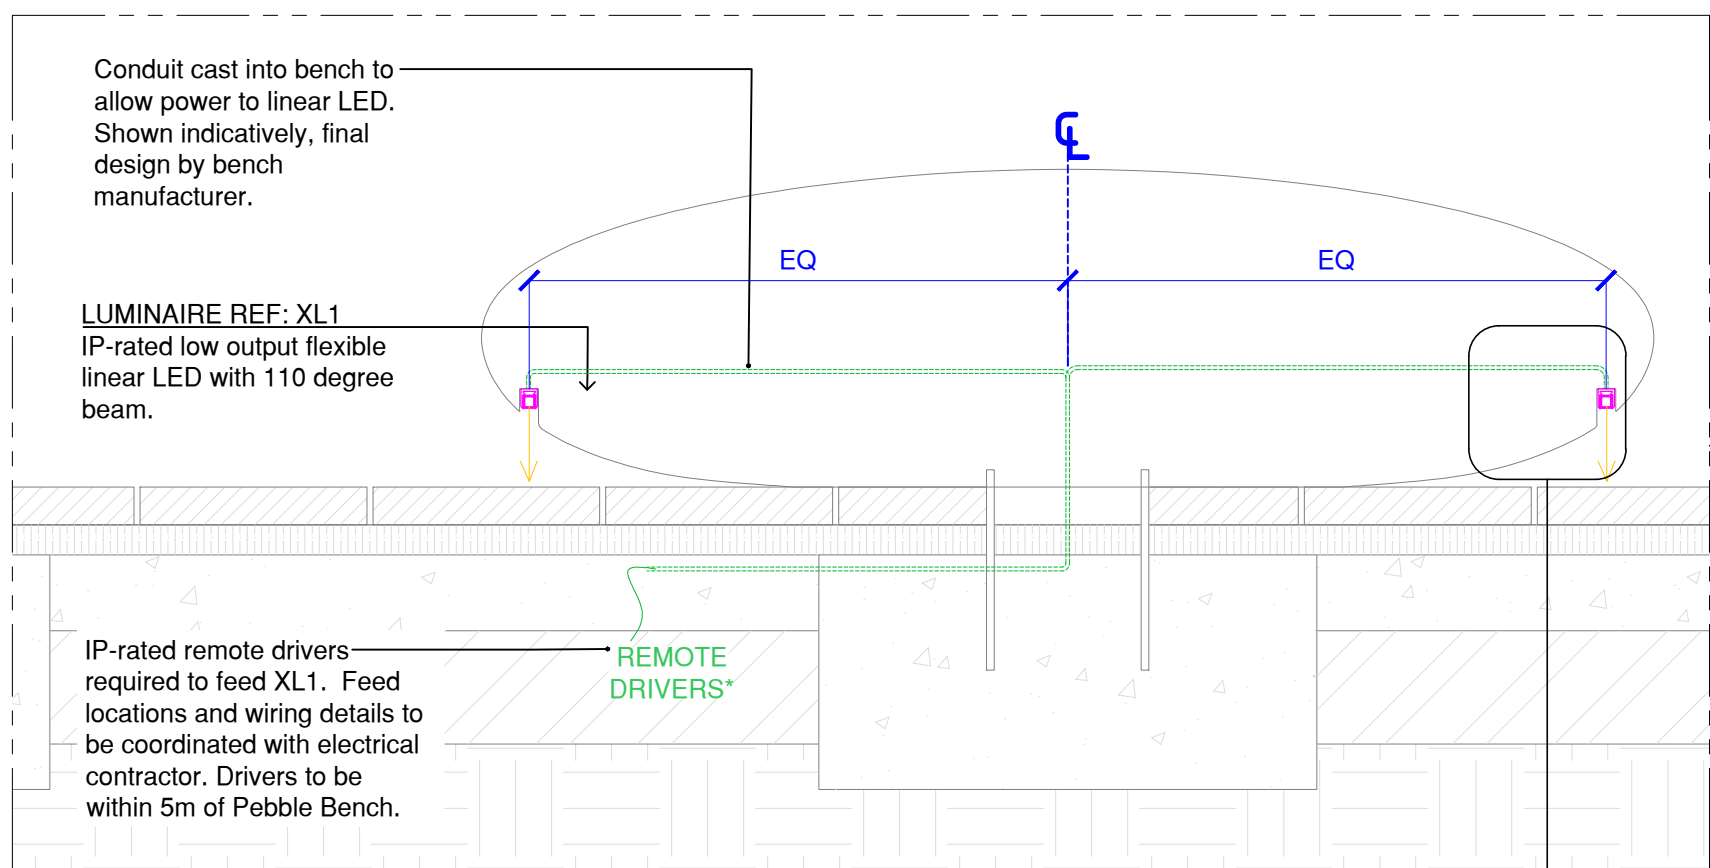


01b Bench Type 1B Lighting - Section

Scale = 1:10

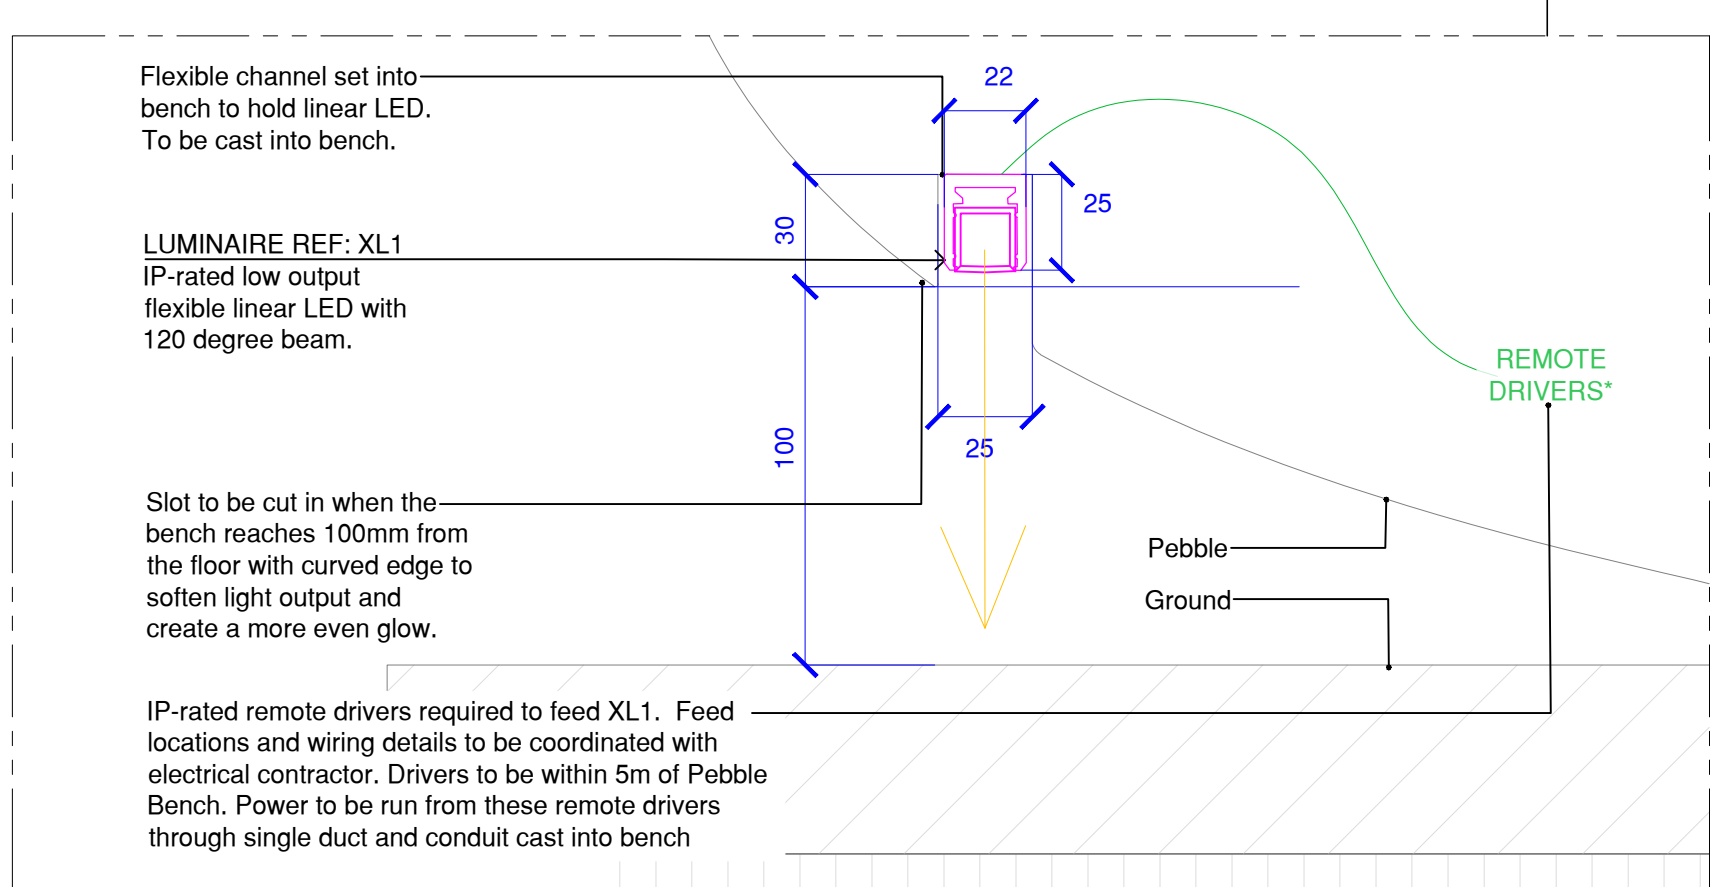


01c Typical Bench Lighting - Detail

Scale = 1:2

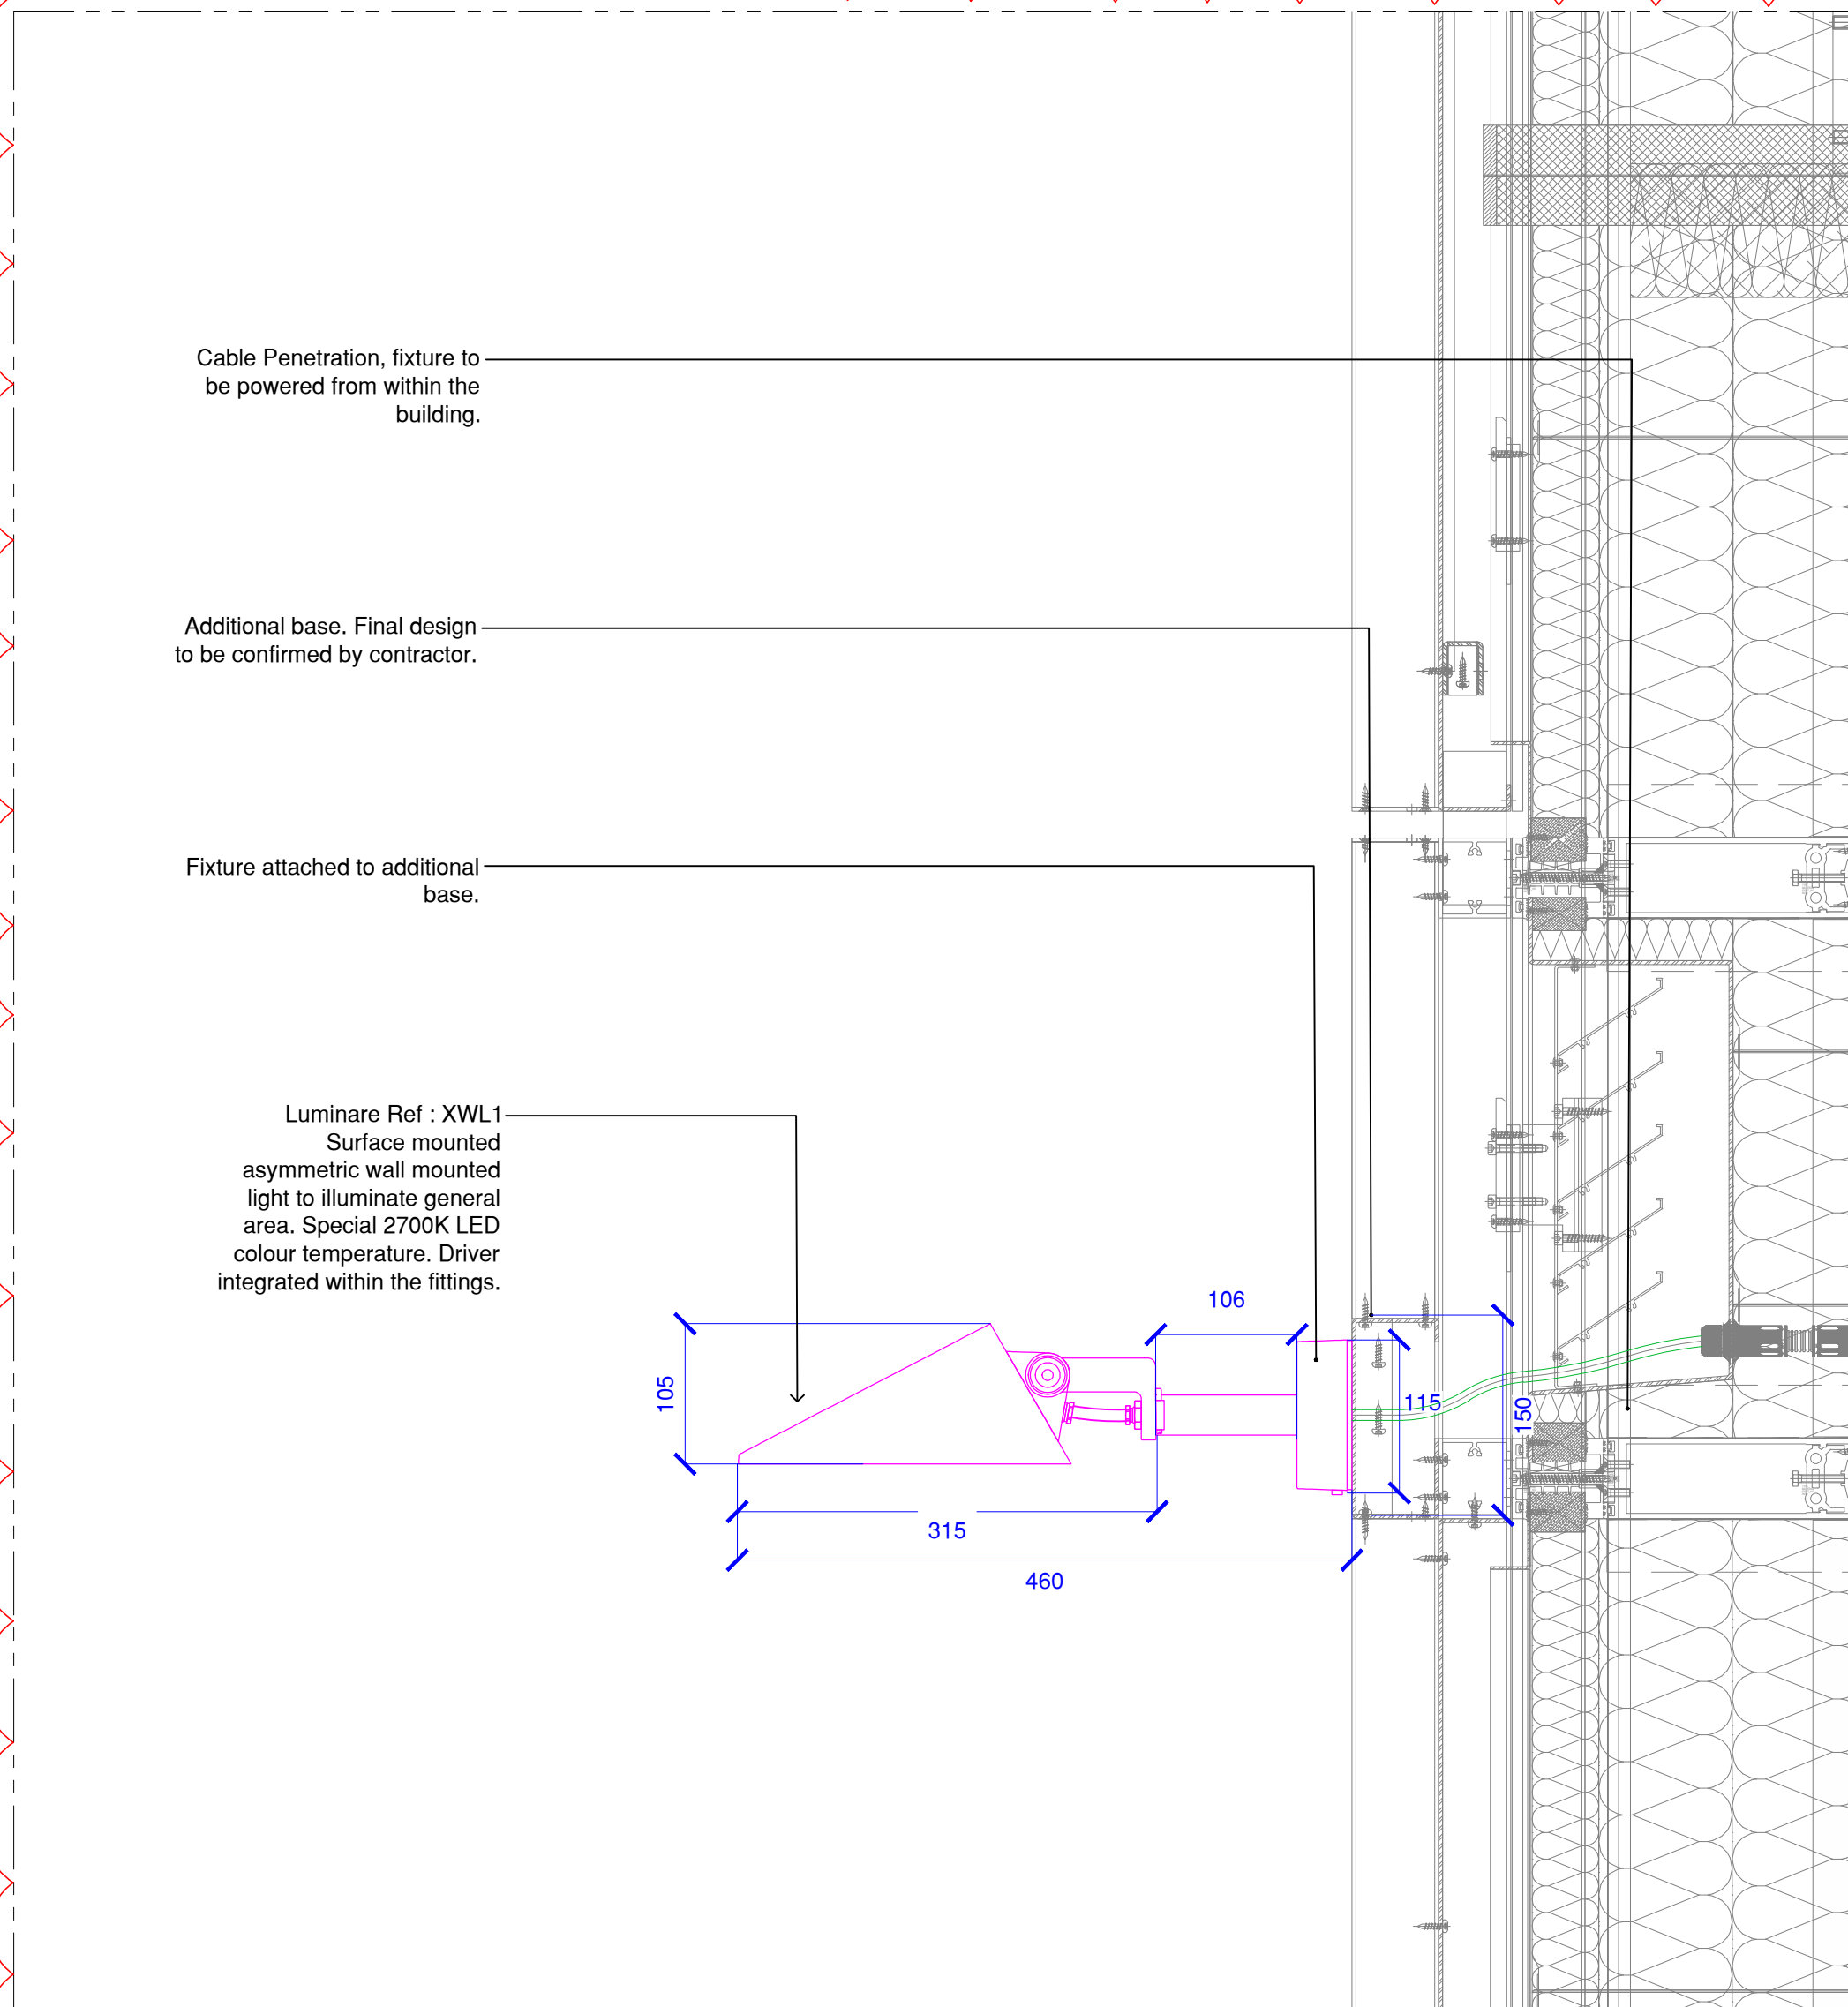


02 Wall Mounted Asymmetric Area Light - Building 1

Scale = 1:5

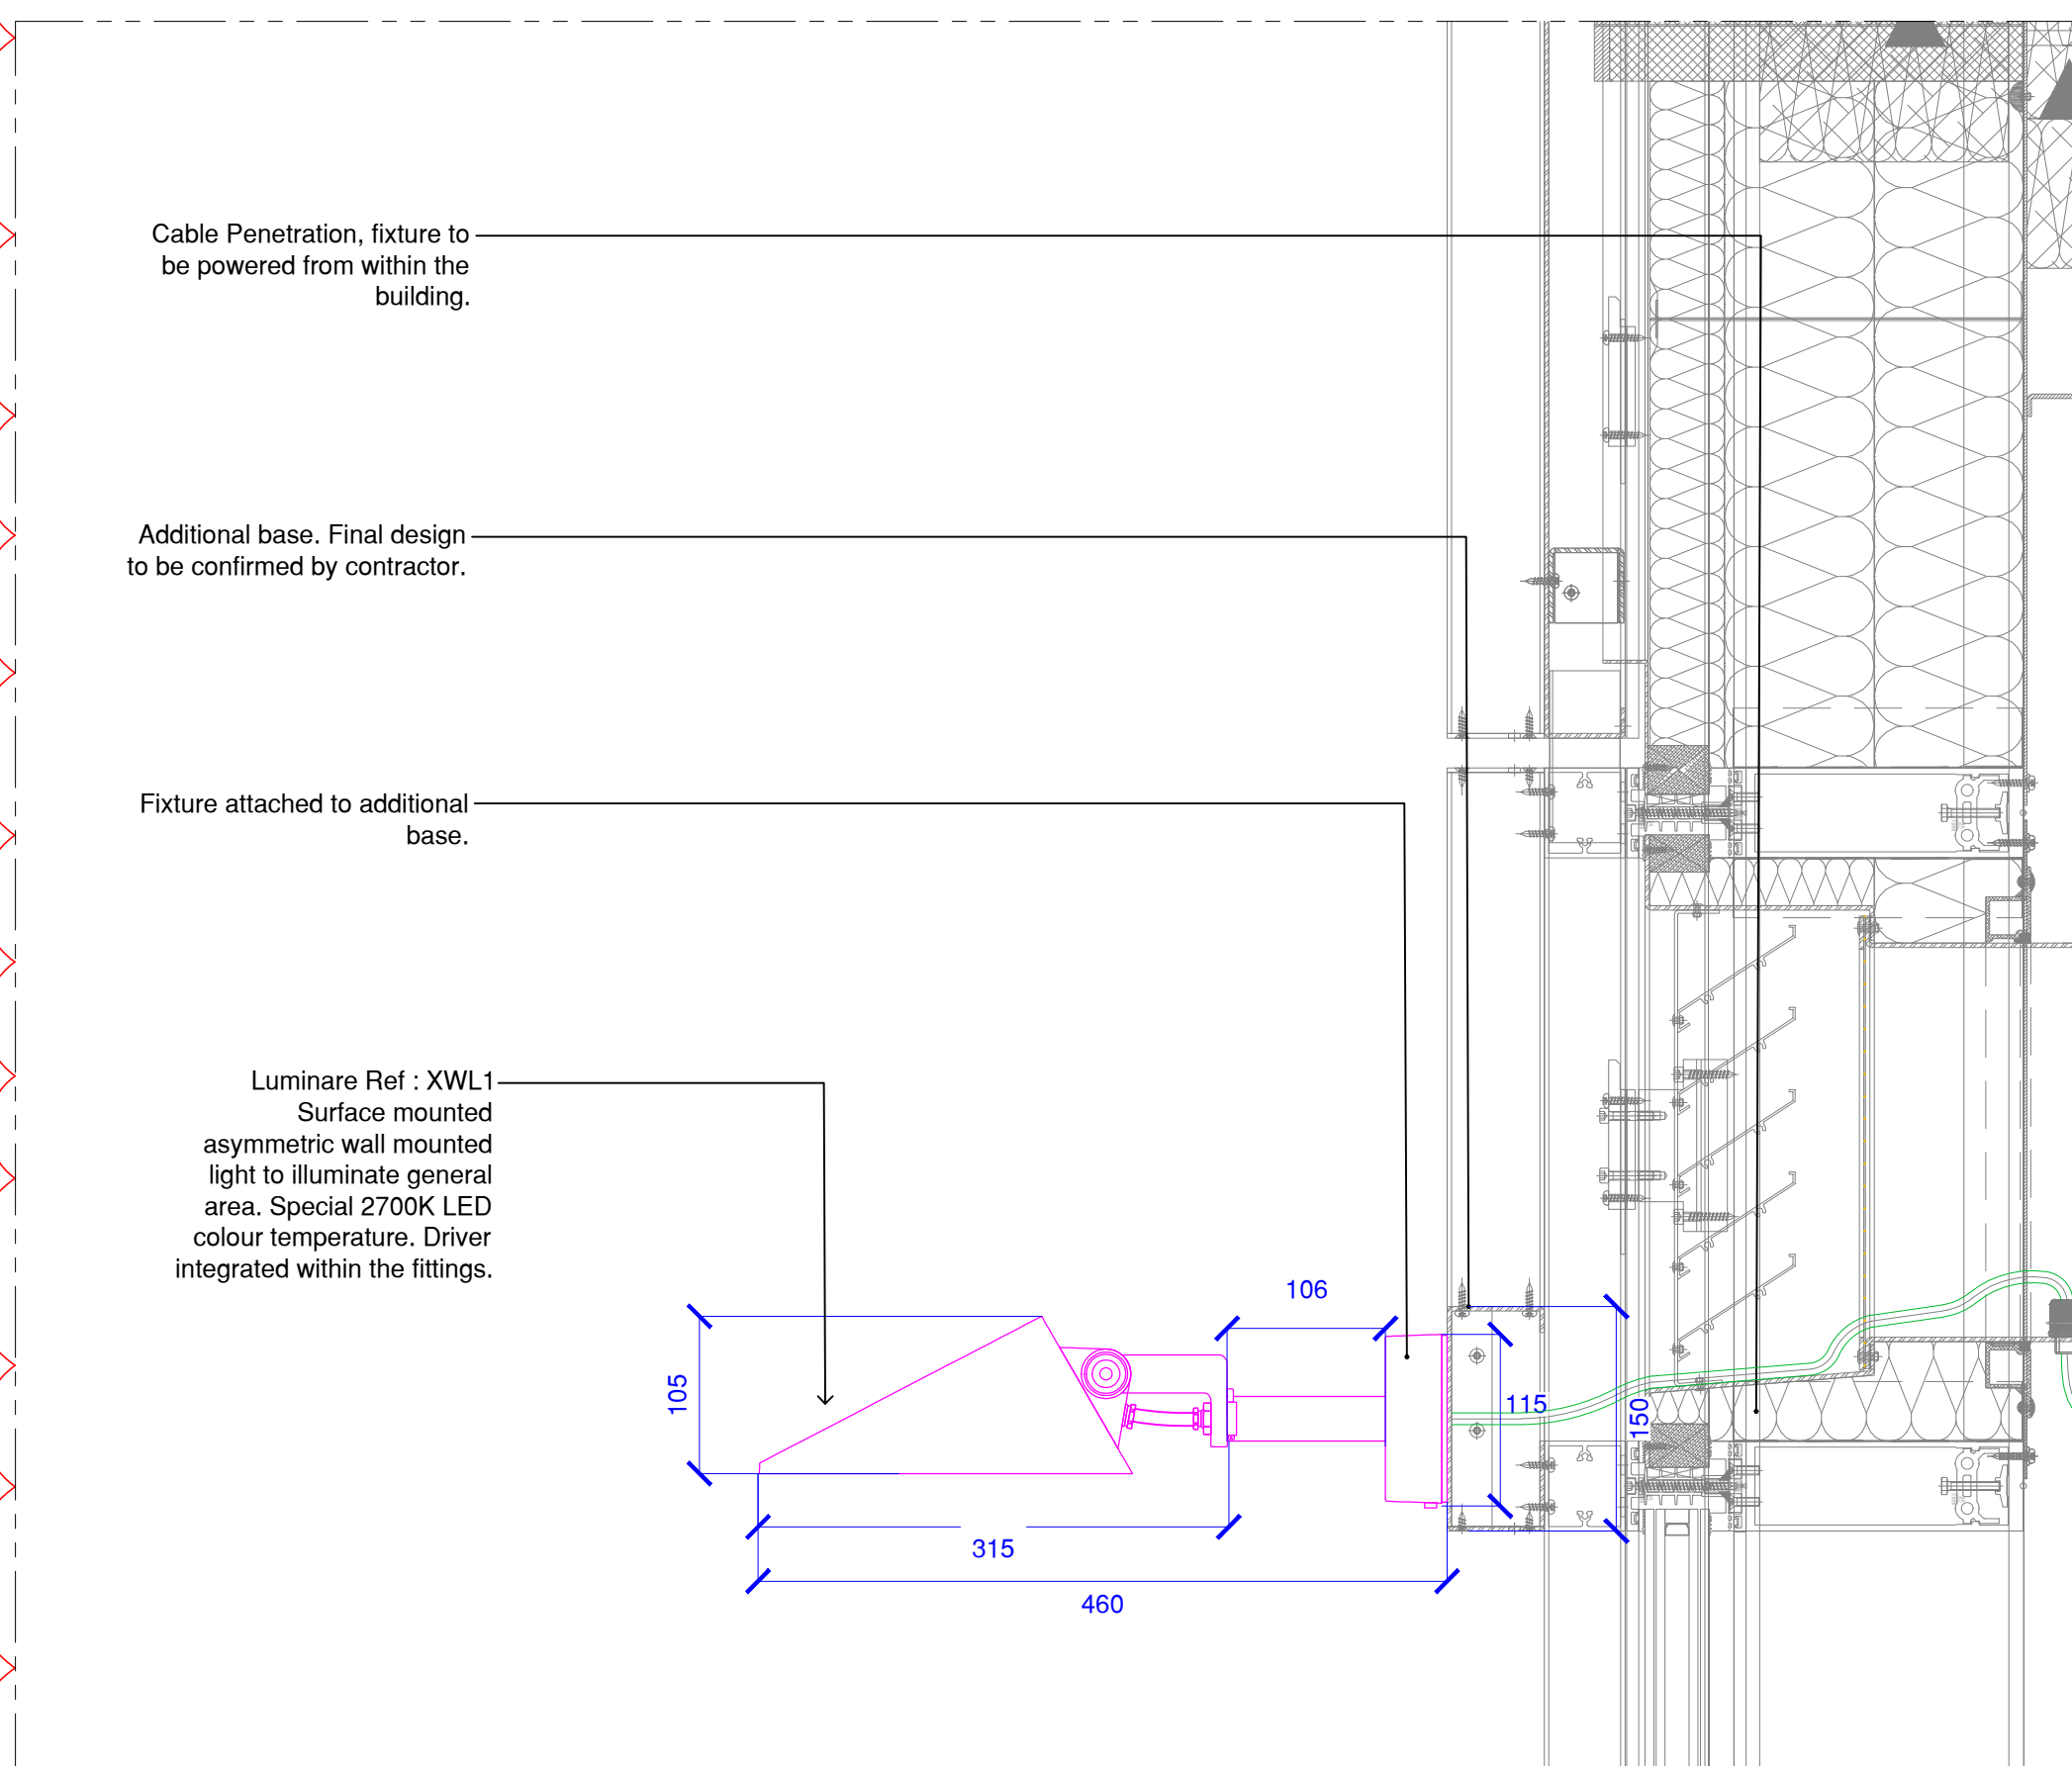


03 Wall Mounted Asymmetric Area Light - Building 2

Scale = 1:5

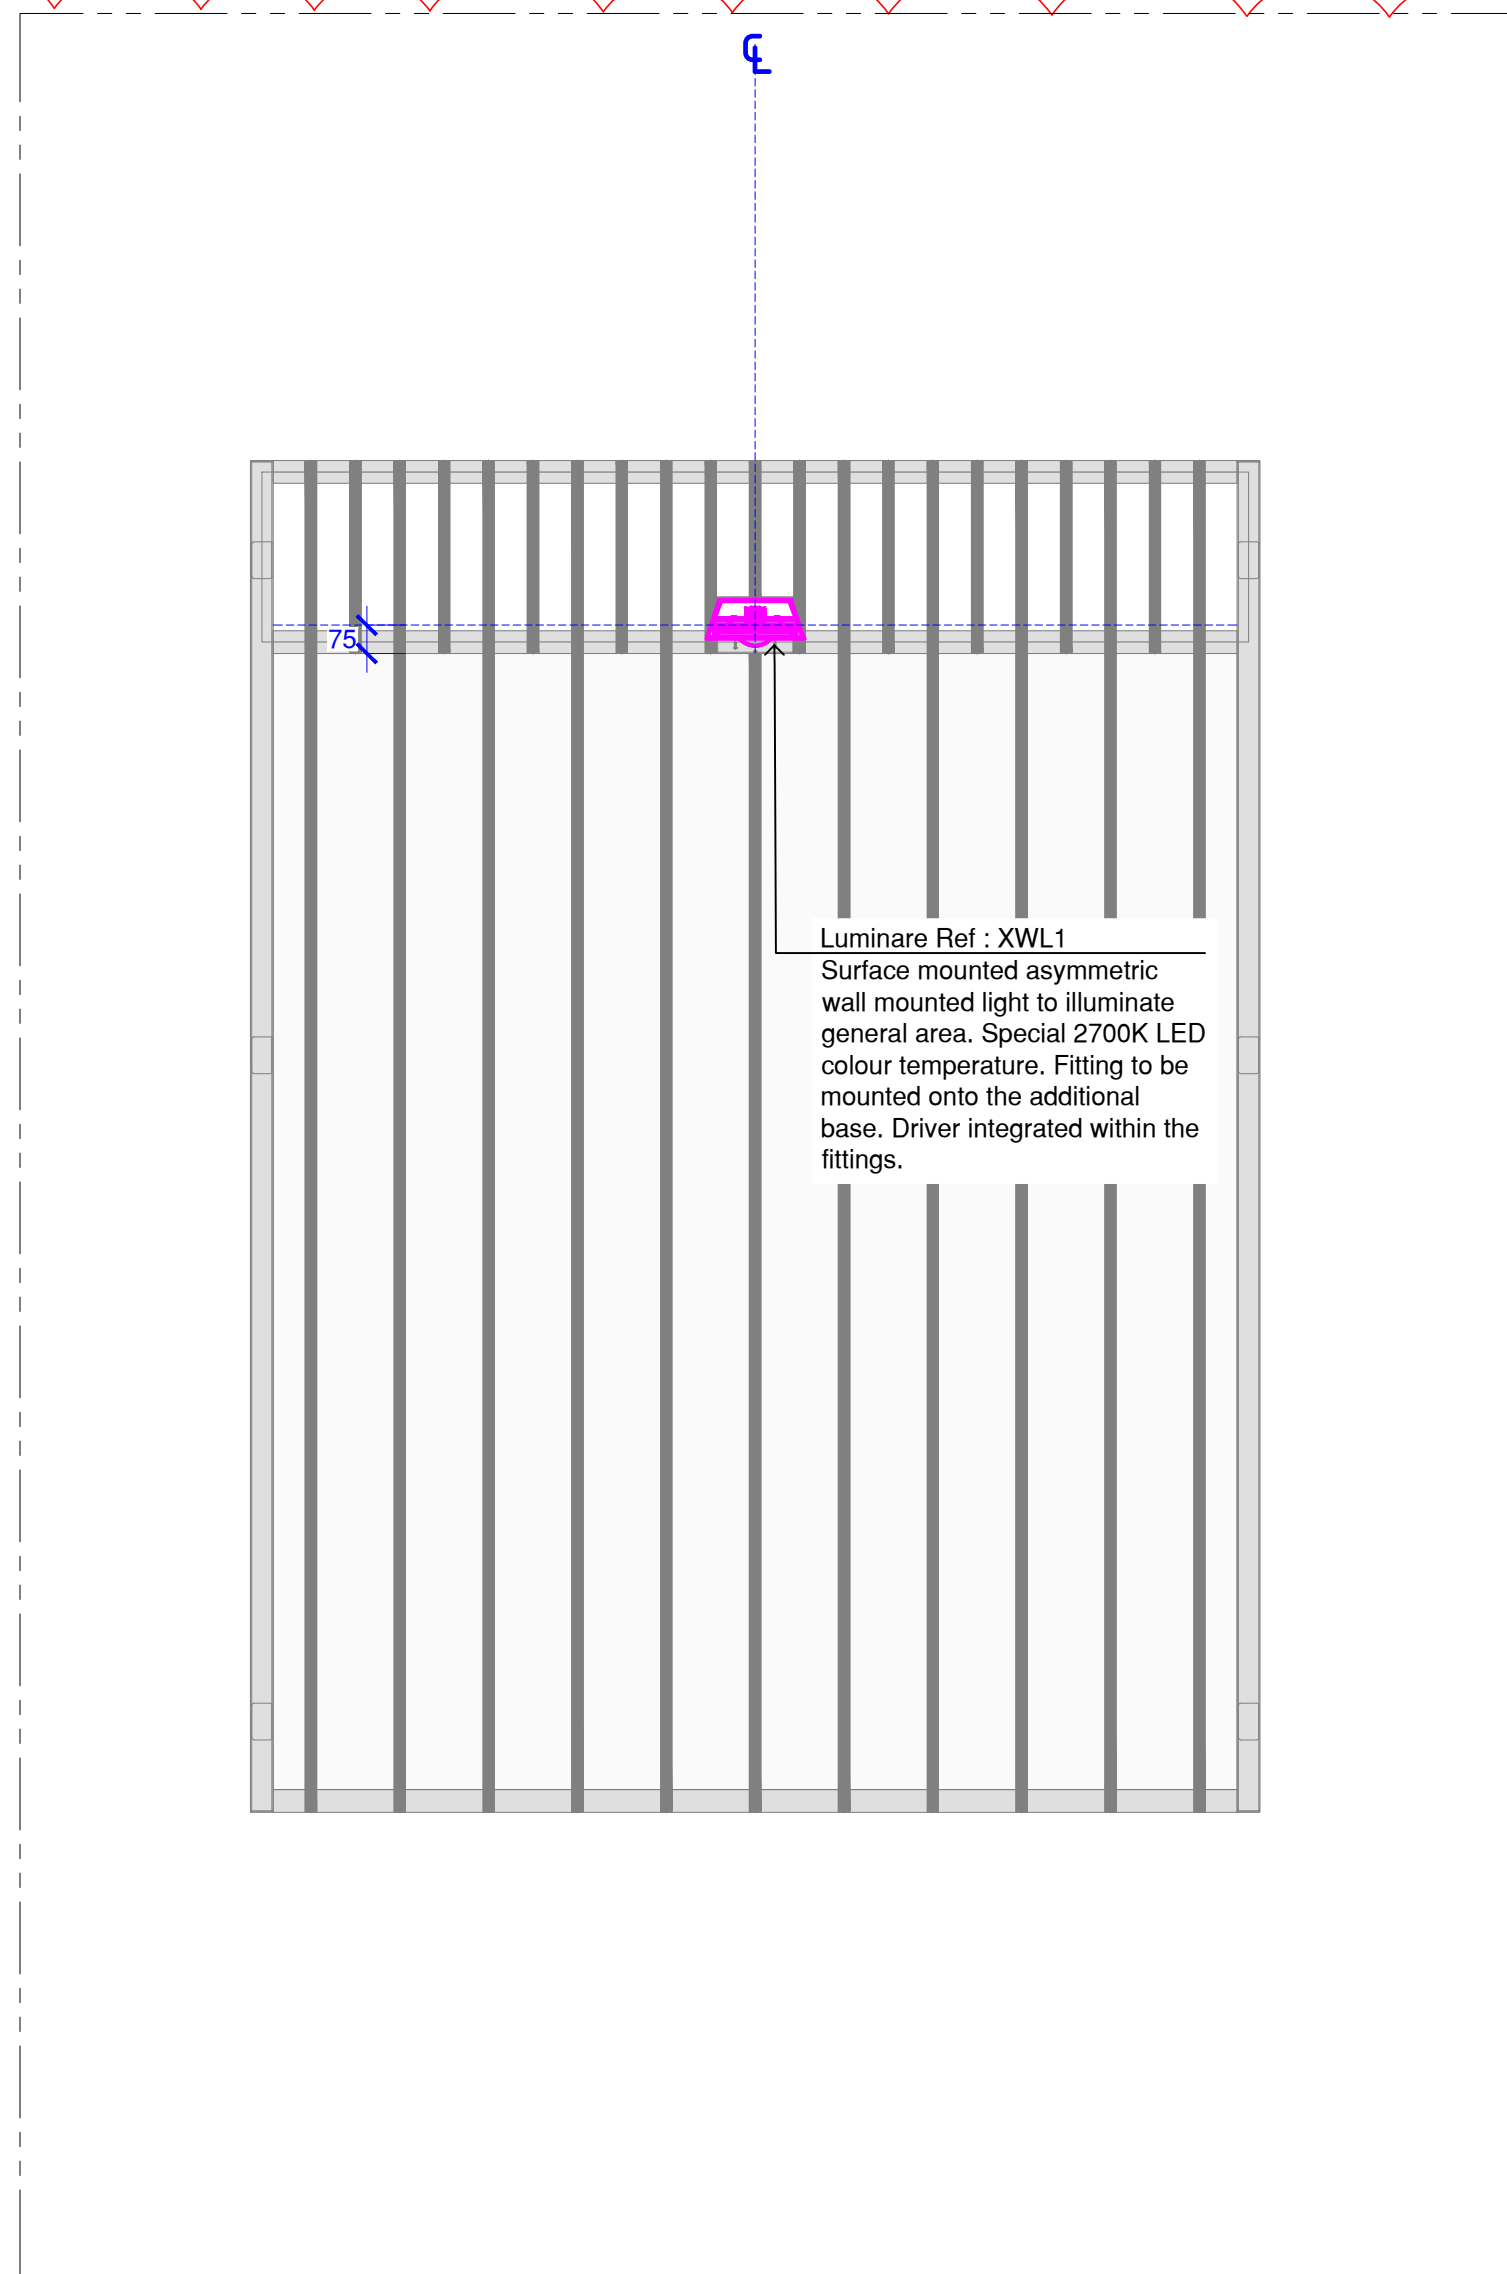

02a Wall Mounted Asymmetric Area Light - Building 1 Elevation

Scale = 1:20

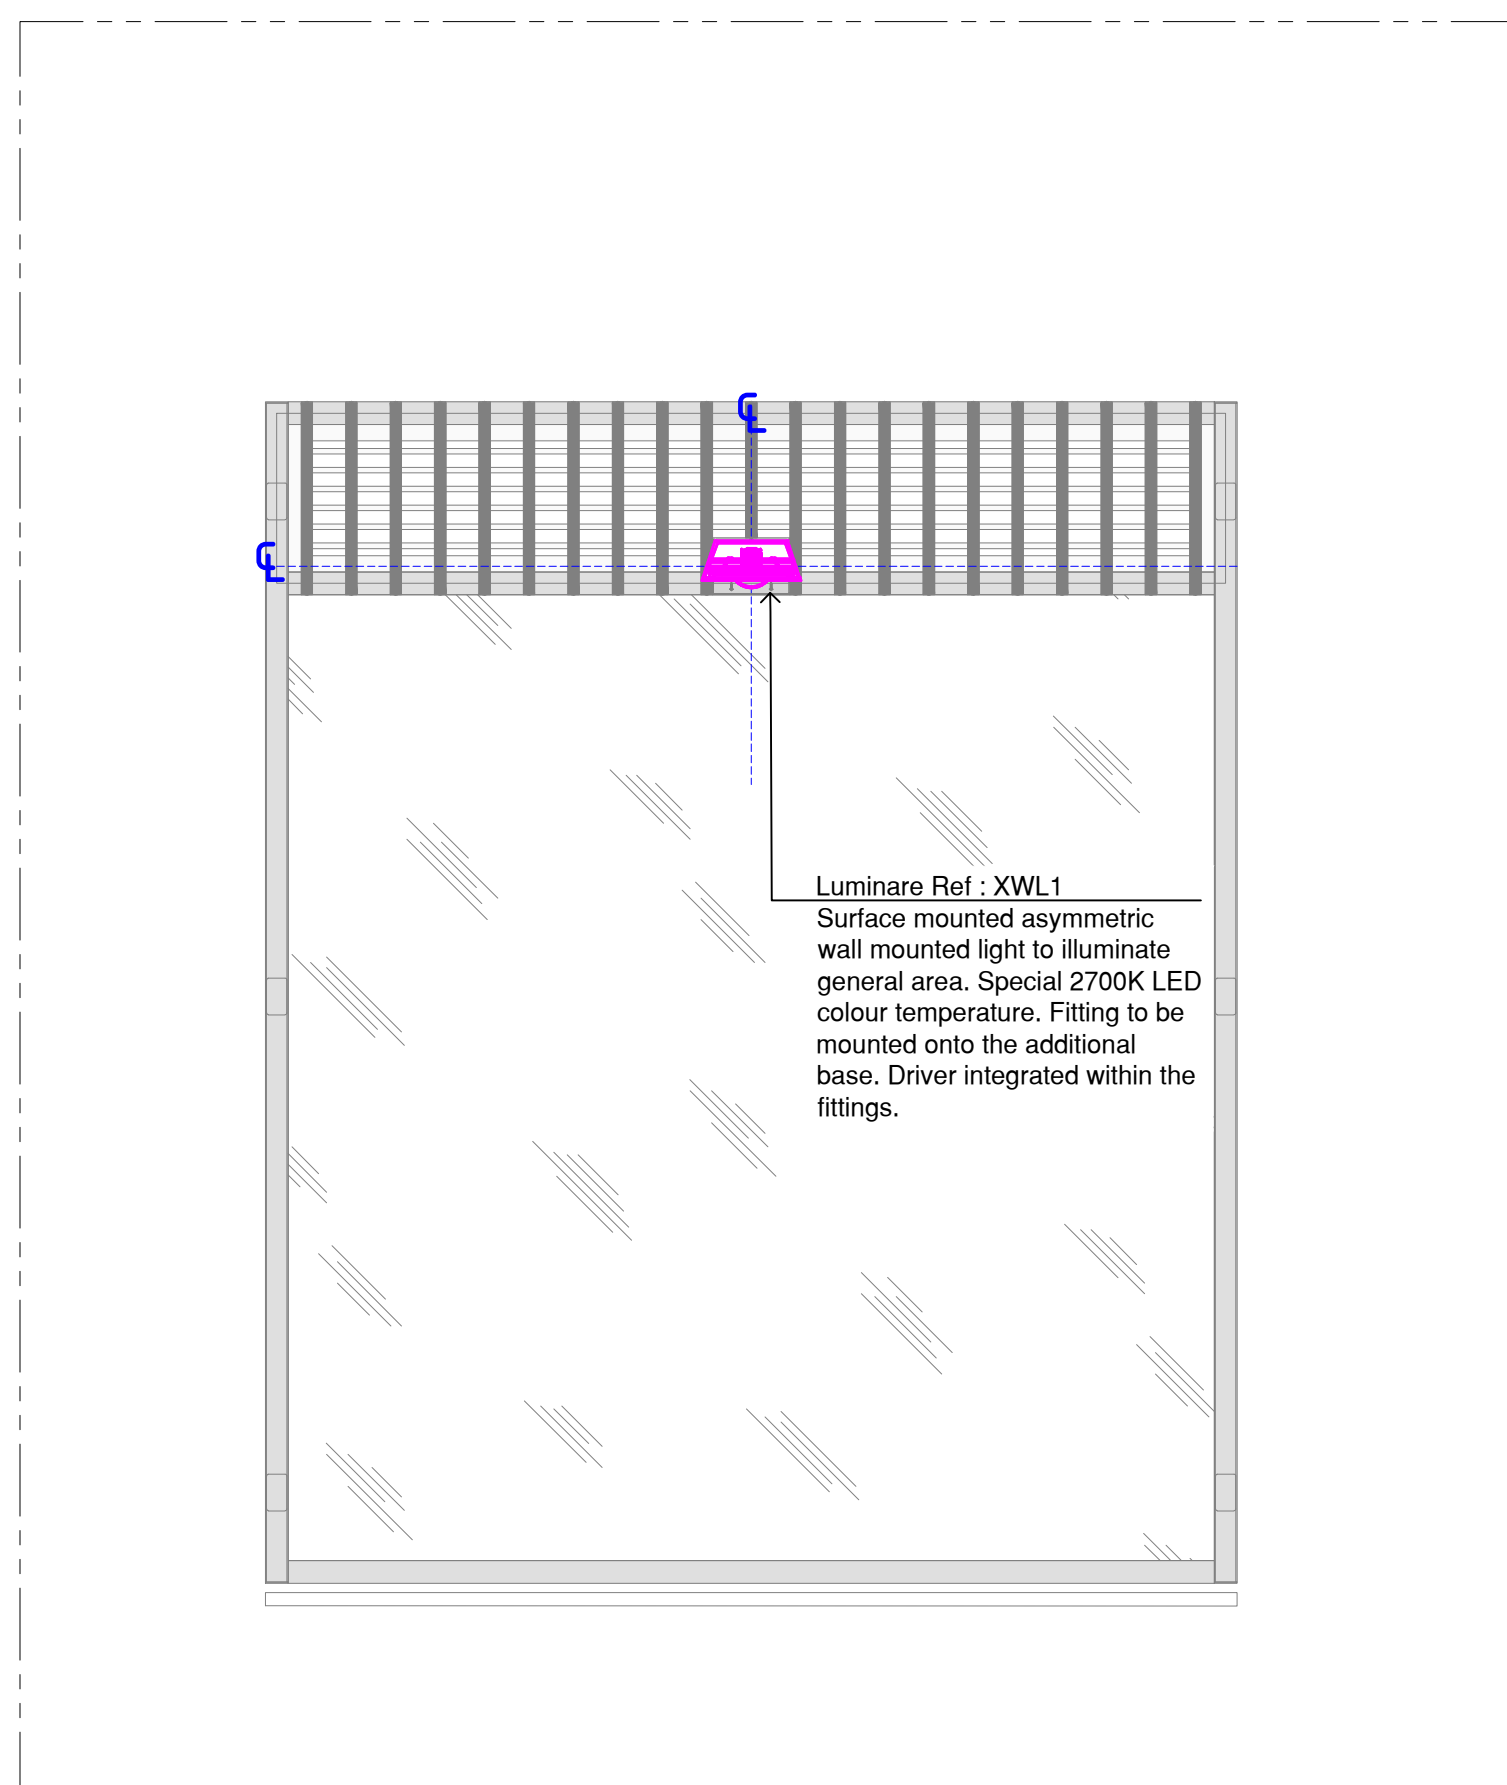


03a Wall Mounted Asymmetric Area Light - Building 2 Elevation

Scale = 1:20

DO NOT SCALE FROM THIS DRAWING. WORK FROM FIGURED DIMENSIONS ONLY. ALL DIMENSIONS TO BE VERIFIED BY THE CONTRACTOR ON SITE.

All designs are the property of Foundry UK LTD and must not be reproduced without their written approval.
Drawing to be read in conjunction with Foundry documentation. Any discrepancies between drawings and specifications must be reported prior to commencement of any work indicated on this drawing.
All lighting details to be confirmed by interior designer, architect or joinery specialist.
Proposed lighting construction drawing including all final setting out dimensions and details to be issued by the contractor for Foundry review and comment in good time before the lighting installation on site.
All electrical works associated with this drawing to be in accordance with the latest edition of IET wiring regulations and electrical engineer's specifications.
LED drivers to be located in a discreet ventilated accessible location.
Remote driver locations and any external drivers to be located in appropriate location.
LED drivers have a maximum distance from the fitting. Please refer to Foundry specifications and manufacturer data sheets. If in doubt, ask the contractor.
Accessories (junction boxes, IP rated boxes etc) to be provided by contractor.
For emergency and exit lighting please refer to electrical engineer's design documentation.
All information to be read in conjunction with symbol key

Key to Symbols

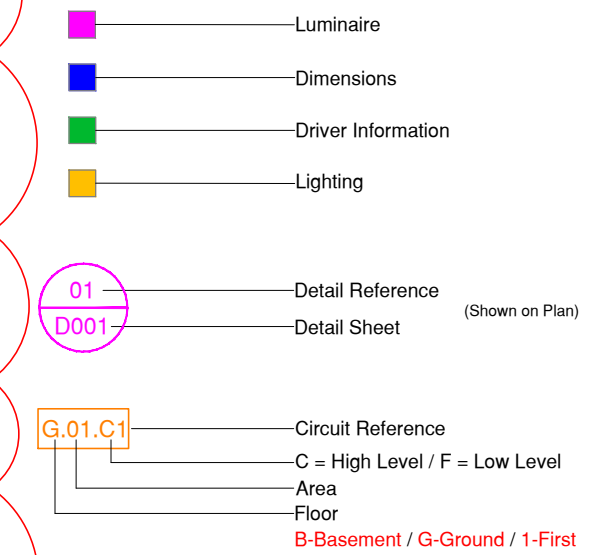

Notes

Please note these details are preliminary design intent details and require mock-ups & further coordination.

REMOTE DRIVERS TO BE STORED IN A DRY, ACCESSIBLE AND WELL VENTILATED LOCATION DETERMINED BY THE ELECTRICAL ENGINEER.

C01	29/09/2025	S4 Suitable for Stage Approval	MN	JB
P02	05/09/2024	S3 Suitable for Review & Comment	MN	JB
P01	25/01/2024	S3 Suitable for Review & Comment	SM	EC
Rev	Date	Comment	By	Chk

Project
Client
Midgard

Drawing Title
Landscape Lighting Details - 1

Drawing no. TH-IS-00-001-J-2613-63-500

Date	29/09/2025	Revision
Drawn by	MN	JB
Check by	S4 Suitable for Stage Approval	Variable @ A1

FOUNDry

T +44 (0)20 7232 4710 E info@foundry.london W www.foundry.london