



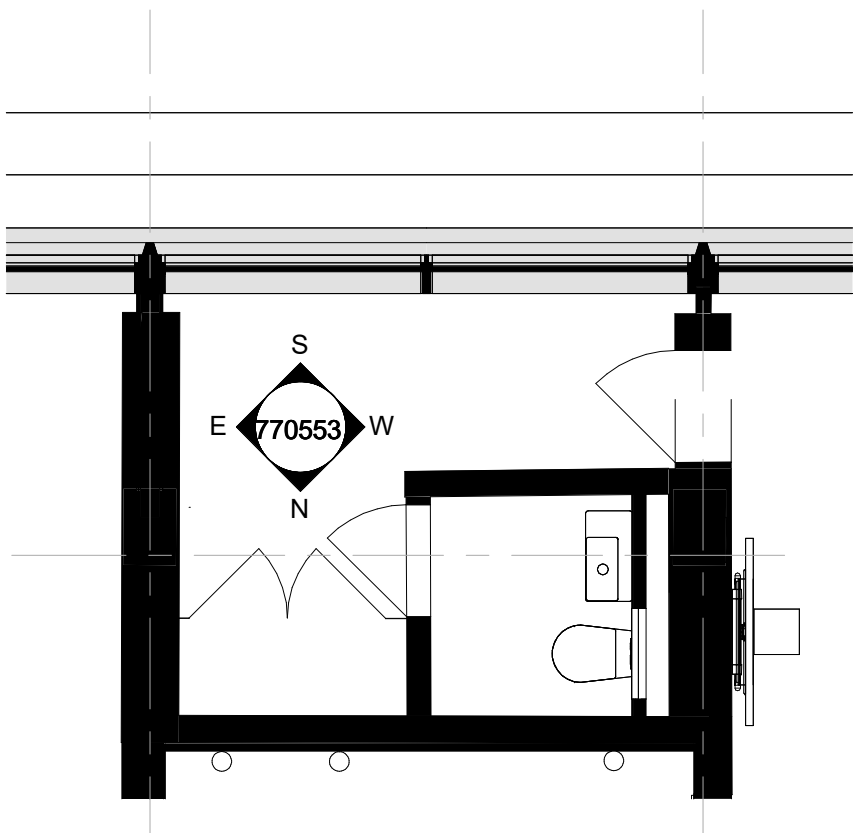


1 CC-01-012 - Mayor robing - Floor Plan
1:50

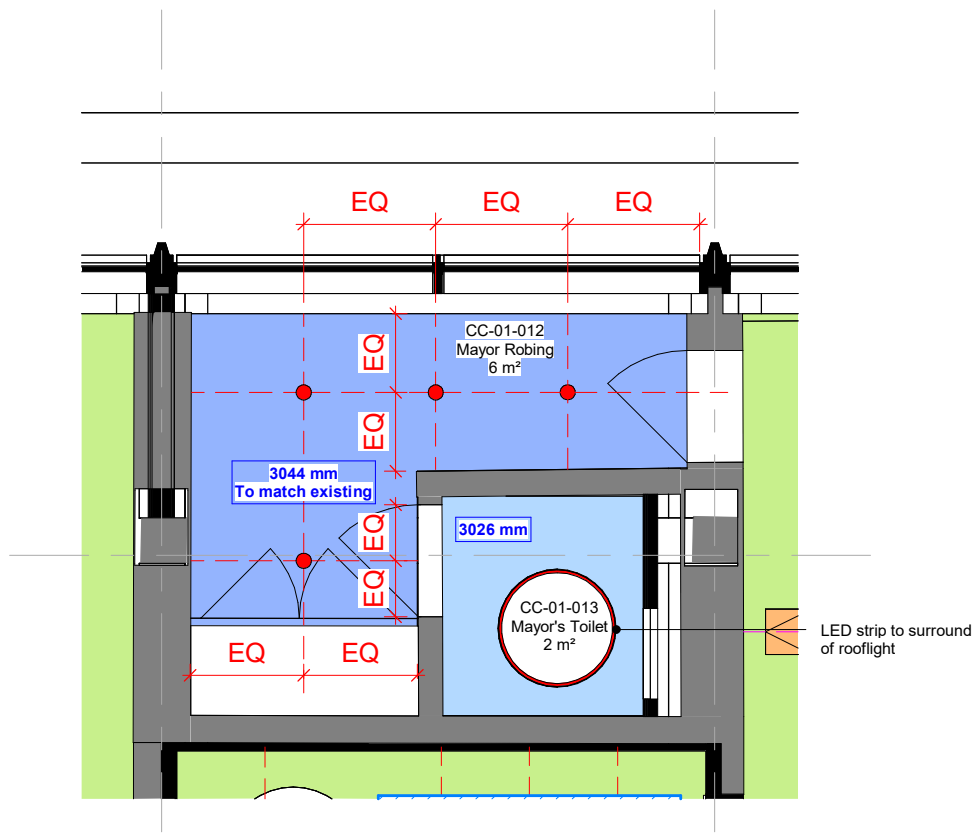


2 CC-01-012 - Mayor robing - Reflected Ceiling Plan
1:50




Robing room heritage panelling to be left in-situ

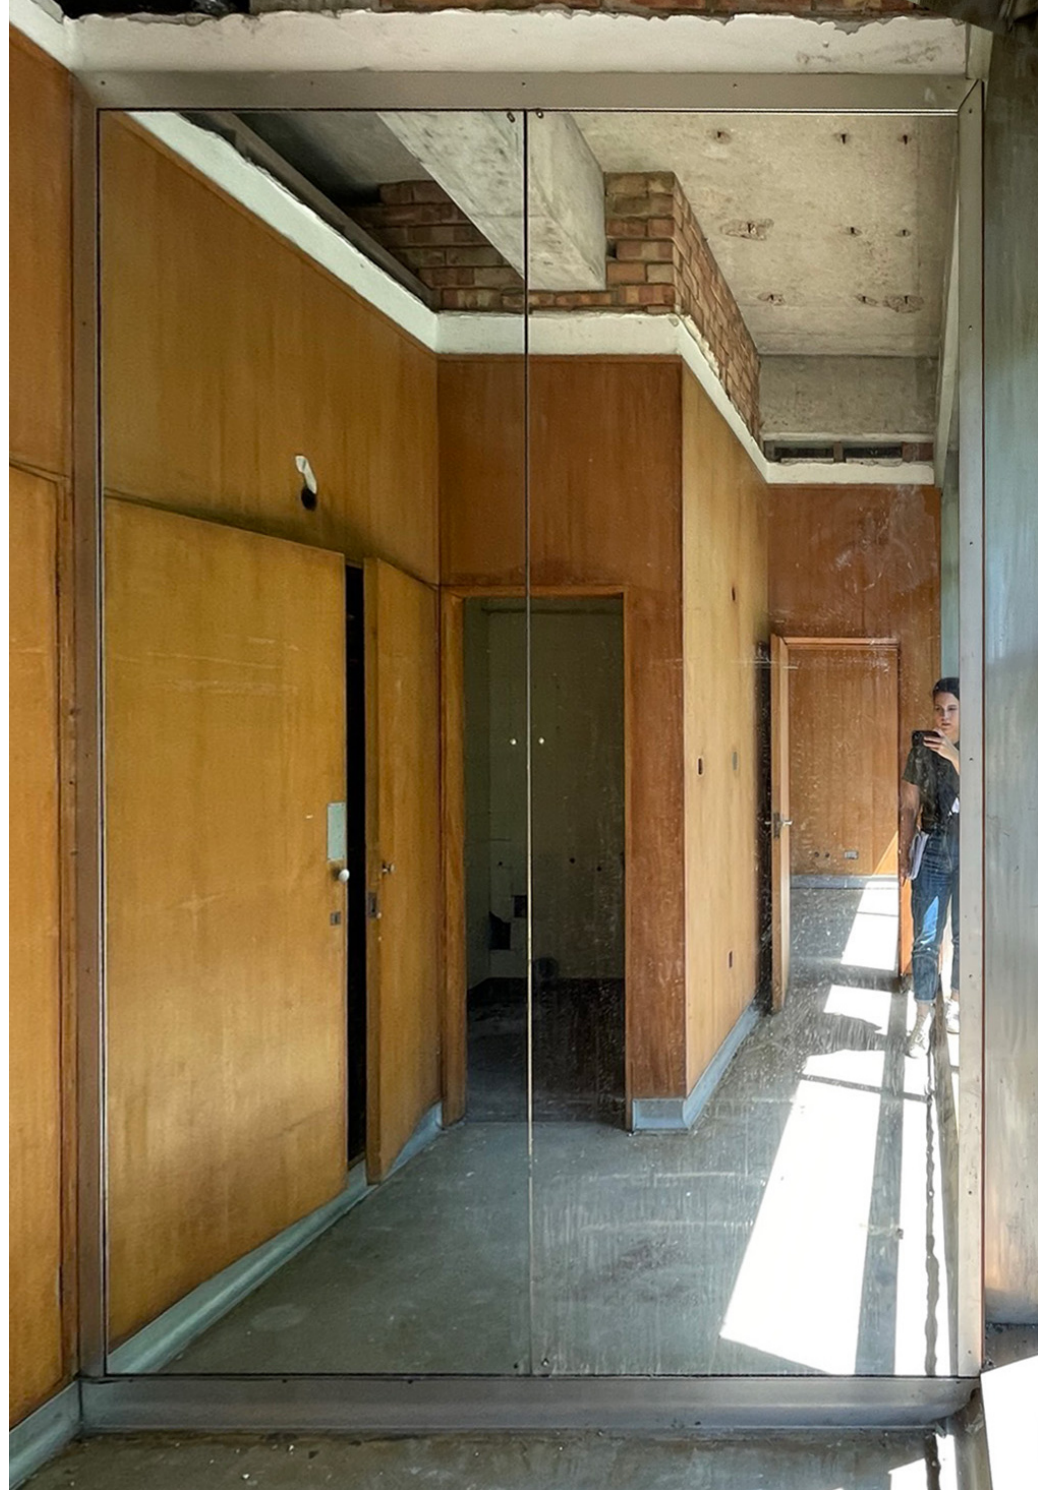


Heritage mirror to be left in-situ

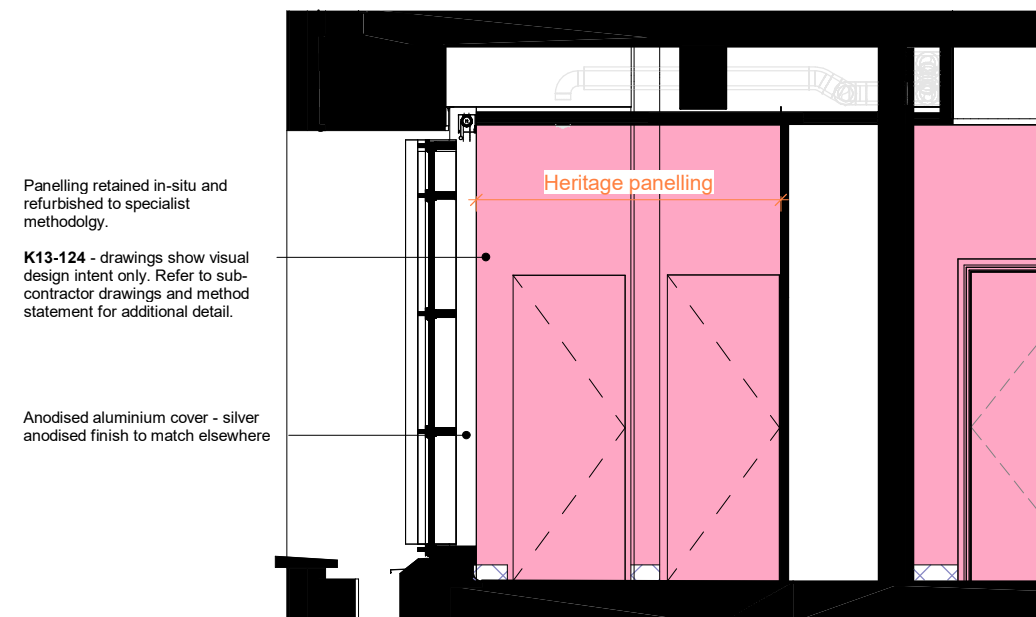


W CC-01-012 - Mayor robing - Elevation West
1:50

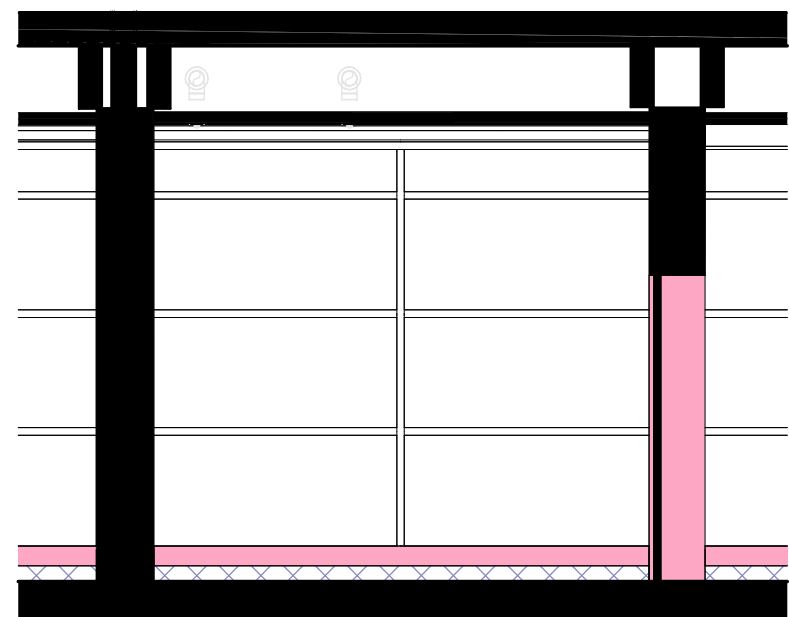

S CC-01-012 - Mayor robing - Elevation South
1:50

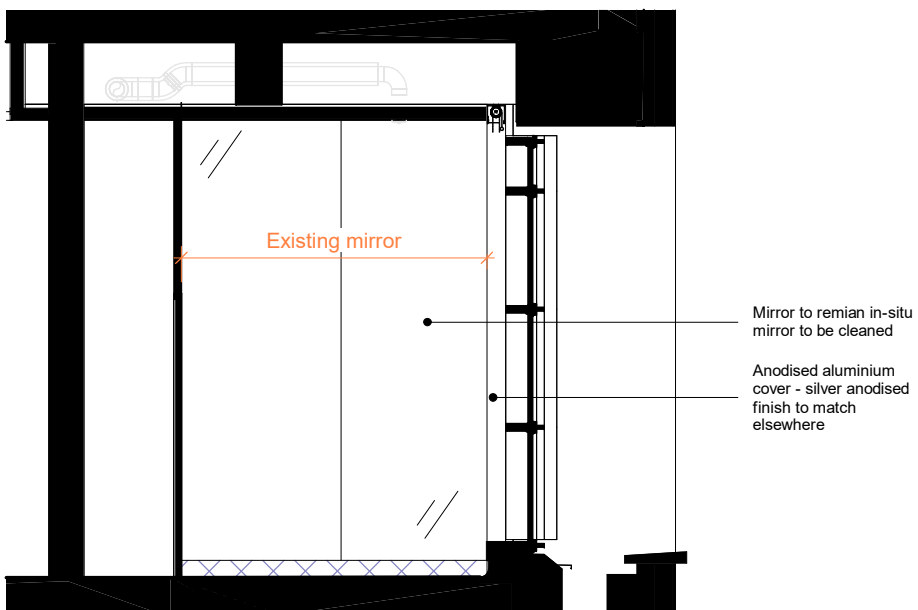

E CC-01-012 - Mayor robing - Elevation East
1:50

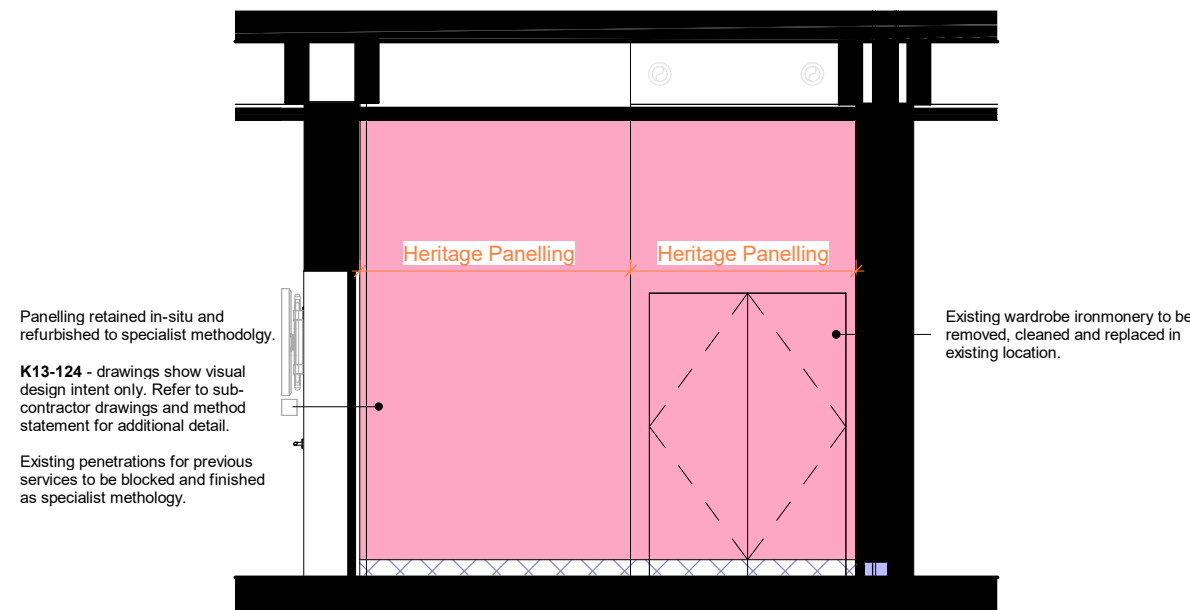

N CC-01-012 - Mayor robing - Elevation North
1:50

GENERAL

Room Function	Mayor Robing
Room Number	CC-01-012
Area	6 m²
Occupancy	1
Floor - Soffit Height	3300 mm
Floor - Ceiling Height (Lower)	3044 mm
Floor - Ceiling Height (Upper)	

ARCHITECTURAL

Floors	M51/130A - Carpet Tile
Walls	L10/310 External glazing C90/115G Mirrored wall K13/124 Elm panelling
Skirting	P20/151 Aluminium skirting
Ceiling	K10/220A Plasterboard Suspended Ceiling K10/220B Plasterboard Moisture Resistant Ceiling

FITTINGS / ACCESSORIES

- To Windows	N10/240B Anti-glare blinds
--------------	----------------------------

NOTES

- Refer to M&E Engineer drawings/ specification for services requirements
- Refer to Acoustic Consultant's drawings/ report for information
- Refer to Fire Engineer's report for detail on fire safety
- Refer to separate door & window scoping drawings and specification for additional information
- Refer to Joinery specialist information for comprehensive approach Joinery approach
- Refer to CMS information for comprehensive approach to AV-IT strategy
- Final finishes to be agreed with client team and conservation officer

ER's Reflected ceiling plans universal rules to be followed in stage 4b setting out

Open plan offices and typical meeting rooms - typical drawings HCC-HBA-AB-ZZ-DR-A-350407, HCC-HBA-AB-ZZ-DR-A-350408, HCC-HBA-AB-00-DR-A-350401, and HCC-HBA-CC-02-DR-A-350400 from ER set

1. Fan coil units to be concealed by only one acoustic panel. The Contractor should avoid placing FCUs over two panels for easy access and maintenance;
2. Suspended strip lights to be central to acoustic panels as per red dimensions and aligned to the underside of acoustic baffles;
3. Acoustic baffles in Open space office to be centred and equally spaced as per green grid lines:
 - A. Civic Centre – Acoustic panels to be equidistant from each other and ordered in relation to the structural grid as shown;
 - B. Annexe - Acoustic panels to be centered to window location per green lines;
 - C. Link Block - Acoustic panels to meet the position of tables and to be finalized according to latest furniture layout;
4. Height of panels and strip lights in open plan offices:
 - A. Civic centre - 2500 mm;
 - B. Annexe Ground Floor - 3000 mm;
 - C. Annexe 1st Floor - 2700 mm;
5. Monolithic ceilings in meeting rooms:
 - A. Downlight/alarms/emergency lights and all AV equipment to be installed in a regular grid line as demonstrated in red lines.

WALL FINISHES TYPES KEY

Proposed / New Finishes

- M60/110A - Painted Plaster (allow for M60/110C, to WCs, kitchen & showers)
- M60/110A M20/210 - Repair to existing plaster with paint finish
- K13/170B - Acoustic Class A Wall panels / pinboard
- P20/200 - MDF skirting, painted finish

Existing / Refurbished Finishes

- M40/115 - Florentine Travertine Stone retained in-situ
- K13/125 - Salvaged Elm Timber Panelling re-installed
- K13/124 - Existing Elm Timber Panelling retained in-situ
- P20/151 - Proposed Replacement Aluminium Skirting
- New insulated lining to facade


CEILING TYPES KEY

Proposed Finishes

- K10/220A Finish: M60/110B Plasterboard Suspended Ceiling
- K10/220B Finish: M60/110B Plasterboard Moisture Resistant Suspended Ceiling
- K10/220C Acoustic Class A Absorbent Ceiling
- K10/220E Bespoke vaulted Class A Ceiling to specialist design
- K13/130 Existing plank timber ceiling
- Under Slab Insulation to Civic Centre (concealed by ceiling finishes) Refer to 21 series details & Meinhardt retrofit strategy

OTHER CEILING FIXTURES

- K30/430 300 x 300mm Seamless access panels
- K30/430 450 x 450mm Seamless access panels
- K30/430 600 x 600mm Seamless access panels
- K30/XXX 800 x 1500mm Seamless access panels

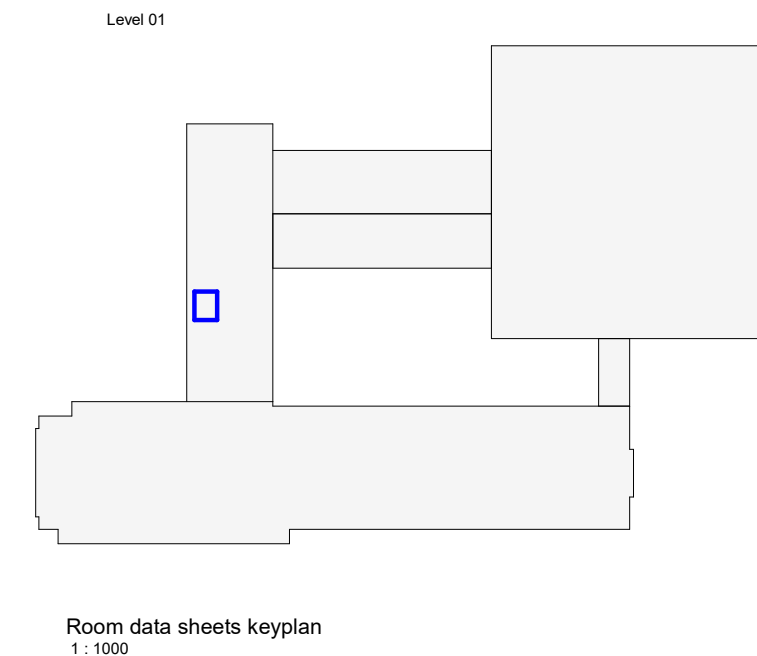

Room data sheets keyplan
1:1000

ELECTRICAL SYMBOLS KEY

Indicative symbols for setting out purposes only. Drawings to be read in conjunction with MEP drawings and specification.

- Light switch
- Data/ telephone/ wireless point (Refer to MEP information)
- Cleaner socket
- Fused spur
- Double switch socket outlet
- Outlet plate
- Floorbox (Refer to MEP information for types)
- Room booking system

- M Recessed microphone
- S Recessed speaker

- Light fittings
- Refer to MEP information for types

- Ceiling recessed ventilation grille
- Refer to MEP information for types

SETTING OUT / DIMENSIONS

- Ceiling / acoustic raft setting out
- Light and fixtures setting out
- Ventilation grilles/spigot setting out - solid ceilings
- REFER TO MEP INFORMATION FOR VENTILATION SETTING OUT IN OPEN AREAS
- Access panel setting out
- Floor to ceiling heights

Copyright Hawkins\Brown Architects
No implied licence exists. This drawing should not be used to calculate areas for the purposes of valuation. Do not scale this drawing. All dimensions to be checked on the site by the contractor and such dimensions to be their responsibility. All work must comply with relevant British Standards and Building Regulations requirements. Drawing errors and omissions to be reported to the architect. To be read in conjunction with Architect's specification and other consultant information.

Rev	Description	Date
P01	For Coordination	24.11.25
P02	For review & comment	03.02.26
P03	For review & comment	17.04.26



30 Clerkenwell Road
London
EC1M 5PG

mail@hawkinsbrown.com
hawkinsbrown.com

Hawkins\Brown

Project
Haringey Civic Centre
High Rd,
Wood Green,
N22 8LE

Drawing
Mayor's Robing - CC-01-012 -
Room Data Sheet

Scale @ A1
As indicated

Date
13.03.26

Drawn By
AK

Checked By
JM

Job Number 190149A	Status S3	Purpose of Issue For Review and Comment
-----------------------	--------------	--

Drawing No. HCC-HBA-CC-01-DR-A-770553	Rev P03
--	------------