
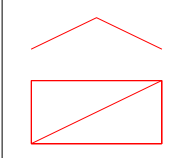
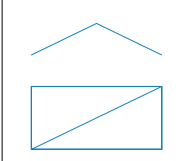
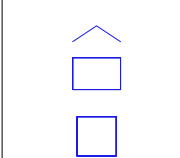
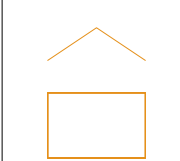



SCHEDULE							
SYMBOL	LABEL	MANUFACTURER	CATALOG NUMBER	DESCRIPTION	QUANTITY	LUMENS PER LAMP	WATTAGE
	XA+E	HOLOPHANE EUROPE LIMITED	DWL.1.LA014.HN.W007.EM3	DENVER ID WALL, HN DISTRIBUTION, WALL MOUNT @ 3.5m, INTEGRATED LIGHTING CONTROL 'SIMPLE', 3-HOUR MAINTAINED INTEGRATED EMERGENCY CIBSE TM66 CEAM RATING '2.6'	11	897	6.5
	XB+E	HOLOPHANE EUROPE LIMITED	DWL.1.LA014.AY.W007.EM3	DENVER ID WALL, AY DISTRIBUTION, WALL MOUNT @ 3.5m, INTEGRATED LIGHTING CONTROL 'SIMPLE', 3-HOUR MAINTAINED INTEGRATED EMERGENCY CIBSE TM66 CEAM RATING '2.6'	3	864	6.5
	XC	HOLOPHANE EUROPE LIMITED	DSX0.4.LA114.FWE (TZ)	D-SERIES 0 AREA LUMINAIRE, FWE DISTRIBUTION, COLUMN MOUNT @ 6m, INTEGRATED LIGHTING CONTROL 'CONNECTED', CIBSE TM66 CEAM RATING '2.3'	4	10897	75
	XD	HOLOPHANE EUROPE LIMITED	DSX0.4.LA134.FWE (TZ)	D-SERIES 0 AREA LUMINAIRE, FWE DISTRIBUTION, WALL MOUNT @ 8m, INTEGRATED LIGHTING CONTROL 'CONNECTED', CIBSE TM66 CEAM RATING '2.3'	3	12879	90

STATISTICS				
DESCRIPTION	SYMBOL	AVG	MIN	MIN/AVG
Car Park Walkway 5 LUX / 0.25 Uo	+	16 LUX	9 LUX	0.56
Perimeter Walkway 5 LUX / 0.25 Uo	+	7 LUX	7 LUX	0.43
Service Yard 20 LUX / 0.25 Uo	+	22 LUX	22 LUX	0.32
Side Walkway 5 LUX / 0.25 Uo	+	11LUX	11 LUX	0.45
Spill	+	1 LUX	1 LUX	0.00
Car Park 20 LUX / 0.25 Uo	+	20 LUX	12 LUX	0.60

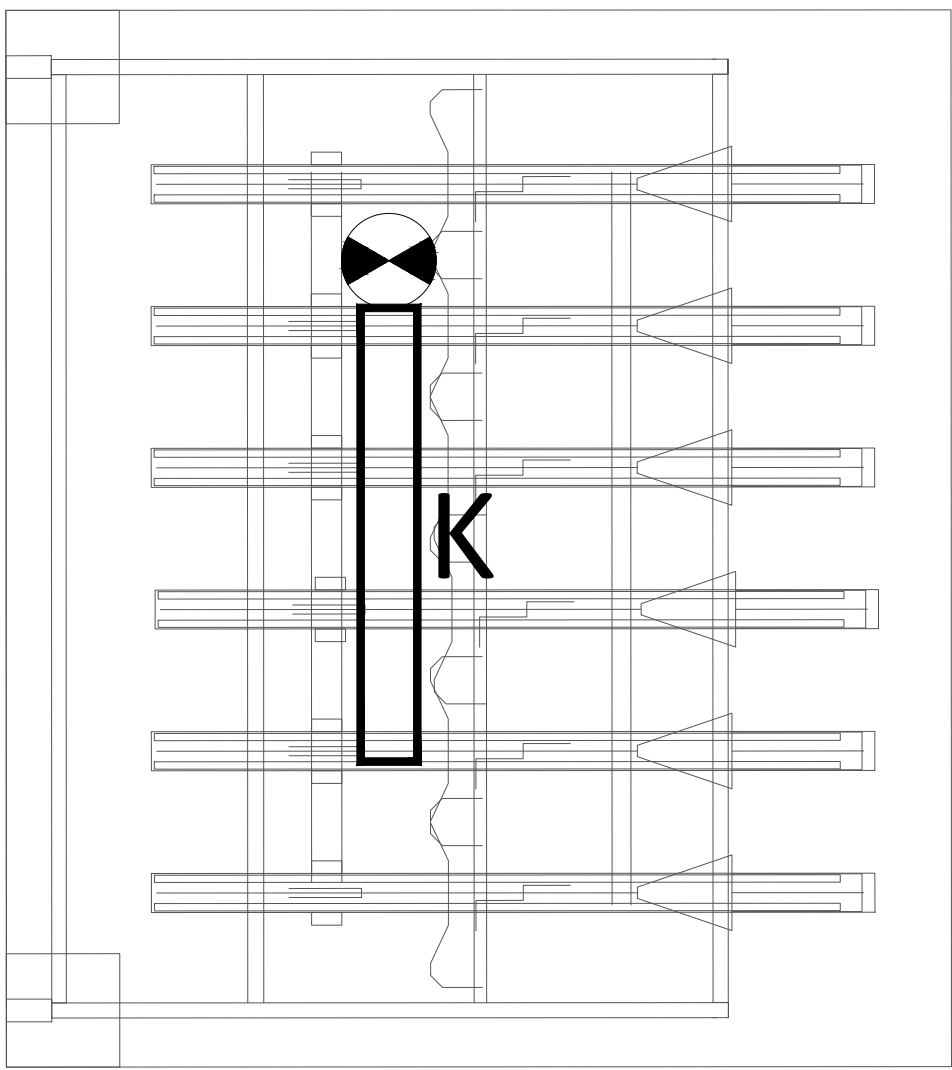

CYCLE STORE
EXTERNAL LIGHTING LAYOUT
NOT TO SCALE

NORTH-WEST VIEW
EXTERNAL LIGHTING LAYOUT
NOT TO SCALE

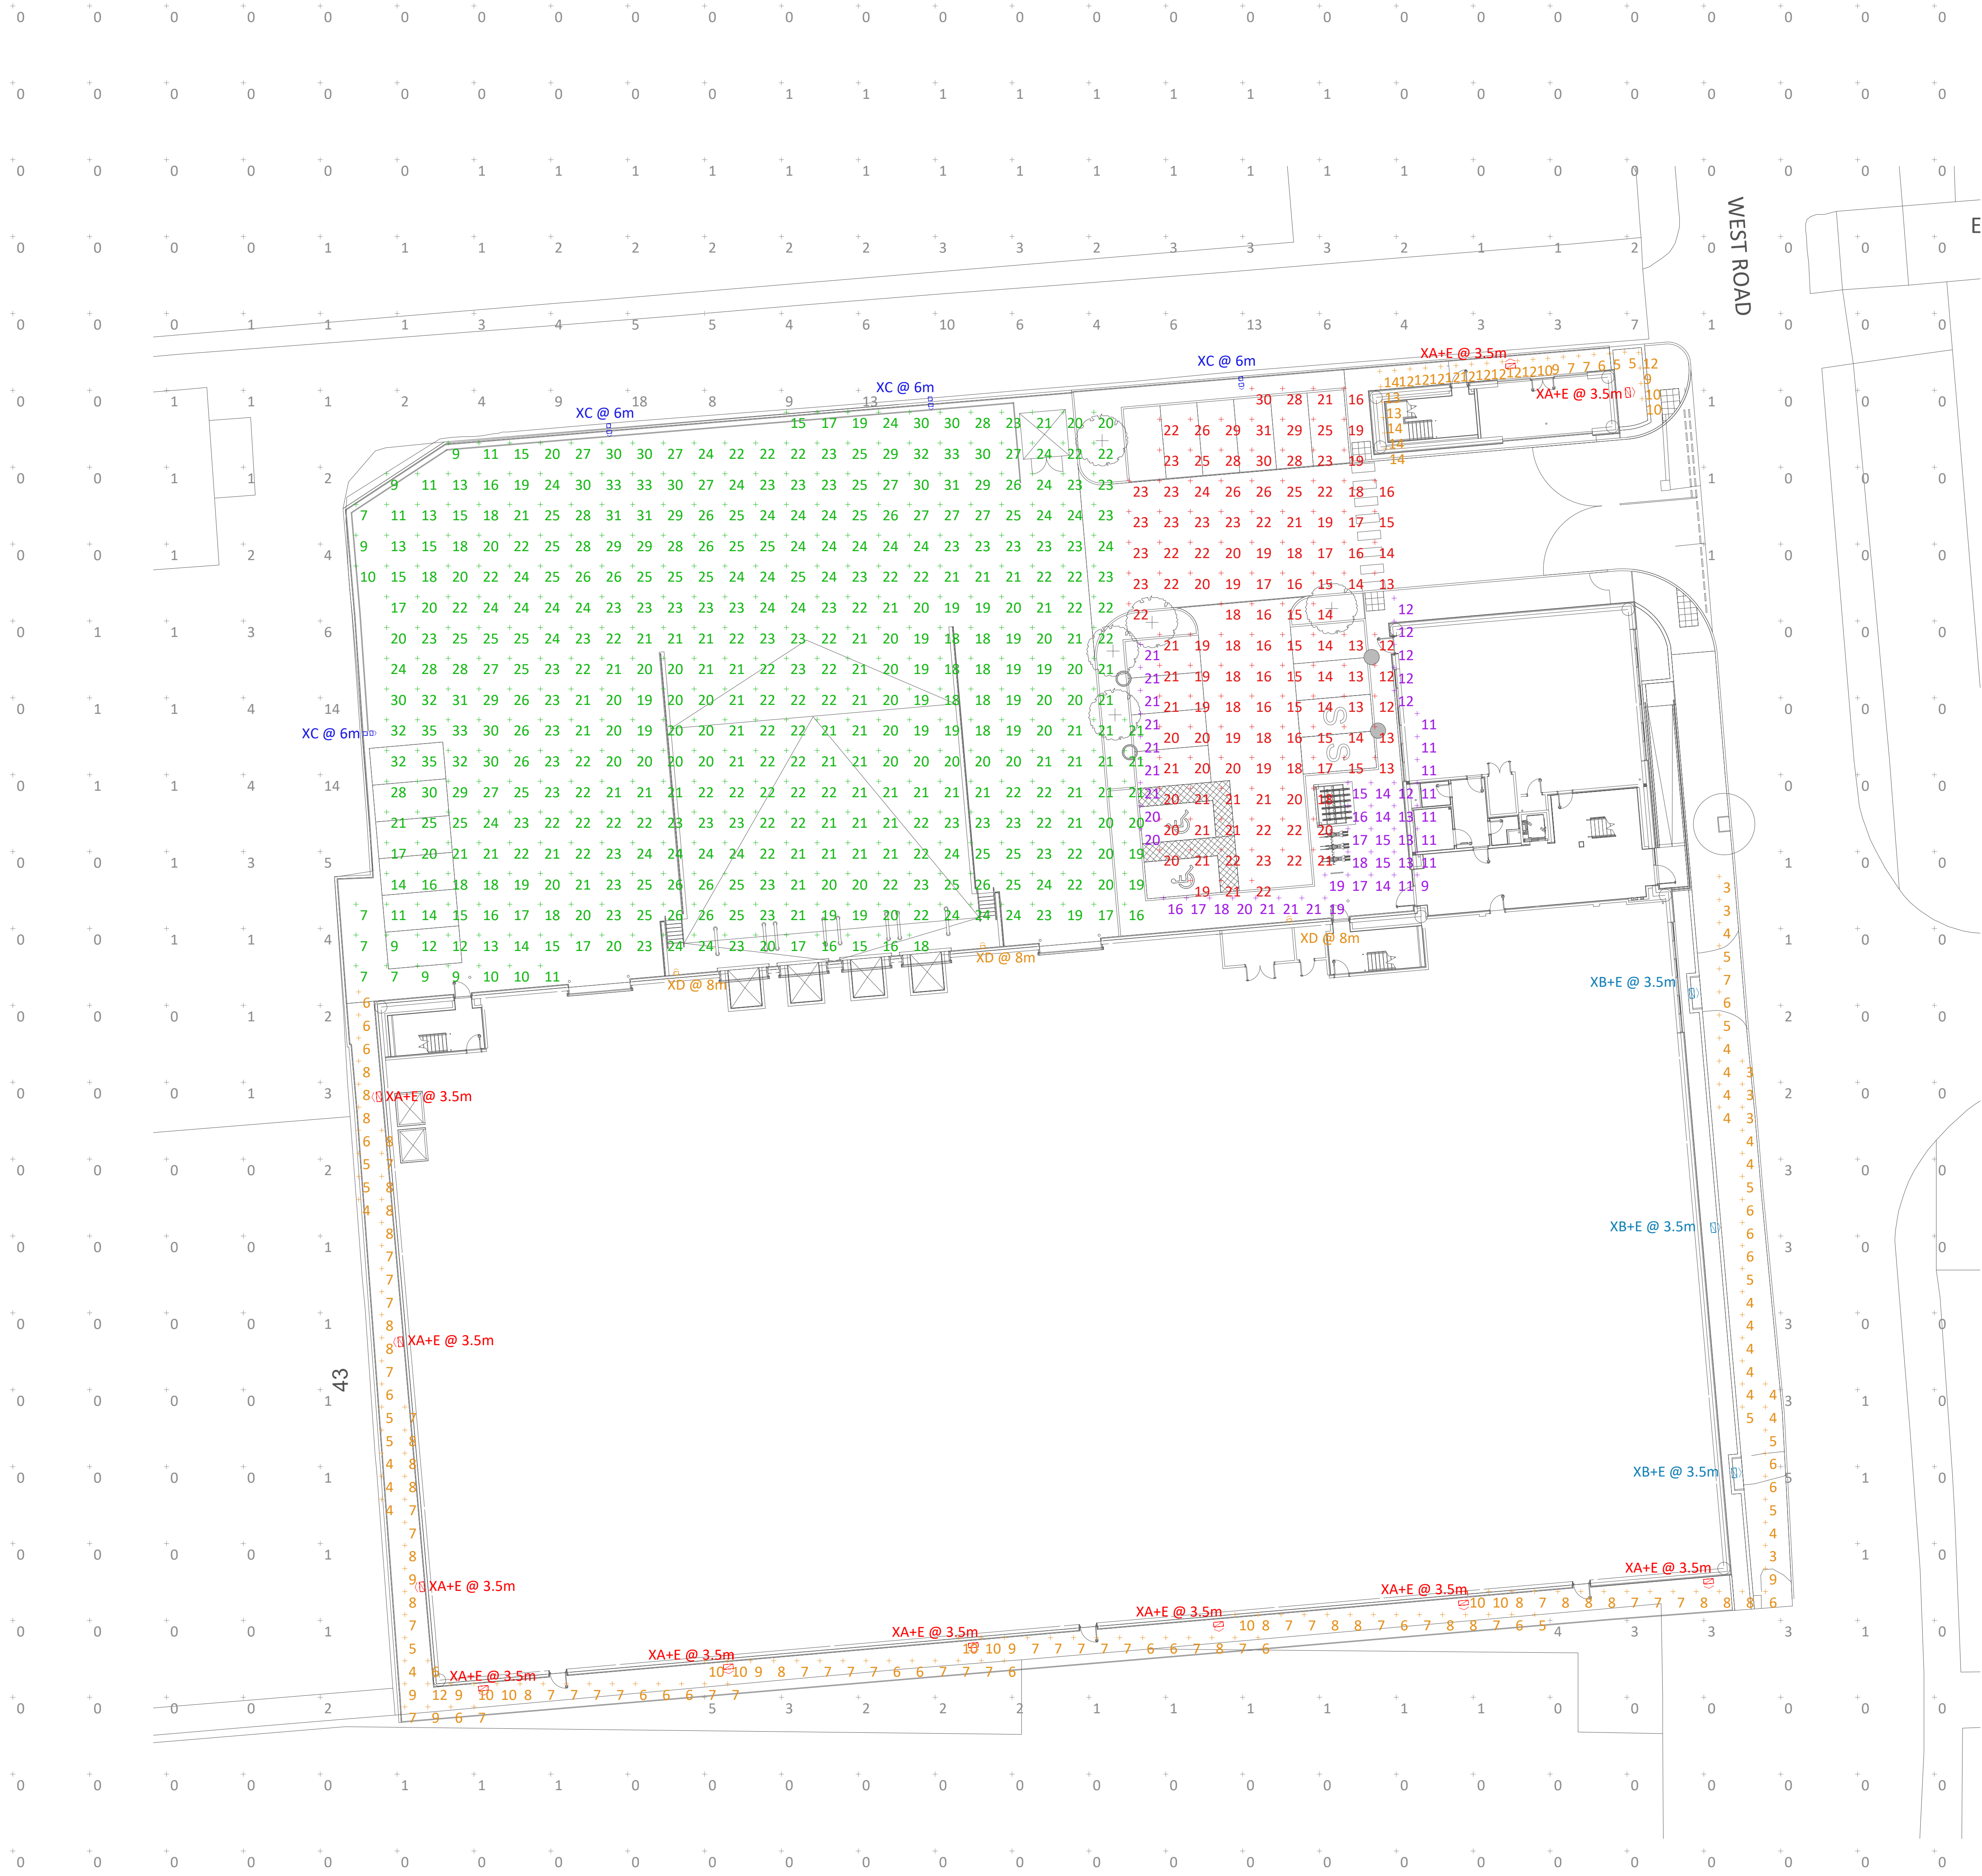

PLAN VIEW
EXTERNAL LIGHTING LAYOUT
SCALE - 1:200 @ A0

- NOTES:
- ALL CALCULATIONS ARE MAINTAINED AT 2,000 HOURS.
 - THE CONTOUR LINES ON THE 3-D VIEW REPRESENT 5 LUX FROM SOURCE.
 - ALL LUMINANCE VALUES SHOWN ARE THE RESULT OF THEORETICAL COMPUTER CALCULATIONS, SUMMATED BY LUMINAIRES POSITIONED IN A FIXED RELATIONSHIP TO EACH OTHER AND THE STATISTICAL ZONE.
 - IN PRACTICE THE VALUES MAY VARY DUE TO TOLERANCES IN COLUMN INSTALLATION, LUMINAIRE ORIENTATION, SURFACE REFLECTANCE AND FLUCTUATIONS IN POWER SUPPLY (VOLTAGE).
 - RESULTS PROVIDED WITHIN THIS DESIGN ARE DERIVED FROM PRODUCT SPECIFIC PHOTOMETRY, THE SUBSTITUTION OF ALTERNATIVE LUMINAIRES WILL NOT PRODUCE COMPARABLE RESULTS.

LUMINAIRE KEY



TYPE XA+E and XB+E
Denver ID Wall



TYPE XC
D-Series Column Mounted



TYPE XD
D-Series Wall Mounted



TYPE K
Glamox Corrist

DESIGN INTENT

2	06-10-25	Tender Issue	LKB
1	25-02-25	Planning Issue	LKB
Rev	Date	Description	Initials
 SHEPHERD BROMBLEY PARTNERSHIP Unit 28 Basepoint Business Centre 1 Winton Valley Road Winchester Hampshire SO23 0LD Tel: 01962 832656 Web: www.shepherdbrombley.co.uk			

Client:
Hillwood Investment Properties International Ltd

Project Title:
West Road
Tottenham

Drawing Title:
External Lighting Layout

Scale:	1:200	Paper Size:	A0	Drawn By:	LKB	Checked By:	DB
Drawing Number:	0278 / E / 200	Rev:	2	Drawing Status:	Tender		

This drawing is the copyright of SB Partnership. It is sent to you in confidence. It may be reproduced internally for use on this project only. It remains our property and must be returned on request.