



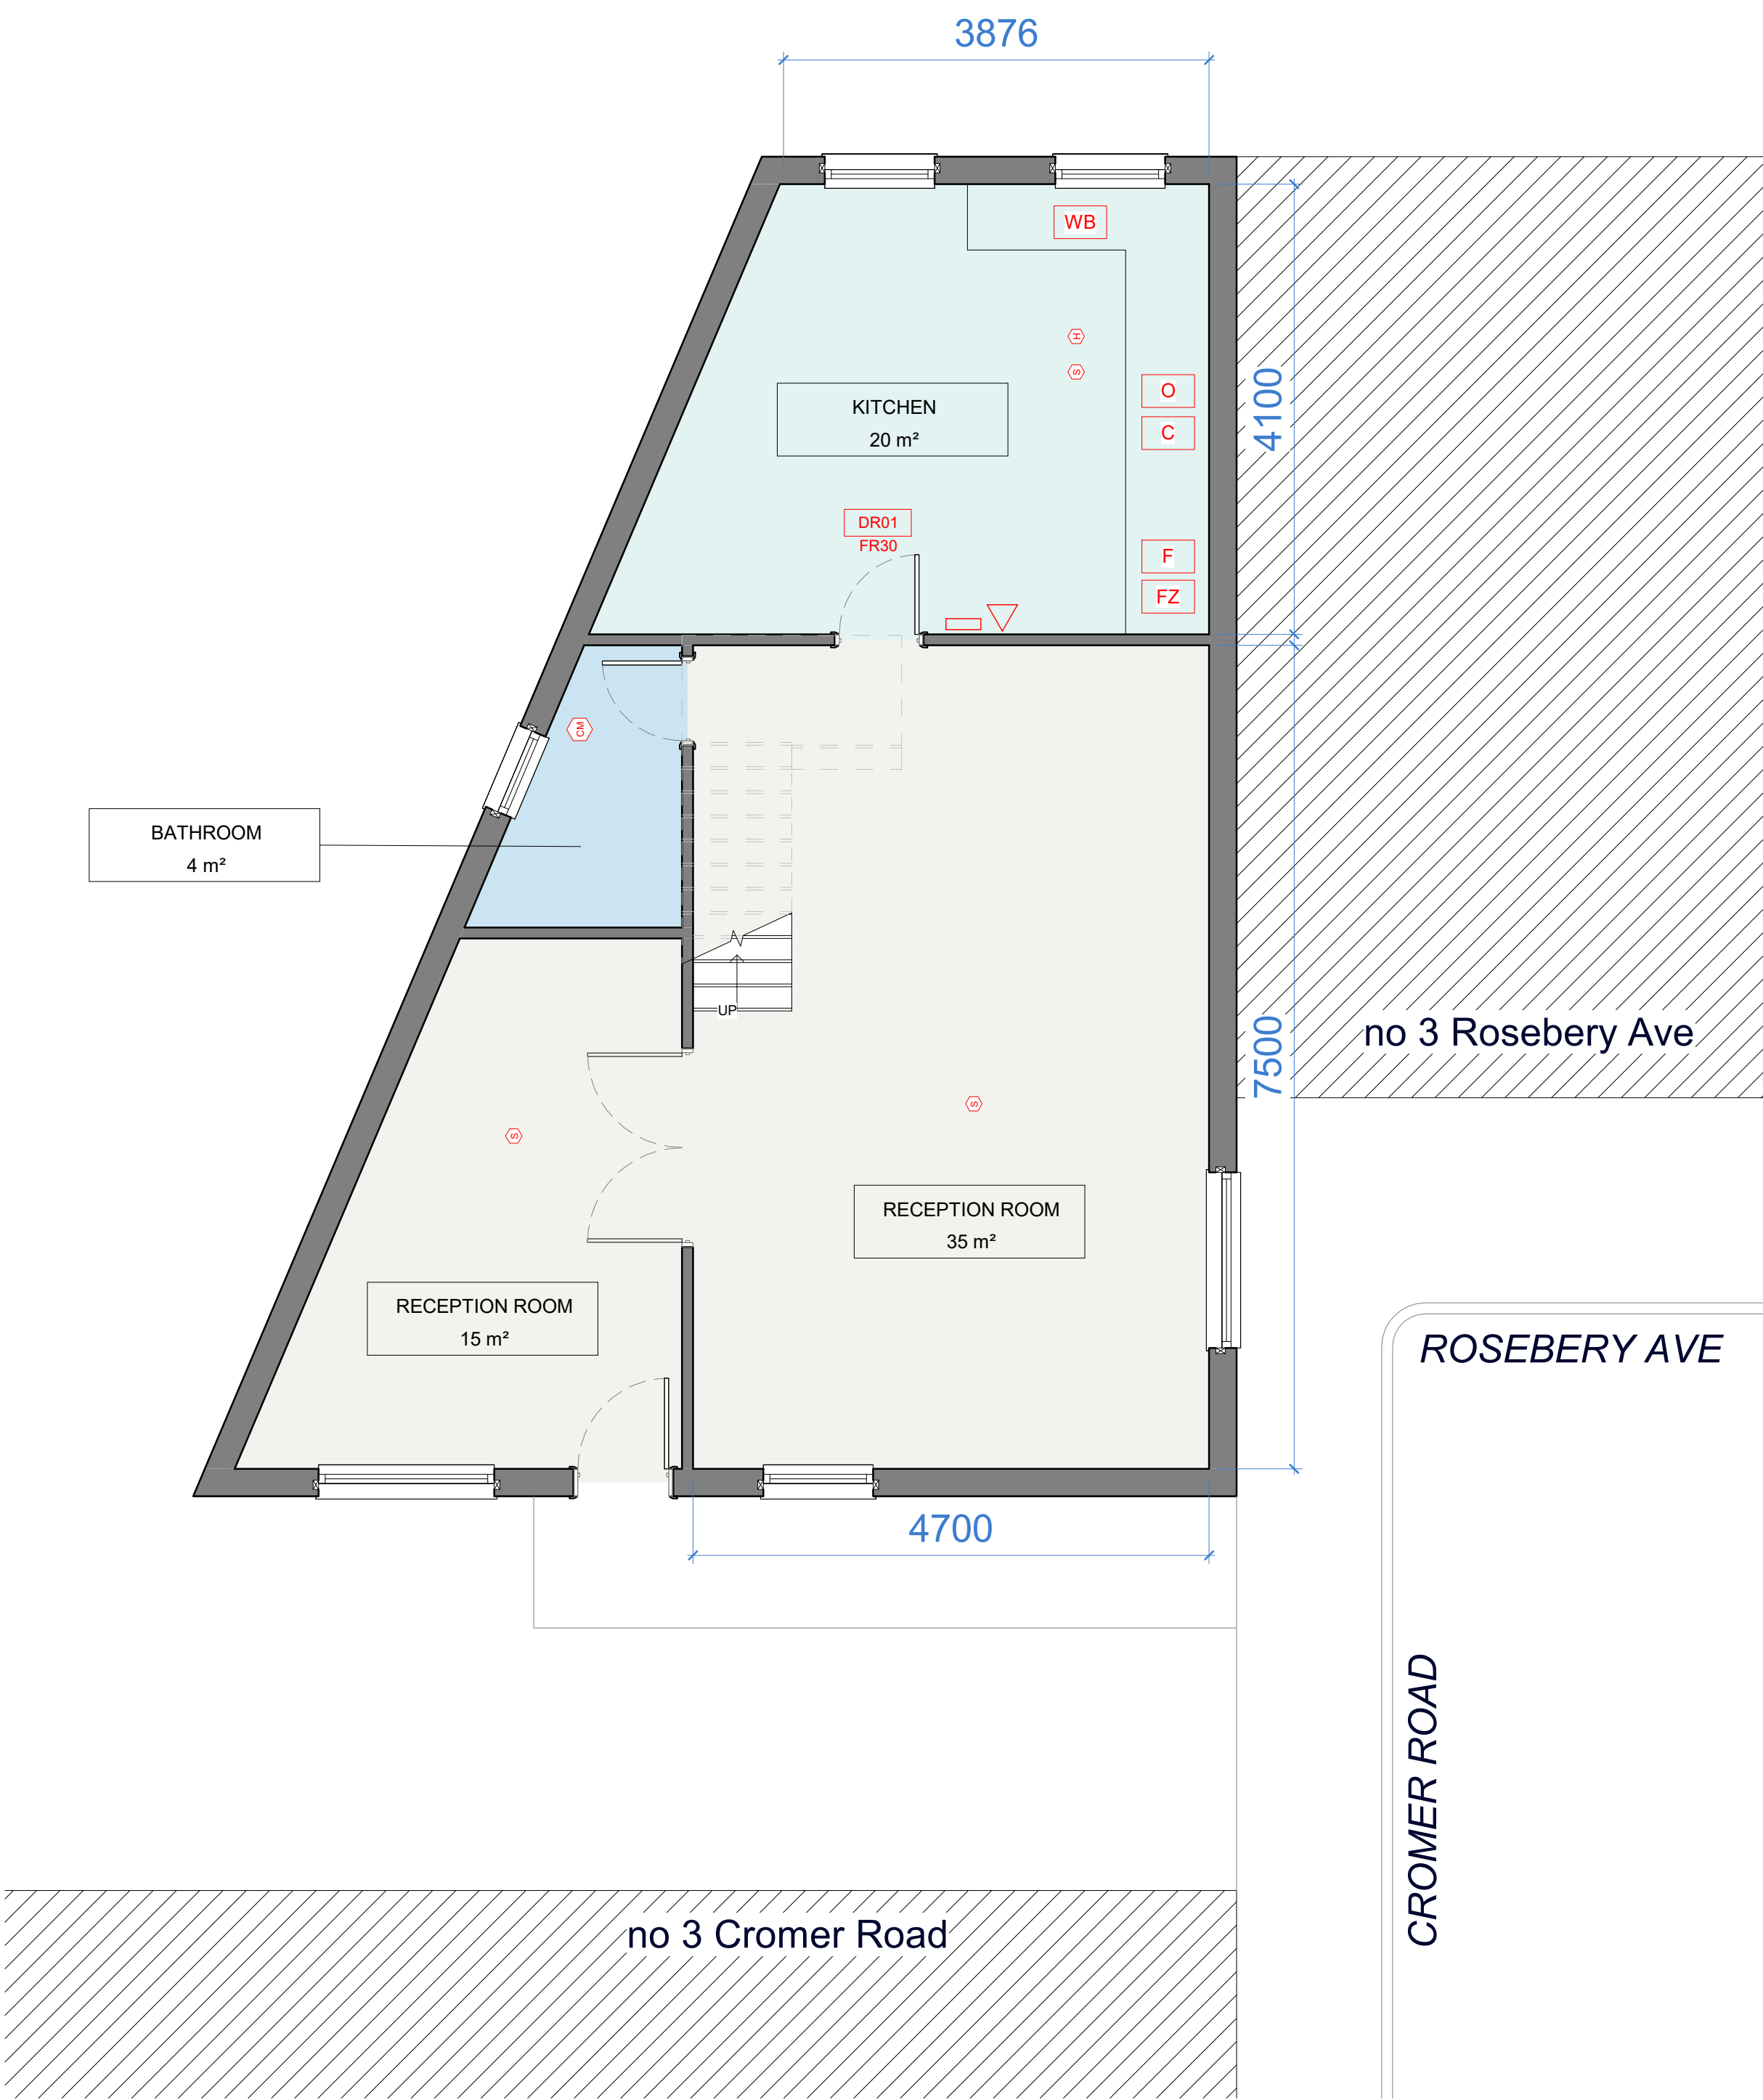

GROUND LEVEL 1:50@A1

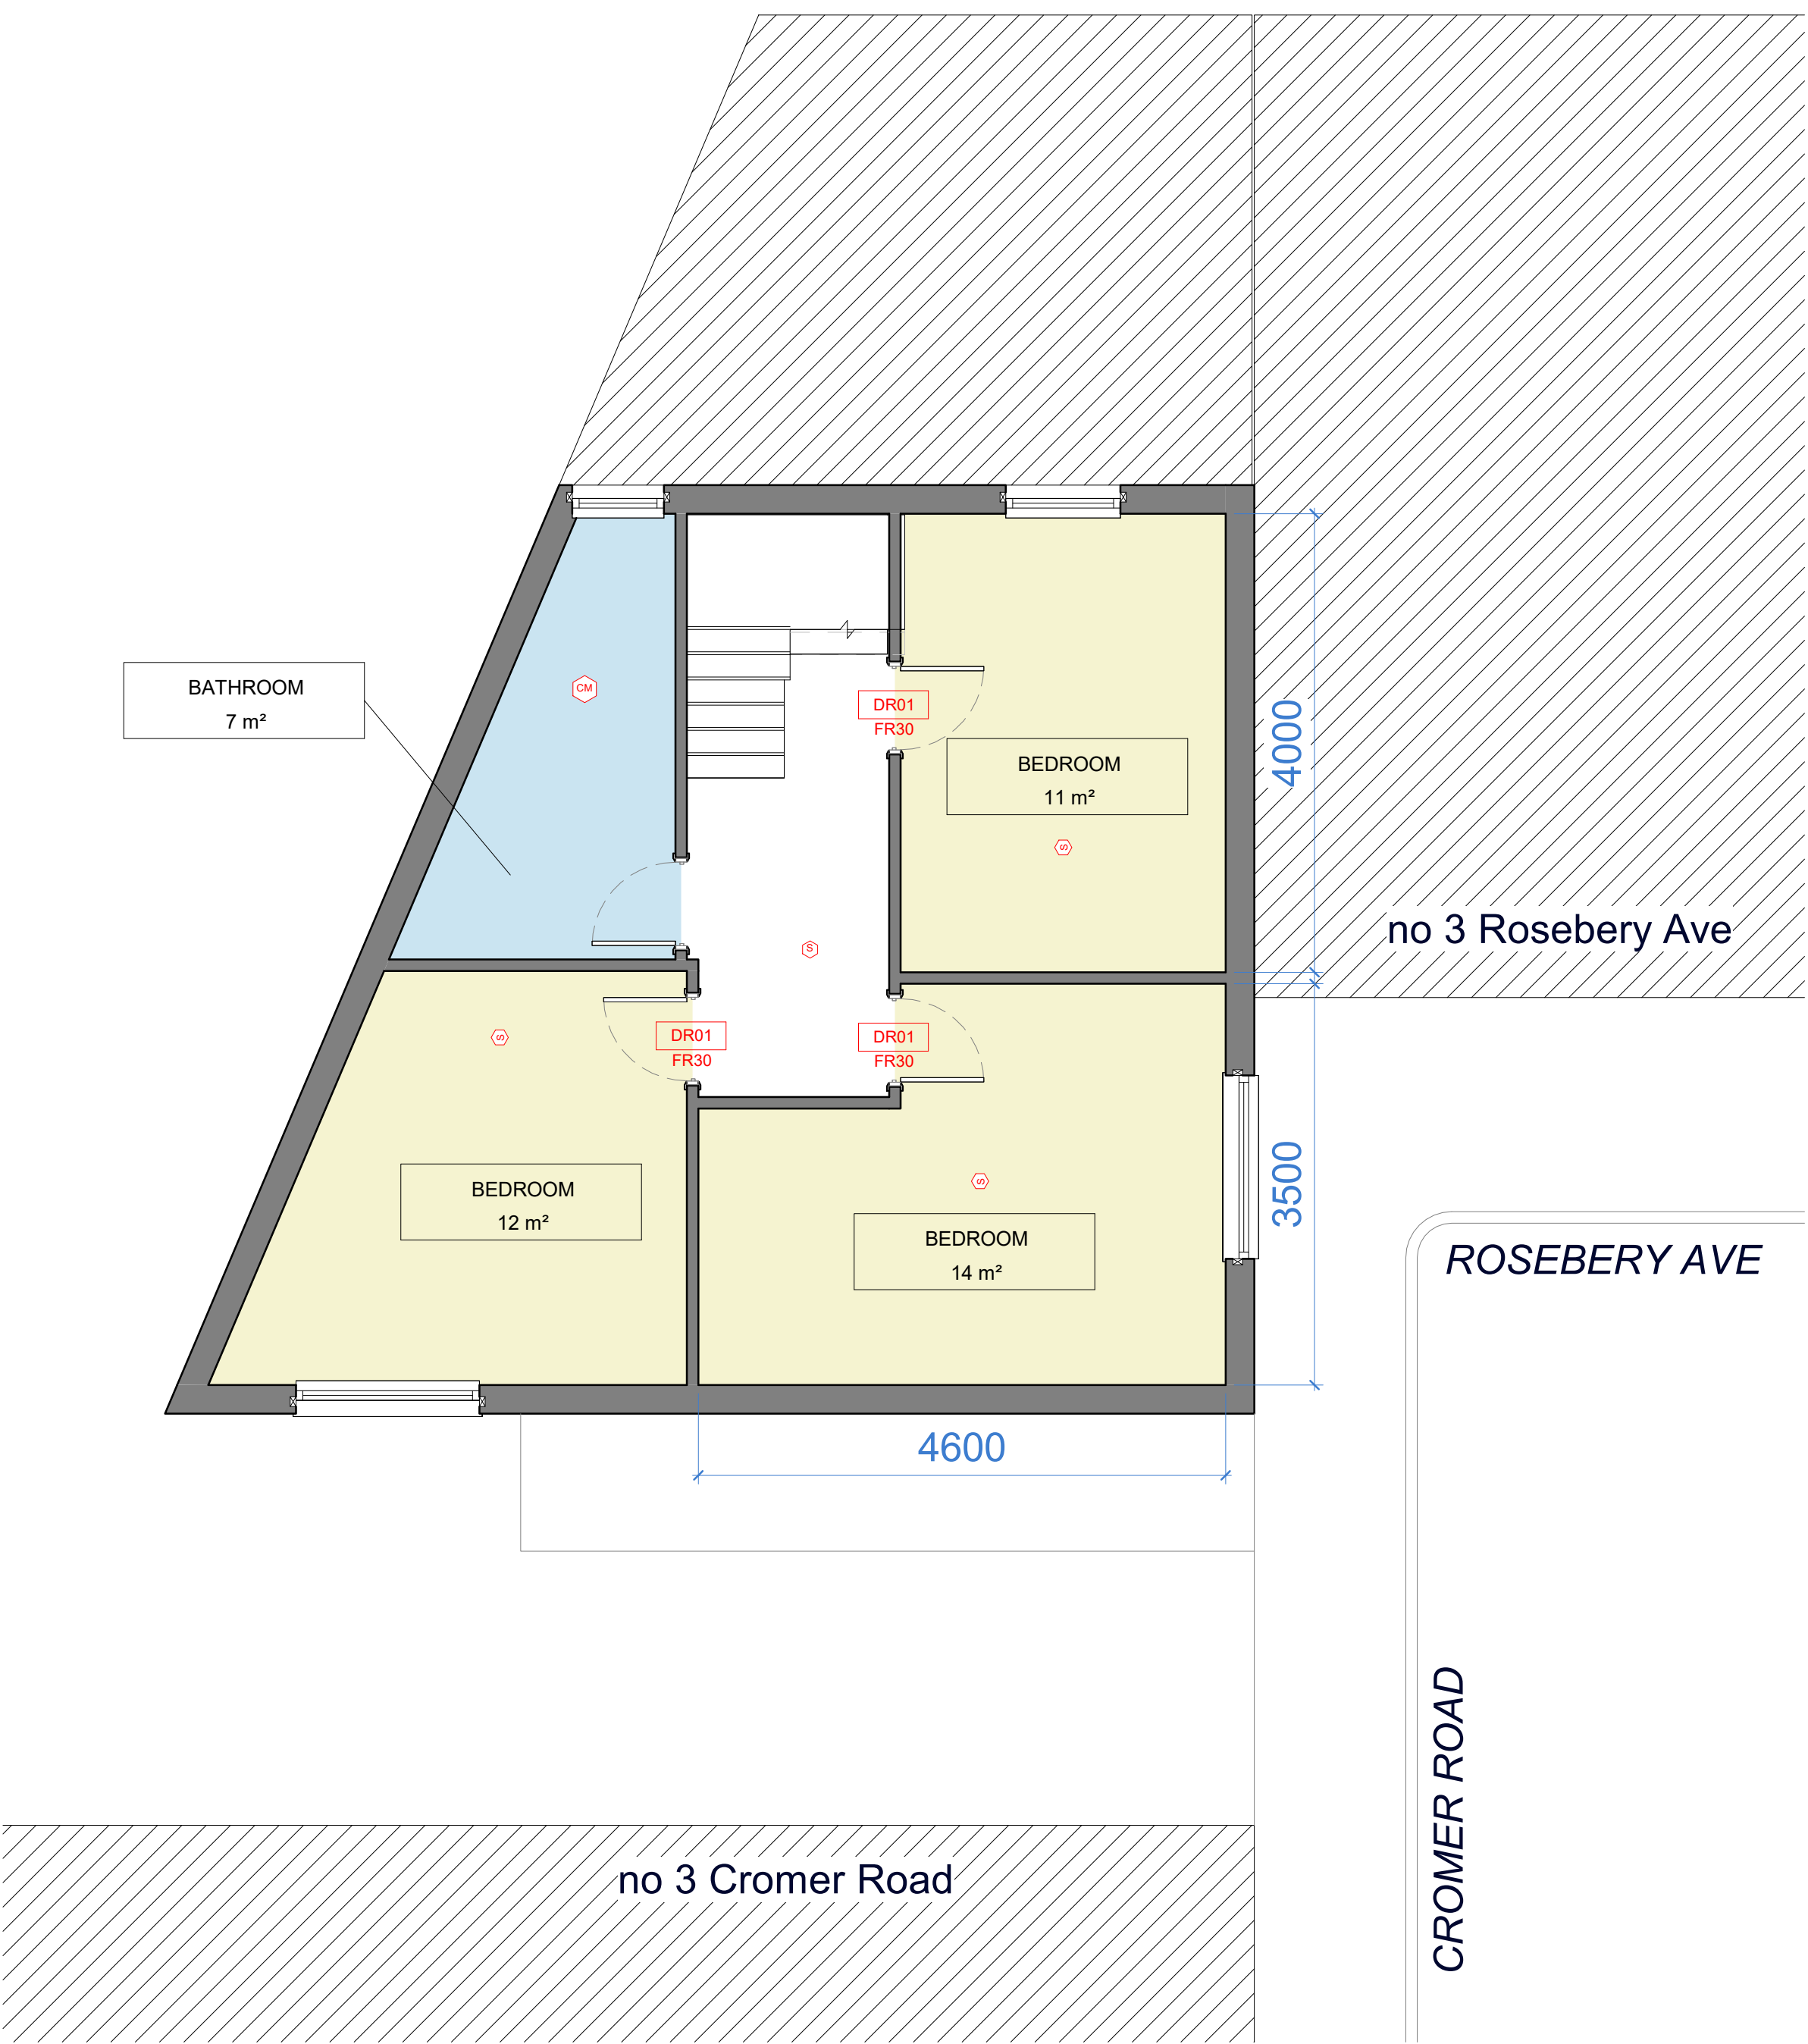

FIRST FLOOR LEVEL 1:50@A1

KEY

FIRE DETECTION	
	Heat Detector and Alarm (Mains Connected)
	Smoke Detector and Alarm (Mains Connected)
	Carbon Monoxide Detector
	Fire Door
	Fire Blanket
	Fire Extinguishers

GENERAL ITEMS	
	Washer & Dryer
	Wash Basin
	Fridge
	Freezer
	Oven
	Cooker


General Notes:

- Do Not Scale This Drawing
- All dimensions are in millimetres unless otherwise stated
- Drawing based on survey information by others
- Contractors are not to scale dimensions from this drawing
- Contractors are to check all dimensions prior to commencement on site and notify the architect of any errors, omissions, or discrepancies
- Drawings should always be printed out in COLOUR
- West Port Five LTD retain copyright of this drawing. It may not be copied, altered or reproduced in any way without their written authority.

Drawing Notes:

Basis of drawings taken from WR-R00-PR-102 provided by client

Rev	Date	Description
-----	------	-------------

 

Project:

1 Rosebery Avenue, N17 9RY

Stage:

Drawing Title:

PROPOSED FLOOR PLANS

Drawing Information:

Scale: **1 : 50 @ A1**

Drawn: **SOI WPA** Checked: **SOI WPA** Approved: **13/06/2024**

PROJECT NO.:	ORIGINATOR:	VOLUME/ZONE:	LEVEL/LOCATION:	TYPE:	ROLE:	NUMBER:	STAGE:	REVISION:
1RA	WPA	XX	XX	DR	A	04100	3	

WEST PORT