


EXISTING A/C EQUIPMENT

NEW A/C EQUIPMENT

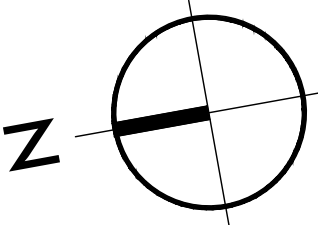

HIGHGATE


GENERAL NOTES

1. THIS DRAWING MUST NOT BE SCALED.
2. FOLLOWING COMMENCEMENT OF WORK ON SITE, ISSUED DRAWINGS AND DETAILS MAY BE SUBJECT TO CHANGE DUE TO SITE CONDITIONS OR CONTRACTOR DESIGN MODIFICATIONS.
3. ALL WORKS MUST BE CARRIED OUT TO THE SATISFACTION OF LOCAL AND STATUTORY AUTHORITIES, IN ACCORDANCE WITH CURRENT BUILDING REGULATIONS AND CODES OF PRACTICE.
4. ALL DIMENSIONS ARE TO BE VERIFIED WITH THE CONTRACTOR ON SITE PRIOR TO MANUFACTURE OR INSTALLATION.
5. QUADRANT DESIGN MUST BE INFORMED OF ANY AMENDMENTS TO THE DESIGN ON SITE.

MORE INFO


SCAN ME

SCAN THIS CODE TO ACCESS: QD WEBSITE

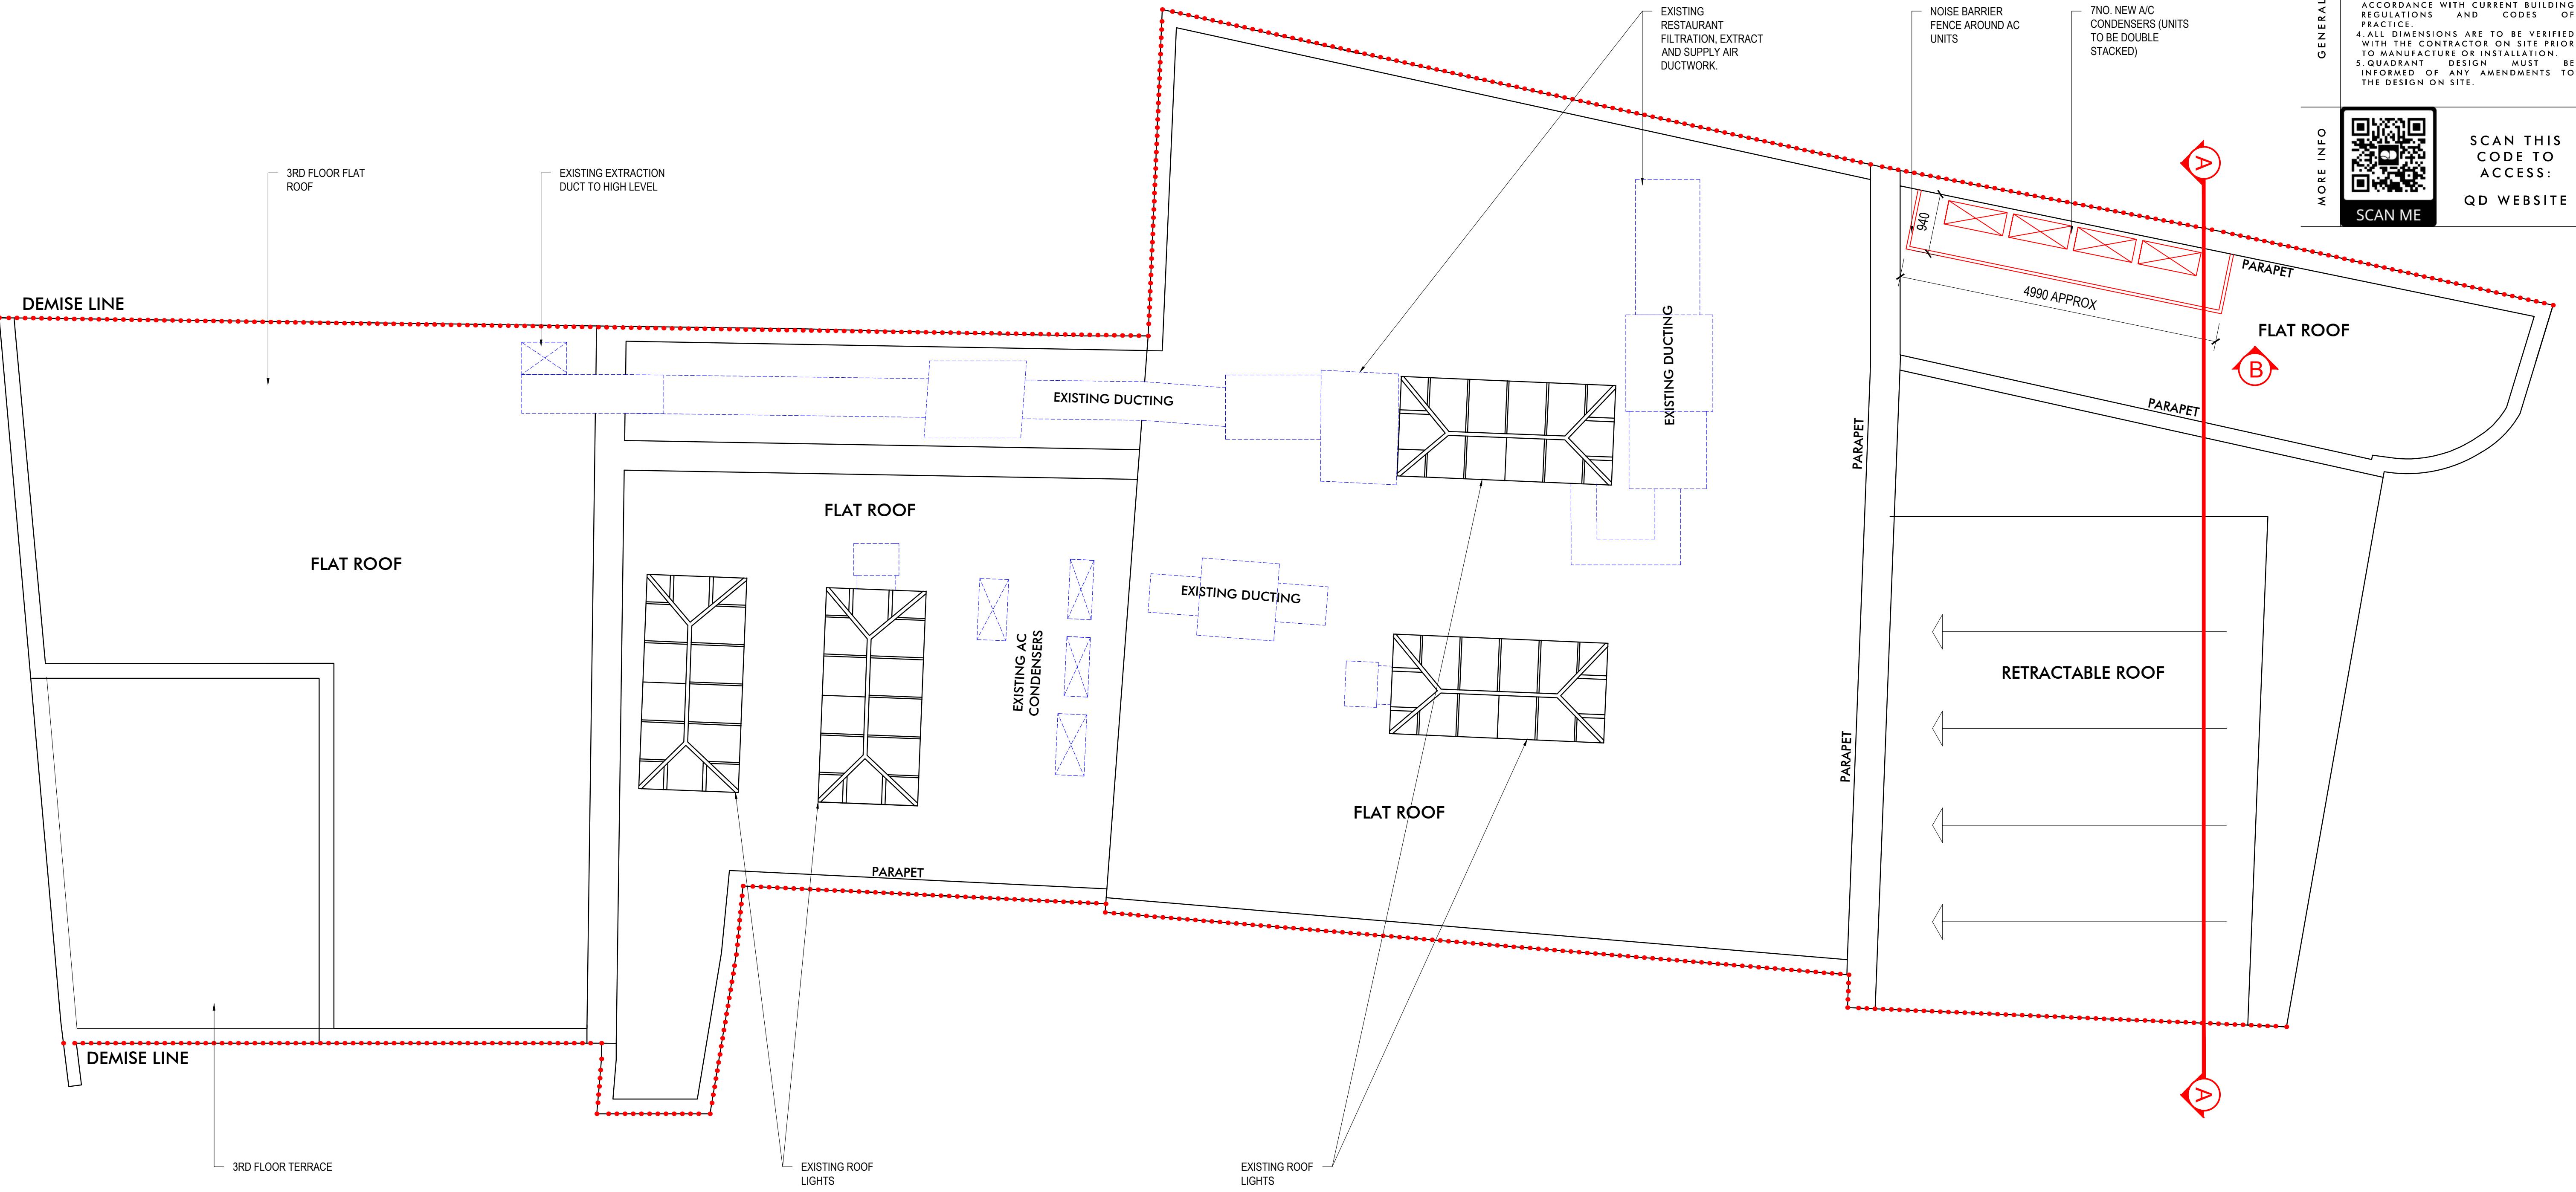

PROPOSED ROOF PLAN

SCALE 1:50

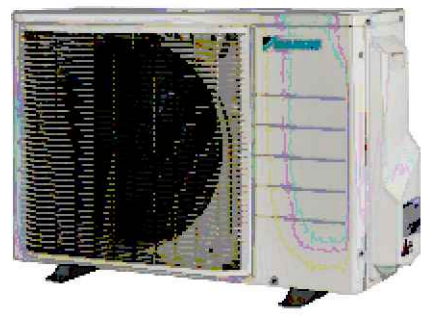

7NO. NEW A/C CONDENSERS
DAIKIN- FTXM20
H- 610MM X W-923MM X D-367MM



GOOGLE EARTH VIEW

WORK STAGE	TECHNICAL DESIGN		
CLIENT	2 HIGHGATE HIGH STREET LONDON N6 5JL		
PROJECT	2 HIGHGATE HIGH STREET LONDON N6 5JL		

SHEET TITLE	PROPOSED ROOF PLAN		
SCALE	AS SHOWN AT A1	DOWN BY	ND
SHEET NO.	J002736_A4_01	REVISION:	

QUADRANT DESIGN
23 KINGS ROAD,
READING,
RG1 3AR
73-74 BERWICK STREET,
LONDON,
W1F 8TE
(+44) 0118 9591 581
hello@quadrantdesign.co.uk
www.quadrantdesign.co.uk

INTERIORS | ARCHITECTURE | BRANDING