




NOTES:


DISTRIBUTION
WORKS NOT SIZED
TO SCALE.

LEGEND:


- ASHP FLOW & RETURN PIPEWORK
- EXHAUST DUCTWORK
- INTAKE DUCTWORK
- SUPPLY DUCTWORK
- EXTRACT DUCTWORK
- SOLAR PHOTO-VOLTAIC PANELS
- AIR SOURCE HEAT PUMP

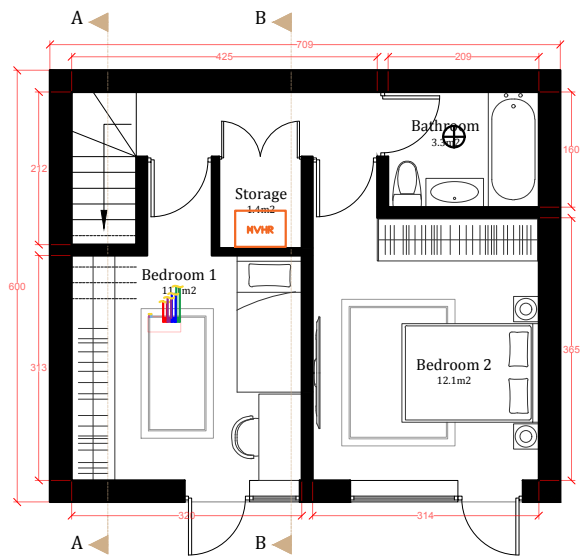


Proposed lower ground floor plan
Scale 1:100

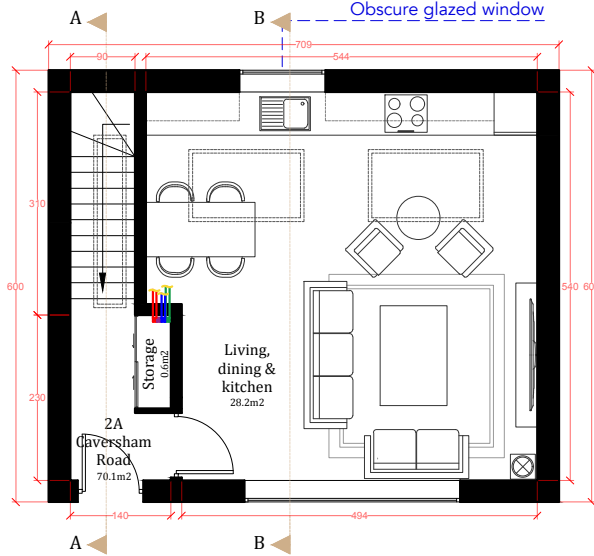


Proposed ground floor plan
Scale 1:100

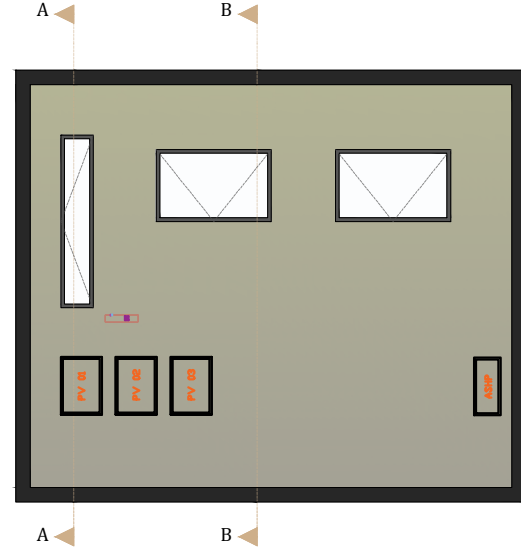


Proposed roof plan
Scale 1:100

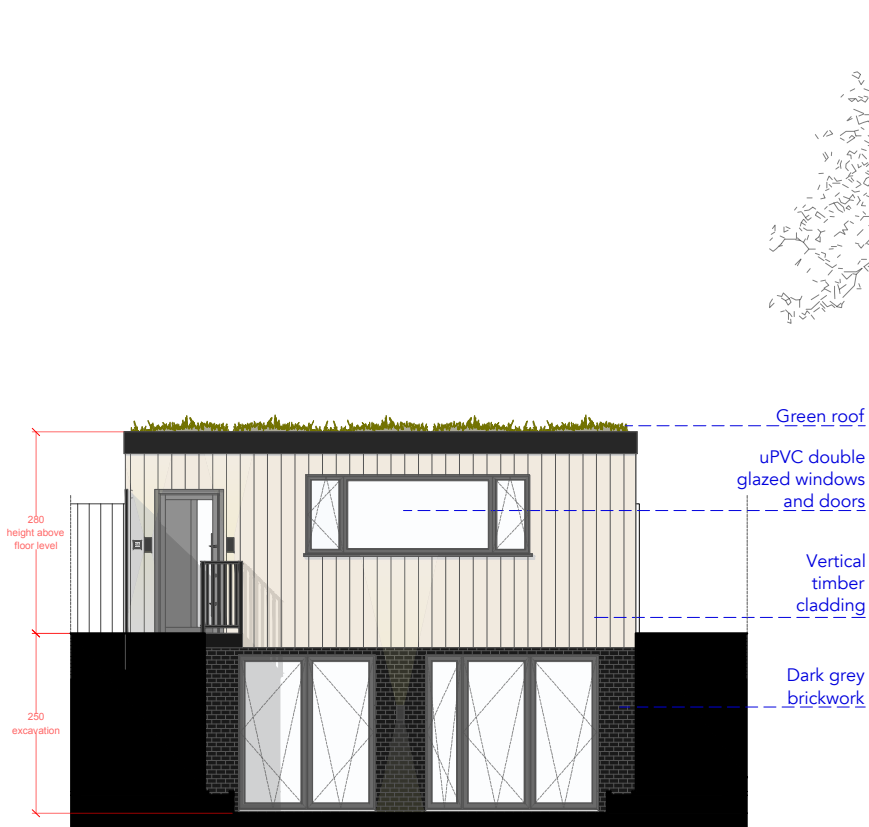


Proposed front elevation (West)
Scale 1:100

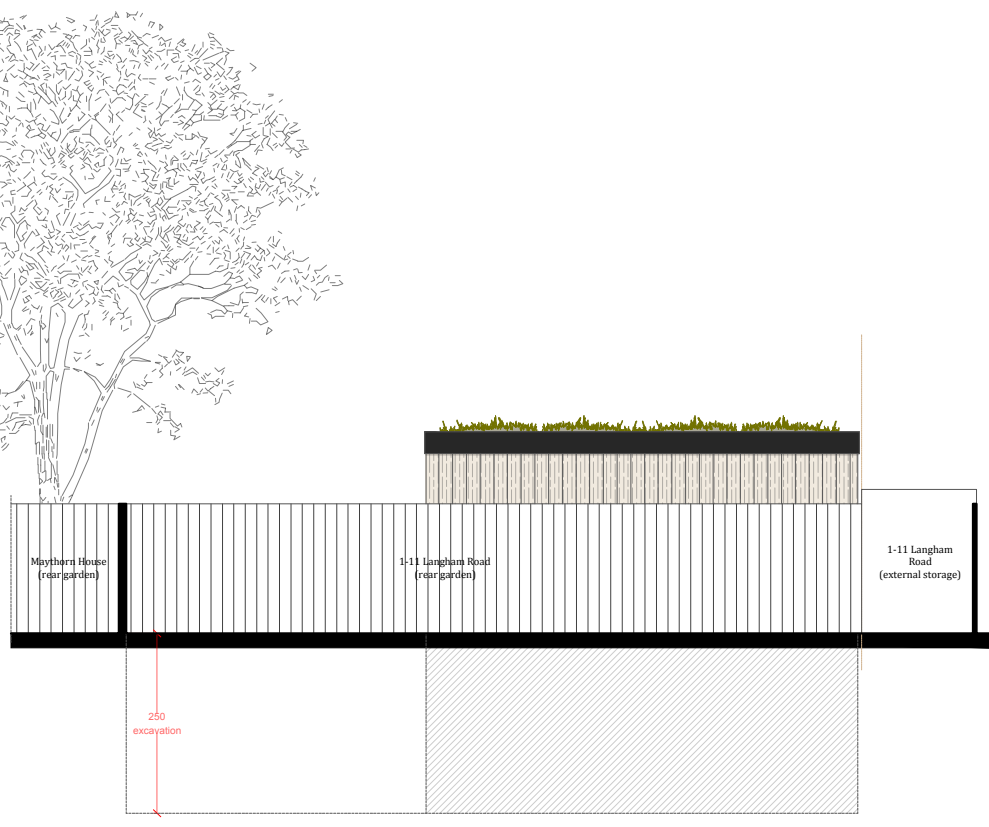


Proposed side elevation (South)
Scale 1:100

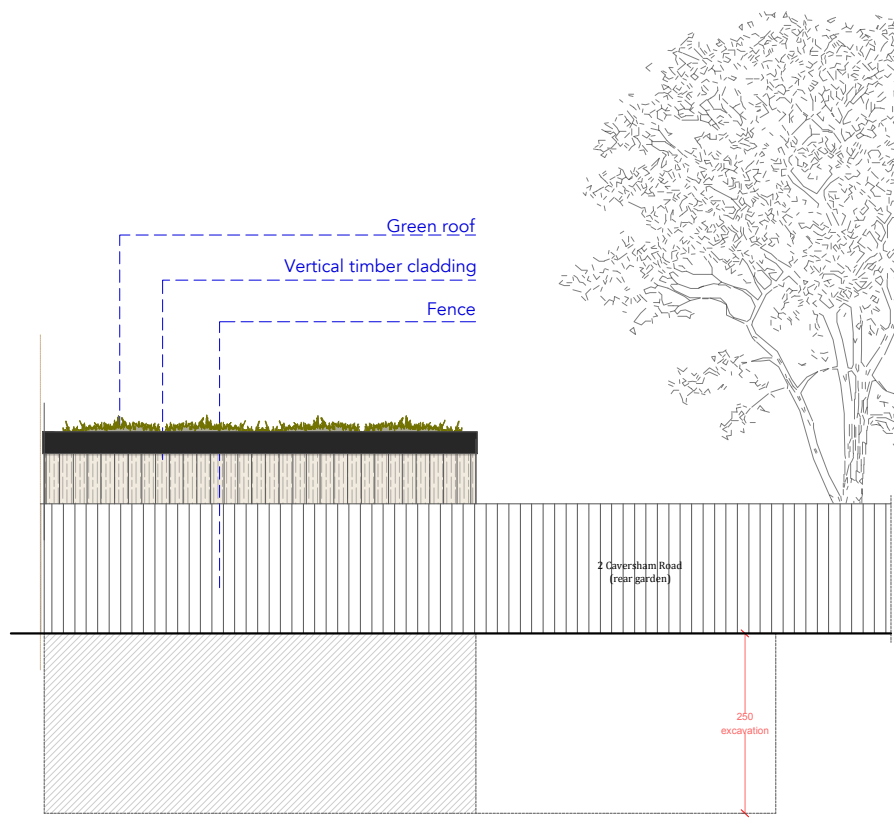


Proposed side elevation (North)
Scale 1:100

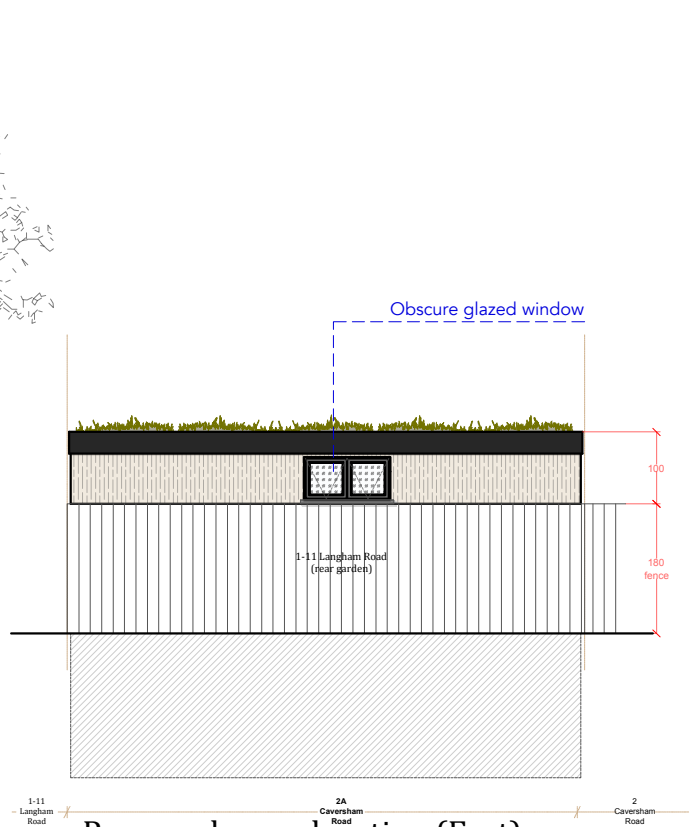

Proposed rear elevation (East)
Scale 1:100

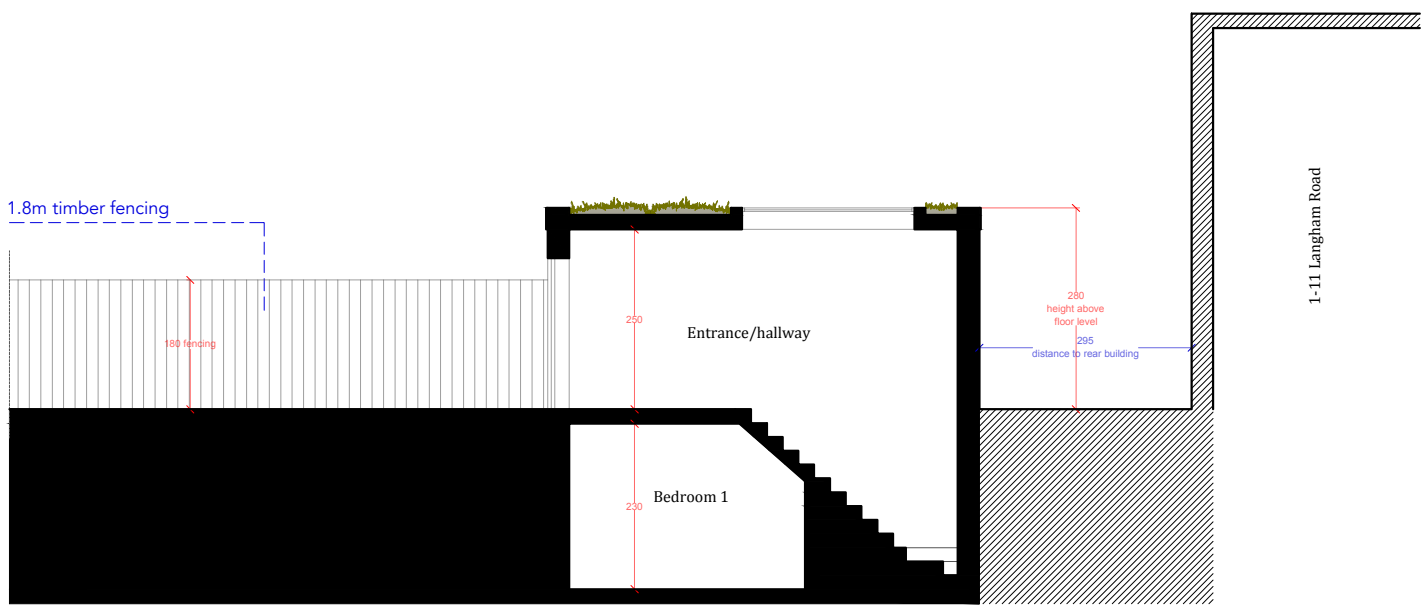

Proposed section A-A
Scale 1:100

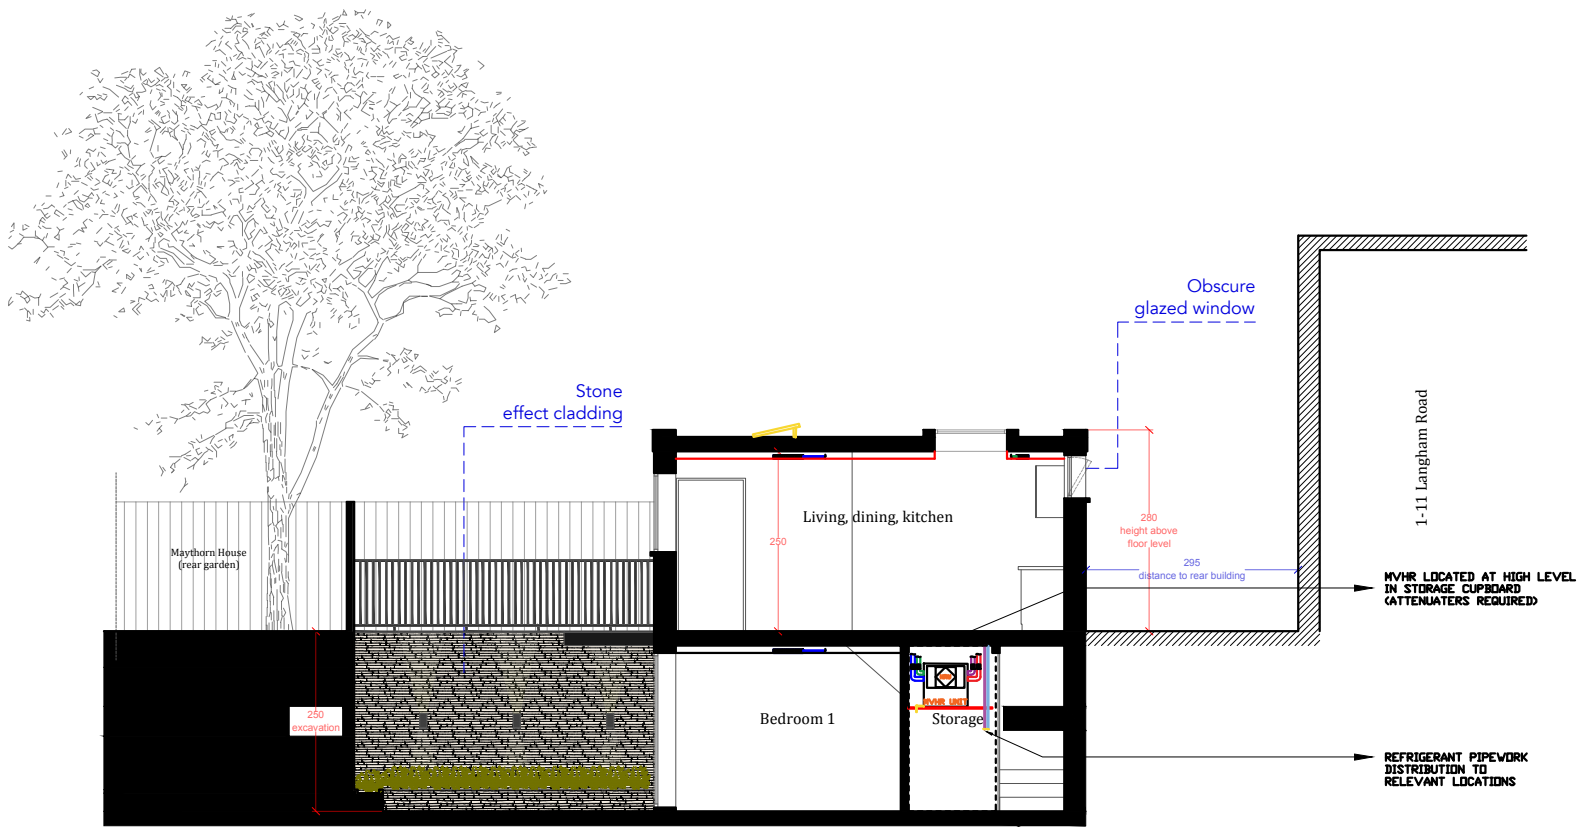

Proposed section B-B
Scale 1:100

29/05/26	SERVICES DRAWING	R01
Date	Description	Rev
Building		
(197A) 2 Caversham Road, London, N15 3QP		
Building Reference 2 CAVERSHAM RD	Floor	
Drawing Description		
PROPOSED PLAN SECTIONS & ELEVATIONS		
Status		
ISSUE 01		
Drawing Number REV-XX-YY-002-R01		
CAD Reference 197A_PL05C		
Scale 1:100 @ A3	Date 26-05-26	
Drawn By REV	Chc	
Drawing Type SPACE PLANNING		
Drawing Discipline MECHANICAL & ENERGY		
R. ELLUL VINCENTI, BEng, MSc email: RebeccaEllulVincenti@gmail.com tel: +44 (0) 7938145787		
Do not scale from the drawings. All discrepancies to be reported immediately. All dimensions to be verified. All rights reserved. All drawings herein constitute original and unpublished work of REV and may not be duplicated, used or disclosed without consent.		