

A1 LANDSCAPE

LIGHTING NOTES:

- DRAWING TO BE READ IN CONJUNCTION WITH CLIENTS ER's & CONTRACT DOCUMENTS
- SETTING OUT TO BE CO-ORDINATED ON SITE WITH STUD POSITIONS
- WHERE OUTLETS ARE ADJACENT ALLOW FOR A 40mm GAP BETWEEN
- ALL EQUIPMENT TO BE INSTALLED IN LINE WITH MANUFACTURERS RECOMMENDATIONS
- ALL FINAL SUB CIRCUITS, LIGHTING AND POWER FOR THE CORRIDORS AND STAIRWAYS APART FROM THE FIRE ALARM SYSTEM SHALL BE WIRED IN TWIN & EARTH C/JLE. GENERALLY POWER CIRCUITS TO BE 2.5mm² AND LIGHTING CIRCUITS TO BE 1.5mm²
- PIR'S IN CORRIDORS TO BE LINKED TOGETHER TO PROVIDE COVERAGE OF FULL AREA
- DRAWING TO BE READ IN CONJUNCTION WITH LUMINAIRE SCHEDULE

LINETYPES:

- CIRCUIT LINE (SWITCHED TOGETHER)
- CIRCUIT LINE (SWITCHED SEPERATELY)

A SURFACE MOUNTED LINEAR LED

B SURFACE MOUNTED LINEAR LED

C SURFACE MOUNTED LINEAR LED

D WALL MOUNTED LED BULKHEAD (SURFACE MOUNTED INDICATED ON DRAWINGS SUBJECT TO SIGN-OFF).

HE EXTERNAL IP65 SURFACE MOUNTED BULKHEAD LIGHT FITTING (ALSO WALL MOUNTED WHERE INDICATED ON DRAWINGS)

F SMALL LED PENCIL DOWNLIGHT

GE SURFACE MOUNTED IP65 RATED EMERGENCY BULKHEAD

P PRESENCE INFRARED DETECTOR

AD ABSENCE DETECTOR

PC PHOTO ELECTRIC CELL (DUSK TO DAWN SENSOR) FOR AUTOMATIC EXTERNAL LIGHTING C/W TIMECLOCK OVERRIDE


G 1 WAY LIGHT SWITCH (G = NO. OF GANGS)

T/A TO ABOVE


T/B TO BELOW

E - DENOTES 3-HOUR INTEGRAL EMERGENCY BACK-UP POWER SUPPLY FOR EMERGENCY FITTINGS


PROPOSED RISER CONFIRMATION (ARCHITECT TO CONFIRM ACCEPTANCE)

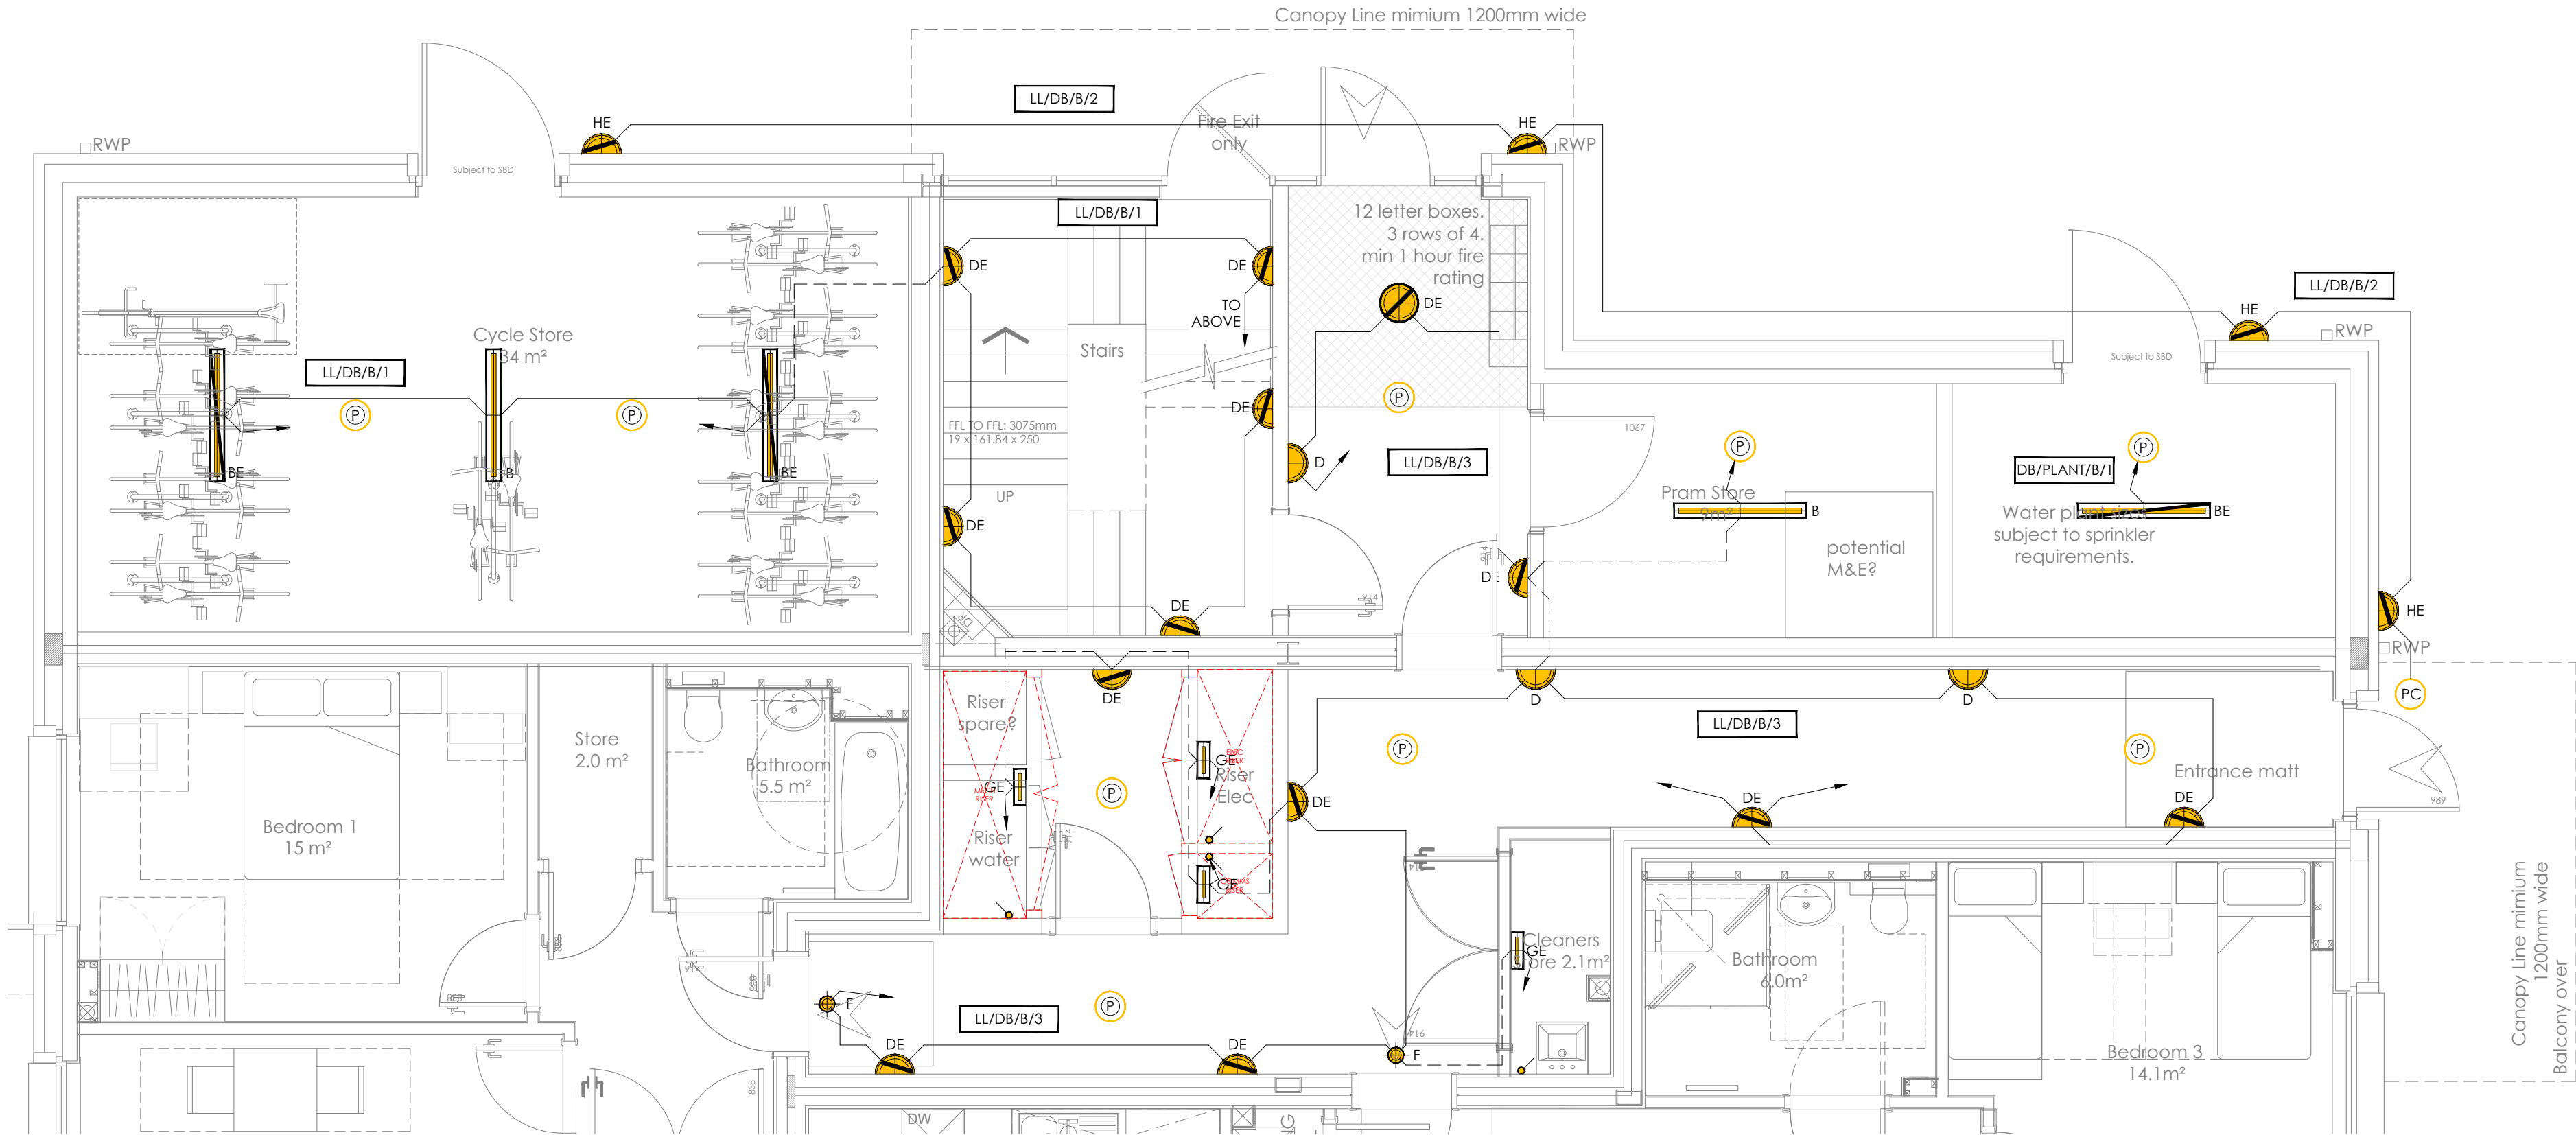


GROUND FLOOR

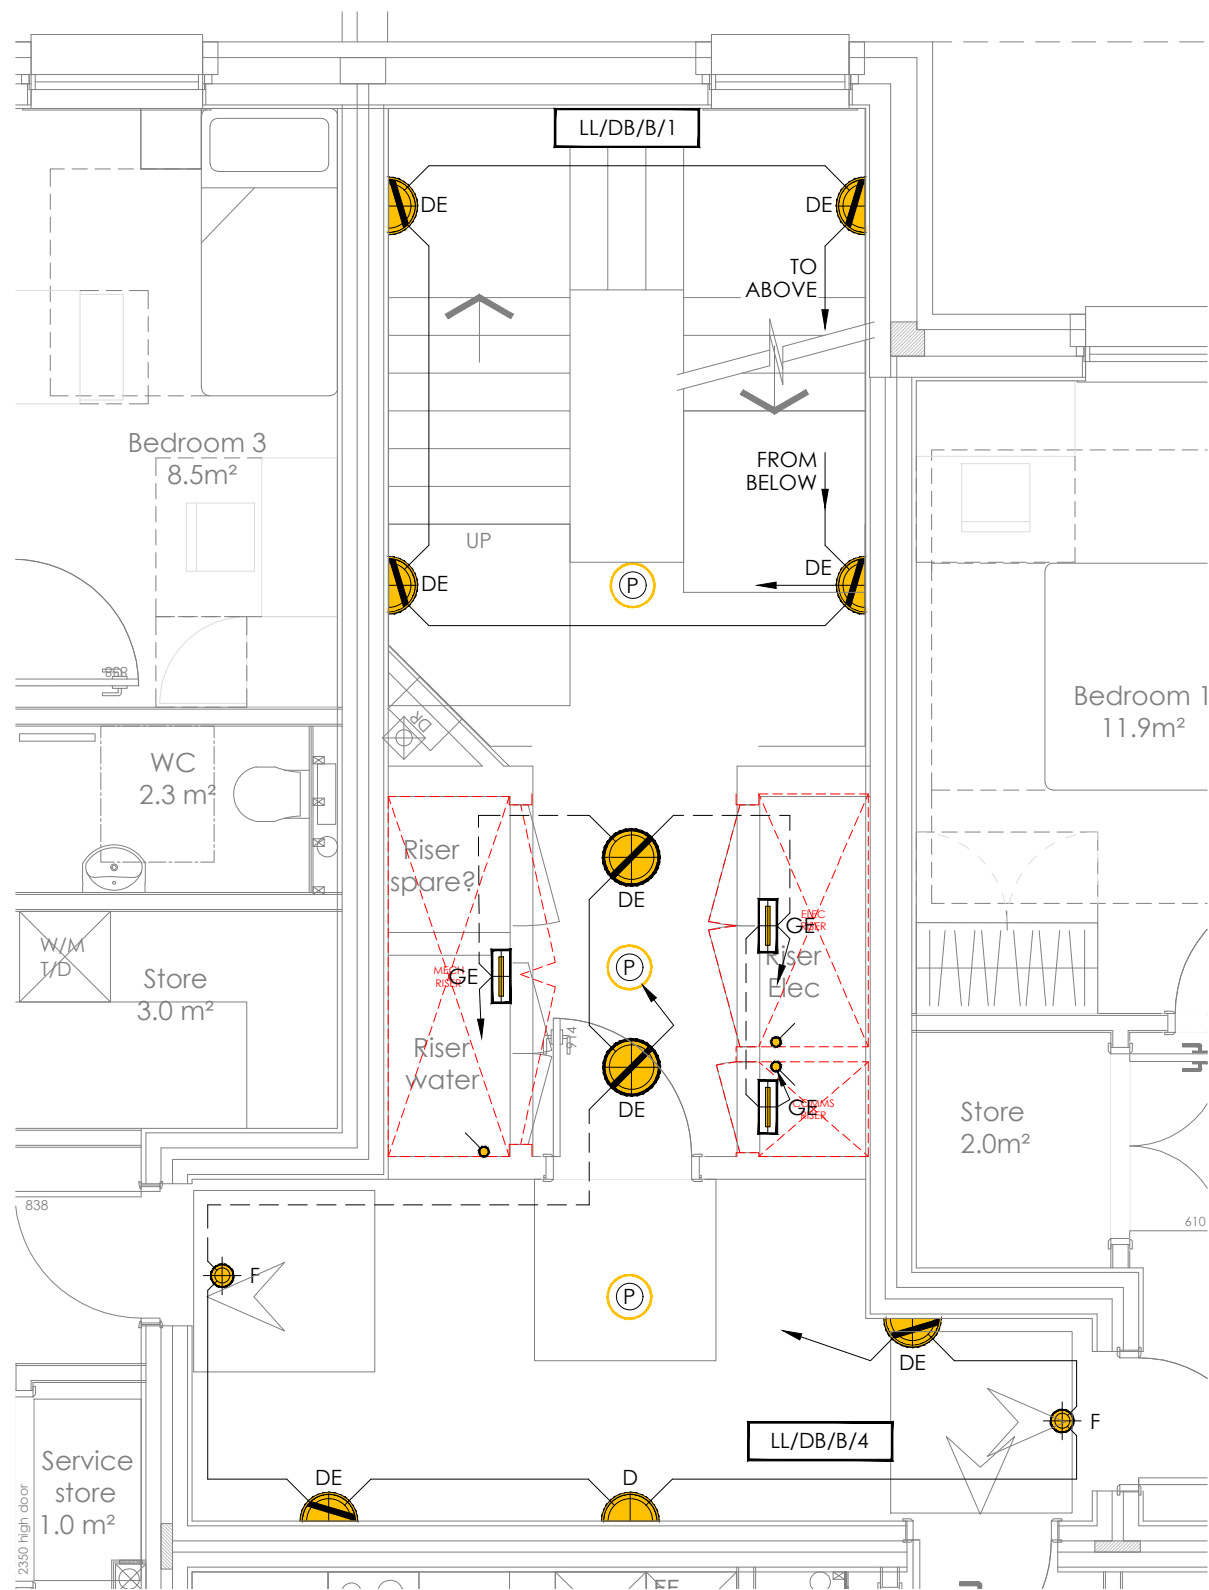

FIRST FLOOR

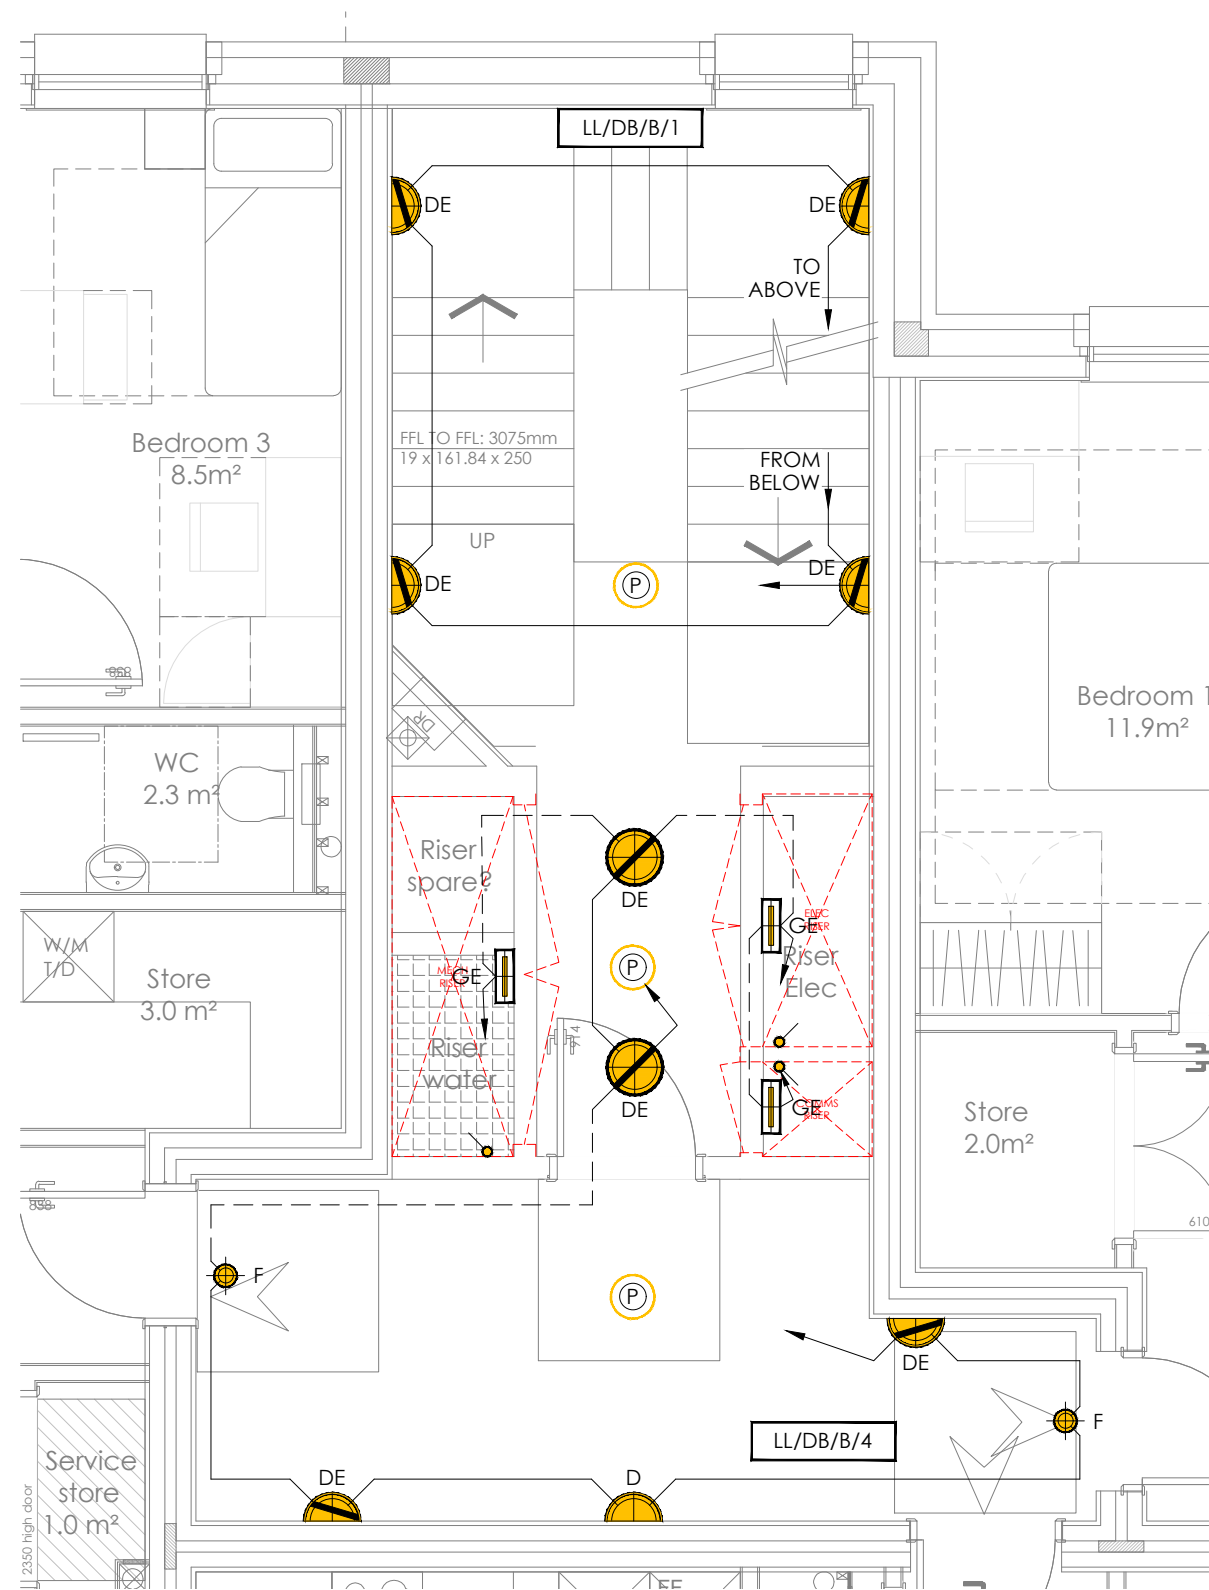

SECOND FLOOR

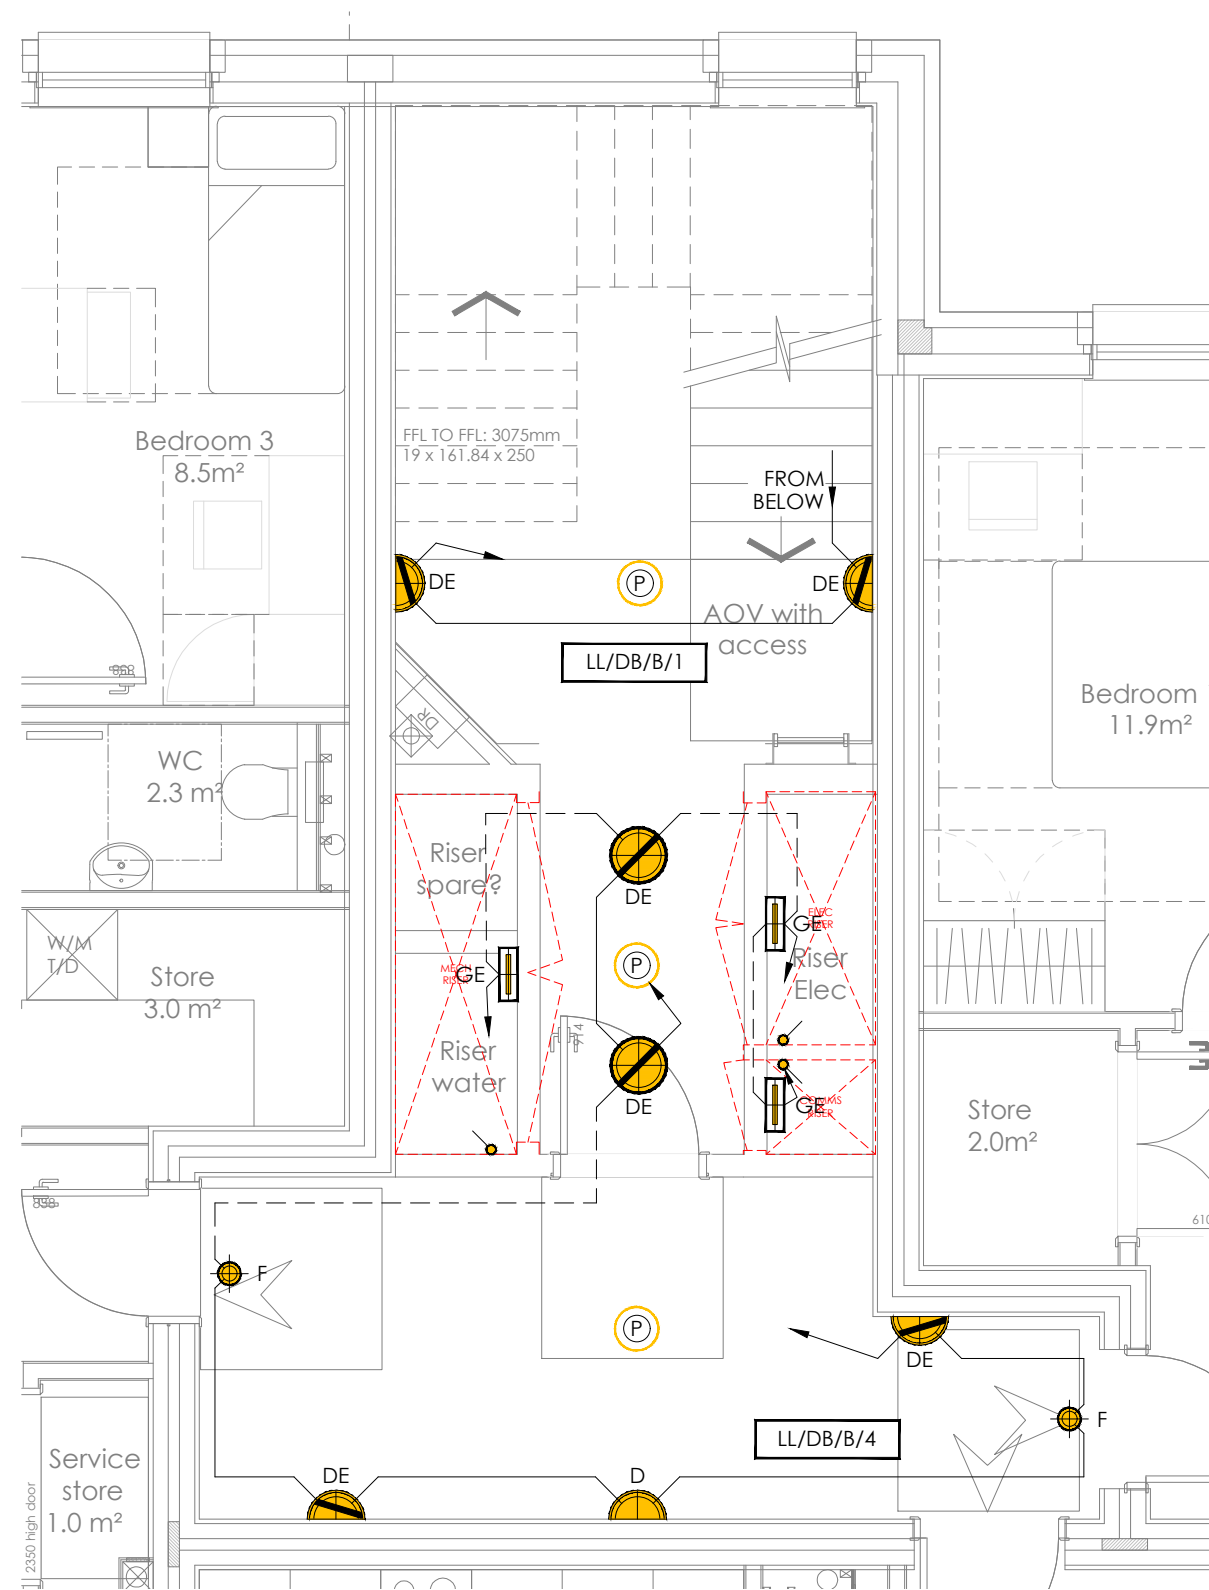

THIRD FLOOR

GENERAL NOTES

- DO NOT SCALE FROM THIS DRAWING. USE ONLY DIMENSIONED FIGURES.
- DIMENSIONS TO BE SITE CHECKED BY THE CONTRACTOR WORKING ONLY FROM GRID AND FIGURED DIMENSIONS AND CROSS-CHECKED WITH ALL OTHER RELEVANT DRAWINGS.
- THIS DRAWING IS TO BE READ IN CONJUNCTION WITH ALL RELEVANT ARCHITECTS, STRUCTURAL ENGINEERS AND KENCH CONSULTANTS LTD DRAWINGS AND SPECIFICATION.
- ANY DISCREPANCIES TO BE REPORTED TO THE CONSULTANT PRIOR TO CONSTRUCTION.
- THE TITLE, COPYRIGHT AND INFORMATION IN THIS DOCUMENT IS THE PROPERTY OF KENCH CONSULTANTS LTD.

P05	05/02/25	APPROVAL ISSUE	JJ	CS	CD
P04	12/08/24	APPROVAL ISSUE	JJ	SH	CD
P03	19/07/24	APPROVAL ISSUE	JJ	SH	CD
P02	30/04/24	PRELIMINARY ISSUE	JJ	JJ	CD
P01	27/02/24	PRELIMINARY ISSUE	JJ	JJ	CD
Rev.	Date:	Description:	Eng:	Drn:	Apr:



ADDRESS:
Unit 7, Sherwood House,
Walderslade Road,
Chatham, Kent, ME5
9UD

TELEPHONE: 0208 057 6552
WEBSITE:
www.kenchconsultants.com
E-MAIL:
info@kenchconsultants.com



Client:
Project:
BRUNEL WALK

Drawing Title:
BLOCK B - ALL FLOORS
COMMUNAL AREAS
LIGHTING LAYOUT

Scale:	Date:	Checked:	Suitability:
1:50@A1	FEB '24	CD	S3

Drawing Status:
STAGE 4 - APPROVAL

Drawing Number:
0053-KCL-BB-ZZ-DR-E-2502

