

LIGHTING NOTES:

- * DRAWING TO BE READ IN CONJUNCTION WITH CLIENTS ER'S & CONTRACT DOCUMENTS
- * SETTING OUT TO BE CO-ORDINATED ON SITE WITH STUD POSITIONS
- * WHERE OUTLETS ARE ADJACENT ALLOW FOR A 40mm GAP BETWEEN
- * ALL EQUIPMENT TO BE INSTALLED IN LINE WITH MANUFACTURERS RECOMMENDATIONS
- * ALL FINAL SUB CIRCUITS, LIGHTING AND POWER FOR THE CORRIDORS AND STAIRWAYS APART FROM THE FIRE ALARM SYSTEM SHALL BE WIRED IN TWIN & EARTH C/J.L.E. GENERALLY POWER CIRCUITS TO BE 2.5mm² AND LIGHTING CIRCUITS TO BE 1.5mm²
- * PIR'S IN CORRIDORS TO BE LINKED TOGETHER TO PROVIDE COVERAGE OF FULL AREA
- * DRAWING TO BE READ IN CONJUNCTION WITH LUMINAIRE SCHEDULE

LINETYPES:

- _____ CIRCUIT LINE (SWITCHED TOGETHER)
 _____ CIRCUIT LINE (SWITCHED SEPERATELY)

A  SURFACE MOUNTED LINEAR LED

 SURFACE MOUNTED LINEAR LED SURFACE MOUNTED LINEAR LED

 D D

WALL MOUNTED LED BULKHEAD
(SURFACE MOUNTED INDICATED ON
DRAWINGS SUBJECT TO SIGN-OFF).

EXTERNAL IP65 SURFACE MOUNTED
BULKHEAD LIGHT FITTING (ALSO WALL
MOUNTED WHERE INDICATED ON
DRAWINGS)

F  SMALL LED PENCIL DOWNLIGHT

GE SURFACE MOUNTED IP65 RATED
EMERGENCY BULKHEAD

 PRESENCE INFRARED DETECTOR

AD ABSENCE DETECTOR



PC PHOTO ELECTRIC CELL (DUSK TO DAWN SENSOR) FOR AUTOMATIC EXTERNAL LIGHTING C/W TIMECLOCK OVERRIDE

 1 WAY LIGHT SWITCH
(G = NO. OF GANGS)


T/A TO ABOVE

- E - DENOTES 3-HOUR INTEGRAL EMERGENCY BACK-UP POWER SUPPLY FOR EMERGENCY FITTINGS


PROPOSED RISER CONFIRMATION
(ARCHITECT TO CONFIRM ACCEPTANCE)

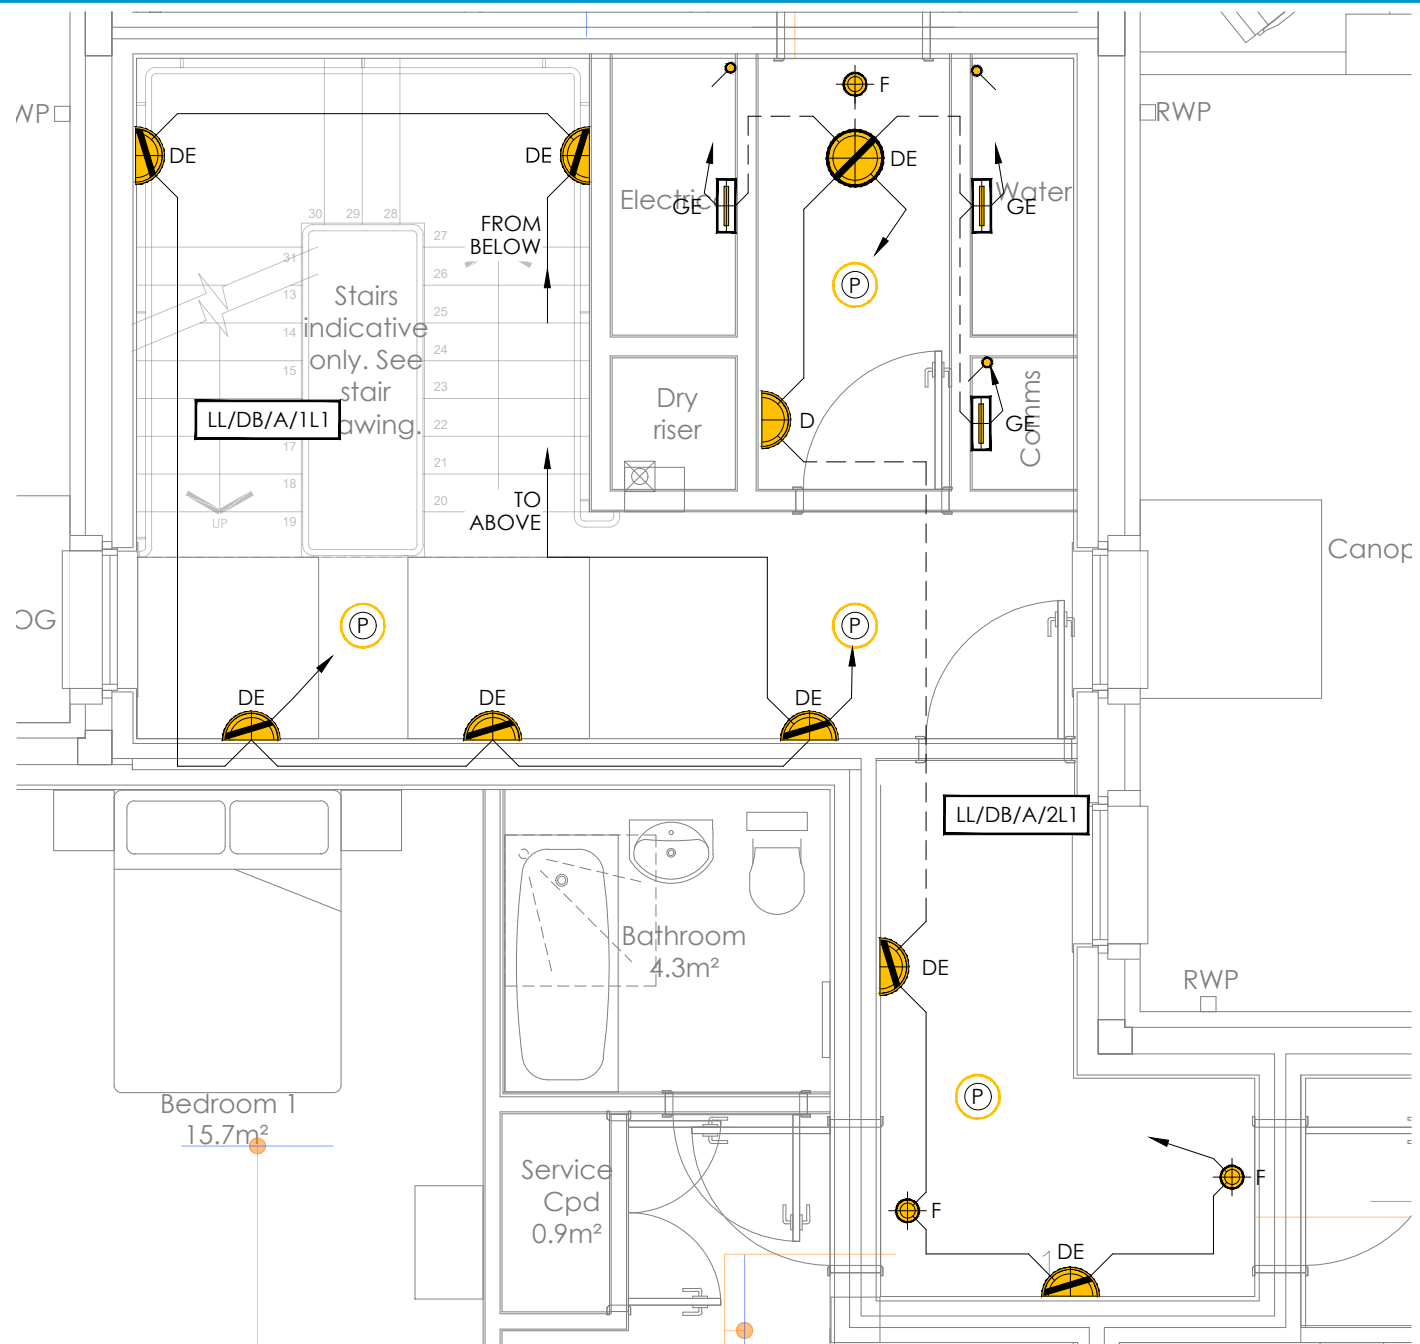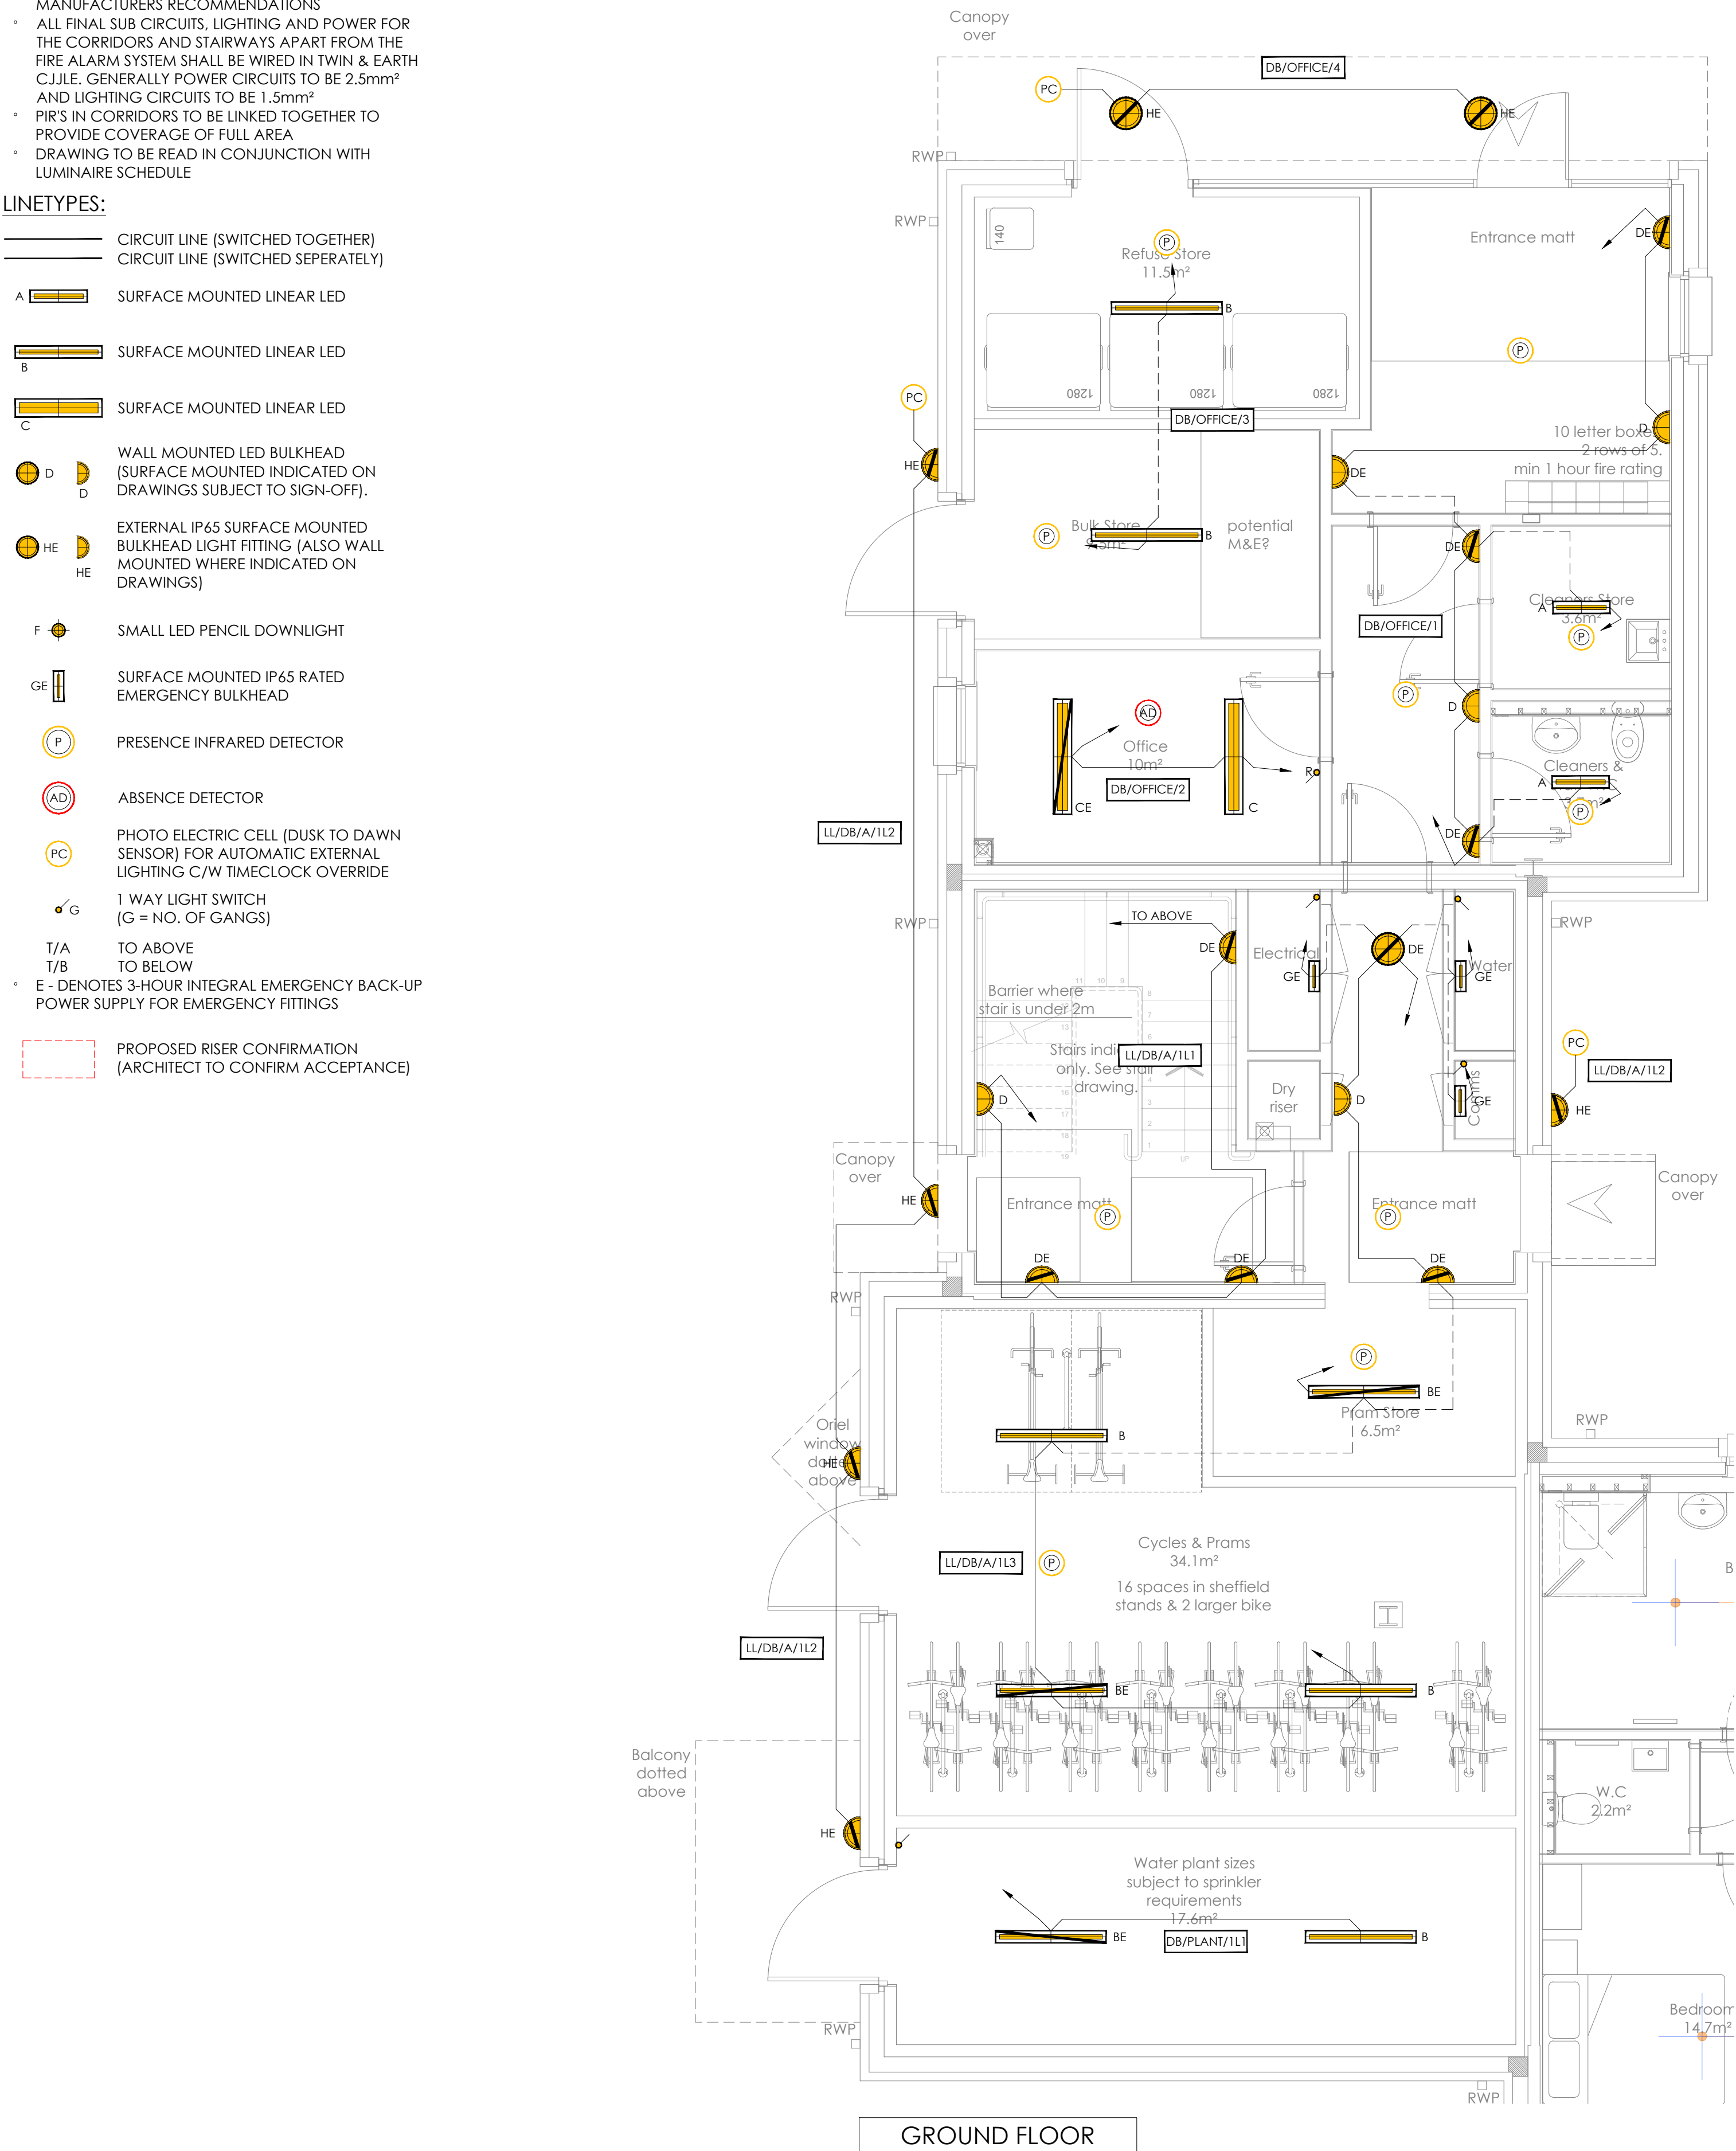

FIRST FLOOR

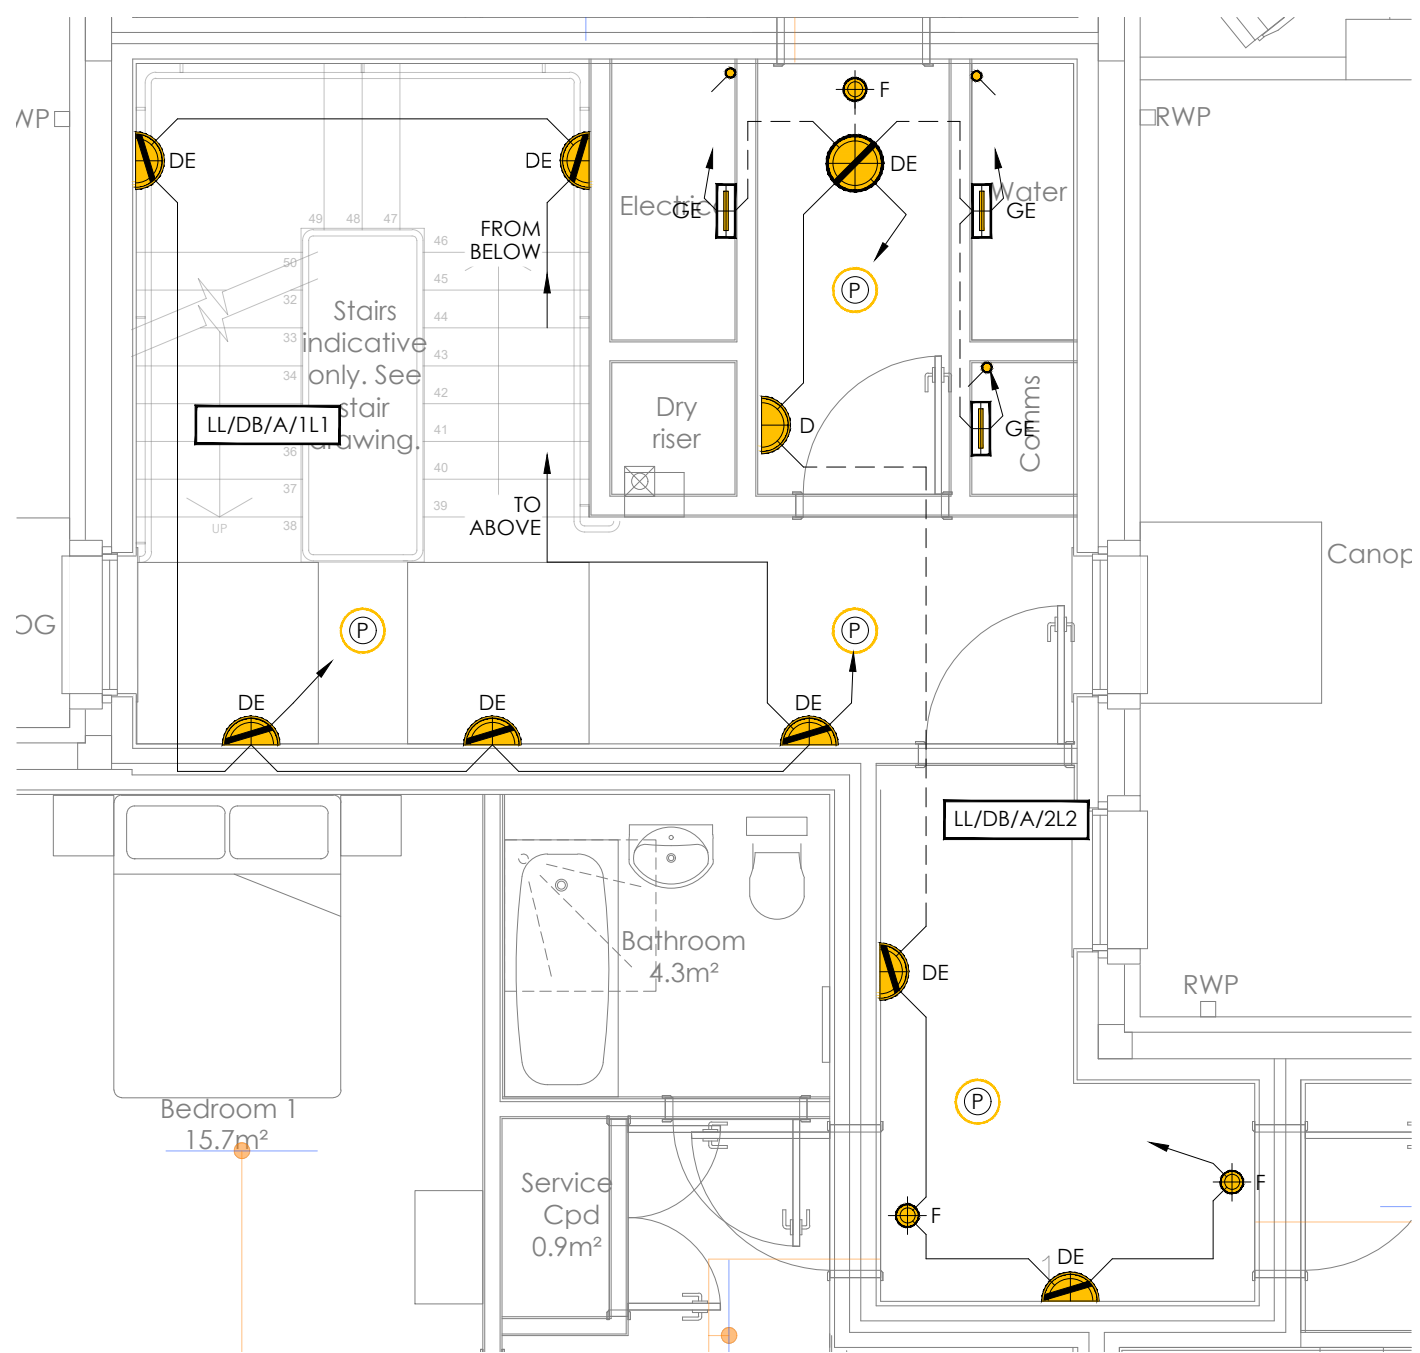

SECOND FLOOR

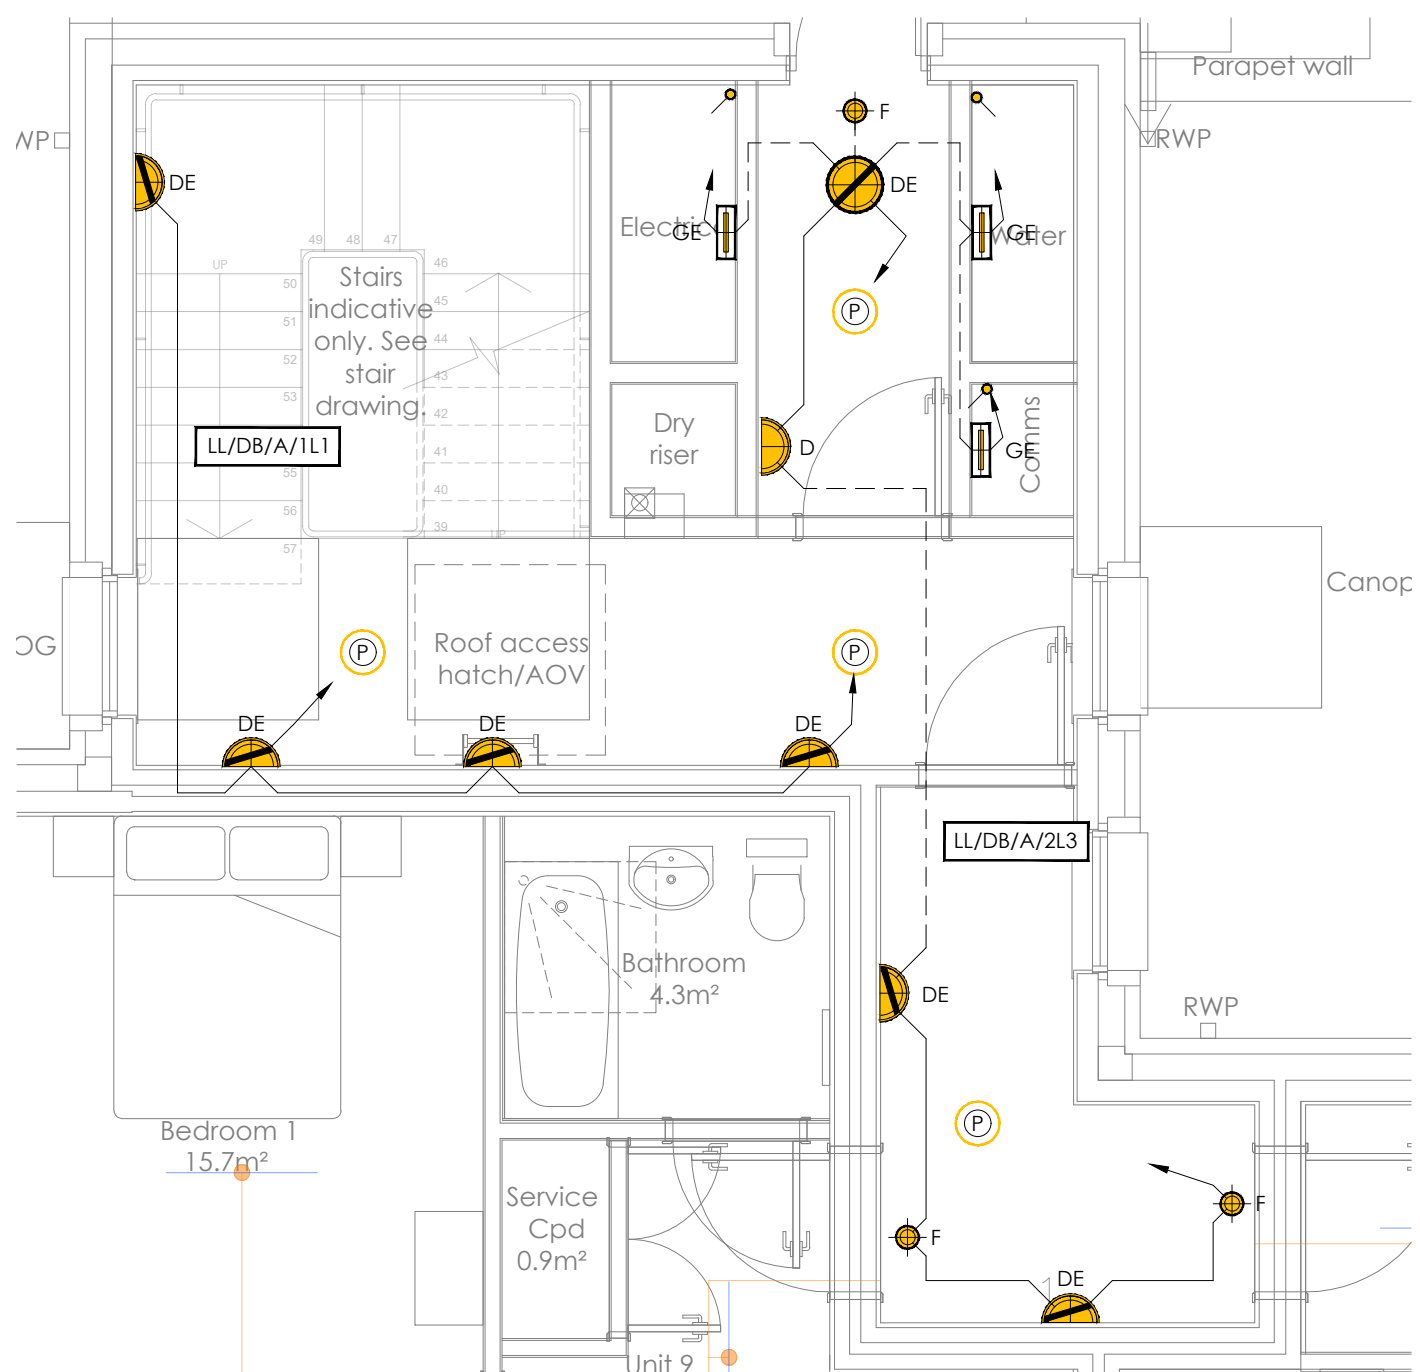

THIRD FLOOR

- ## GENERAL NOTES
- DO NOT SCALE FROM THIS DRAWING. USE ONLY DIMENSIONED FIGURES.
 - DIMENSIONS TO BE SITE CHECKED BY THE CONTRACTOR WORKING ONLY FROM GRID AND FIGURED DIMENSIONS AND CROSS-CHECKED WITH ALL OTHER RELEVANT DRAWINGS.
 - THIS DRAWING IS TO BE READ IN CONJUNCTION WITH ALL RELEVANT ARCHITECTS, STRUCTURAL ENGINEERS AND KENCH CONSULTANTS LTD DRAWINGS AND SPECIFICATION.
 - ANY DISCREPANCIES TO BE REPORTED TO THE CONSULTANT PRIOR TO CONSTRUCTION.
 - THE TITLE, COPYRIGHT AND INFORMATION IN THIS DOCUMENT IS THE PROPERTY OF KENCH CONSULTANTS LTD.

P05	05/02/25	APPROVAL ISSUE	NT	DS	CD
P04	12/08/24	APPROVAL ISSUE	JJ	SH	CD
P03	19/07/24	APPROVAL ISSUE	JJ	SH	CD
P02	30/04/24	PRELIMINARY ISSUE	JJ	JJ	CD
P01	27/02/24	PRELIMINARY ISSUE	JJ	JJ	CD
Rev.	Date:	Description:	Eng:	Drn:	Apr:



ADDRESS:
Unit 7, Sherwood House,
Walderslade Road,
Chatham, Kent, ME5
9UD

TELEPHONE: 0208 057 6552

WEBSITE:
www.kenchconsultants.com

E-MAIL:
info@kenchconsultants.com



Project:

BRUNEL WALK

BLOCK A - ALL FLOORS
COMMUNAL AREAS
LIGHTING LAYOUT

Scale: Date: Checked: Suitability:

1:50@A1

FEB '2

CD

Drawing Status:

Revision:

STAGE 4 - APPROVAL

Drawing Number:

0053-KCL-BA-ZZ-DR-E-2501