


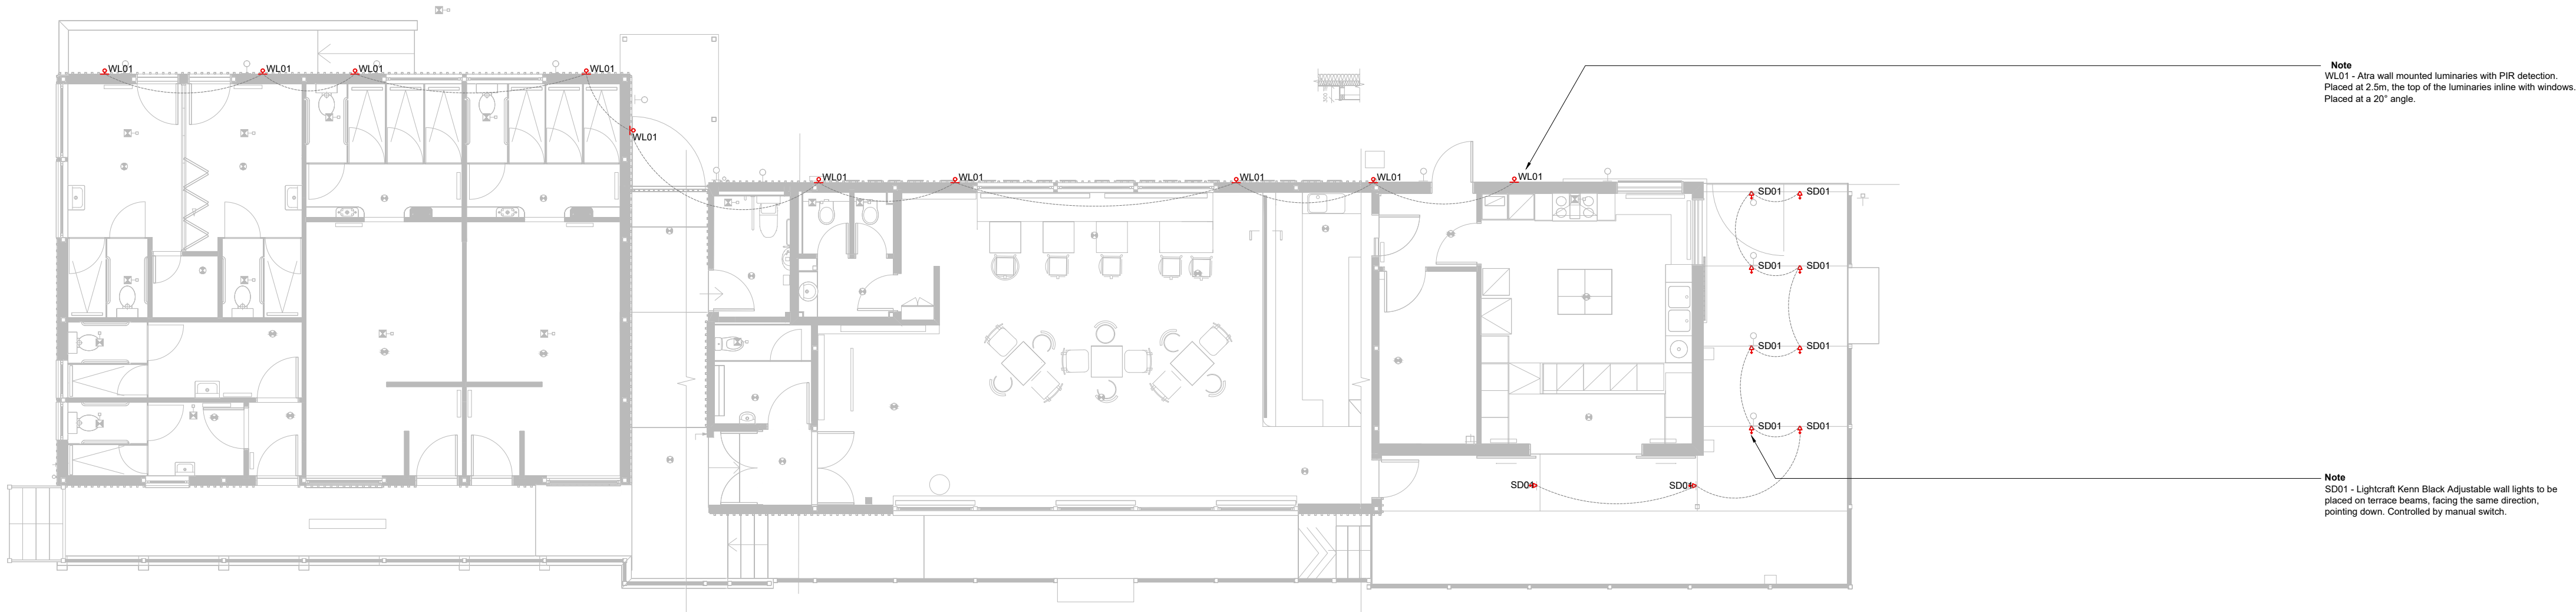

This drawing represents design intent only and is not for construction. The contractor must coordinate all works accordingly and report discrepancies to 18 Degrees Below Ltd prior to action.

Not all lighting components are shown. Contractor to include all necessary items (wiring, controls, interfaces, etc.) for full functionality per design intent.

Linear lengths are indicative and must be verified in details and on site before ordering.

Do not scale to this drawing. Dimensions are for coordination purposes only. Refer to architect's RCP and GA drawings for setting out.

Controls and control gear to be coordinated and installed in accessible, ventilated locations per MEP/Architect input. Wiring/control layouts are indicative. Electrical Engineer to confirm design infrastructure.

Power/data by others. See MEP drawings for information.

Additional terms apply. Please refer to the lighting specification document.

Drawing Key

Grey hatch indicates area outside of the 18 Degrees scope area.

Clouded denotes changes.

Revision change relates to.

RD01 Luminaire Reference

XX Floor
Y Area
ZZZ Channel

Connected luminaires are in the same control group.

Luminaire Reference / Architectural

- RD Recessed downlight
- SD Suspended/Surface mounted light
- LL Linear light
- WL Wall light
- LT Light tile
- LB Light box
- TR Lighting track
- TS Track mounted spotlight
- TL Track mounted linear
- TP Track mounted pendant
- SP Spike mounted light

Recessed Luminaire Cut Out Requirements

- RD01 ø 64mm
- RD02 285mm x 43mm
- RD03 ø 64mm
- RD04 ø 47mm
- EM ø 43mm

P04	22.06.2026			JD	PB
P03	09.06.2026			JD	PB
P02	28.05.2026			JD	PB
P01	26.05.2026			JD	PB
Rev	Date	Issue	Dwn.	Chk.	



18 Degrees
Studio 20, 1 Waterden Rd
London | E15 2HB

hello@18degs.com
www.18degs.com
+44(0)20 7426 0190

Client

NLCC

Architect

Berzins Architects


Project Title

NLCC

Drawing Title


Ground Floor
External Lighting Plan

Status	Drawn	Checked	Scale @ A1
	JD	PB	1:100
Drawing No.	Revision		
0620-18D-XX-DR-J-10100	-P01		

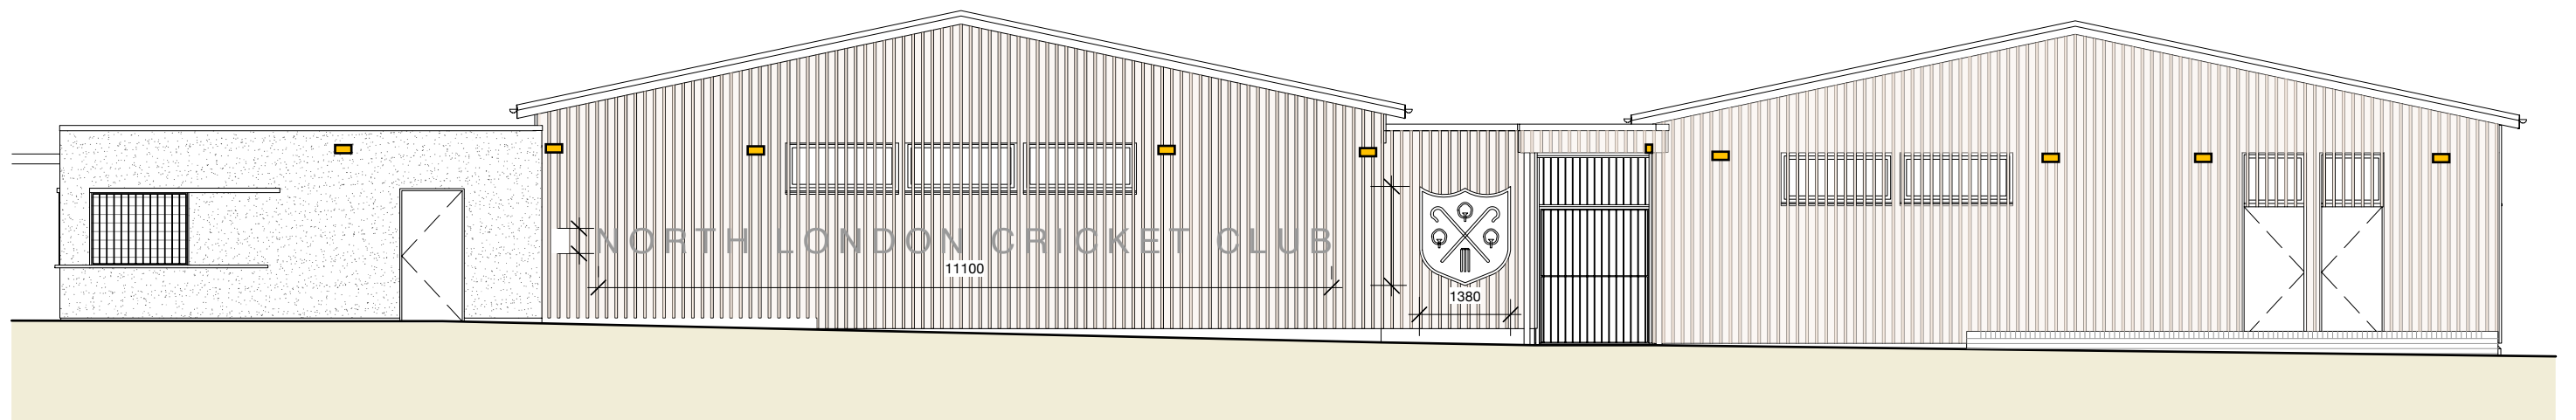

SOUTH ELEVATION : SIGNAGE : PROPOSED

Scale 1:100

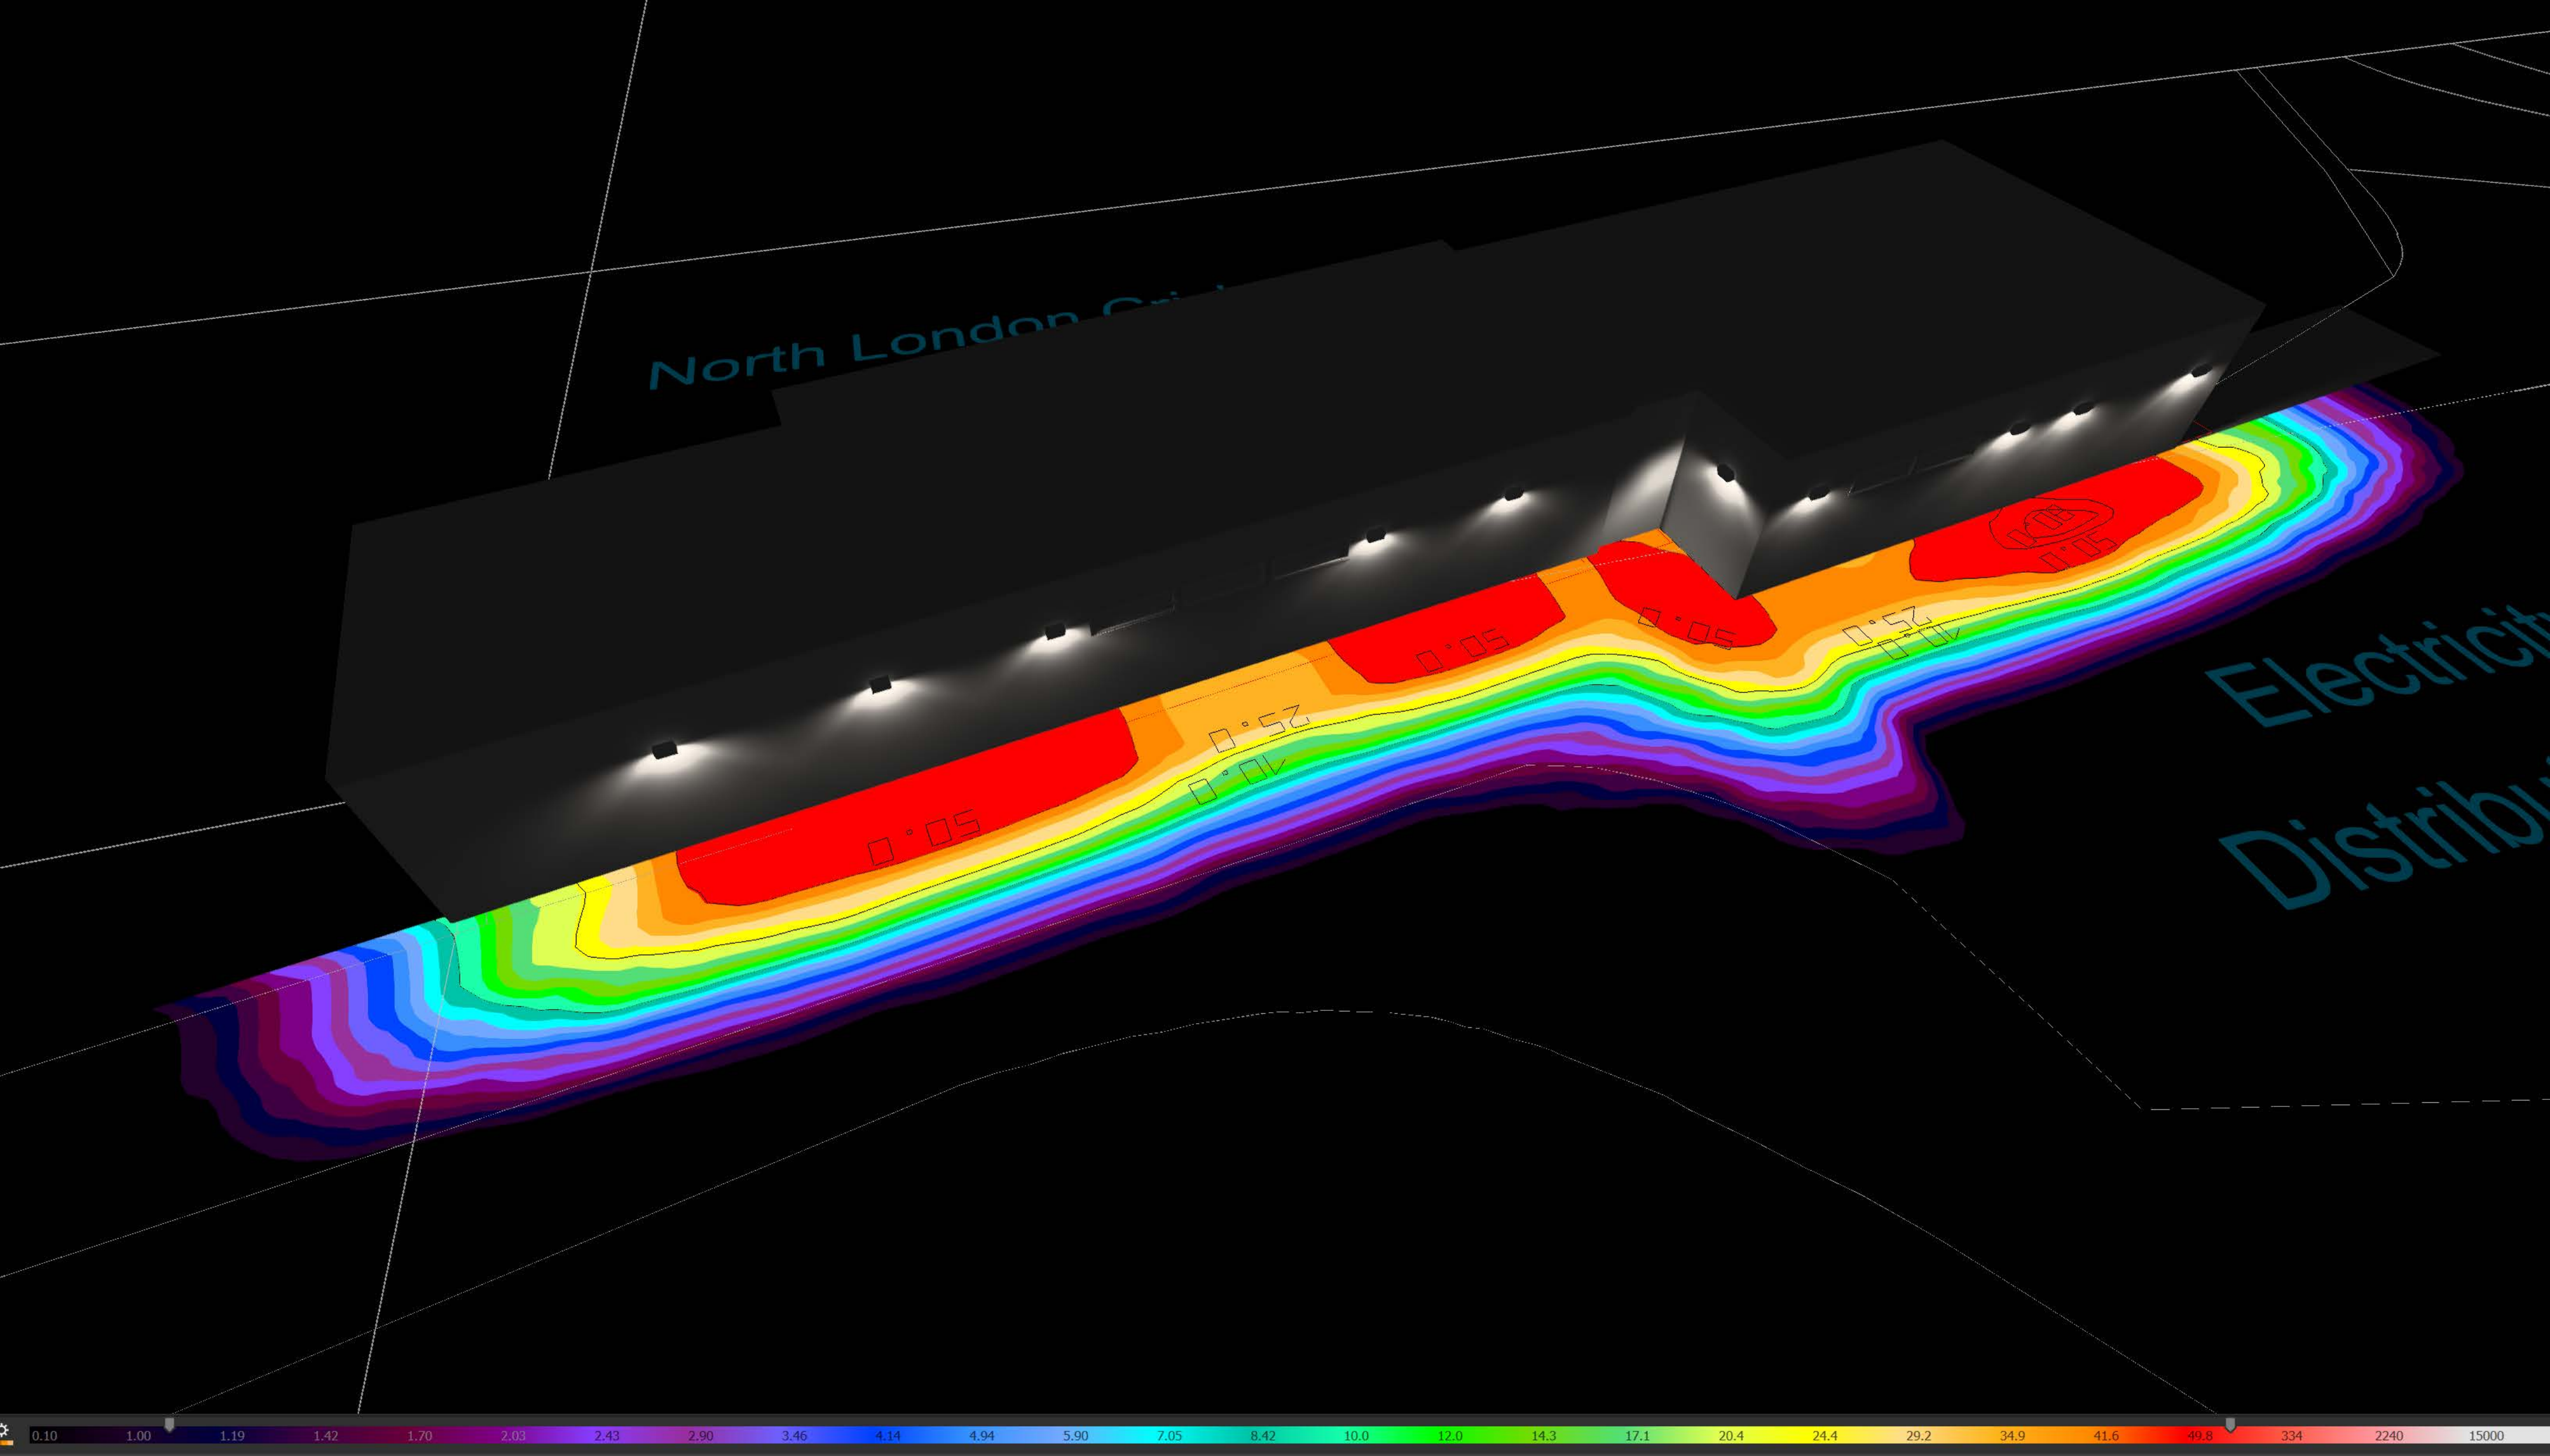

Electricity
Distribution Site

