

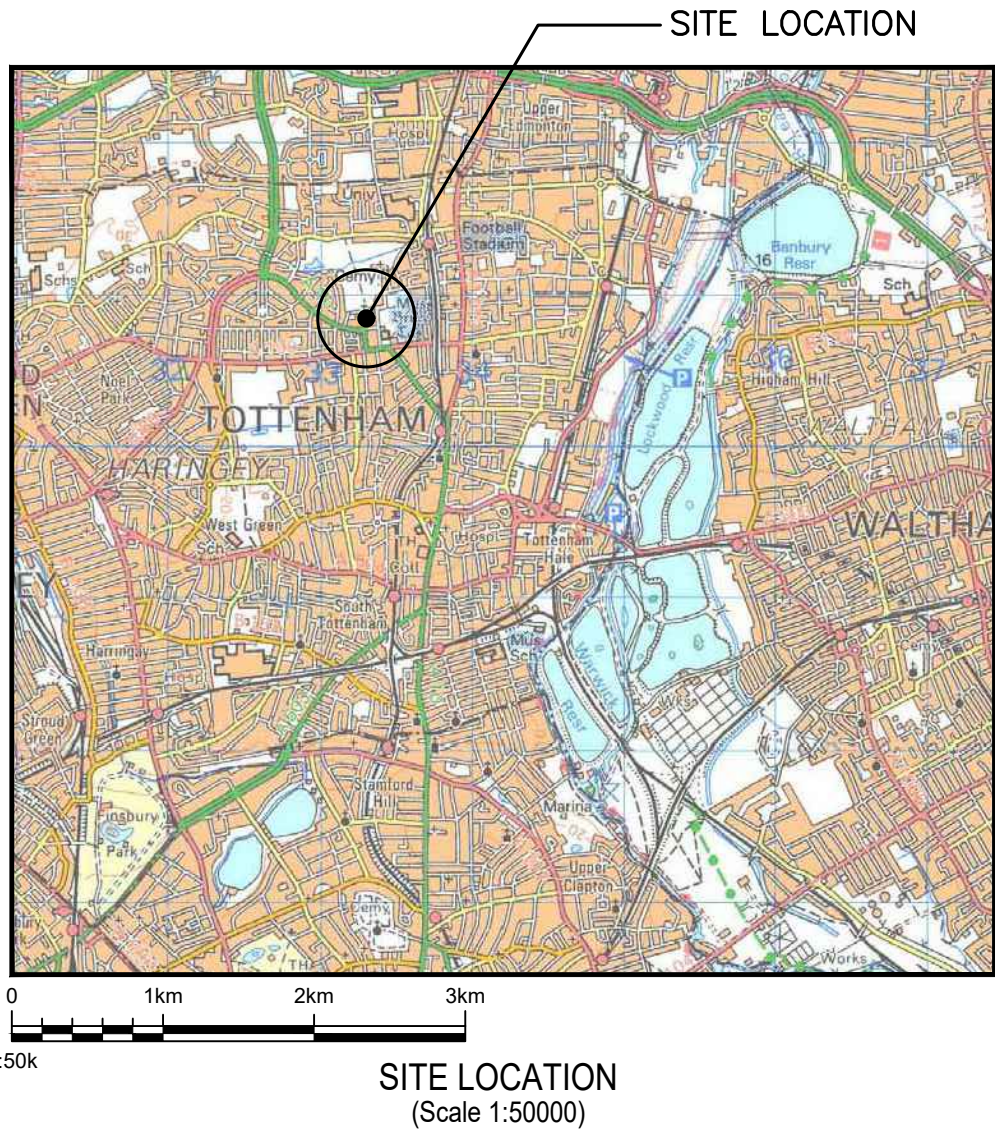


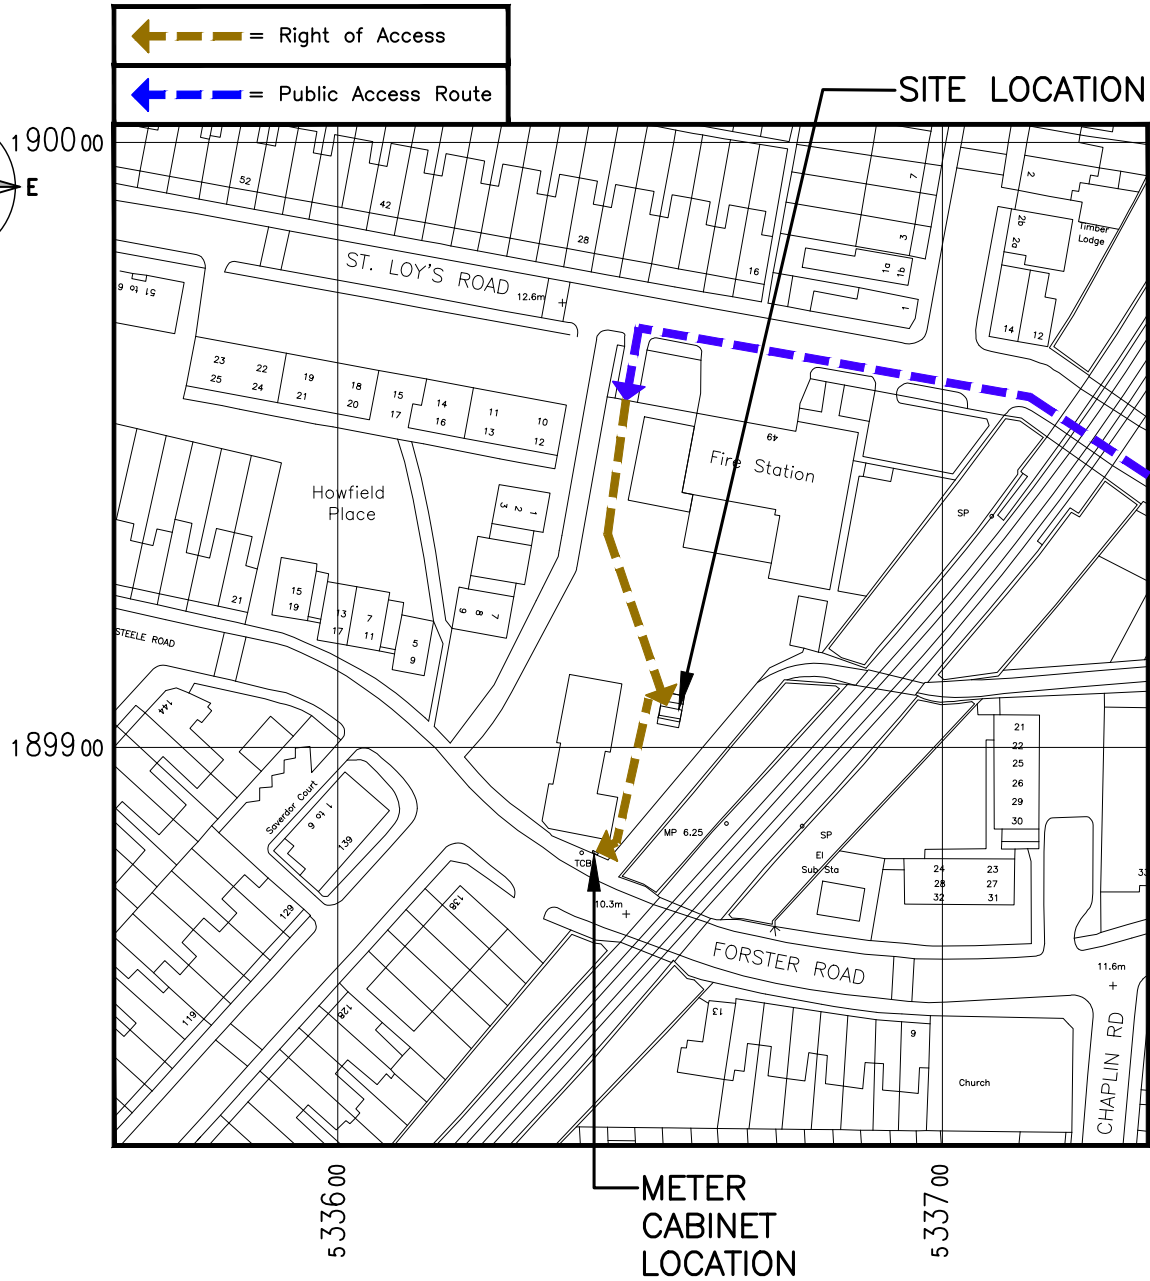

SITE PHOTOGRAPH

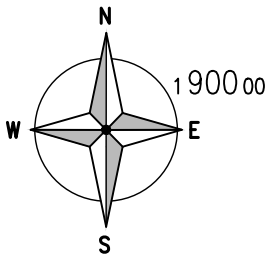

ALL DIMENSIONS ARE IN mm UNLESS NOTED OTHERWISE

N.G.R | E:533657 | N: 189908

NOTES:

DIRECTIONS TO SITE:

AT JUNCTION 25, TAKE THE A10 EXIT TO LONDON (N&C) ENFIELD/HERTFORD. AT THE ROUNDABOUT, TAKE THE 3RD EXIT ONTO GREAT CAMBRIDGE ROAD/A10. KEEP LEFT AT THE FORK AT THE ROUNDABOUT, TAKE THE 1ST EXIT ONTO LORDSHIP LANE/A10. CONTINUE TO FOLLOW THE A10 THEN TURN RIGHT ONTO HIGH ROAD. TAKE THE 1ST RIGHT ONTO ST. LOY'S ROAD. THE SITE IS LOCATED ON THE LEFT HAND SIDE.

A	PLANNING ISSUE	CB	CA	23.07.26
REV	MODIFICATION	BY	CH	DATE


2nd Floor, Building C, One Central Park,
Northampton Road, Manchester, M40 5BP,
Tel: 0161 785 4500
Fax: 0161 785 4501
Web: www.clarke-telecom.com




Cell Name	Opt.
TOTTENHAM FIRE STATION	—

Cell ID No		
CSID	VF	TEF
13613535	N/A	19511
Project No.	TM Cell ID	N/A
—	—	—

Site Address / Contact Details
TOTTENHAM FIRE STATION ST LOY'S ROAD HOWFIELD PLACE LONDON N17 6UF

Drawing Title:		SITE LOCATION MAPS			
Purpose of issue:					Dwg Rev:
PLANNING					
Drawing Number:					
100					A
Surveyed By:			Original Sheet Size:		Pack Issue:
CA			A3		
Drawn:	Date:	Checked:	Date:		
CB	23.07.26	CA	23.07.26		A

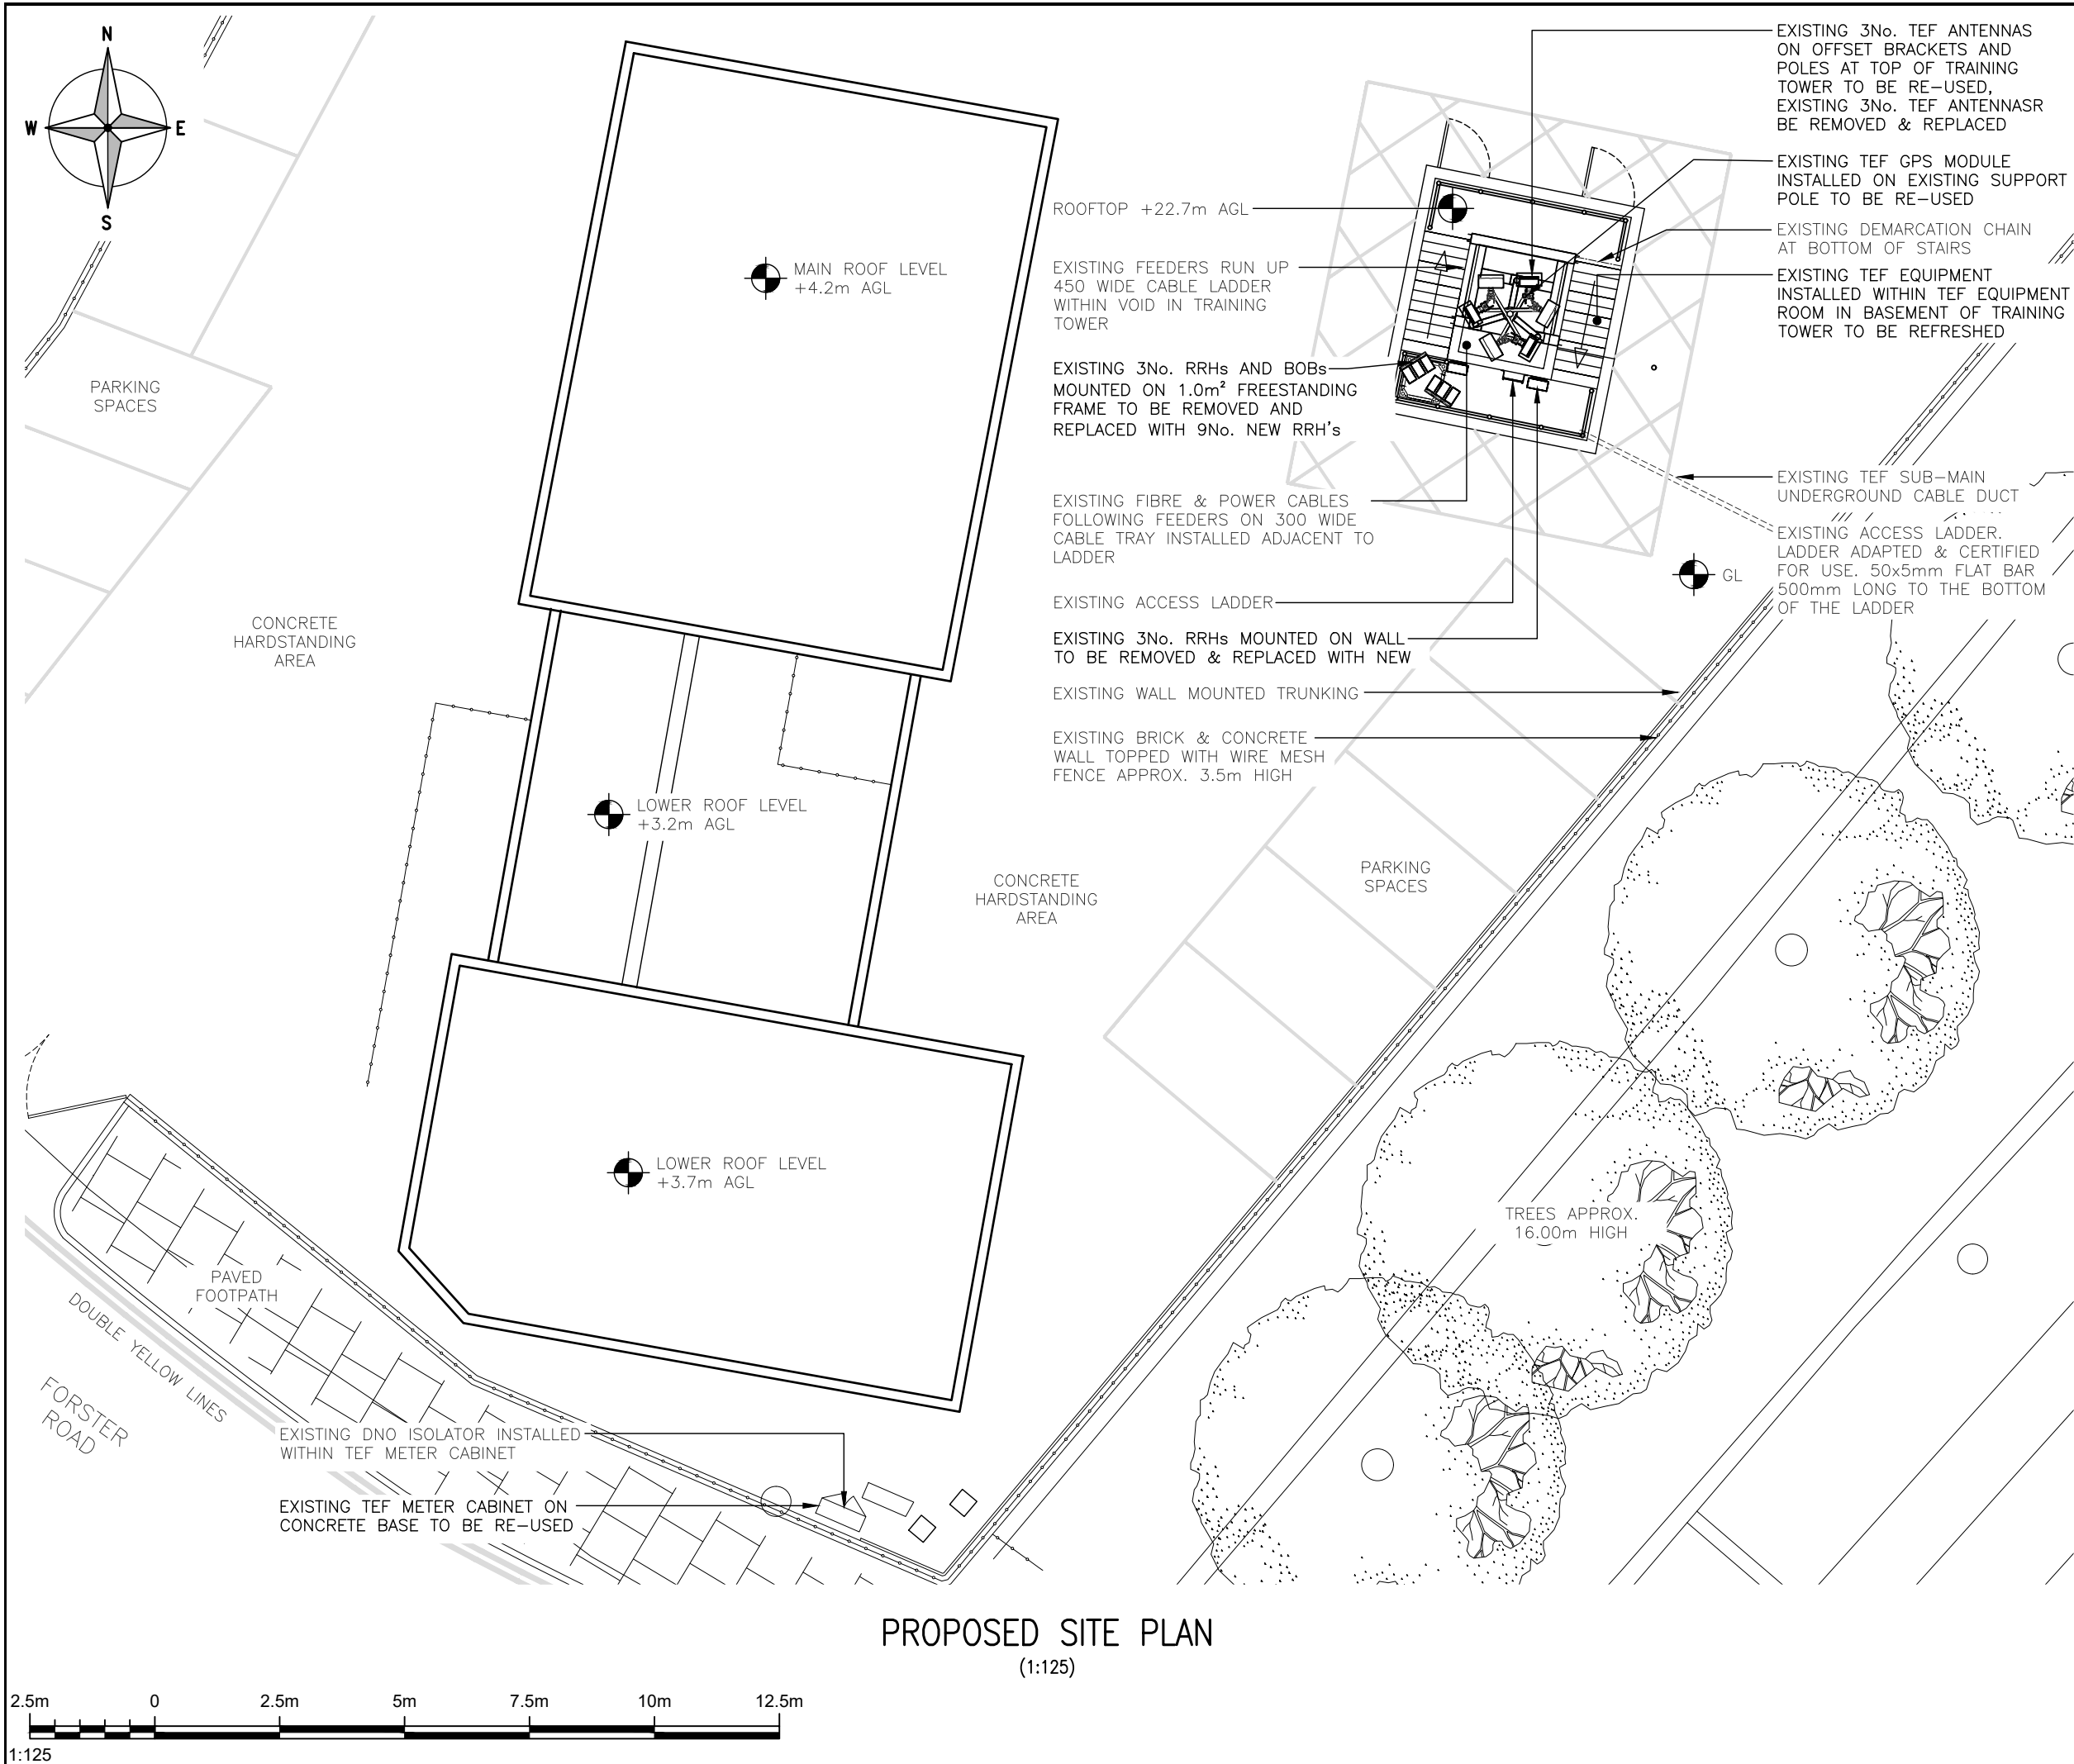

ALL DIMENSIONS ARE IN mm UNLESS NOTED OTHERWISE

N.G.R

E:533657

N: 189908


NOTES:

A	PLANNING ISSUE	CB	CA	23.07.26
REV	MODIFICATION	BY	CH	DATE


Clarke Telecom

2nd Floor, Building C, One Central Park,
Northampton Road, Manchester, M40 5BP,
Tel: 0161 785 4500
Fax: 0161 785 4501
Web: www.clarke-telecom.com

Cell Name				Opt.
TOTTENHAM FIRE STATION				—
Cell ID No				
CSID	—	VF	—	TEF
13613535	—	N/A	—	19511
Project No.	—	TM Cell ID	—	N/A
—	—	—	—	—
Site Address / Contact Details				
TOTTENHAM FIRE STATION ST LOY'S ROAD HOWFIELD PLACE LONDON N17 6UF				
Drawing Title: PROPOSED SITE PLAN				
Purpose of issue: PLANNING				Dwg Rev: A
Drawing Number: 201				A
Surveyed By: CA		Original Sheet Size: A3		Pack Issue:
Drawn: CB	Date: 23.07.26	Checked: CA	Date: 23.07.26	A

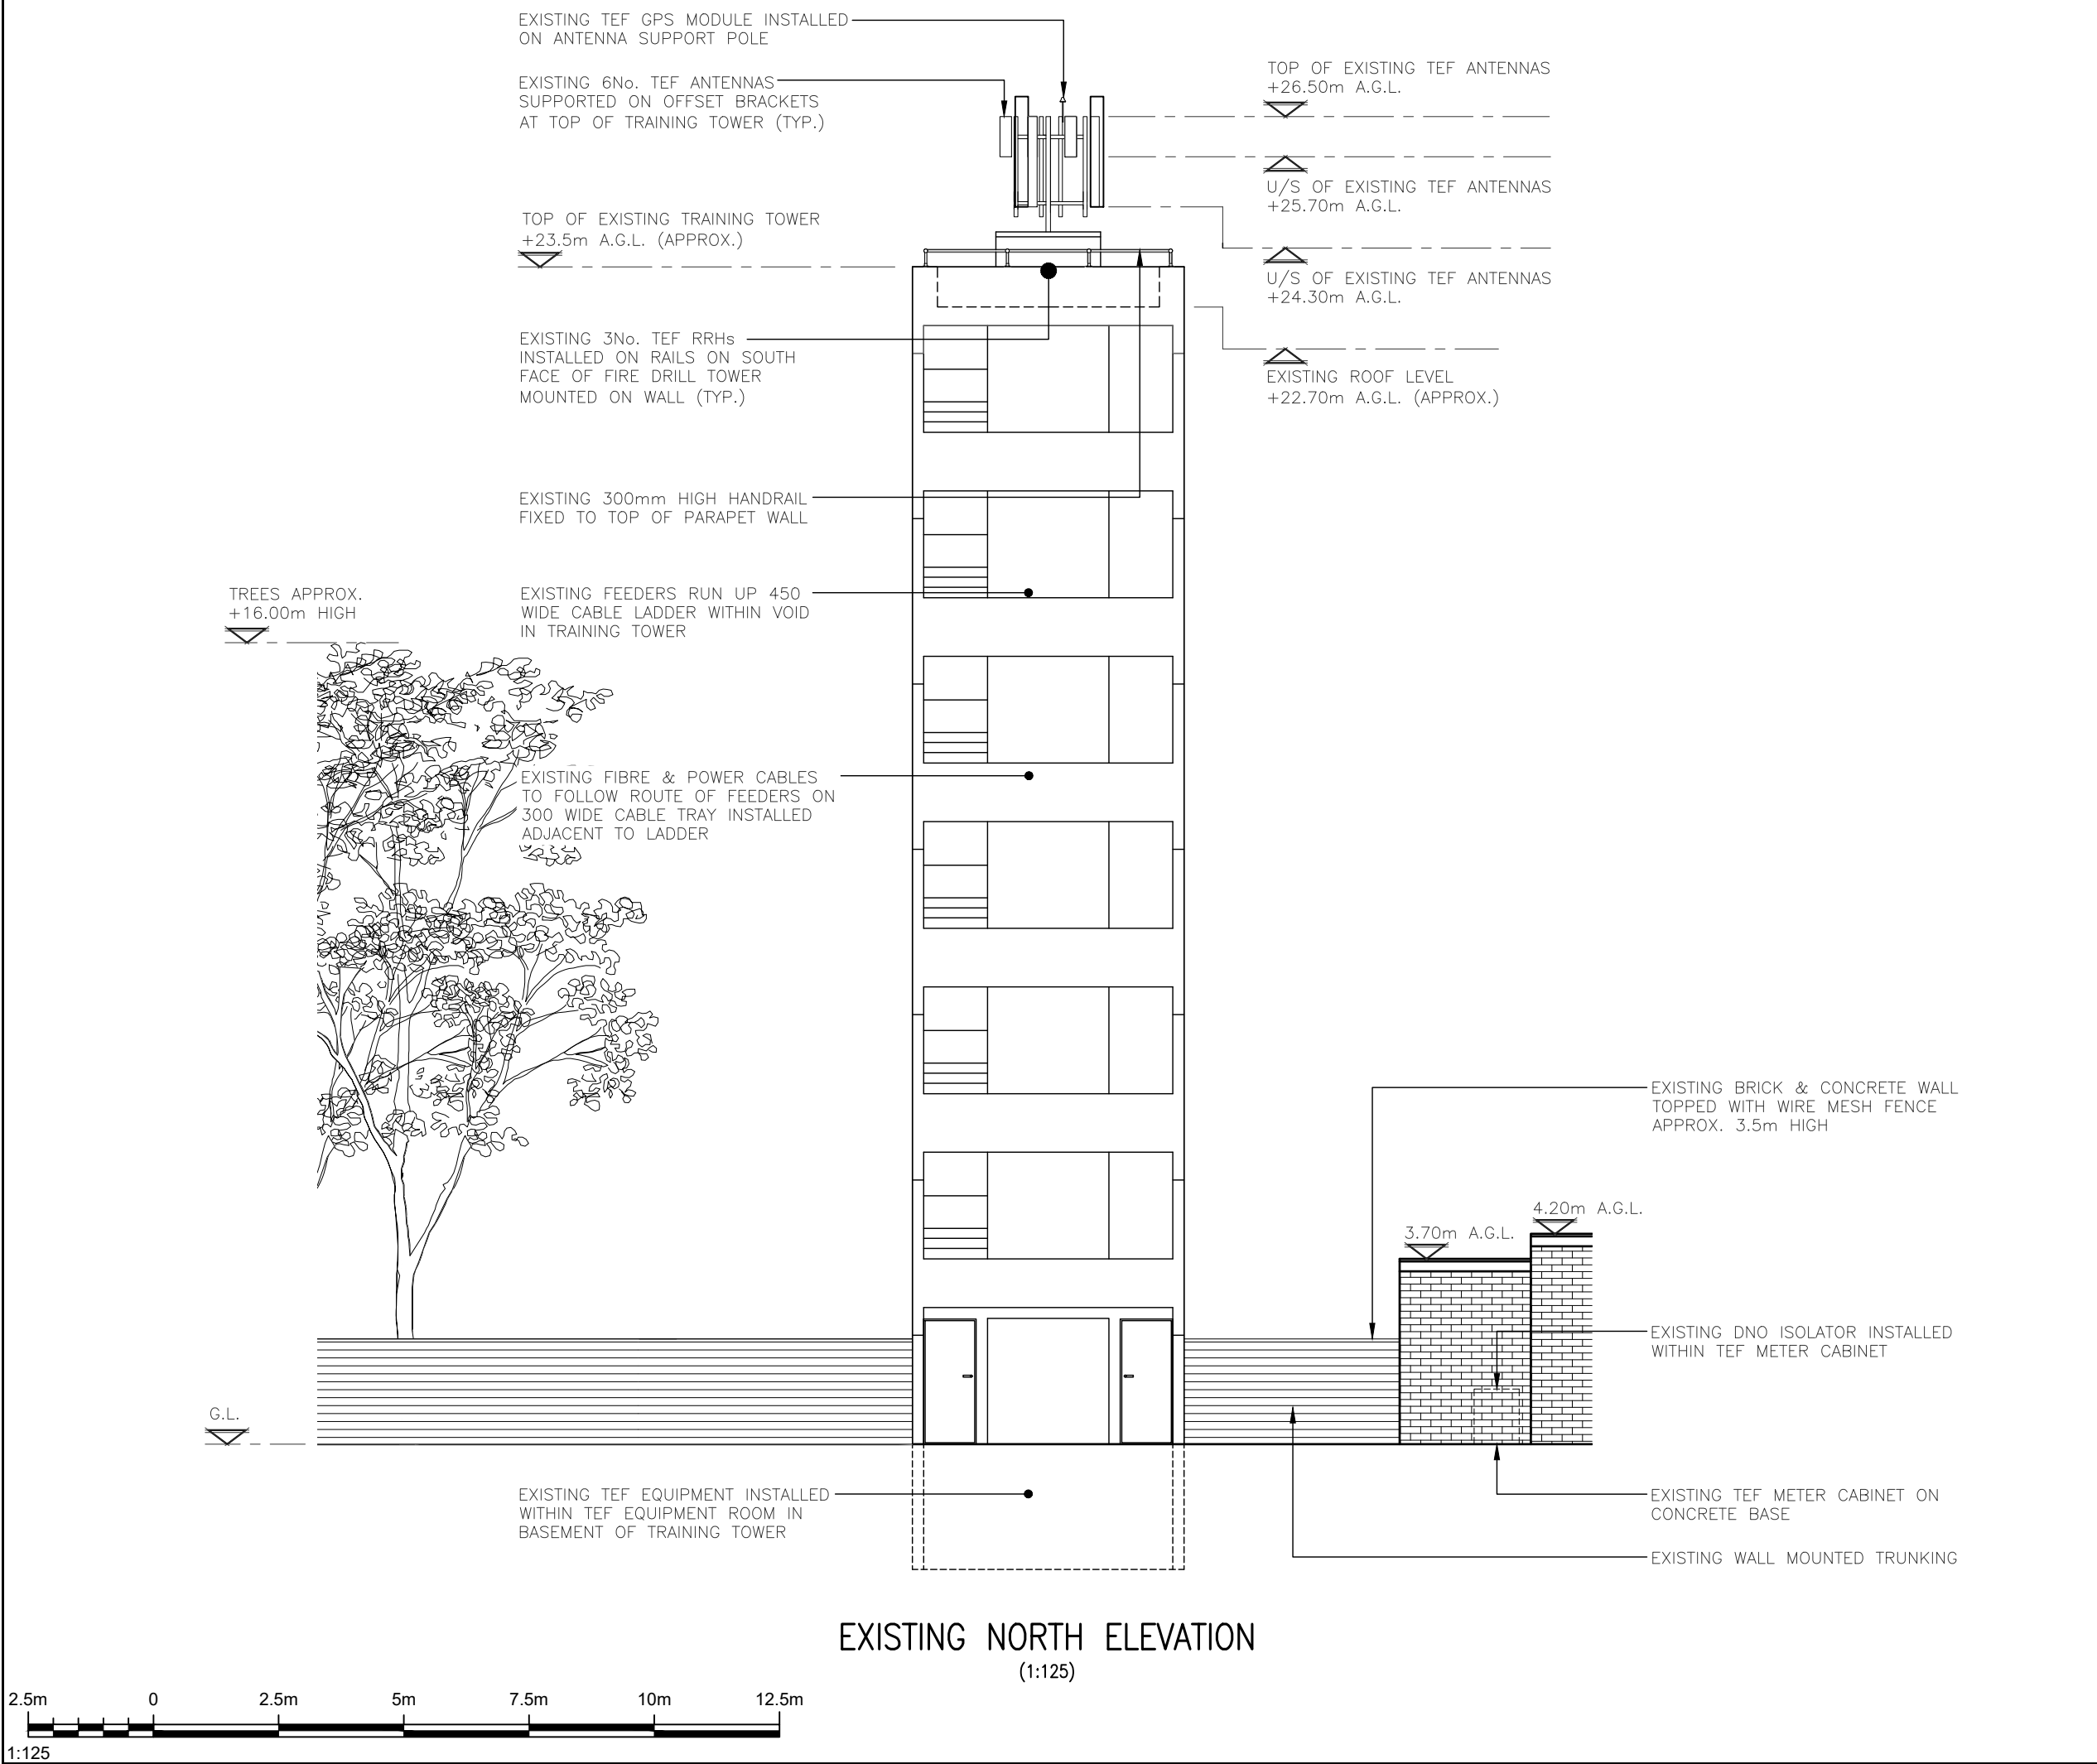

ALL DIMENSIONS ARE IN mm UNLESS NOTED OTHERWISE					
N.G.R		E:533657		N: 189908	
NOTES:					
NOTES: ROOF LEVELS ARE APPROXIMATE AND NEED TO BE CONFIRMED AS A LFB SITE					
A	PLANNING ISSUE		CB	CA	23.07.26
REV	MODIFICATION		BY	CH	DATE
 Clarke Telecom 2nd Floor, Building C, One Central Park, Northampton Road, Manchester, M40 5BP, Tel: 0161 785 4500 Fax: 0161 785 4501 Web: www.clarke-telecom.com					
 cornerstone					
Cell Name					Opt.
TOTTENHAM FIRE STATION					—
Cell ID No					
CSID		—	VF	—	TEF
13613535		N/A		19511	
Project No.		—	TM Cell ID	—	N/A
—		—		—	
Site Address / Contact Details					
TOTTENHAM FIRE STATION ST LOY'S ROAD HOWFIELD PLACE LONDON N17 6UF					
Drawing Title: EXISTING SITE ELEVATION					
Purpose of issue: PLANNING					Dwg Rev:
Drawing Number: 300					A
Surveyed By: CA			Original Sheet Size: A3		Pack Issue:
Drawn: CB	Date: 23.07.26	Checked: CA	Date: 23.07.26	A	

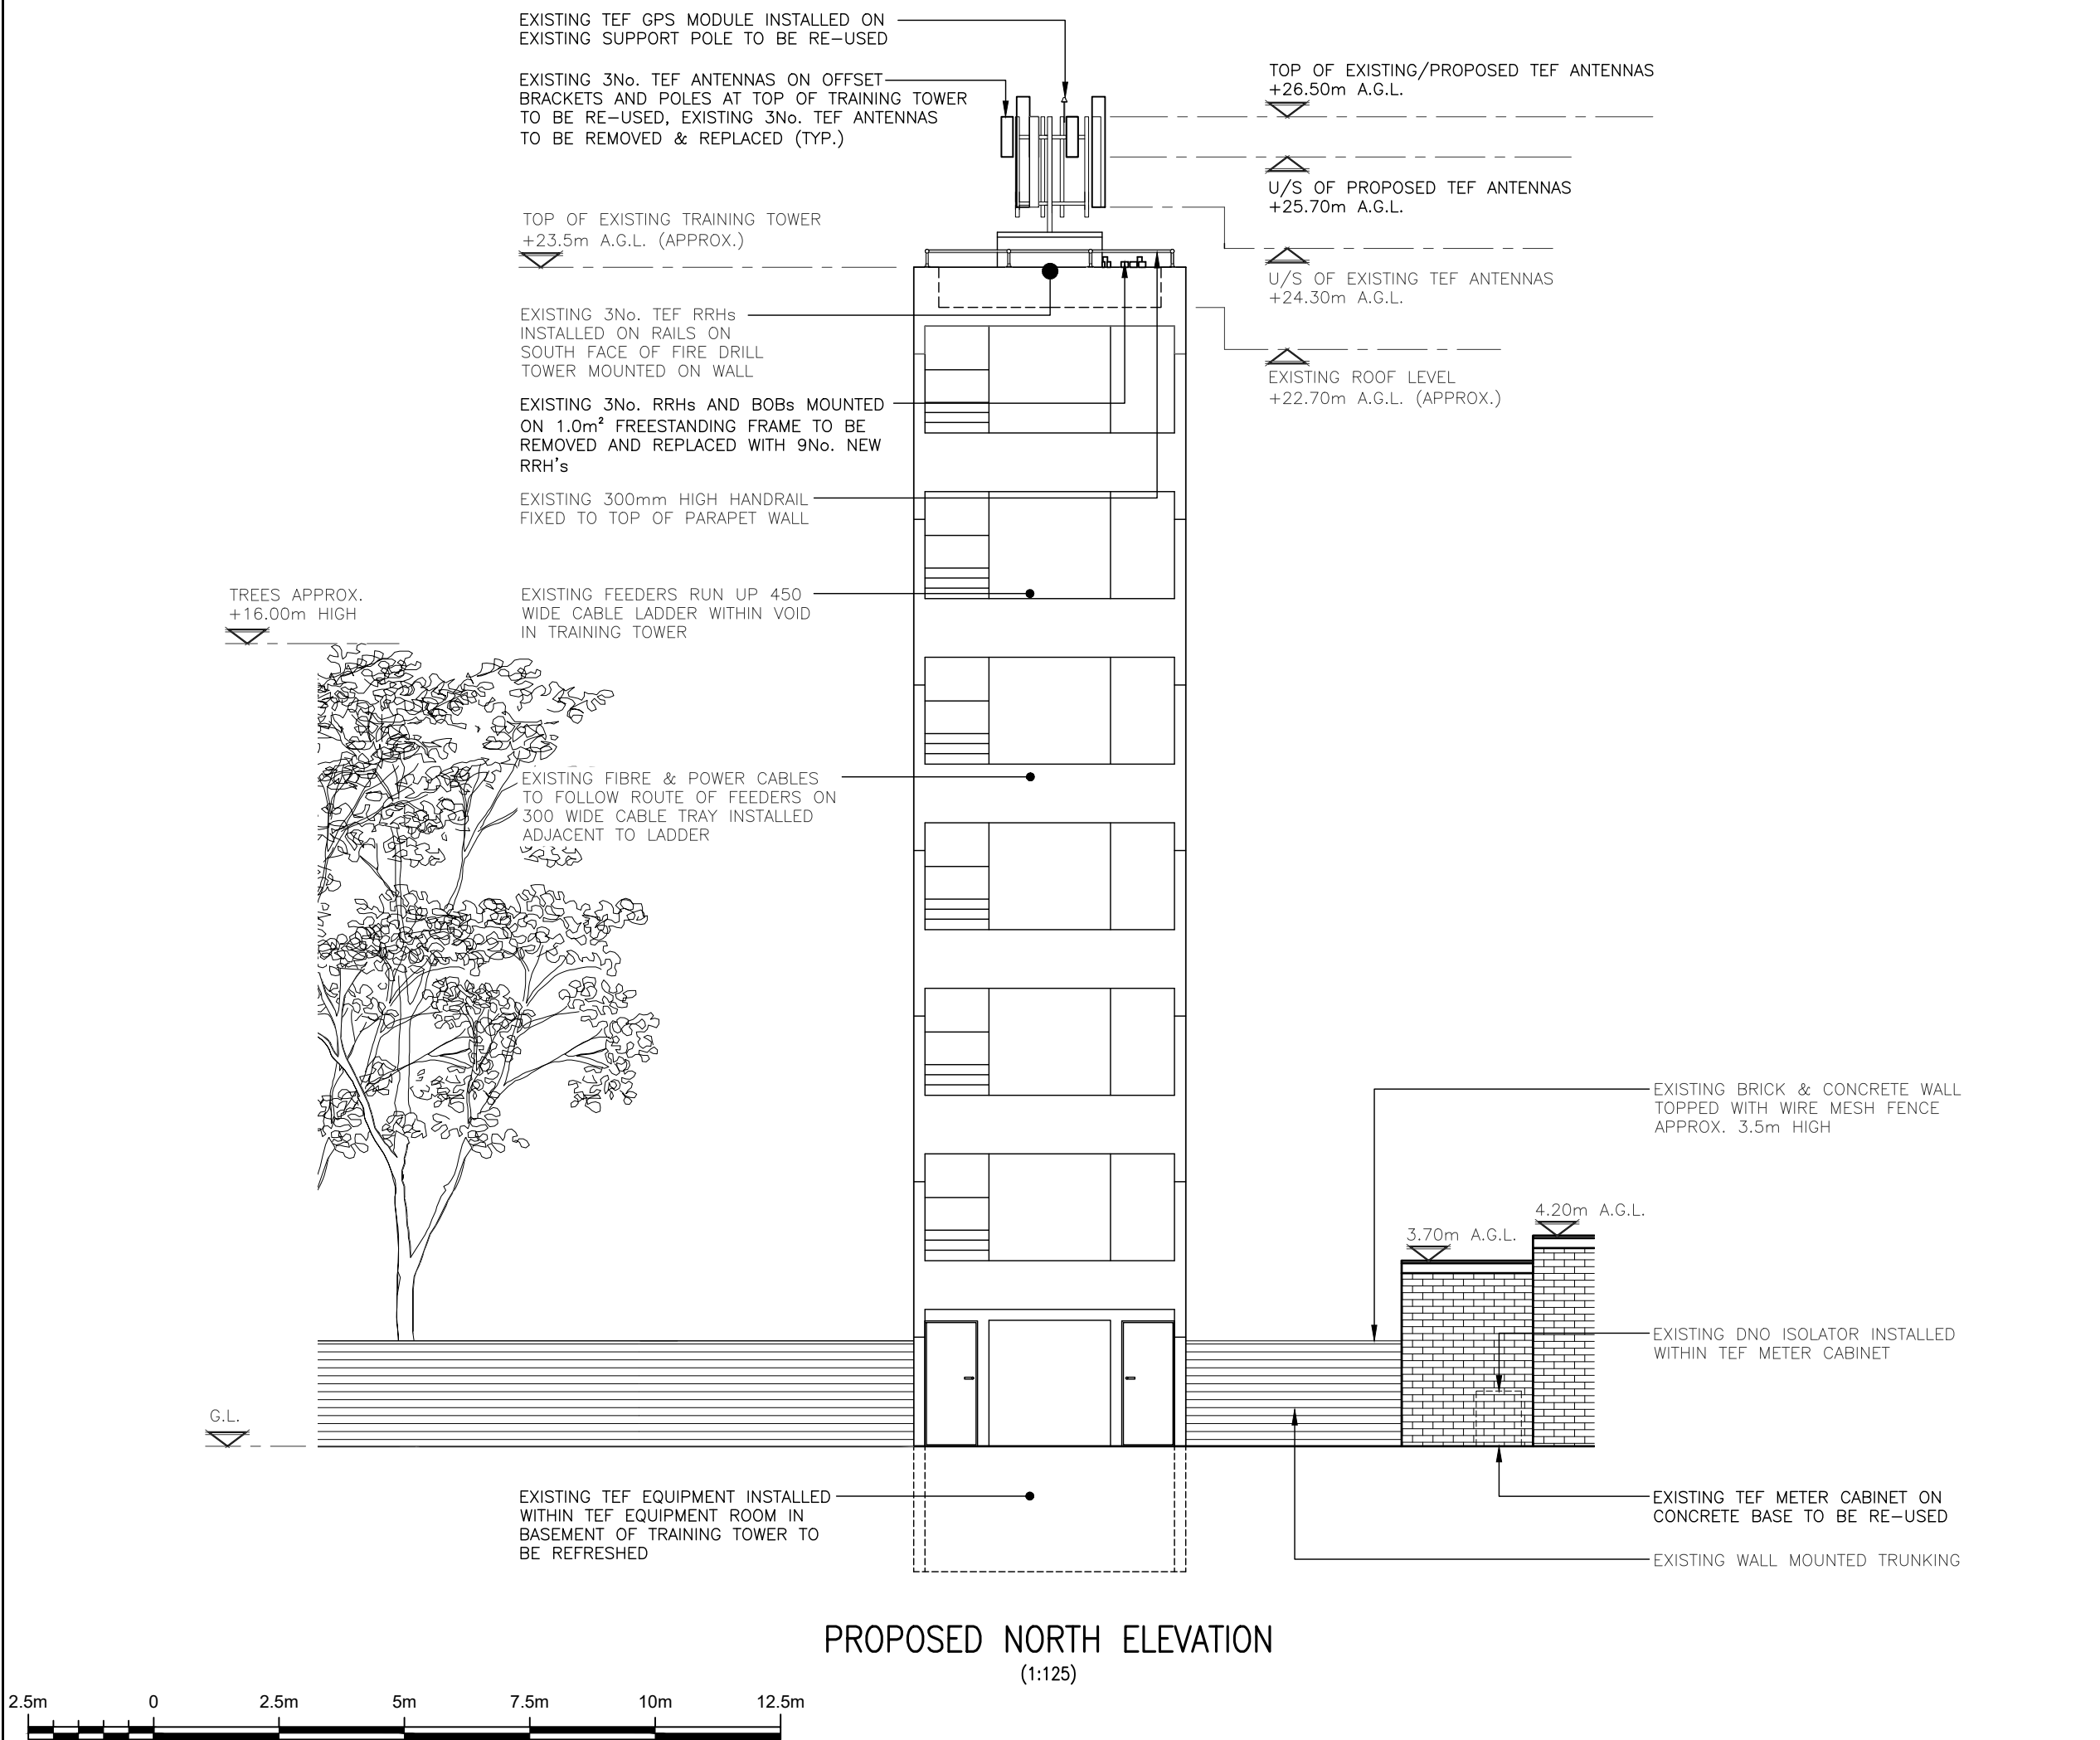

ALL DIMENSIONS ARE IN mm UNLESS NOTED OTHERWISE				
N.G.R		E:533657		N: 189908
NOTES:				
NOTES: ROOF LEVELS ARE APPROXIMATE AND NEED TO BE CONFIRMED AS A LFB SITE				