


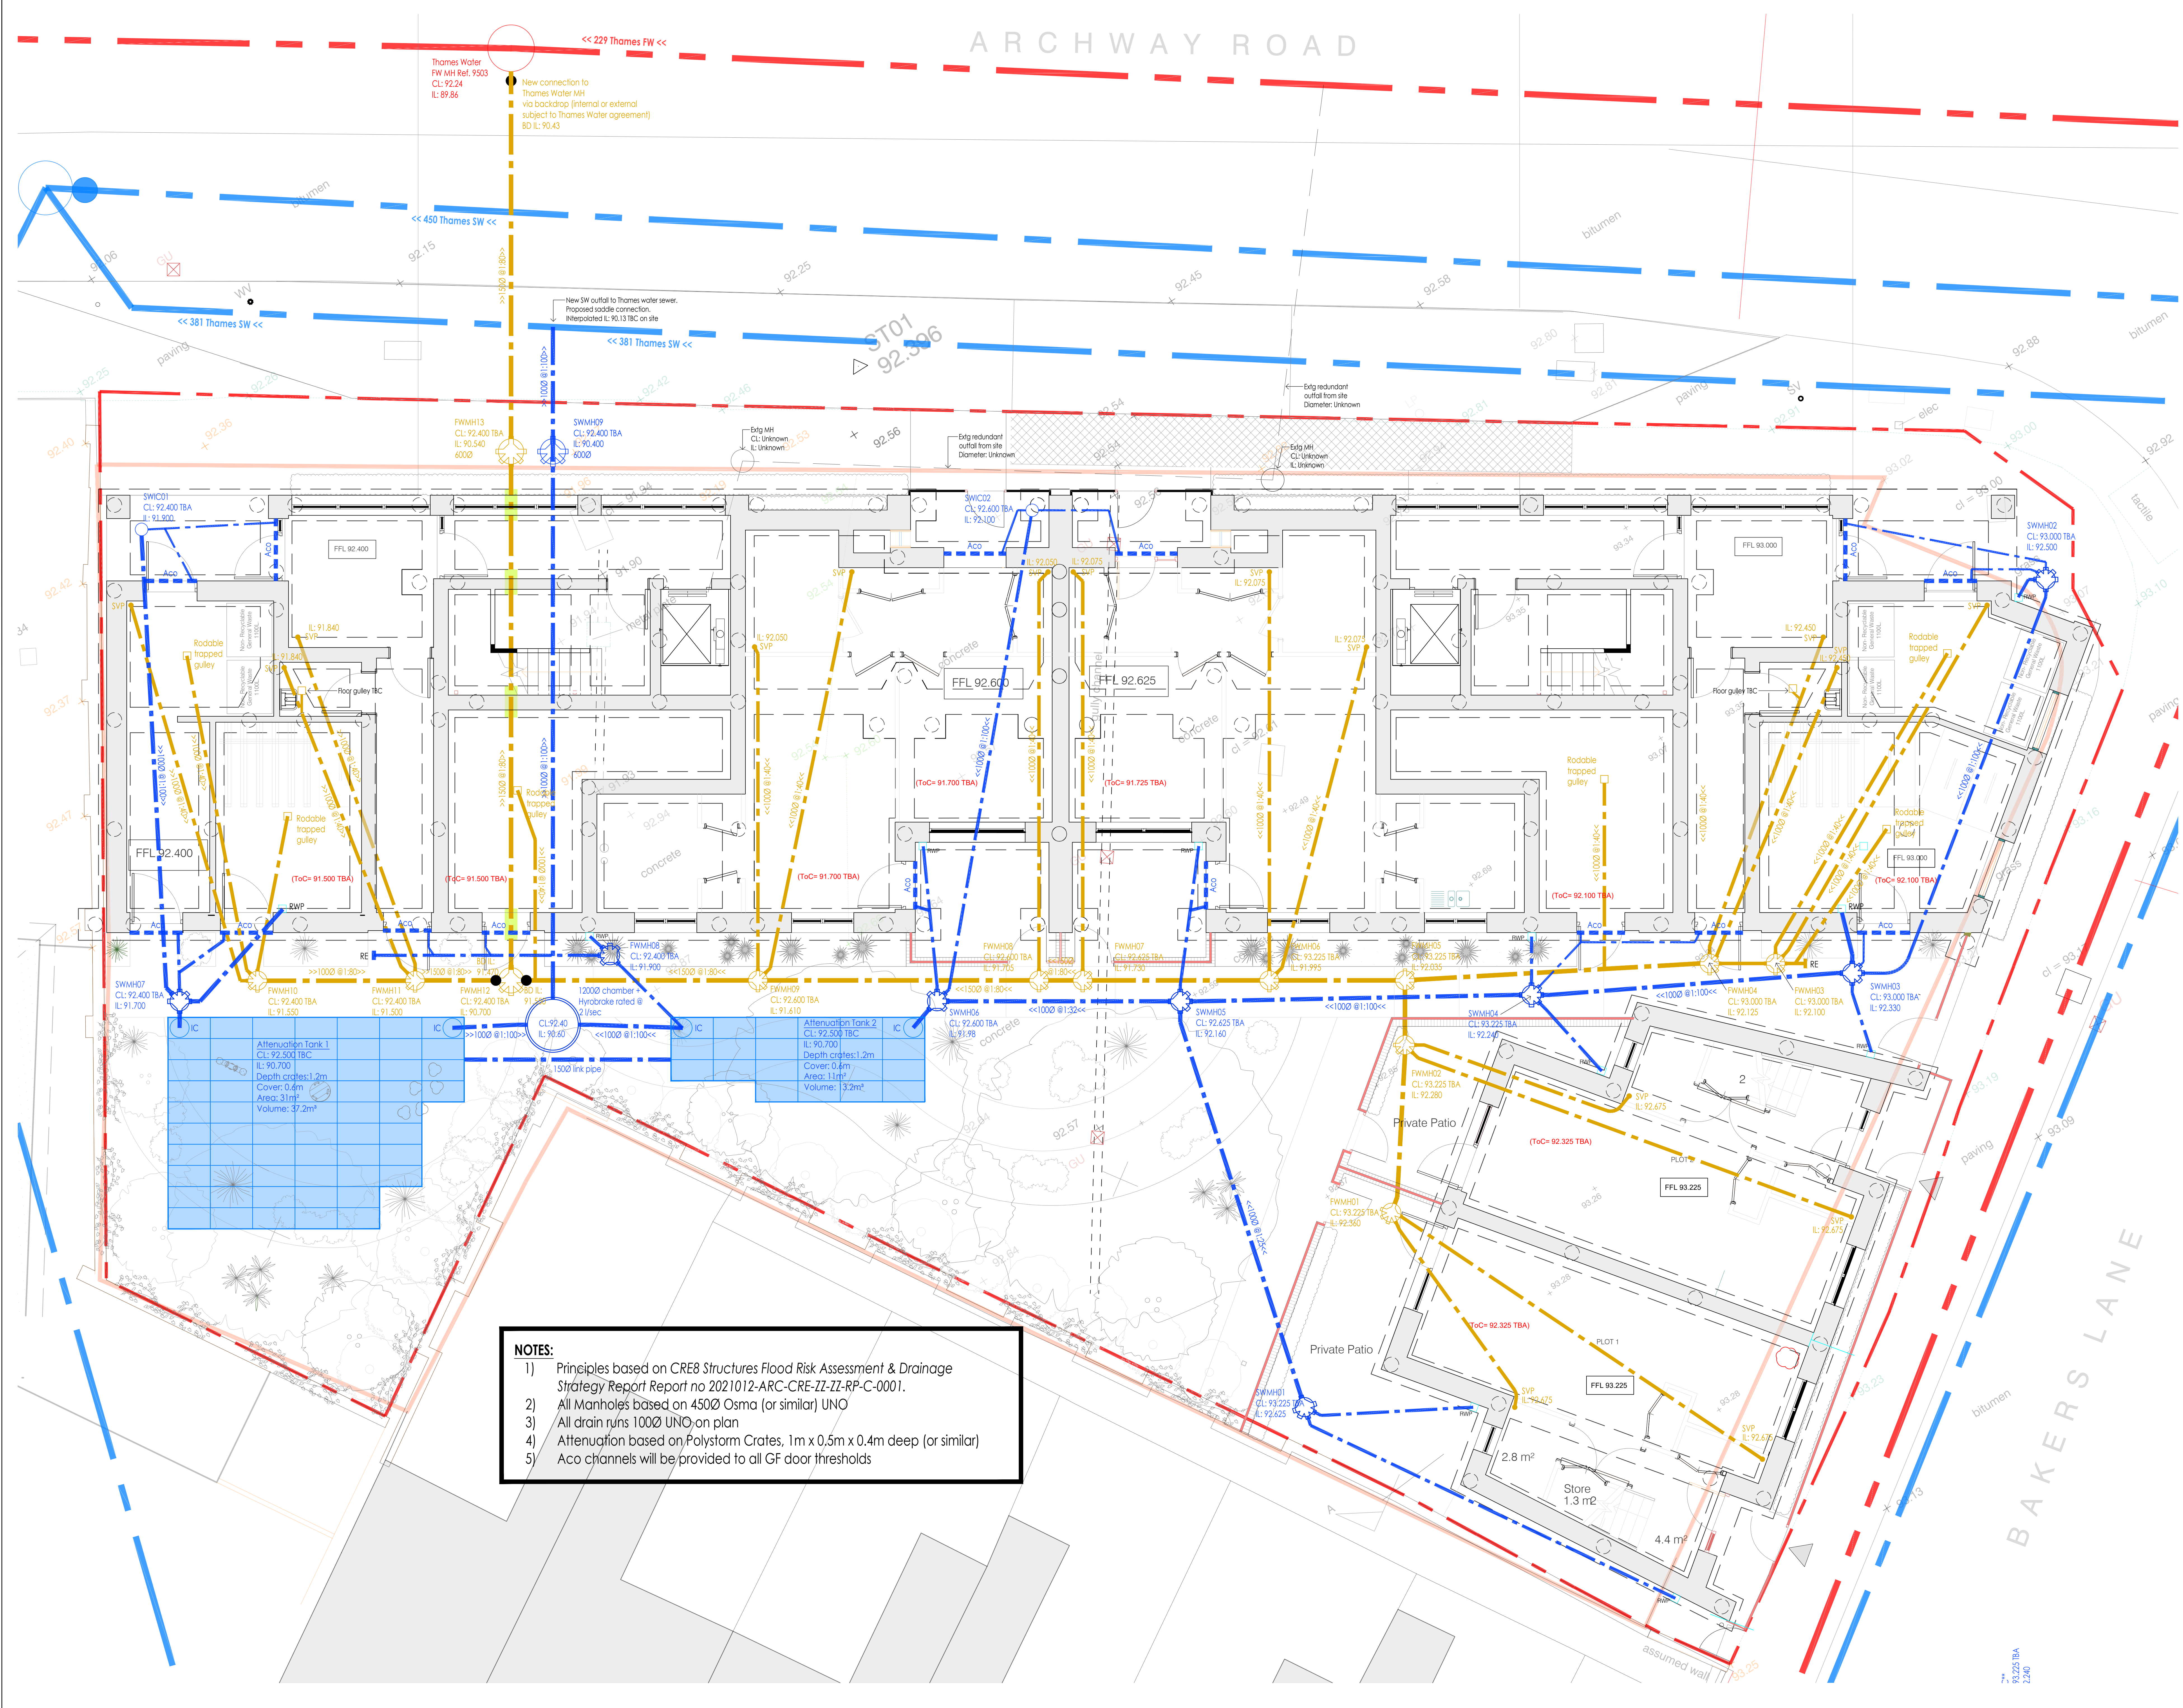

GENERAL NOTES:

- The drawing is copyright PJC.
- The drawing is to be read in conjunction with all relevant drawings and specifications.
- The drawing shall not be used for any other purpose.
- Dimensions and conditions shall be as indicated on the drawing. Any discrepancy between the drawing and the conditions shall be referred to the designer for clarification.
- The drawing shall be read in conjunction with the relevant specifications and the requirements of the Local Authority, current Codes of Practice and British Standards.
- Dimensions shall be as indicated on the drawing.
- For materials of materials are as indicated on the drawing.
- Our design is based upon the assumption that the existing drainage system is as shown on the drawing.
- Splice equipment in new steel beams to be allowed for by contractor on required. Splice design assumed to be 200kN in 1.4m. Existing beams to be 200kN in 1.4m. Existing beams to be 200kN in 1.4m. Existing beams to be 200kN in 1.4m.
- Responsibility for the design of the drainage system shall be the responsibility of the contractor.
- Any material or work shall be to the satisfaction of the Local Authority.
- Any material or work shall be to the satisfaction of the Local Authority.
- Any material or work shall be to the satisfaction of the Local Authority.

PRELIMINARY

Rev	Description	By	Date	CHK'd	Auth
P03	Co-ordinated with above ground drainage	AF	14/09/26	GN	GN
P02	Surface water invert levels indicated	AF	09/09/26	GN	GN
P01	First issued P01	AF	09/09/26	GN	GN

MARKS HEELEY

THE SHARLES CANNONS MILL LANE
MARKS HEELEY
HERFORDSHIRE CV33 3BN
TELEPHONE: 01273 465900
FACSIMILE: 01273 465999
GENERAL@MARKSHEELEY.CO.UK

CONSULTING STRUCTURAL AND CIVIL ENGINEERS

Client: **AJC**

Project: **505-511 ARCHWAY ROAD, LONDON, N6 4HX**

Title: **PROPOSED FOUL AND STORM DRAINAGE LAYOUT**

Sheet No.	Original Scale	Designed/Drawn	Checked	Authorised
A0	1:50	AF	GN	GN

Status	Drawing Number	Rev
P	H19001/ D1	P03