


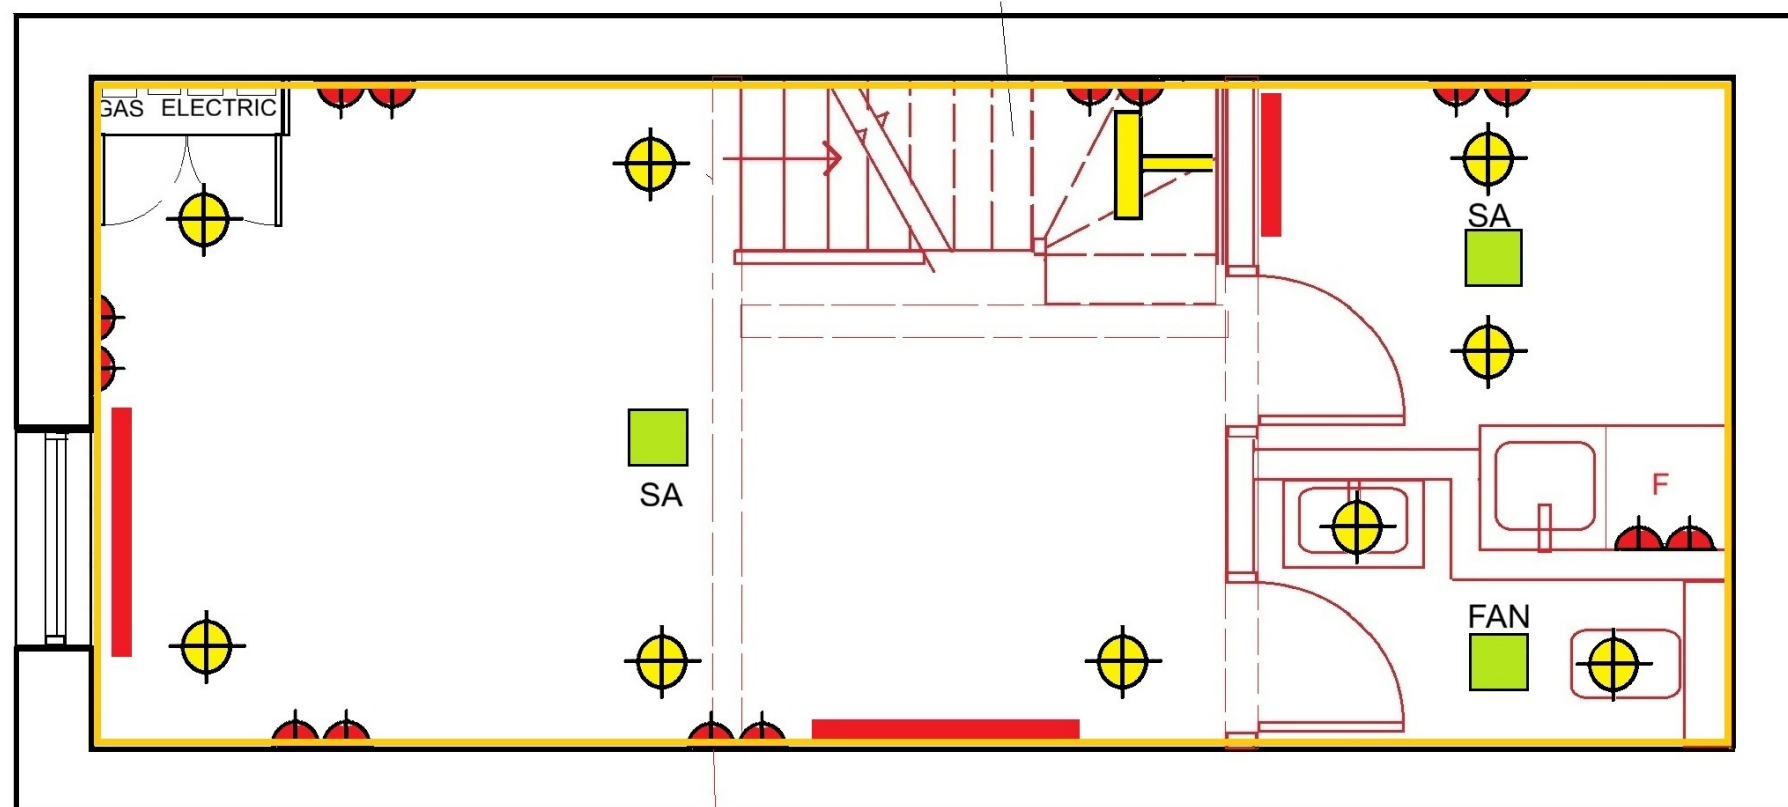


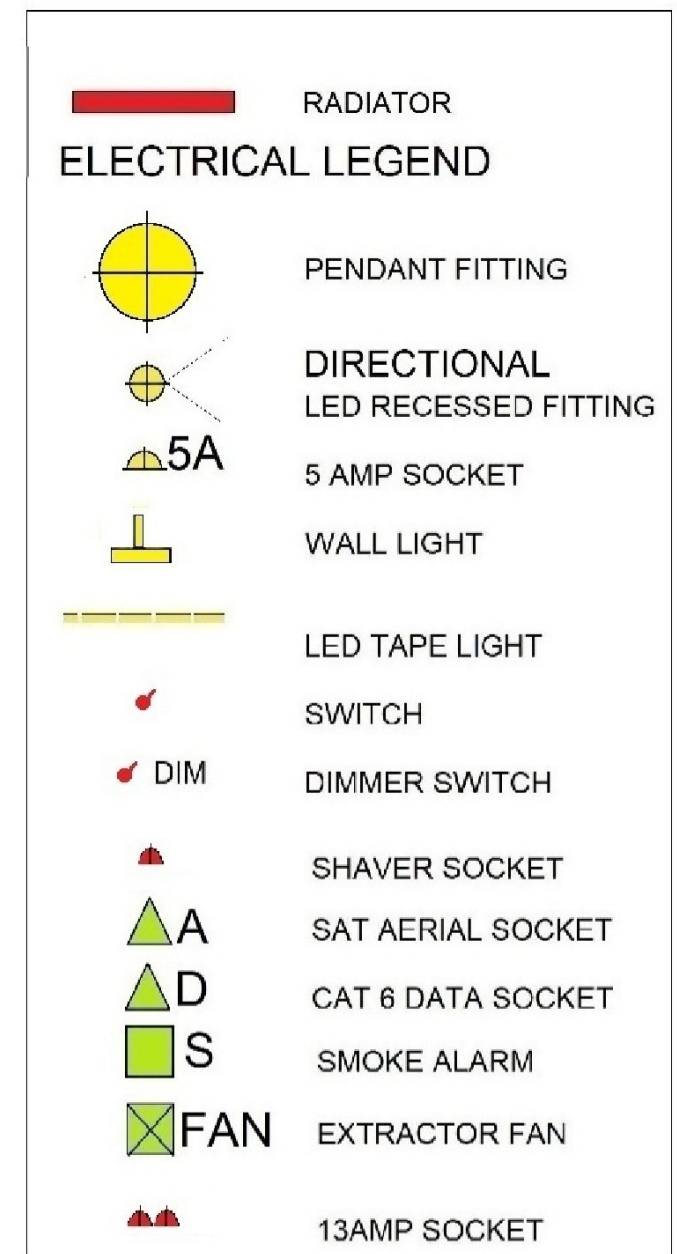

NO CHASING TO WALLS WIRING BEHIND PLASTERBOARD

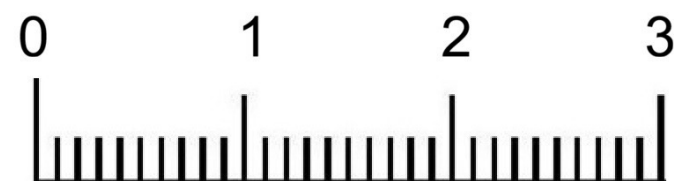

ELECTRICS AND PLUMBING

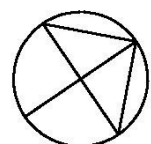

archplan

architects and property management

1 Millfield Place, Highgate, London N6 6JP
Tel: 020 8341 5628 e-mail: archplan@hotmail.com

Date
MAY 25


Drawn by

Checked by

Scale
1:50
At A3


Project
84 HIGHGATE HIGH ST
LONDON N6 5HX
Title **BASEMENT PLAN**

Drawing no
HH/31
Copyright
Archplan 2020

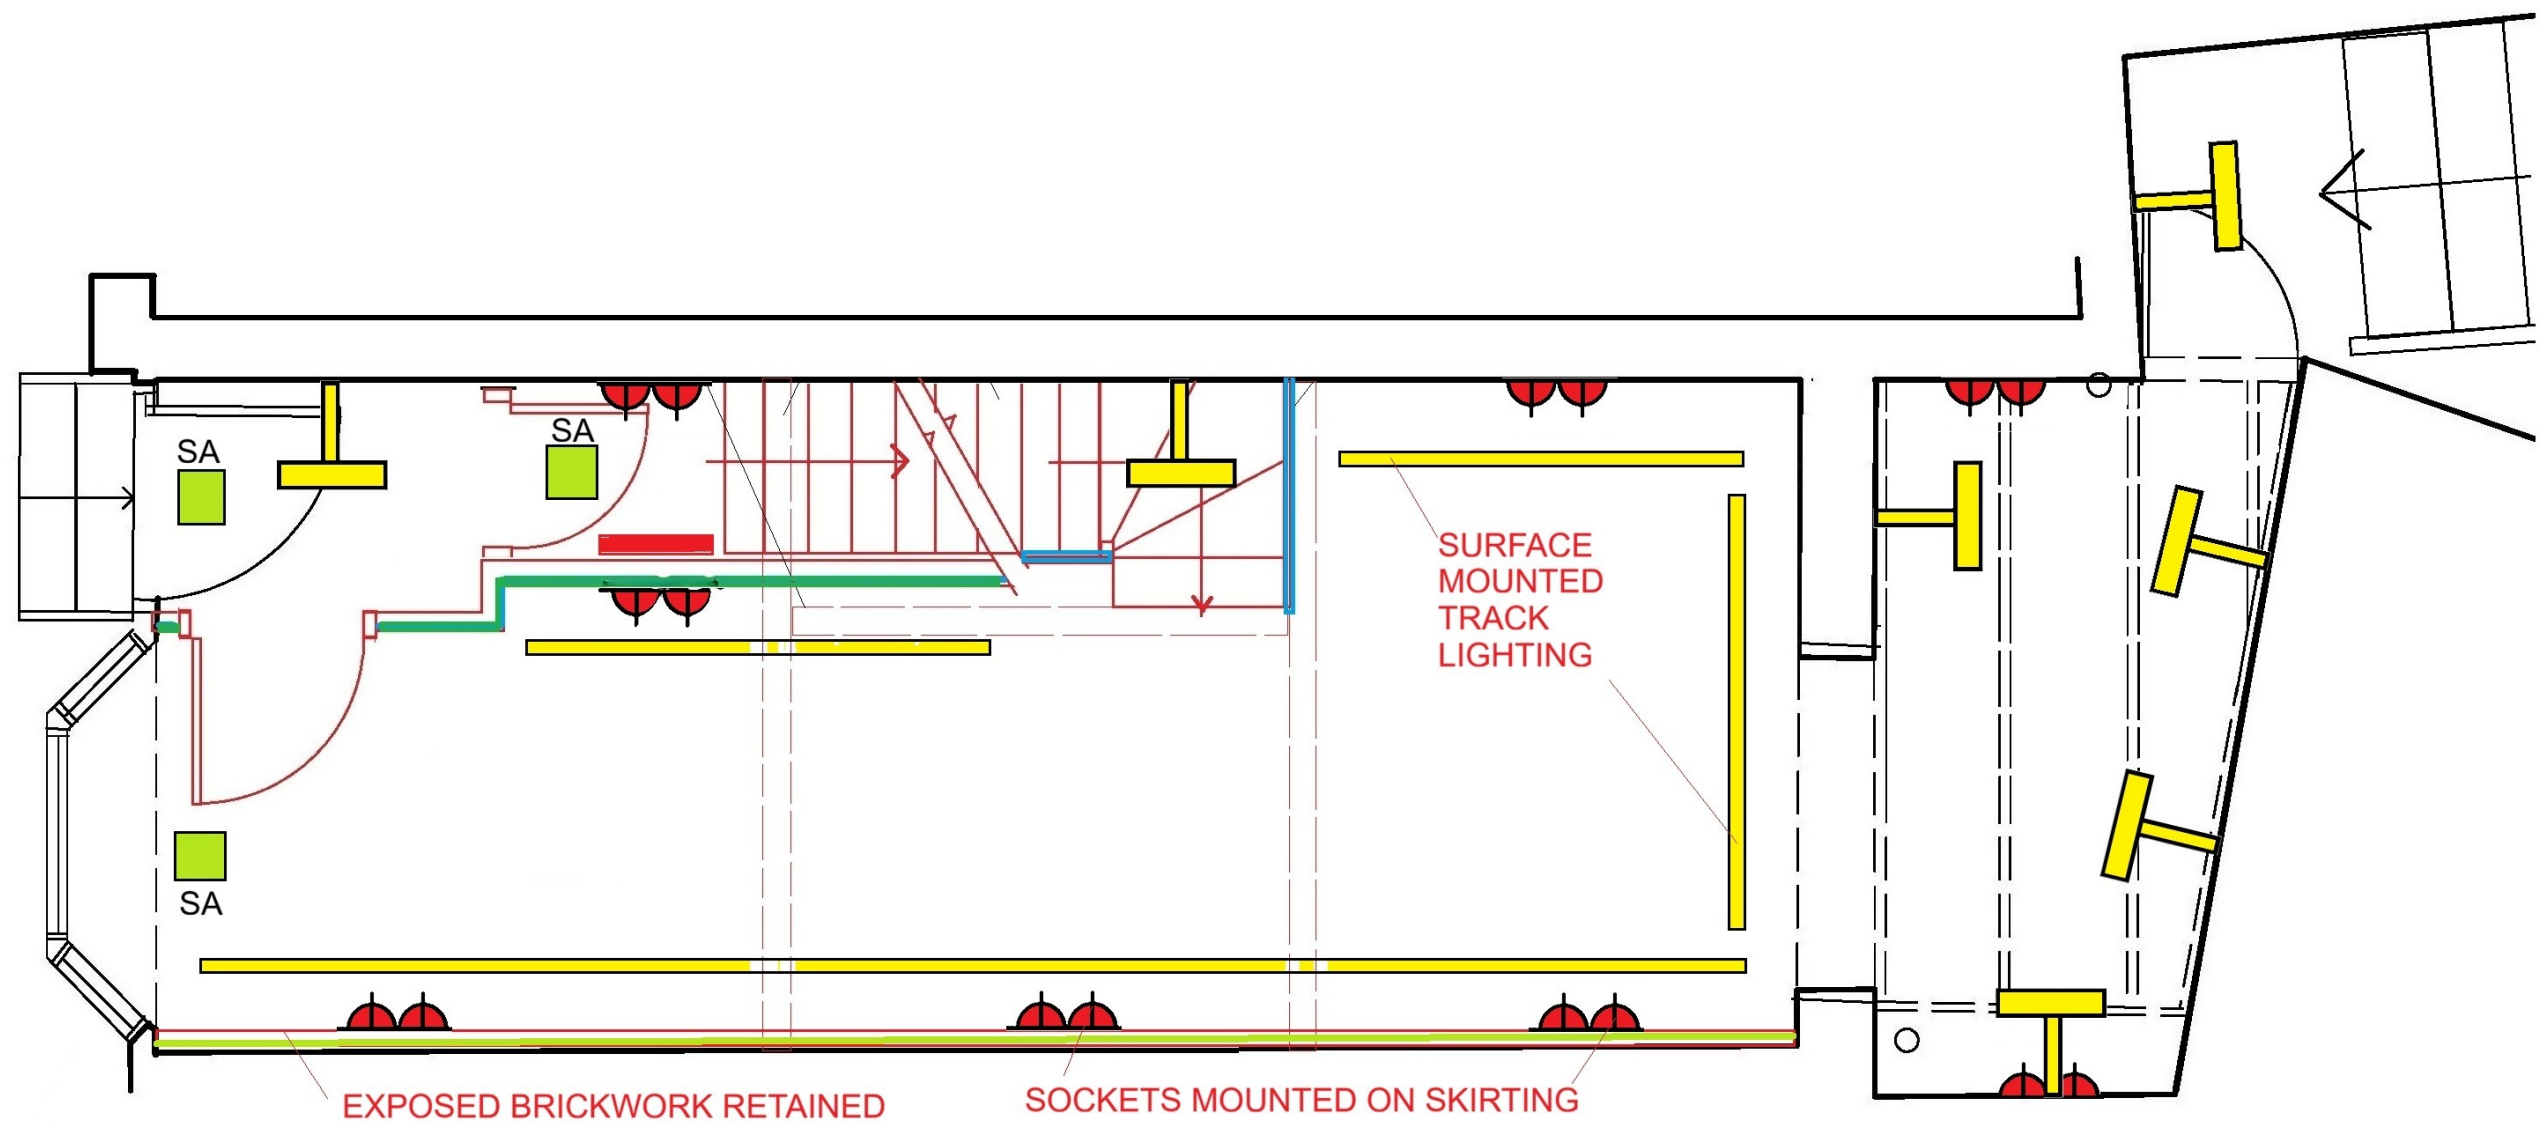

	RADIATOR		SWITCH
ELECTRICAL LEGEND			DIMMER SWITCH
	PENDANT FITTING		SHAVER SOCKET
	DIRECTIONAL LED RECESSED FITTING		SAT AERIAL SOCKET
	5 AMP SOCKET		CAT 6 DATA SOCKET
	WALL LIGHT		SMOKE ALARM
	LED TAPE LIGHT		EXTRACTOR FAN
			13AMP SOCKET

ELECTRICS AND PLUMBING

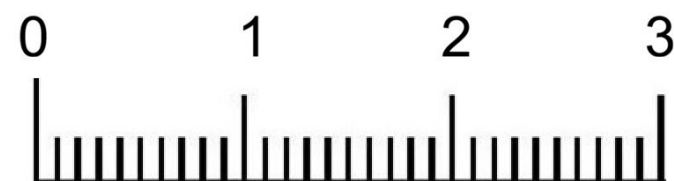

archplan

architects and property management

1 Millfield Place, Highgate, London N6 6JP
Tel: 020 8341 5628 e-mail: archplan@hotmail.com

Date
MAY 25

Drawn by



Checked by

Scale
1:50
At A3


Project
84 HIGHGATE HIGH ST
LONDON N6 5HX
Title **GROUND FL PLAN**

Drawing no
HH/ 32

Copyright
Archplan 2020

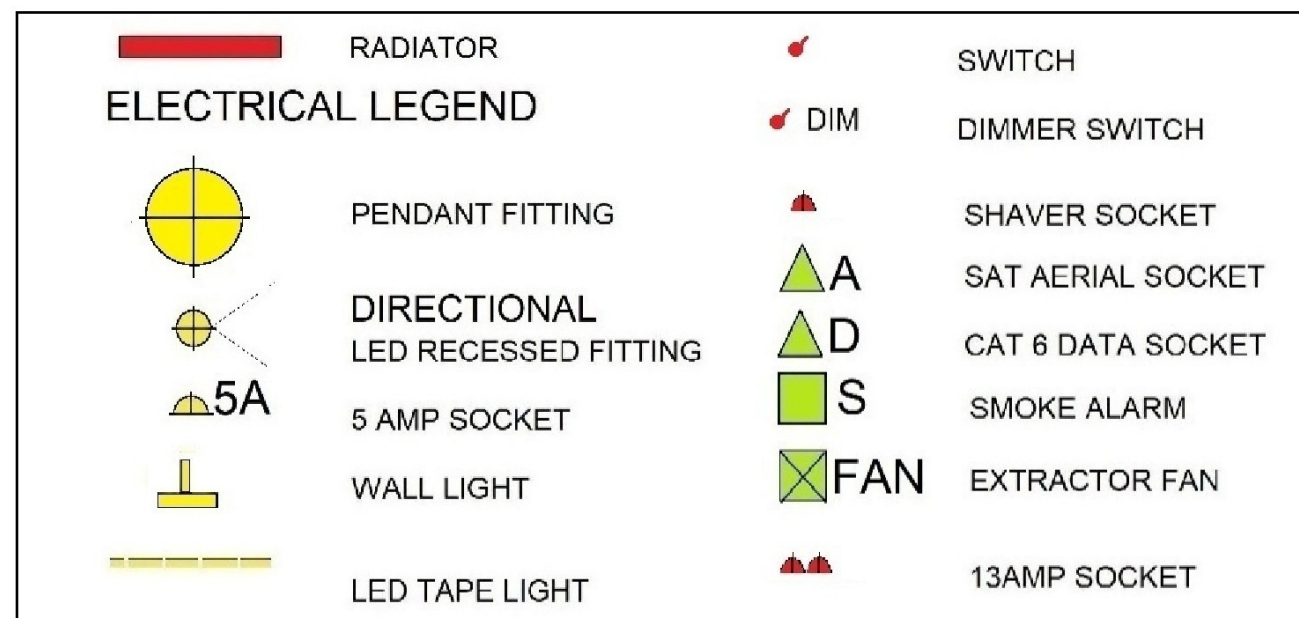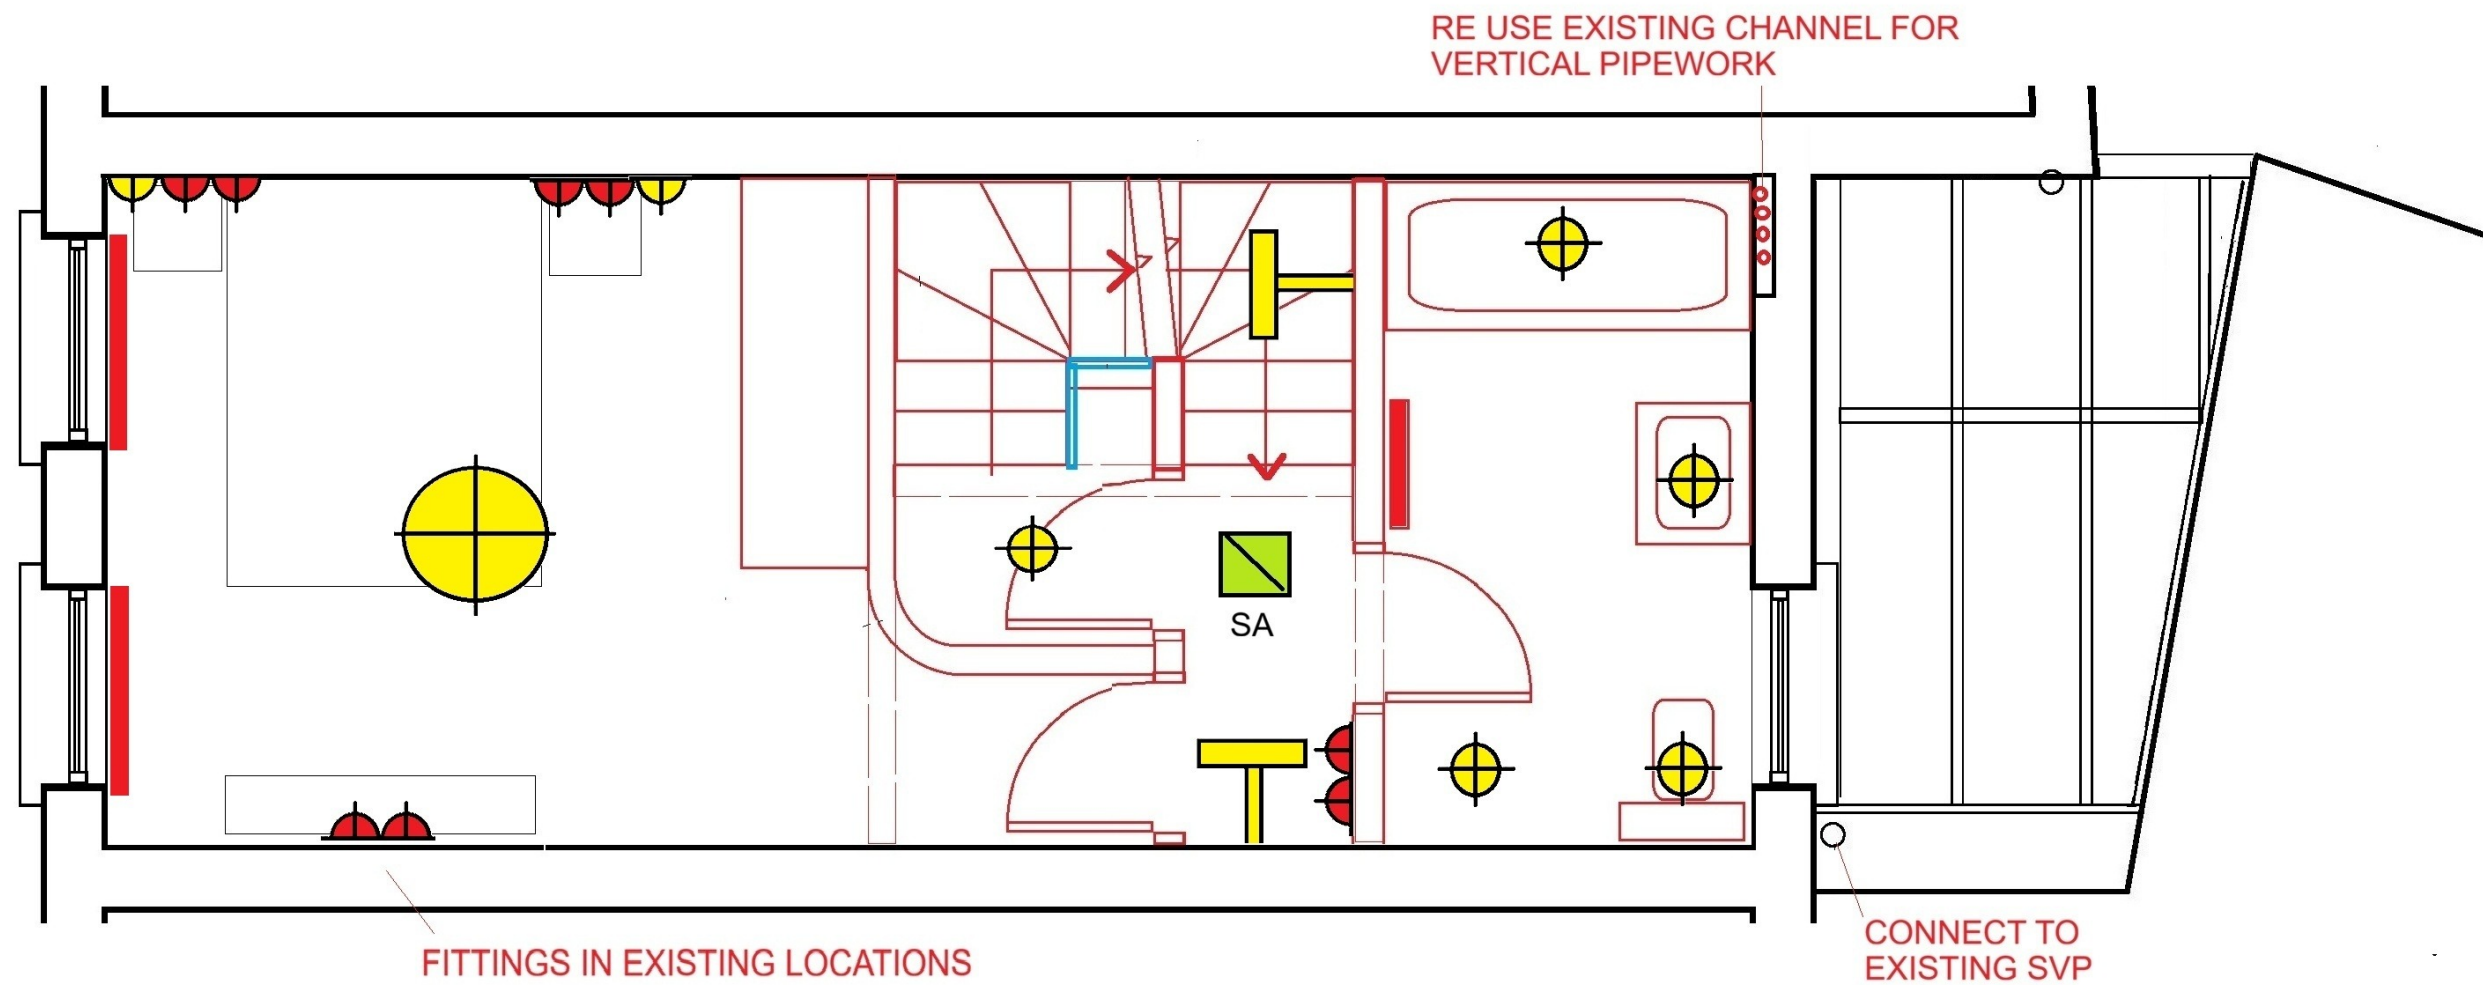

ELECTRICS AND PLUMBING

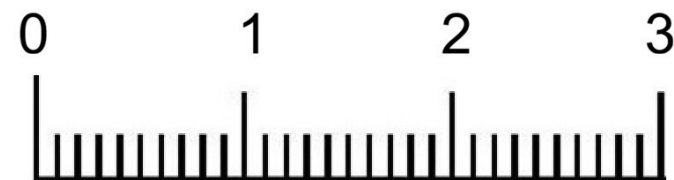

archplan

architects and property management

1 Millfield Place, Highgate, London N6 6JP
Tel: 020 8341 5628 e-mail: archplan@hotmail.com

Date
MAY 25

Drawn by

Checked by

Scale
1:50
At A3

Project
84 HIGHGATE HIGH ST
LONDON N6 5HX
Title
FIRST FLOOR PLAN

Drawing no
HH/33

Copyright
Archplan 2020

