



FOR CONTINUATION PLEASE REFER TO DRAWING 28744/06021

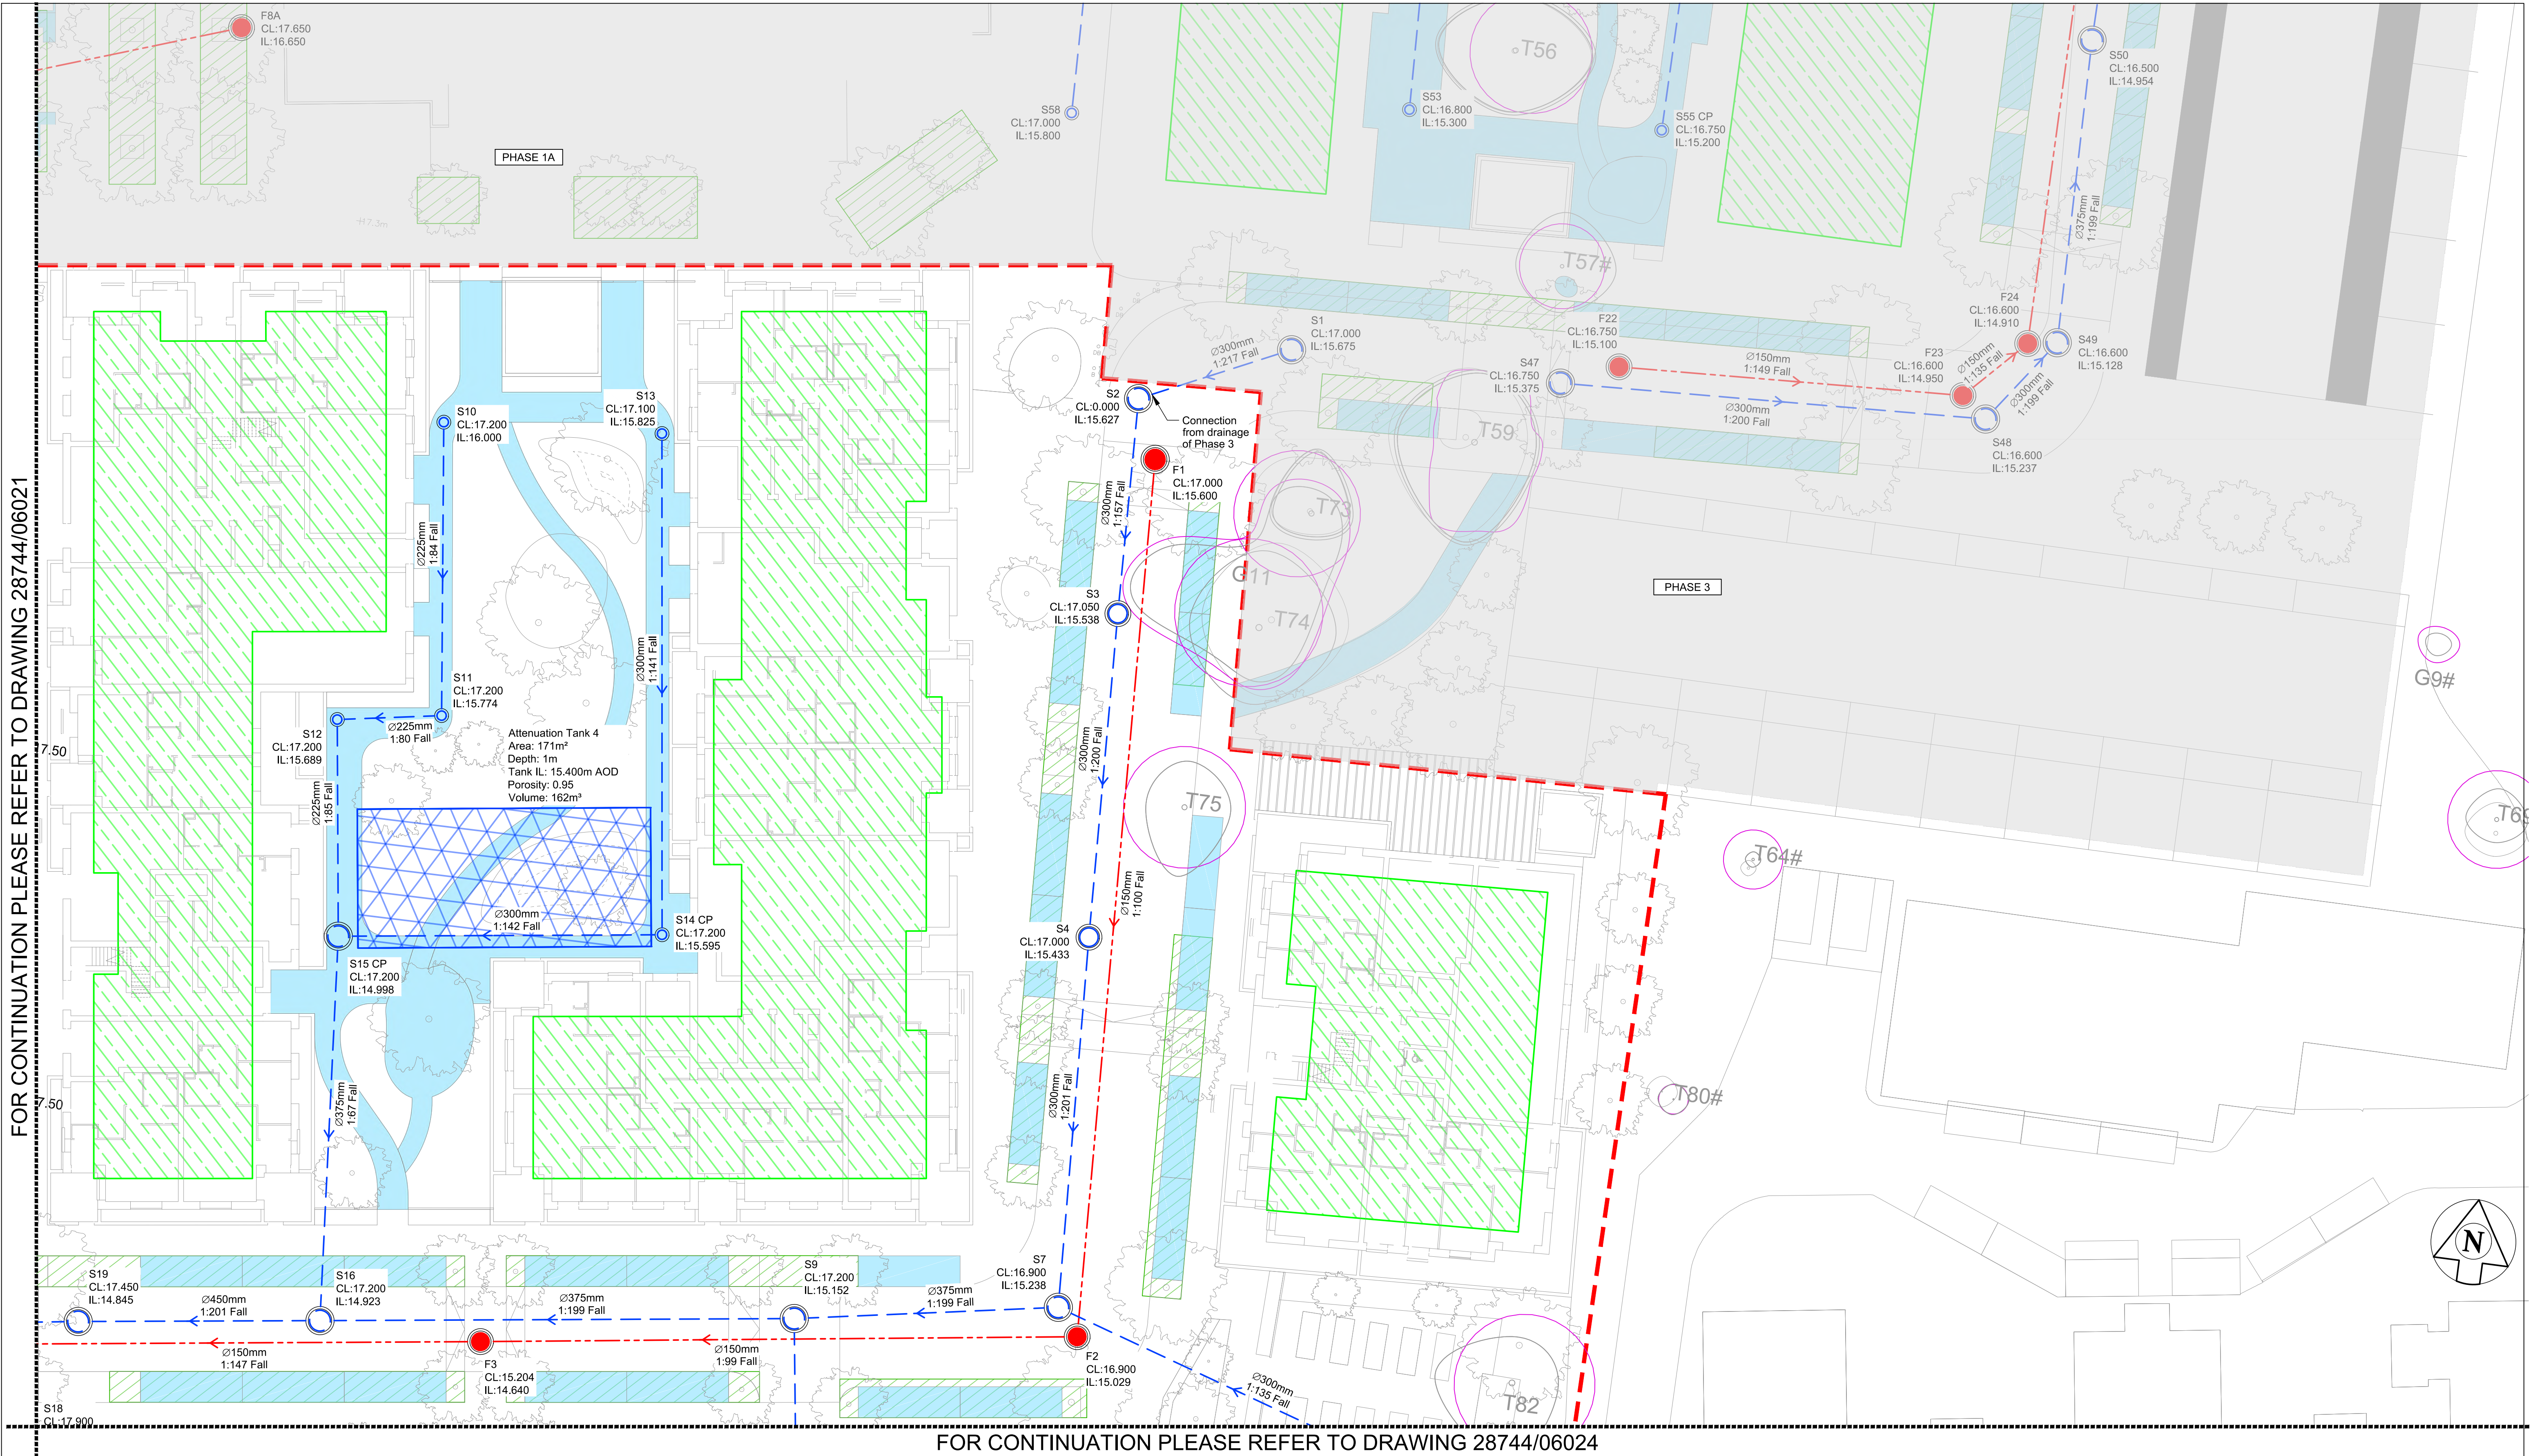

FOR CONTINUATION PLEASE REFER TO DRAWING 28744/06024

NOTES :

- This drawing is to be read in conjunction with all relevant Architect's, Engineer's and specialists' drawings and specifications.
- Do not scale from this drawing in either paper or digital form. Use written dimensions only. To check that this drawing has been printed to the intended scale this bar should be 50mm long @ A1 or 25mm long @ A3.
- Health & Safety : All specific drawing notes are to be read in conjunction with the project "Information Pack" and "Site Rules".
- For general notes refer to Drawing No. N15301-PAM-ZZ-ZZ-DR-S-00001.

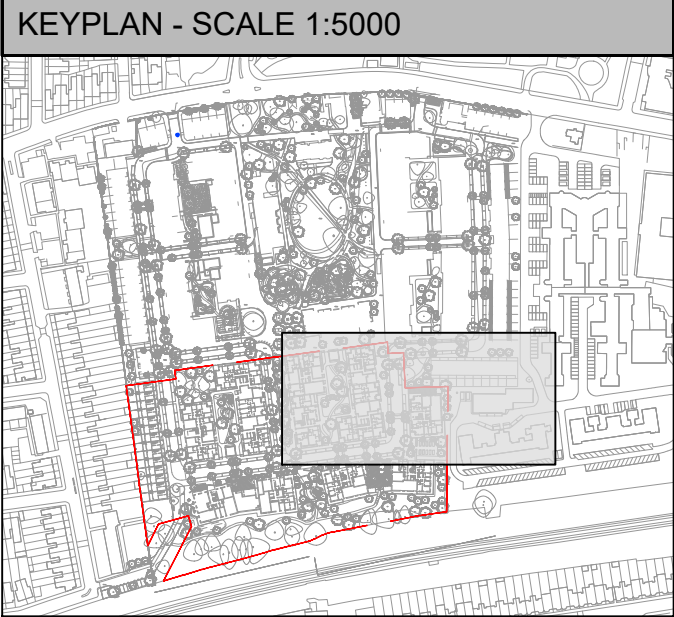

DRAINAGE LEGEND	
Detailed Application Boundary	—
Outline Application Boundary	- - -
New FW Drain	—>
New SW Drain	—>
New Perforated Pipe	—>
Existing SW Drain	—>
Existing FW Drain	—>
Existing SW Sewer	—>
Existing FW Sewer	—>
Tree Root Protection Zones	○

DRAINAGE KEY	
S1	Surface Water Manhole Chamber
F1	Foul Water Manhole Chamber
FCMH1	Flow Control Chamber (SW only)
	Headwall
RG	Road Gully

DRAINAGE KEY	
	Storage or Attenuation Cells
	Permeable paving
	Detention basin
	Bioretention tree pits
	Green Roofs

P02	28.07.23	DLa	TS	Stage 2 Issue
P01	11.05.23	DLa	TS	Stage 2 Issue
Rev	Date	Drawn	Eng	Amendment

ST ANN'S HOSPITAL SITE

PHASE 2 NORTH
BELOW GROUND
DRAINAGE LAYOUT

Status
S3 - REVIEW & COMMENT
NOT FOR CONSTRUCTION

Drawn	DLa	Eng	TS
Scales	1:200 at A1	1:400 at A3	
Drawing No	28744/06022	Rev	P02
Doc Ref.	N15302-PAM-ZZ-00-DR-C-06022		

PRICE & MYERS

Consulting Engineers
37 Alfred Place
London
WC1E 7DP
020 7631 5128
mail@pricemyers.com
www.pricemyers.com