



FOR CONTINUATION PLEASE REFER TO DRAWING 28744/06021

FOR CONTINUATION PLEASE REFER TO DRAWING 28744/06024

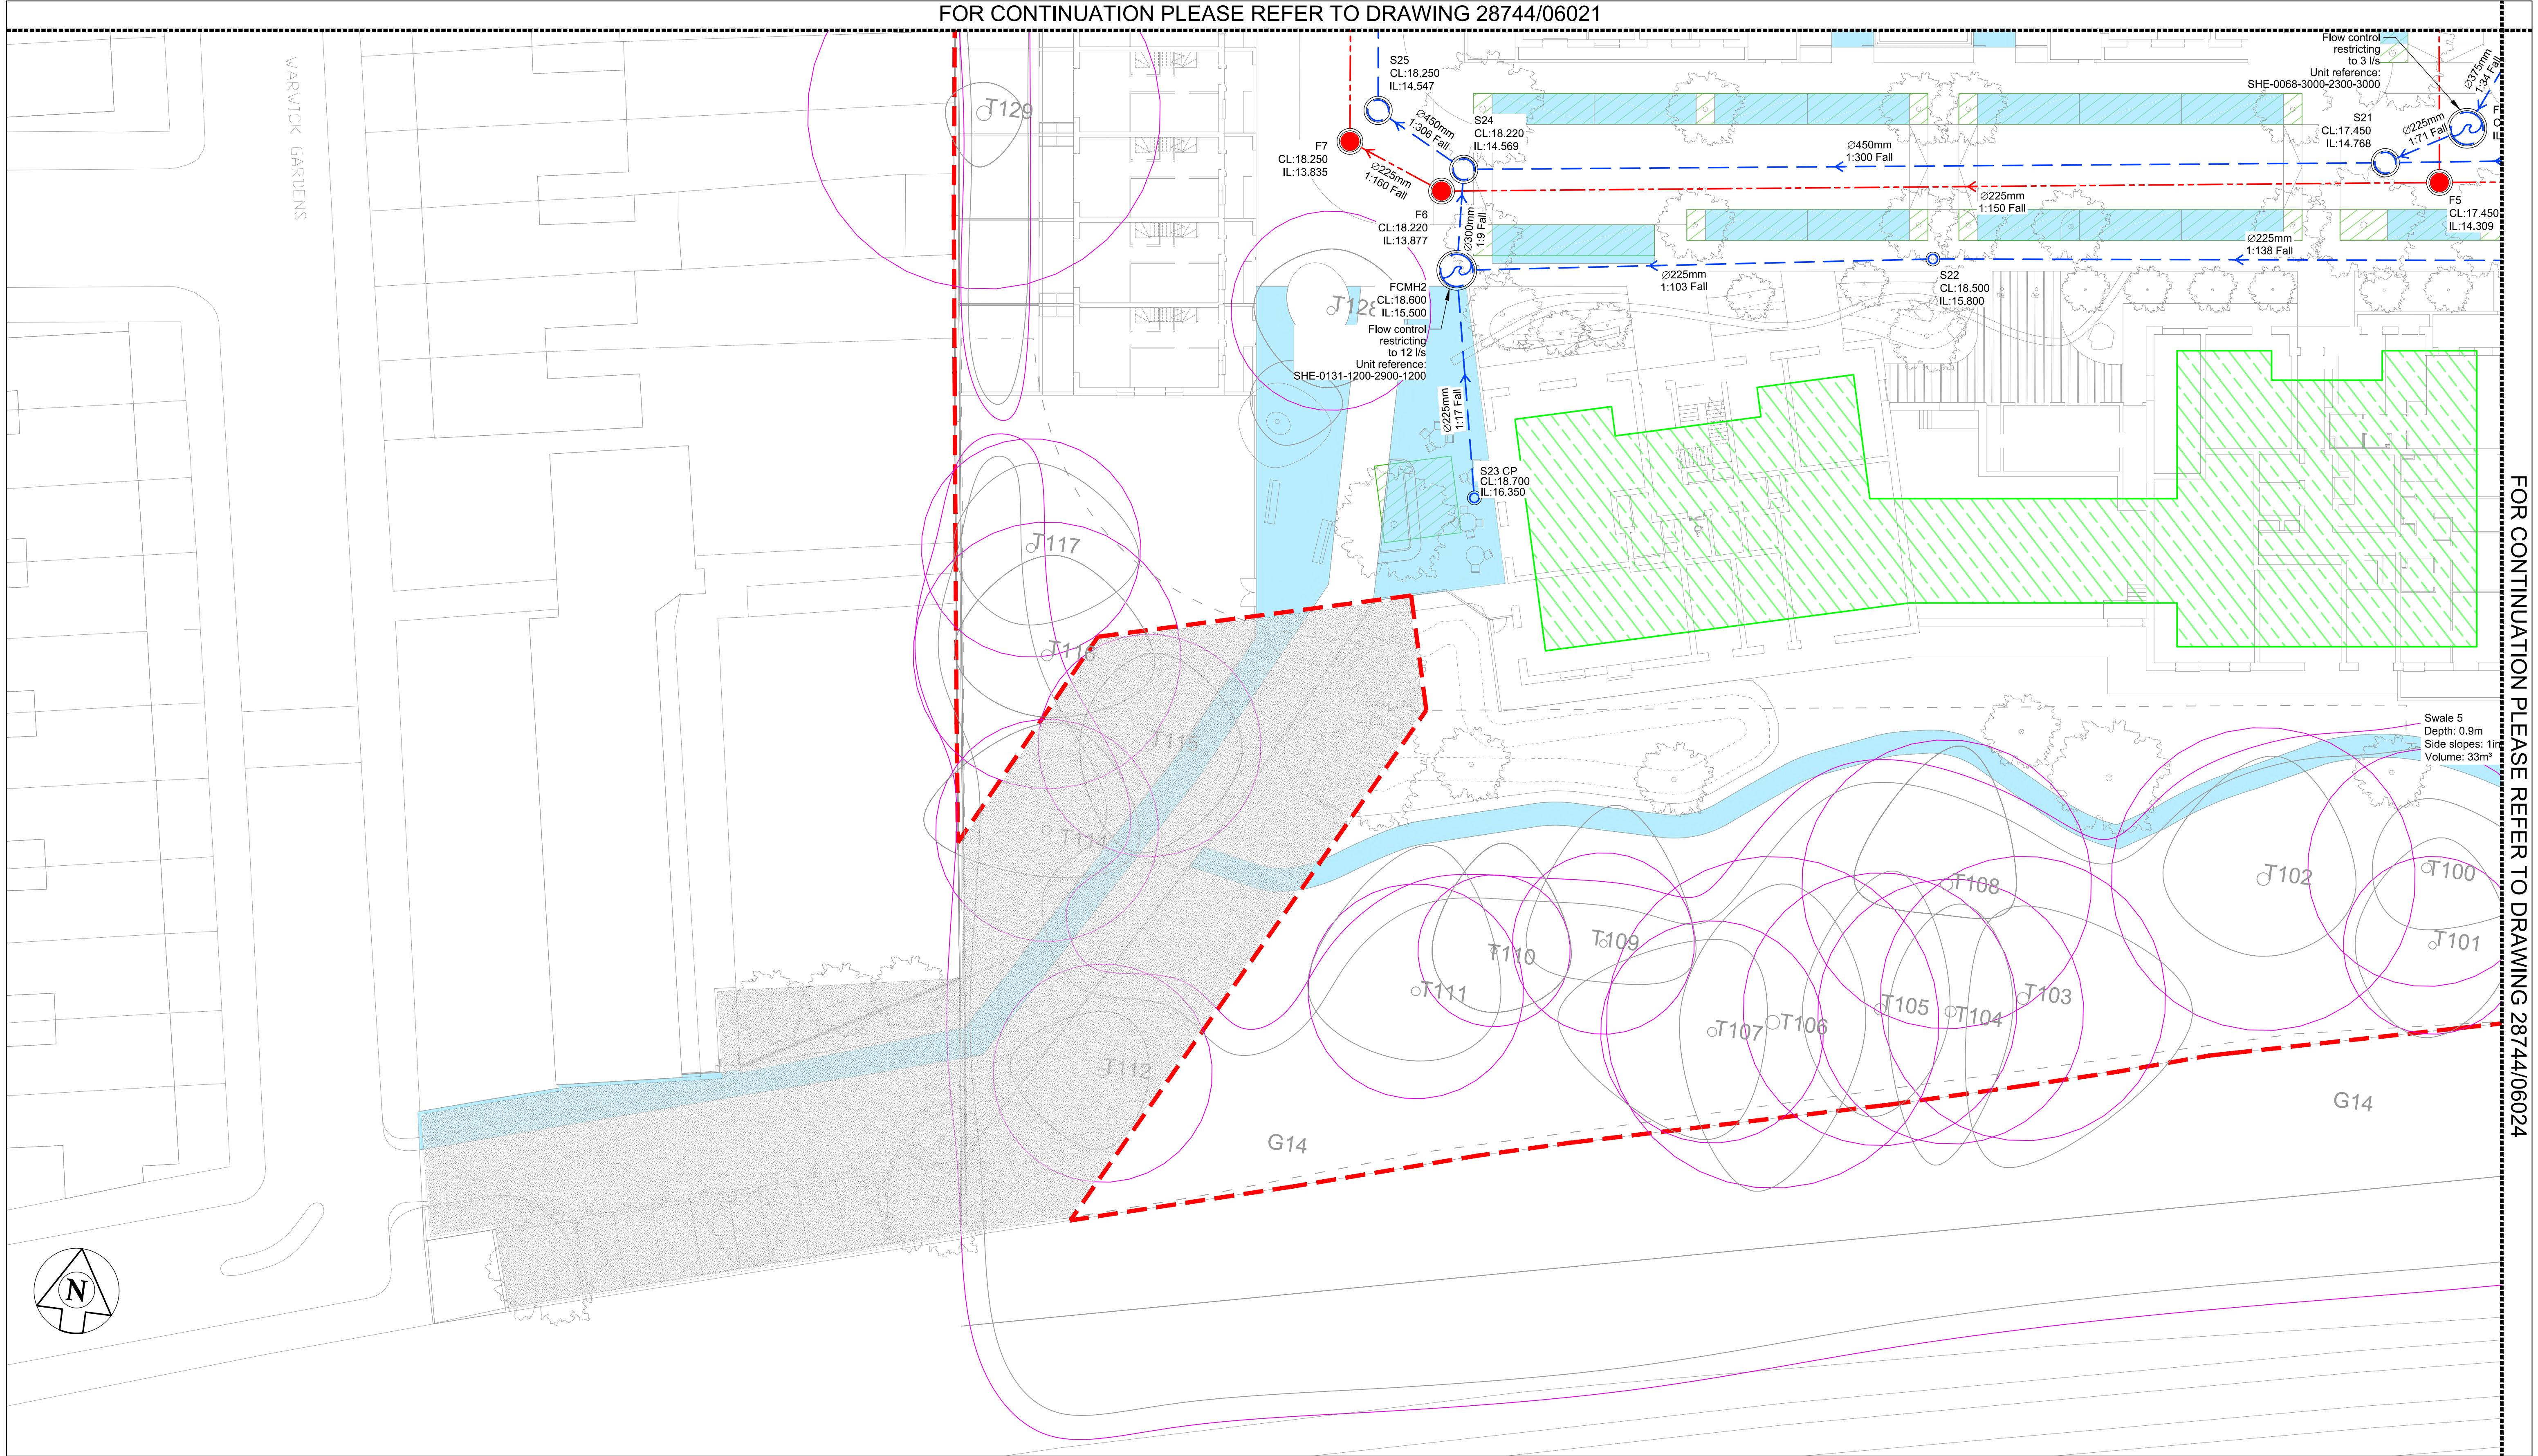

- NOTES :
- This drawing is to be read in conjunction with all relevant Architect's, Engineer's and specialists' drawings and specifications.
 - Do not scale from this drawing in either paper or digital form. Use written dimensions only. To check that this drawing has been printed to the intended scale this bar should be 50mm long @ A1 or 25mm long @ A3.
 - Health & Safety : All specific drawing notes are to be read in conjunction with the project "Information Pack" and "Site Rules".
 - For general notes refer to Drawing No. N15301-PAM-ZZ-ZZ-DR-S-00001.

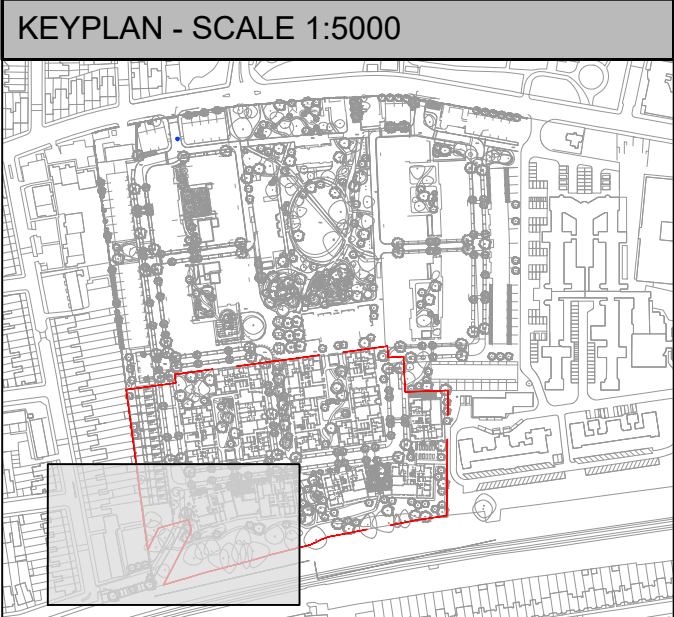

DRAINAGE LEGEND	
Detailed Application Boundary	Red dashed line
Outline Application Boundary	Red dashed line with arrows
New FW Drain	Red dashed line with arrows
New SW Drain	Blue dashed line with arrows
New Perforated Pipe	Blue dashed line with arrows
Existing SW Drain	Blue dashed line
Existing FW Drain	Red dashed line
Existing SW Sewer	Blue dashed line
Existing FW Sewer	Red dashed line
Tree Root Protection Zones	Purple circle

DRAINAGE KEY	
S1	Surface Water Manhole Chamber
F1	Foul Water Manhole Chamber
FCMH1	Flow Control Chamber (SW only)
Headwall	Blue hatched area
RG	Road Gully

DRAINAGE KEY	
Storage or Attenuation Cells	Blue hatched area
Permeable paving	Blue hatched area
Detention basin	Green hatched area
Bioretention tree pits	Green hatched area
Green Roofs	Green hatched area

P02	28.07.23	DLA	TS	Stage 2 Issue
P01	11.05.23	DLA	TS	Stage 2 Issue
Rev	Date	Drawn	Eng	Amendment

ST ANN'S HOSPITAL SITE

PHASE 1B SOUTH
BELOW GROUND
DRAINAGE LAYOUT

Status
S3 - REVIEW & COMMENT
NOT FOR CONSTRUCTION

Drawn	DLA	Eng	TS
Scales	1:200 at A1	1:400 at A3	
Drawing No	28744/06023	Rev	P02
Doc Ref.	N15302-PAM-ZZ-00-DR-C-06023		

PRICE & MYERS

Consulting Engineers
37 Alfred Place
London
WC1E 7DP
020 7631 5128
mail@pricemyers.com
www.pricemyers.com